

This document is made available electronically by the Minnesota Legislative Reference Library as part of an ongoing digital archiving project. <http://www.leg.state.mn.us/lrl/lrl.asp>



OPERATIONS & MAINTENANCE

FACILITY CONSTRUCTION

VOLUME 2B

OMF BUILDING

60% SUBMISSION
DATE : 09/28/15

THE PROPOSED SOUTHWEST LRT PROJECT IS NOT FINAL BUT IS STILL UNDER ENVIRONMENTAL REVIEW AND THE PROJECT IS SUBJECT TO CHANGE. THESE PLANS ARE NOT FINAL.

THE COUNCIL, THROUGH THE DEVELOPMENT OF THESE PLANS, DOES NOT INTEND THAT THEY WILL PREJUDICE OR COMPROMISE ANY STATE OR FEDERAL ENVIRONMENTAL REVIEW OR OTHER LEGAL REQUIREMENTS. THESE PLANS DO NOT LIMIT THE PROJECT DESIGN ALTERNATIVES OR MITIGATIVE MEASURES THAT THE COUNCIL MAY UNDERTAKE IF THE PROPOSED SWLRT PROJECT PROCEEDS TO CONSTRUCTION.

THE COUNCIL WILL NOT TAKE FINAL ACTION ON THIS MATTER UNLESS THE COUNCIL PROCEEDS WITH THE PROJECT AFTER THE FTA'S RECORD OF DECISION AND THE COUNCIL'S DETERMINATION OF ADEQUACY.

WARNING: THIS RECORD MAY CONTAIN SENSITIVE SECURITY INFORMATION THAT IS CONTROLLED UNDER 49 CFR PARTS 15 AND 1520. NO PART OF THIS RECORD MAY BE DISCLOSED TO PERSONS WITHOUT A "NEED TO KNOW", AS DEFINED IN 49 CFR PARTS 15 AND 1520, EXCEPT WITH THE WRITTEN PERMISSION OF THE ADMINISTRATOR OF THE TRANSPORTATION SECURITY ADMINISTRATION OR THE SECRETARY OF TRANSPORTATION. UNAUTHORIZED RELEASE MAY RESULT IN CIVIL PENALTY OR OTHER ACTION. FOR U.S. GOVERNMENT AGENCIES, PUBLIC DISCLOSURE IS GOVERNED BY 5 U.S.C. 552 AND 49 CFR PARTS 15 AND 1520.

AECOM

 
Sep. 24 2015 03:28 pm V:\3400_ADC\CAD\CAD MANAGEMENT\DRAWING_LIST\OMF - GEN - IDX.dwg By: V-KriewoMR

OPERATIONS AND MAINTENANCE FACILITY							OPERATIONS AND MAINTENANCE FACILITY							OPERATIONS AND MAINTENANCE FACILITY									
SHT #	SHEET NAME		SHEET DESCRIPTION		STATION	STATION	REV	SHT #	SHEET NAME		SHEET DESCRIPTION		STATION	STATION	REV	SHT #	SHEET NAME		SHEET DESCRIPTION		STATION	STATION	REV
VOLUME 2B - OMF BUILDING																							
1	OMF-GEN-CVR-003	COVER SHEET						65	OMF-MECH-PLN-M210F	LEVEL ONE - PARTIAL PIPING PLAN AREA F						138	OMF-PLM-PLN-P210	LEVEL ONE OVERALL COMPRESSED AIR FLOOR PLAN					
2	OMF-GEN-IDX-002	VOLUME INDEX OF PLAN SHEETS SHEET 1						66	OMF-MECH-PLN-M210G	LEVEL ONE - PARTIAL PIPING PLAN AREA G						139	OMF-PLM-PLN-P210E	LEVEL ONE - PARTIAL COMPRESSED AIR PLAN AREA E					
3	OMF-GEN-IDX-003	VOLUME INDEX OF PLAN SHEETS SHEET 2						67	OMF-MECH-PLN-M210H	LEVEL ONE - PARTIAL PIPING PLAN AREA H						140	OMF-PLM-PLN-P210F	LEVEL ONE - PARTIAL COMPRESSED AIR PLAN AREA F					
4	OMF-MECH-GEN-M001	GENERAL NOTES & CODE INDEX						68	OMF-MECH-PLN-M210J	LEVEL ONE - PARTIAL PIPING PLAN AREA J						141	OMF-PLM-PLN-P210G	LEVEL ONE - PARTIAL COMPRESSED AIR PLAN AREA G					
5	OMF-MECH-GEN-M002	ABBREVIATIONS						69	OMF-MECH-PLN-M210K	LEVEL ONE - PARTIAL PIPING PLAN AREA K						142	OMF-PLM-PLN-P210H	LEVEL ONE - PARTIAL COMPRESSED AIR PLAN AREA H					
6	OMF-MECH-GEN-M003	STANDARD SYMBOLS AND LEGENDS						70	OMF-MECH-PLN-M210L	LEVEL ONE - PARTIAL PIPING PLAN AREA L						143	OMF-PLM-PLN-P210J	LEVEL ONE - PARTIAL COMPRESSED AIR PLAN AREA J					
7	OMF-MECH-SCH-M004	MECHANICAL SCHEDULES 1						71	OMF-MECH-PLN-M210M	LEVEL ONE - PARTIAL PIPING PLAN AREA M						144	OMF-PLM-PLN-P210K	LEVEL ONE - PARTIAL COMPRESSED AIR PLAN AREA K					
8	OMF-MECH-SCH-M005	MECHANICAL SCHEDULES 2						72	OMF-MECH-PLN-M210N	LEVEL ONE - PARTIAL PIPING PLAN AREA N						145	OMF-PLM-PLN-P210L	LEVEL ONE - PARTIAL COMPRESSED AIR PLAN AREA L					
9	OMF-MECH-SCH-M006	MECHANICAL SCHEDULES 3						73	OMF-MECH-PLN-M215	MEZZANINE LEVEL OVERALL PIPING FLOOR PLAN						146	OMF-PLM-PLN-P210M	LEVEL ONE - PARTIAL COMPRESSED AIR PLAN AREA M					
10	OMF-MECH-SCH-M007	MECHANICAL SCHEDULES 4						74	OMF-MECH-PLN-M215J	MEZZANINE LEVEL - PARTIAL PIPING PLAN AREA J						147	OMF-PLM-PLN-P210N	LEVEL ONE - PARTIAL COMPRESSED AIR PLAN AREA N					
11	OMF-MECH-PLN-M100	UNDERGROUND OVERALL HVAC PLAN						75	OMF-MECH-PLN-M215K	MEZZANINE LEVEL - PARTIAL PIPING PLAN AREA K						148	OMF-PLM-PLN-P215	MEZZANINE LEVEL OVERALL COMPRESSED AIR FLOOR PLAN					
12	OMF-MECH-PLN-M100J	UNDERGROUND - PARTIAL HVAC PLAN AREA J						76	OMF-MECH-PLN-M220	LEVEL TWO OVERALL PIPING FLOOR PLAN													
13	OMF-MECH-PLN-M100K	UNDERGROUND - PARTIAL HVAC PLAN AREA K						77	OMF-MECH-PLN-M220E	LEVEL TWO - PARTIAL PIPING PLAN AREA E						149	OMF-PLM-PLN-P215J	MEZZANINE LEVEL - PARTIAL COMPRESSED AIR PLAN AREA J					
14	OMF-MECH-PLN-M110	LEVEL ONE OVERALL HVAC FLOOR PLAN						78	OMF-MECH-PLN-M220F	LEVEL TWO - PARTIAL PIPING PLAN AREA F													
15	OMF-MECH-PLN-M110A	LEVEL ONE - PARTIAL HVAC PLAN AREA A						79	OMF-MECH-PLN-M220G	LEVEL TWO - PARTIAL PIPING PLAN AREA G						150	OMF-PLM-PLN-P215K	MEZZANINE LEVEL - PARTIAL COMPRESSED AIR PLAN AREA K					
16	OMF-MECH-PLN-M110B	LEVEL ONE - PARTIAL HVAC PLAN AREA B						80	OMF-MECH-PLN-M220H	LEVEL TWO - PARTIAL PIPING PLAN AREA H													
17	OMF-MECH-PLN-M110C	LEVEL ONE - PARTIAL HVAC PLAN AREA C						81	OMF-MECH-PLN-M500	ENLARGED MECHANICAL PLANS 1						151	OMF-PLM-PLN-P500	ENLARGED PLUMBING PLANS 1					
18	OMF-MECH-PLN-M110D	LEVEL ONE - PARTIAL HVAC PLAN AREA D						82	OMF-MECH-PLN-M501	ENLARGED MECHANICAL PLANS 2						152	OMF-PLM-PLN-P501	ENLARGED PLUMBING PLANS 2					
19	OMF-MECH-PLN-M110E	LEVEL ONE - PARTIAL HVAC PLAN AREA E						83	OMF-PLM-GEN-P001	GENERAL NOTES & CODE INDEX						153	OMF-PLM-PLN-P502	ENLARGED PLUMBING PLANS 3					
20	OMF-MECH-PLN-M110F	LEVEL ONE - PARTIAL HVAC PLAN AREA F						84	OMF-PLM-GEN-P002	ABBREVIATIONS						154	OMF-FP-PLN-FP-110	FIRE PROTECTION LEVEL ONE OVERALL PLAN					
21	OMF-MECH-PLN-M110G	LEVEL ONE - PARTIAL HVAC PLAN AREA G						85	OMF-PLM-GEN-P003	STANDARD SYMBOLS AND LEGENDS						155	OMF-FP-PLN-FP-115	FIRE PROTECTION MEZZANINE LEVEL OVERALL PLAN					
22	OMF-MECH-PLN-M110H	LEVEL ONE - PARTIAL HVAC PLAN AREA H						86	OMF-PLM-SCH-P004	PLUMBING SCHEDULES						156	OMF-FP-PLN-FP-120	FIRE PROTECTION LEVEL TWO OVERALL PLAN					
23	OMF-MECH-PLN-M110J	LEVEL ONE - PARTIAL HVAC PLAN AREA J						87	OMF-PLM-PLN-P100	UNDERGROUND OVERALL PLUMBING PLAN						157	OMF-FP-SCT-FP-600	FIRE PROTECTION SECTIONS AND DETAILS					
24	OMF-MECH-PLN-M110K	LEVEL ONE - PARTIAL HVAC PLAN AREA K						88	OMF-PLM-PLN-P100A	UNDERGROUND - PARTIAL PLUMBING PLAN AREA A						158	OMF-ELE-GEN-E001	ABBREVIATIONS & INDEX					
25	OMF-MECH-PLN-M110L	LEVEL ONE - PARTIAL HVAC PLAN AREA L						89	OMF-PLM-PLN-P100B	UNDERGROUND - PARTIAL PLUMBING PLAN AREA B						159	OMF-ELE-GEN-E002	SYMBOLS (1 OF 2)					
26	OMF-MECH-PLN-M110M	LEVEL ONE - PARTIAL HVAC PLAN AREA M						90	OMF-PLM-PLN-P100C	UNDERGROUND - PARTIAL PLUMBING PLAN AREA C						160	OMF-ELE-GEN-E003	SYMBOLS (2 OF 2)					
27	OMF-MECH-PLN-M110N	LEVEL ONE - PARTIAL HVAC PLAN AREA N						91	OMF-PLM-PLN-P100D	UNDERGROUND - PARTIAL PLUMBING PLAN AREA D						161	OMF-ELE-SIT-E051	SITE LIGHTING PLAN					
28	OMF-MECH-PLN-M115	MEZZANINE LEVEL OVERALL HVAC FLOOR PLAN						92	OMF-PLM-PLN-P100E	UNDERGROUND - PARTIAL PLUMBING PLAN AREA E						162	OMF-ELE-PLN-E110A	POWER - LEVEL ONE - AREA A					
29	OMF-MECH-PLN-M115J	MEZZANINE LEVEL - PARTIAL HVAC PLAN AREA J						93	OMF-PLM-PLN-P100F	UNDERGROUND - PARTIAL PLUMBING PLAN AREA F						163	OMF-ELE-PLN-E110B	POWER - LEVEL ONE - AREA B					
30	OMF-MECH-PLN-M115K	MEZZANINE LEVEL - PARTIAL HVAC PLAN AREA K						94	OMF-PLM-PLN-P100G	UNDERGROUND - PARTIAL PLUMBING PLAN AREA G						164	OMF-ELE-PLN-E110C	POWER - LEVEL ONE - AREA C					
31	OMF-MECH-PLN-M120	LEVEL TWO OVERALL HVAC FLOOR PLAN						95	OMF-PLM-PLN-P100H	UNDERGROUND - PARTIAL PLUMBING PLAN AREA H						165	OMF-ELE-PLN-E110D	POWER - LEVEL ONE - AREA D					
32	OMF-MECH-PLN-M120E	LEVEL TWO - PARTIAL HVAC PLAN AREA E						96	OMF-PLM-PLN-P100J	UNDERGROUND - PARTIAL PLUMBING PLAN AREA J						166	OMF-ELE-PLN-E110E	POWER - LEVEL ONE - AREA E					
33	OMF-MECH-PLN-M120F	LEVEL TWO - PARTIAL HVAC PLAN AREA F						97	OMF-PLM-PLN-P100K	UNDERGROUND - PARTIAL PLUMBING PLAN AREA K						167	OMF-ELE-PLN-E110F	POWER - LEVEL ONE - AREA F					
34	OMF-MECH-PLN-M120G	LEVEL TWO - PARTIAL HVAC PLAN AREA G						98	OMF-PLM-PLN-P100L	UNDERGROUND - PARTIAL PLUMBING PLAN AREA L						168	OMF-ELE-PLN-E110G	POWER - LEVEL ONE - AREA G					
35	OMF-MECH-PLN-M120H	LEVEL TWO - PARTIAL HVAC PLAN AREA H						99	OMF-PLM-PLN-P100M	UNDERGROUND - PARTIAL PLUMBING PLAN AREA M						169	OMF-ELE-PLN-E110H	POWER - LEVEL ONE - AREA H					
36	OMF-MECH-PLN-M130	ROOF LEVEL OVERALL HVAC AND PIPING PLAN						100	OMF-PLM-PLN-P100N	UNDERGROUND - PARTIAL PLUMBING PLAN AREA N						170	OMF-ELE-PLN-E110J	POWER - LEVEL ONE - AREA J					
37	OMF-MECH-PLN-M130A	ROOF LEVEL - PARTIAL HVAC AND PIPING PLAN AREA A						101	OMF-PLM-PLN-P110	LEVEL ONE OVERALL PLUMBING FLOOR PLAN						171	OMF-ELE-PLN-E110K	POWER - LEVEL ONE - AREA K					
38	OMF-MECH-PLN-M130B	ROOF LEVEL - PARTIAL HVAC AND PIPING PLAN AREA B						102	OMF-PLM-PLN-P110A	LEVEL ONE - PARTIAL PLUMBING PLAN AREA A						172	OMF-ELE-PLN-E110L	POWER - LEVEL ONE - AREA L					
39	OMF-MECH-PLN-M130C	ROOF LEVEL - PARTIAL HVAC AND PIPING PLAN AREA C						103	OMF-PLM-PLN-P110B	LEVEL ONE - PARTIAL PLUMBINGPLAN AREA B						173	OMF-ELE-PLN-E110M	POWER - LEVEL ONE - AREA M					
40	OMF-MECH-PLN-M130D	ROOF LEVEL - PARTIAL HVAC AND PIPING PLAN AREA D						1															


Sep. 24 2015 03:29 pm v:\3400_ADC\CAD\CAD MANAGEMENT\DRAWING_LIST\OMF-GEN-1DX.dwg By: V-KriewoMR

OPERATIONS AND MAINTENANCE FACILITY						OPERATIONS AND MAINTENANCE FACILITY						OPERATIONS AND MAINTENANCE FACILITY					
SHT #	SHEET NAME	SHEET DESCRIPTION	STATION	STATION	REV	SHT #	SHEET NAME	SHEET DESCRIPTION	STATION	STATION	REV	SHT #	SHEET NAME	SHEET DESCRIPTION	STATION	STATION	REV
VOLUME 2B - OMF BUILDING (cont'd)																	
208	OMF-ELE-PLN-E310J	SYSTEMS - LEVEL ONE - AREA J															
209	OMF-ELE-PLN-E310K	SYSTEMS - LEVEL ONE - AREA K															
210	OMF-ELE-PLN-E310L	SYSTEMS - LEVEL ONE - AREA L															
211	OMF-ELE-PLN-E310M	SYSTEMS - LEVEL ONE - AREA M															
212	OMF-ELE-PLN-E310N	SYSTEMS - LEVEL ONE - AREA N															
213	OMF-ELE-PLN-E320E	SYSTEMS - LEVEL TWO - AREA E															
214	OMF-ELE-PLN-E320F	SYSTEMS - LEVEL TWO - AREA F															
215	OMF-ELE-PLN-E320G	SYSTEMS - LEVEL TWO - AREA G															
216	OMF-ELE-PLN-E320H	SYSTEMS - LEVEL TWO - AREA H															
217	OMF-ELE-PLN-E400A	GROUNDING ELECTRODE PLAN - LEVEL ONE															
218	OMF-ELE-PLN-E400B	GROUNDING ELECTRODE PLAN - LEVEL ONE															
219	OMF-ELE-PLN-E410A	SAFETY GROUNDING SYSTEM - LEVEL ONE - AREA A															
220	OMF-ELE-PLN-E410B	SAFETY GROUNDING SYSTEM - LEVEL ONE - AREA B															
221	OMF-ELE-PLN-E410C	SAFETY GROUNDING SYSTEM - LEVEL ONE - AREA C															
222	OMF-ELE-PLN-E410D	SAFETY GROUNDING SYSTEM - LEVEL ONE - AREA D															
223	OMF-ELE-PLN-E410E	SAFETY GROUNDING SYSTEM - LEVEL ONE - AREA E															
224	OMF-ELE-PLN-E410F	SAFETY GROUNDING SYSTEM - LEVEL ONE - AREA F															
225	OMF-ELE-PLN-E410G	SAFETY GROUNDING SYSTEM - LEVEL ONE - AREA G															
226	NOT USED																
227	OMF-ELE-PLN-E410J	SAFETY GROUNDING SYSTEM - LEVEL ONE - AREA J															
228	OMF-ELE-PLN-E410K	SAFETY GROUNDING SYSTEM - LEVEL ONE - AREA K															
229	OMF-ELE-PLN-E410L	SAFETY GROUNDING SYSTEM - LEVEL ONE - AREA L															
230	OMF-ELE-PLN-E410M	SAFETY GROUNDING SYSTEM - LEVEL ONE - AREA M															
231	OMF-ELE-PLN-E410N	SAFETY GROUNDING SYSTEM - LEVEL ONE - AREA N															
232	OMF-ELE-PLN-E415J	SAFETY GROUNDING SYSTEM - MEZZANINE LEVEL - AREA J															
233	OMF-ELE-PLN-E415K	SAFETY GROUNDING SYSTEM - MEZZANINE LEVEL - AREA K															
234	OMF-ELE-OLD-E501	POWER ONE-LINE DIAGRAMS															
235	OMF-ELE-RSD-E502	POWER ONE-LINE DIAGRAMS															
236	OMF-ELE-RSD-E503	POWER ONE-LINE DIAGRAMS															
237	OMF-ELE-RSD-E504	POWER ONE-LINE DIAGRAMS															
238	OMF-ELE-DTL-E505	ELECTRICAL EQUIPMENT DETAILS															
239	OMF-ELE-DTL-E506	DUCTBANK DETAILS															
240	OMF-ELE-SCH-E801	LUMINAIRE SCHEDULE															
241	OMF-ELE-SCH-E805	INDUSTRIAL EQUIPMENT SCHEDULE															
242	OMF-IND-TYP-I009	INDUSTRIAL GENERAL INFORMATION															
243	OMF-IND-PLN-I110	LEVEL ONE OVERALL FLOOR PLAN															
244	OMF-IND-PLN-I110A	LEVEL ONE ENLARGED PLAN AREA A															
245	OMF-IND-PLN-I110B	LEVEL ONE ENLARGED PLAN AREA B															
246	OMF-IND-PLN-I110C	LEVEL ONE ENLARGED PLAN AREA C															
247	OMF-IND-PLN-I110D	LEVEL ONE ENLARGED PLAN AREA D															
248	OMF-IND-PLN-I110E	LEVEL ONE ENLARGED PLAN AREA E															
249	OMF-IND-PLN-I110F	LEVEL ONE ENLARGED PLAN AREA F															
250	OMF-IND-PLN-I110G	LEVEL ONE ENLARGED PLAN AREA G															
251	OMF-IND-PLN-I110H	LEVEL ONE ENLARGED PLAN AREA H															
252	OMF-IND-PLN-I110I	LEVEL ONE ENLARGED PLAN AREA I															
253	OMF-IND-PLN-I110J	LEVEL ONE ENLARGED PLAN AREA J															
254	OMF-IND-PLN-I110K	LEVEL ONE ENLARGED PLAN AREA K															
255	OMF-IND-PLN-I110L	LEVEL ONE ENLARGED PLAN AREA L															
256	OMF-IND-PLN-I110M	LEVEL ONE ENLARGED PLAN AREA M															
257	OMF-IND-PLN-I110N	LEVEL ONE ENLARGED PLAN AREA N															
258	OMF-IND-PLN-I115	MEZZANINE LEVEL OVERALL FLOOR PLAN															
259	OMF-IND-PLN-I120	MEZZANINE LEVEL ENLARGED PLAN J															
260	OMF-IND-PLN-I121	MEZZANINE LEVEL ENLARGED PLAN K															
261	OMF-IND-PLN-I122	SCREENED STORAGE															
262	OMF-IND-PLN-I123	EQUIPMENT DETAILS															
263	OMF-IND-PLN-I124	EQUIPMENT DETAILS															


PLUMBING/PIPING SYMBOLS




1. PIPE UP
2. PIPE CONNECTION
3. TOP CONNECTION
4. BOTTOM CONNECTION
5. PIPE DROP
6. PIPE RISE
7. SHUT OFF VALVE
8. BALANCING VALVE
9. PIPE BREAK
10. STRAINER
11. STRAINER W/BLOWDOWN VALVE
12. UNION
13. MOTORIZED VALVE - 2 WAY
14. MOTORIZED VALVE - 3 WAY
15. CHECK VALVE
16. DRAIN VALVE
17. FLOW ARROW
18. STEAM TRAP
19. ARROW INDICATES DIRECTION OF PIPE PITCH
20. FLEXIBLE CONNECTION
21. PIPEDUCT CAP
22. PRESSURE AND TEMPERATURE STATION
23. RADIATION ELEMENT
24. TEMPERATURE TRANSMITTER IN PIPE WELL
25. RELIEF VALVE
26. PIPE GUIDE
27. ANCHOR PRESSURE GAGE
28. THERMOMETER
29. AIR VENT
30. VENTURI WATER FLOW MEASURING STATION
31. TURBIN WATER FLOW MEASURING STATION
32. METER
33. EXPANSION COMPENSOR
34. FLOW ALARM
35. INLINE PUMP
36. CONCENTRIC PIPE REDUCER
37. ECCENTRIC PIPE REDUCER (FLAT ON TOP)
38. ECCENTRIC PIPE REDUCER (FLAT ON BOTTOM)
39. PRESSURE ZONE BACKFLOW PREVENTER
40. SOLENOID VALVE
41. SHOCK ABSORBER (SA) (PDI SYMBOL)
42. CLEAN OUT
43. ZONE VALVE BOX (ZVB)
44. ROOM VALVE BOX (RVB)
51. MASTER ALARM PANEL (AAP)
52. AREA ALARM PANEL (AAP)
53. NITROGEN CONTROL CABINET
54. PRESSURE GAUGE

 PLAN TITLE

NEW

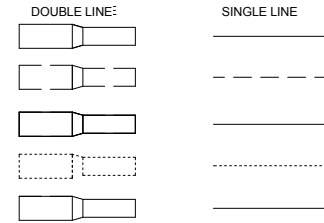

CONNECTION TO EXISTING

 

ITEM INDICATED	DOUBLE LINE DRAWING REPRESENTATION	SINGLE LINE DRAWING REPRESENTATION	ITEM INDICATED	DOUBLE LINE DRAWING REPRESENTATION	SINGLE LINE DRAWING REPRESENTATION
TAKEOFFS IN SUPPLY DUCT			RISE OR DROP IN DIRECTION OF AIR FLOW (ARROW SHOWS DIRECTION OF AIR)		
BRANCH DUCTS			SUPPLY DUCTWORK TURNING UP AND DOWN		
BUTTED TAKEOFF TO REGISTER OR GRILLE W/NO AIR EXTRACTOR			RETURN DUCTWORK TURNING UP AND DOWN		
SUPPLY DIFFUSER RUNOUT			DOUBLE WALL DUCT, PLENUM OR HOUSING WITH 4" THICK INSULATION BETWEEN		
RETURN/EXH. REG OR GRILLE CENTERED IN BOTTOM OF DUCT			DOUBLE WALL DUCT, PLENUM OR HOUSING PERFORATED INTERIOR WALL WITH 4" THICK INSULATION BETWEEN		
DUCT SPLIT USING MITERED ELBOWS W/ TURNING VANES			FLEXIBLE DUCT CONNECTION		
SQUARE ELBOW W/ TURNING VANES			INTERNAL DUCT INSULATION		
ONE SIDED EXPANSION OR CONTRACTION (INDICATE ONLY WHERE MANDATORY)			DAMPER IN HORIZ OR VERTICAL DUCT		
TWO SIDED EXPANSION OR CONTRACTION (INDICATE ONLY WHERE MANDATORY)			▲ FIRE DAMPER △ SMOKE DAMPER △ COMBINATION SMOKE AND FIRE DAMPER △ BACK DRAFT DAMPER △ MOTORIZED DAMPER △ VOLUME DAMPER — HAND DAMPER		
TYPICAL BUTTED TAKEOFF WITH VOLUME DAMPER AND REHEAT COIL			ACCESS PANEL DAMPER SMOKE DETECTOR		
RETURN OR EXHAUST DUCT TAKEOFF			SEE SPECIFICATIONS FOR DEFINITIONS OF DAMPER TYPES		
VERTICAL SPLIT TAKEOFF (PLAN VIEW)					

PT DPT SPT NCR MFC

(1) (2) (3) (4) (5)



1. PRESSURE TRANSMITTER
2. DIFFERENTIAL PRESSURE TRANSMITTER
3. STATIC PRESSURE TRANSMITTER
4. NETWORK CONTROLLER/ROUTER (NCR)
5. MULTIFUNCTION CONTROLLER (MFC)
6. VARIABLE FREQUENCY DRIVE
7. CONTROL PANEL
8. OVERTEMP DETECTOR
9. HEAT DETECTOR
10. SMOKE DETECTOR
11. CARBON MONOXIDE (CO) MONITOR
12. CARBON DIOXIDE (CO₂) MONITOR
13. THERMOSTAT WITH INSULATED SUBBASE
14. TEMPERATURE TRANSMITTER W/ SUBBASE
15. THERMOSTAT
16. TEMPERATURE TRANSMITTER
17. HUMIDISTAT
18. HUMIDITY TRANSMITTER
19. DIFFERENTIAL PRESSURE MONITOR

[illegible]

METROPOLITAN
COUNCIL



STANDARD SYMBOLS AND LEGENDS

DISCIPLINE:

MECHANICAL

SHEET NAME:

OMF-MECH-GEN

M-003

53

9/21/2015 11:29:02 AM C:\Users\lisa\Documents\OMF_Mech_lisa.rvt

FAN SCHEDULE														
UNIT ID	LOCATION	AREA SERVED	CAPACITY (CFM)	STATIC PRESSURE (IN W.G.)	FAN RPM	FAN TYPE	HP	VOLTAGE	PHASE	RPM	BHP	VFD	REMARKS	
EF 1	LRV STORAGE ROOF	LRV STORAGE	4,850	0.25	419	CENTRIFUGAL	1	460 V	3	1725	0	NO	BASED ON GREENHECK GB-360	
EF 2	LRV STORAGE ROOF	LRV STORAGE	4,850	0.25	419	CENTRIFUGAL	1	460 V	3	1725	0	NO	BASED ON GREENHECK GB-360	
EF 3	LRV STORAGE ROOF	LRV STORAGE	4,850	0.25	419	CENTRIFUGAL	1	460 V	3	1725	0	NO	BASED ON GREENHECK GB-360	
EF 4	LRV STORAGE ROOF	LRV STORAGE	4,850	0.25	419	CENTRIFUGAL	1	460 V	3	1725	0	NO	BASED ON GREENHECK GB-360	
EF 5	LRV STORAGE ROOF	LRV STORAGE	4,850	0.25	419	CENTRIFUGAL	1	460 V	3	1725	0	NO	BASED ON GREENHECK GB-360	
EF 6	LRV STORAGE ROOF	LRV STORAGE	4,850	0.25	419	CENTRIFUGAL	1	460 V	3	1725	0	NO	BASED ON GREENHECK GB-360	
EF 7	LRV STORAGE ROOF	LRV STORAGE	4,850	0.25	419	CENTRIFUGAL	1	460 V	3	1725	0	NO	BASED ON GREENHECK GB-360	
EF 8	LRV STORAGE ROOF	LRV STORAGE	4,850	0.25	419	CENTRIFUGAL	1	460 V	3	1725	0	NO	BASED ON GREENHECK GB-360	
EF 9	LRV STORAGE ROOF	LRV STORAGE	4,850	0.25	419	CENTRIFUGAL	1	460 V	3	1725	0	NO	BASED ON GREENHECK GB-360	
EF 10	LRV STORAGE ROOF	LRV STORAGE	4,850	0.25	419	CENTRIFUGAL	1	460 V	3	1725	0	NO	BASED ON GREENHECK GB-360	
EF 11	LRV STORAGE ROOF	LRV STORAGE	4,850	0.25	419	CENTRIFUGAL	1	460 V	3	1725	0	NO	BASED ON GREENHECK GB-360	
EF 12	LRV STORAGE ROOF	LRV STORAGE	4,850	0.25	419	CENTRIFUGAL	1	460 V	3	1725	0	NO	BASED ON GREENHECK GB-360	
EF 13	SALLY PORT ROOF	SALLY ROOF	400	0.25	870	CENTRIFUGAL	0	115 V	1	1725	0	NO	BASED ON GREENHECK GB-091-4	
EF 14	STORAGE ROOM ROOF	RESTROOM 129	140	0.25	1665	CENTRIFUGAL	0	115 V	1	1725	0	NO	BASED ON GREENHECK G-060-VG	
EF 15	MAINTENANCE AREA ROOF	2ND FLOOR TOILET & LOCKER ROOM	2,500	0.63	1130	CENTRIFUGAL	1	460 V	3	1725	1	NO	BASED ON GREENHECK GB-161-7	
EF 16	MAINTENANCE AREA ROOF	BREAK ROOM	2,500	1.16	13370	CENTRIFUGAL	1	460 V	3	1725	1	NO	BASED ON GREENHECK GB-161	
EF 17	LRV STORAGE ROOF	SALT TRUCK AREA/COMPACTOR AREA/SYSTEM MAINTENANCE	7,200	0.63	443	CENTRIFUGAL	2	460 V	3	1725	1	NO	BASED ON GREENHECK GB-360-15	
EF 18	SANDING TRACK ROOF	SANDING BAY	9,700	0.25	419	CENTRIFUGAL	2	460 V	3	1725	0	NO	BASED ON GREENHECK GB-360	
EF 19	SANDING TRACK ROOF	SANDING BAY	9,700	0.25	419	CENTRIFUGAL	2	460 V	3	1725	0	NO	BASED ON GREENHECK GB-360	
EF 21	SANDING TRACK ROOF	SANDING BAY	9,700	0.25	419	CENTRIFUGAL	2	460 V	3	1725	0	NO	BASED ON GREENHECK GB-360	
EF 22	SALLY PORT ROOF	SALLY ROOF	400	0.25	870	CENTRIFUGAL	0	115 V	1	1725	0	NO	BASED ON GREENHECK GB-091-4	

GRAVITY ROOF VENTILATOR SCHEDULE												
MARK	LOCATION	TYPE	CFM	DIMENSIONS (IN)			THROAT		STATIC PRESSURE (IN. W.G.)	MINIMUM FREE AREA (S.F.)	REMARKS	
				L	W	H	L	W				
GRV 1	LRV STORAGE ROOM	GRV	9700	3' - 0"	5' - 0"	2' - 6"	36"	60"	0.04	15	BASED ON RUSKIN PH811	
GRV 2	LRV STORAGE ROOM	GRV	9700	3' - 0"	5' - 0"	2' - 6"	36"	60"	0.04	15	BASED ON RUSKIN PH811	
GRV 3	LRV STORAGE ROOM	GRV	9700	3' - 0"	5' - 0"	2' - 6"	36"	60"	0.04	15	BASED ON RUSKIN PH811	
GRV 4	LRV STORAGE ROOM	GRV	9700	3' - 0"	5' - 0"	2' - 6"	36"	60"	0.04	15	BASED ON RUSKIN PH811	
GRV 5	LRV STORAGE ROOM	GRV	9700	3' - 0"	5' - 0"	2' - 6"	36"	60"	0.04	15	BASED ON RUSKIN PH811	
GRV 6	LRV STORAGE ROOM	GRV	9700	3' - 0"	5' - 0"	2' - 6"	36"	60"	0.04	15	BASED ON RUSKIN PH811	
GRV 7	LRV STORAGE ROOM	GRV	9700	4' - 0"	8' - 0"	2' - 6"	48"	96"	0.04	32	BASED ON RUSKIN PH811	
GRV 8	LRV STORAGE ROOM	GRV	9700	4' - 0"	8' - 0"	2' - 6"	48"	96"	0.04	32	BASED ON RUSKIN PH811	
GRV 10		GRV	5000	2' - 6"	4' - 0"	2' - 1"	30"	48"	0.04	10		
GRV 12		GRV	6000	3' - 0"	5' - 0"	2' - 6"	36"	60"	0.04	15	BASED ON RUSKIN PH811	
GRV 13		GRV	6000	3' - 0"	5' - 0"	2' - 6"	36"	60"	0.04	15	BASED ON RUSKIN PH811	
GRV 14		GRV	6000	3' - 0"	5' - 0"	2' - 6"	36"	60"	0.04	15	BASED ON RUSKIN PH811	
GRV 15		GRV	6000	3' - 0"	5' - 0"	2' - 6"	36"	60"	0.04	15	BASED ON RUSKIN PH811	
GRV 15		GRV	5000	2' - 0"	2' - 0"	2' - 1"	24"	24"	0.04	4		
GRV 16		GRV	6000	3' - 0"	5' - 0"	2' - 6"	36"	60"	0.04	15	BASED ON RUSKIN PH811	
GRV 17		GRV	6000	3' - 0"	5' - 0"	2' - 6"	36"	60"	0.04	15	BASED ON RUSKIN PH811	
GRV 18		GRV	6000	3' - 0"	5' - 0"	2' - 6"	36"	60"	0.04	15	BASED ON RUSKIN PH811	
GRV 19		GRV	6000	4' - 0"	5' - 0"	2' - 6"	48"	60"	0.04	20		
GRV 20		GRV	6000	4' - 0"	5' - 0"	2' - 6"	48"	60"	0.04	20		
GRV 21		GRV	6000	4' - 0"	5' - 0"	2' - 6"	48"	60"	0.04	20		
GRV 22		GRV	6000	4' - 0"	5' - 0"	2' - 6"	48"	60"	0.04	20		

FAN COIL SCHEDULE																														
WT	LOCATION	AREA SERVED	UNIT TYPE	SUPPLY FAN		COOLING												HEATING								MOTOR		REMARKS	SCHEDULE PARAMETER	
				AIRFLOW (CFM)	E.S.P. (IN. W.G.)	TOTAL CAPACITY (MBH)	SENSIBLE CAPACITY (MBH)	EAT DB (°F)	EAT WB (°F)	LAT DB (°F)	LAT WB (°F)	WATER FLOW	EWT (°F)	LWT (°F)	W.P.D. (FT.)	ROWS	FPI	HEATING CAPACITY (MBH)	EAT (°F)	LAT (°F)	ROWS	FPI	WATER FLOW (GPM)	EWT (°F)	LWT (°F)	W.P.D. (FT.)	HP			RPM
FC 1-1		FABRICATION AREA		1600	0.00			80	-460	-460	-460	0	45	57	5.00	0	0	0.0	-460	-460	0		0	-460	-460	0.00	1			FCU
FC 1-2		GEAR ROOM		1000	0.00			80	-460	-460	-460	0	45	57	5.00	0	0	0.0	-460	-460	0		0	-460	-460	0.00	1			FCU
FC 1-3		GEAR ROOM		250	0.00			80	-460	-460	-460	0	45	57	5.00	0	0	0.0	-460	-460	0		0	-460	-460	0.00	0			FCU
FC 1-4		GEAR ROOM		820	0.00			80	-460	-460	-460	0	45	57	5.00	0	0	0.0	-460	-460	0		0	-460	-460	0.00	0			FCU
FC 1-5		TRACK SHOP		1060	0.00			80	-460	-460	-460	0	45	57	5.00	0	0	0.0	-460	-460	0		0	-460	-460	0.00	1			FCU
FC 1-6		POWER SHOP		1060	0.00			80	-460	-460	-460	0	45	57	5.00	0	0	0.0	-460	-460	0		0	-460	-460	0.00	1			FCU
FC 1-7		SIGNAL SHOP		1060	0.00			80	-460	-460	-460	0	45	57	5.00	0	0	0.0	-460	-460	0		0	-460	-460	0.00	1			FCU
FC 1-8		COMM SHOP		1060	0.00			80	-460	-460	-460	0	45	57	5.00	0	0	0.0	-460	-460	0		0	-460	-460	0.00	1			FCU
FC 1-9		EMR		150	0.00			80	-460	-460	-460	0	45	57	5.00	0	0	0.0	-460	-460	0		0	-460	-460	0.00	0			FCU
FC 1-10		COORIDOR		300	0.00			80	-460	-460	-460	0	45	57	5.00	0	0	0.0	-460	-460	0		0	-460	-460	0.00	0			FCU
FC 1-11		MACHINE SHOP		1080	0.00			80	-460	-460	-460	0	45	57	5.00	0	0	0.0	-460	-460	0		0	-460	-460	0.00	1			FCU
FC 1-12		MACHINE SHOP		1080	0.00			80	-460	-460	-460	0	45	57	5.00	0	0	0.0	-460	-460	0		0	-460	-460	0.00	1			FCU
FC 1-13		TRUCK WASH		600	0.00			80	-460	-460	-460	0	45	57	5.00	0	0	0.0	-460	-460	0		0	-460	-460	0.00	0			FCU
FC 1-14		ELECTRICAL ROOM		1500	0.00	0	0	80	-460	-460	-460	0	45	57	5.00	0	0	0.0	-460	-460	0		0	-460	-460	0.00				
FC 1-15		LOBBY		500	0.00			80	-460	-460	-460	0	45	57	5.00	0	0	0.0	-460	-460	0		0	-460	-460	0.00	0			
FC 1-16		VESTIBULE		275	0.00			80	-460	-460	-460	0	45	57	5.00	0	0	0.0	-460	-460	0		0	-460	-460	0.00	0			FCU
FC 1-17		EMR		300	0.00			80	-460	-460	-460	0	45	57	5.00	0	0	0.0	-460	-460	0		0	-460	-460	0.00	0			FCU
FC 1-18		COMM CLOSET		300	0.00	0	0	80	-460	-460	-460	0	45	57	5.00	0	0	0.0	-460	-460	0		0	-460	-460	0.00				
FC 1-19		ELECTRICAL & COMM ROOM		150	0.00			80	-460	-460	-460	0	45	57	5.00	0	0	0.0	-460	-460	0		0	-460	-460	0.00	0			FCU
FC 1-20		EMERGENCY POWER		600	0.00	0	0	80	-460	-460	-460	0	45	57	5.00	0	0	0.0	-460	-460	0		0	-460	-460	0.00				
FC 1-21		FIRE RISER		450	0.00	0	0	80	-460	-460	-460	0	45	57	5.00	0	0	0.0	-460	-460	0		0	-460	-460	0.00				
FC 1-22		TOOL CRIB		150	0.00			80	-460	-460	-460	0	45	57	5.00	0	0	0.0	-460	-460	0		0	-460	-460	0.00	0			FCU
FC 1-23		GEAR ROOM		150	0.00			80	-460	-460	-460	0	45	57	5.00	0	0	0.0	-460	-460	0		0	-460	-460	0.00	0			FCU
FC 1-24		SW 321		2000	0.00	0	0	80	-460	-460	-460	0	45	57	5.00	0	0	0.0	-460	-460	0		0	-460	-460	0.00				
FC 1-25		COMPRESSOR ROOM		2000	0.00	0	0	80	-460	-460	-460	0	45	57	5.00	0	0	0.0	-460	-460	0		0	-460	-460	0.00				
FC 2-1		ELECTRICAL ROOM		250	0.00	0	0	80	-460	-460	-460	0	45	57	5.00	0	0	0.0	-460	-460	0		0	-460	-460	0.00				
FC 2-2		COMM ROOM		300	0.00	0	0	80	-460	-460	-460	0	45	57	5.00	0	0	0.0	55	72	1		0	-460	160	0.00				
FC 2-3		ELECTRICAL ROOM		300	0.00	0	0	80	-460	-460	-460	0	45	57	5.00	0	0	0.0	55	72	1		0	-460	160	0.00				

[illegible][illegible][illegible][illegible][illegible][illegible]

--

 
60% SUBMISSION - 09/28/15




The footer contains two logos. On the left is the Metropolitan Council logo, featuring a stylized triangle with a diagonal line through it, and the text "METROPOLITAN COUNCIL" below it. On the right is the Southwest logo, featuring the word "SOUTHWEST" in a bold, sans-serif font, with a stylized airplane tail fin to its right.

OPERATIONS & MAINTENANCE FACILITY -V2B MECHANICAL MECHANICAL SCHEDULES 3		
DISCIPLINE: MECHANICAL	SHEET NAME: OMF-MECH-SCH	M-006

BOILER SCHEDULE												
UNIT ID	TYPE	LOCATION	WATER INLET TEMP	WATER OUTLET TEMP	FLUID TYPE	MINIMUM THERMAL EFFICIENCY	FLUE DIA (IN)	FUEL TYPE	INPUT MBH	OUTPUT MBH	REMARKS	
B 1	CONDENSING	3RD FLOOR MECHANICAL ROOM	130 °F	160 °F	40%	90.00%	8"	NATURAL GAS	2000000	1820000	BASED ON AERCO	
B 2	CONDENSING	3RD FLOOR MECHANICAL ROOM	130 °F	160 °F	40%	90.00%	8"	NATURAL GAS	2000000	1820000	BASED ON AERCO	
B 3	CONDENSING	3RD FLOOR MECHANICAL ROOM	130 °F	160 °F	40%	90.00%	8"	NATURAL GAS	2000000	1820000	BASED ON AERCO	
B 4	CONDENSING	3RD FLOOR MECHANICAL ROOM	130 °F	160 °F	40%	90.00%	8"	NATURAL GAS	2000000	1820000	BASED ON AERCO	
B 5	CONDENSING	3RD FLOOR MECHANICAL ROOM	130 °F	160 °F	40%	90.00%	8"	NATURAL GAS	2000000	1820000	BASED ON AERCO	

 	 
60% SUBMISSION - 09/28/15	

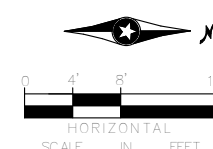

KEY PLAN - SCALE: N.T.S.

[illegible]

60% SUBMISSION - 09/28/15

SHEET
13
OF
263

DISCIPLINE:	SHEET NAME:	
MECHANICAL	OME-MECH-PLN	M-100K

[illegible]

METROPOLITAN COUNCIL



SOUTHWEST

60% SUBMISSION - 09/28/15

OPERATIONS & MAINTENANCE FACILITY -V2B MECHANICAL LEVEL ONE OVERALL HVAC FLOOR PLAN	S
---	---



DISCIPLINE:	SHEET NAME:	
MECHANICAL	OMF-MECH-PLN	M-110

SHEET
14
OF
263

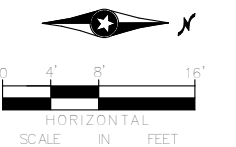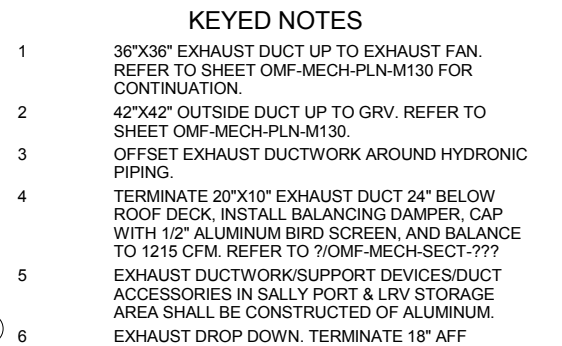

M-110A SCALE: 1/8" = 1'-0"
REF. SHEET: M-603 / REF. DETAIL: 1

DISCIPLINE:	SHEET NAME:	
MECHANICAL	OMF-MECH-PLN	M-110A

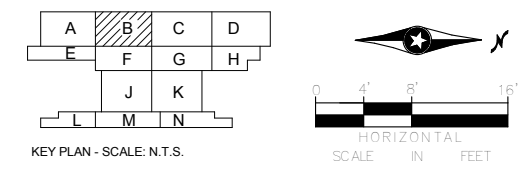
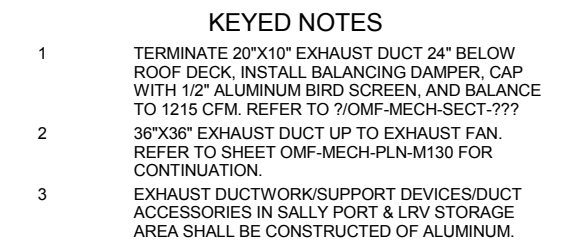
[illegible]

METROPOLITAN COUNCIL

SOUTHWEST

DISCIPLINE:	SHEET NAME:	
MECHANICAL	OMF-MECH-PLN	M-110B

SHEET
16
OF
263

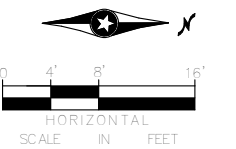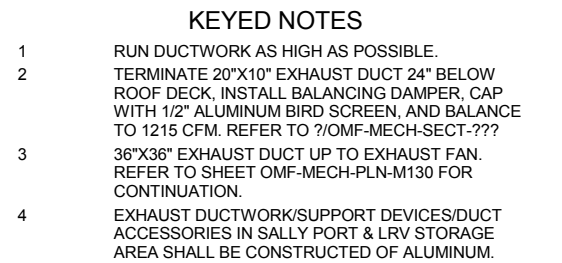



	NO	DATE	BY	CHECK	DESIGN	REVISION / SUBMITTAL
6						
7						
8						
100						



**OPERATIONS & MAINTENANCE FACILITY -V2B
MECHANICAL**

LEVEL ONE - PARTIAL HVAC PLAN AREA C

DISCIPLINE:	SHEET NAME:	
MECHANICAL	OMF-MECH-PLN	M-110C

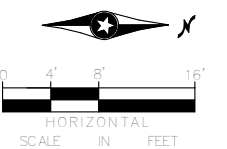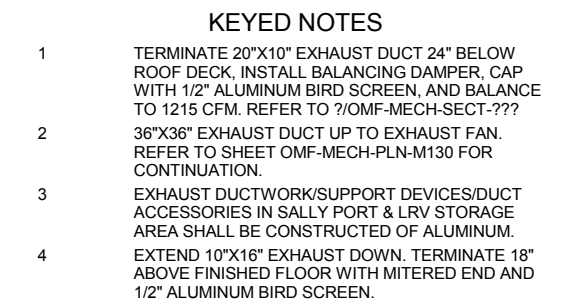

SCALE: 1/8" = 1'-0"
REF. SHEET: M-603 / REF. DETAIL: 1

LV
ENGINEERING • LLC
CERTIFIED WOMEN'S
BUSINESS ENTERPRISE




METROPOLITAN
COUNCIL

SOUTHWEST

SHEET NAME:	
OMF-MECH-PLN	M-110D

 SHEET
18
OF
263




KEY PLAN - SCALE: N.T.S.

The key plan shows a site layout with buildings labeled A through S. Buildings A, B, C, and D are in the top row. Building E is to the left of A. Buildings F, G, and H are in the second row. Buildings J and K are in the third row. Buildings L, M, and N are in the bottom row. To the right of the buildings is a north arrow pointing towards the top right, and a scale bar labeled 'HORIZONTAL' with markings for 0, 4', 8', and 16'.

 	 	OPERATIONS & MAINTENANCE FACILITY -V2B MECHANICAL LEVEL ONE - PARTIAL HVAC PLAN AREA E			SHEET
60% SUBMISSION - 09/28/15		DISCIPLINE: MECHANICAL	SHEET NAME: OMF-MECH-PLN	M-110E	19
					OF
					263


1 RUN DUCTWORK AS HIGH AS POSSIBLE.

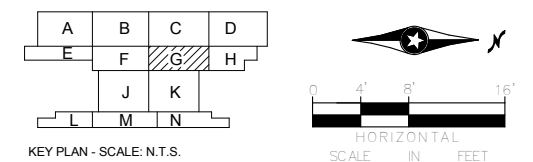[illegible]

LEVEL ONE - PARTIAL HVAC PLAN AREA G

DISCIPLINE:	SHEET NAME:	
MECHANICAL	OMF-MECH-PLN	M-110G

SHEET
21
OF
263

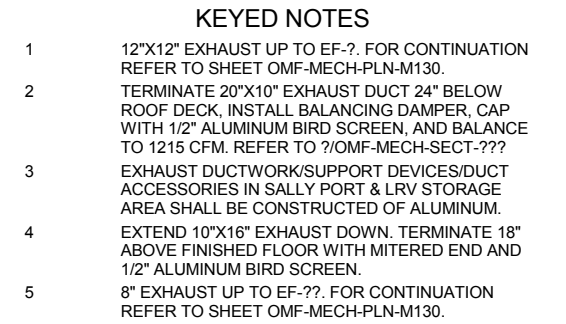



KEY PLAN - SCALE: N.T.S.

The key plan shows a building layout with rooms labeled A through N. Room A is at the top left, B is to its right, C is to the right of B, and D is at the top right. Below A is E, below B is F, below C is G, and below D is H. Below E is L, below F is M, below G is J, and below H is K. Below L is N. A north arrow points towards the top right. A scale bar is shown below the north arrow, with markings for 0, 4', 8', and 16'. The scale is labeled 'SCALE IN FEET' and 'HORIZONTAL'.

[illegible]


DISCIPLINE:	SHEET NAME:	
MECHANICAL	OMF-MECH-PLN	M-110H

SHEET
22
OF
263

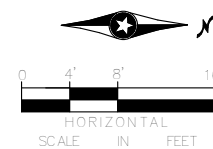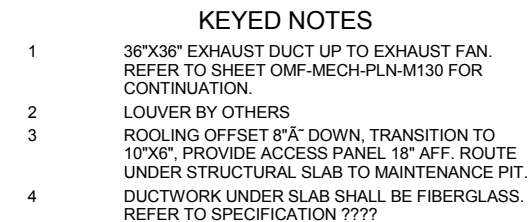


SCALE: 1/8" = 1'-0"

DISCIPLINE:	SHEET NAME:	
MECHANICAL	OMF-MECCH-PLN	M-110J

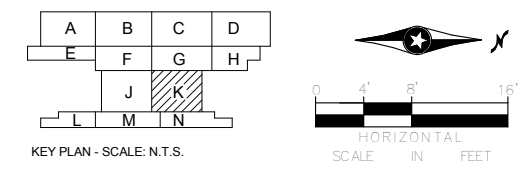


DISCIPLINE:	SHEET NAME:	
MECHANICAL	OMF-MECH-PLN	M-110K

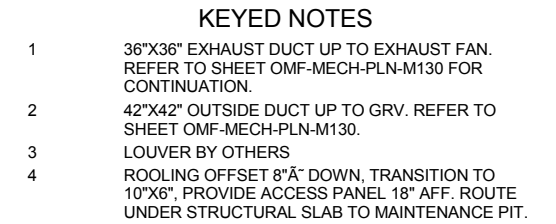


KEY PLAN - SCALE: N.T.S.

 	 	OPERATIONS & MAINTENANCE FACILITY -V2B MECHANICAL LEVEL ONE - PARTIAL HVAC PLAN AREA M			SHEET
60% SUBMISSION - 09/28/15		DISCIPLINE: MECHANICAL	SHEET NAME: OMF-MECH-PLN	M-110M	26
					OF
					263

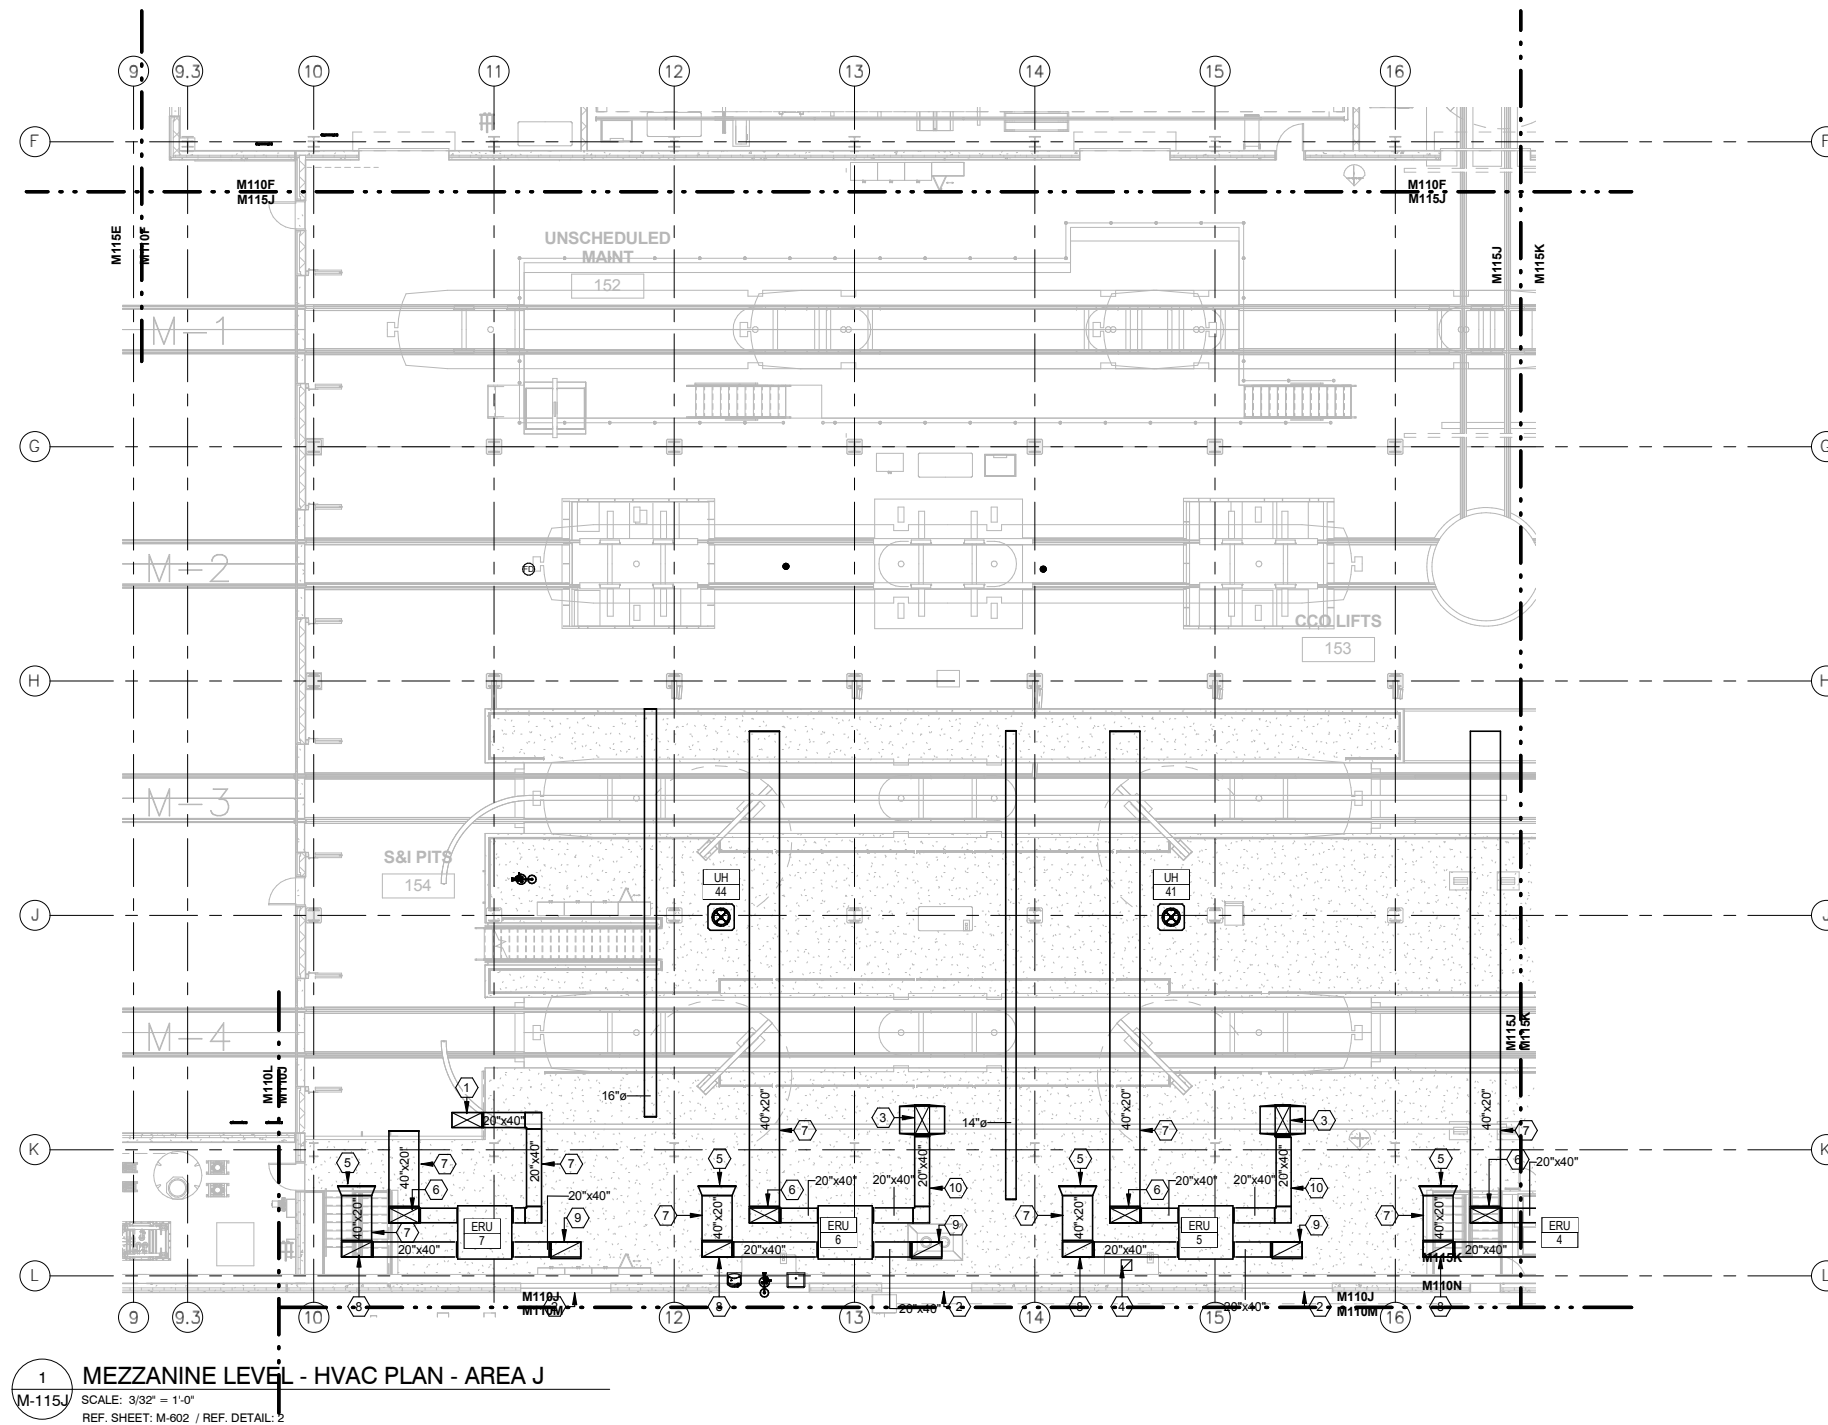

- ## KEYED NOTES
- 1 20"X40" OUTSIDE AIR UP TO GRV. FOR
CONTINUATION REFER TO SHEET
OMF-MECH-PLN-M130.
 - 2 LOUVER BY OTHERS
 - 3 42"X42" OUTSIDE DUCT UP TO GRV. REFER TO
SHEET OMF-MECH-PLN-M130.
 - 4 EXHAUST DUCTWORK DN TO RESTROOM GRILLE
 - 5 50"X26" BELL MOUTH WITH 1/2" STAINLESS STEEL
BIRD SCREEN
 - 6 40"X20" OFFSET SUPPLY DOWN
 - 7 RUN DUCTWORK AS HIGH AS POSSIBLE.
 - 8 40"X20" RETURN OFFSET DOWN
 - 9 40"X20" EXHAUST OFFSET DOWN
 - 10 EXHAUST DROP DOWN. TERMINATE 18" AFF

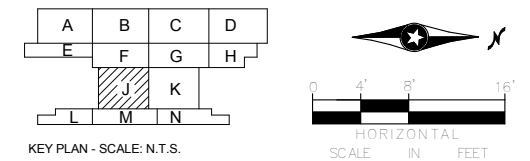[illegible]

AECOM **ENGINEERING • LLC**
CERTIFIED WOMEN'S BUSINESS ENTERPRISE

60% SUBMISSION - 09/28/15





OPERATIONS & MAINTENANCE FACILITY -V2B
MECHANICAL
MEZZANINE LEVEL - PARTIAL HVAC PLAN
AREA J

DISCIPLINE:	SHEET NAME:	
MECHANICAL	OMF-MECH-PLN	M-115J

SHEET
29
OF
263



- ## KEYED NOTES
- | | |
|---|---|
| 1 | 50"X26" BELL MOUTH WITH 1/2" STAINLESS STEEL BIRD SCREEN |
| 2 | 40"X20" OFFSET SUPPLY DOWN |
| 3 | RUN DUCTWORK AS HIGH AS POSSIBLE. |
| 4 | 40"X20" RETURN OFFSET DOWN |
| 5 | 42"X42" OUTSIDE DUCT UP TO GRV. REFER TO SHEET OMF-MECH-PLN-M130. |
| 6 | EXHAUST DROP DOWN. TERMINATE 18" AFF |
| 7 | 20"X40" OUTSIDE AIR UP TO GRV. FOR CONTINUATION REFER TO SHEET OMF-MECH-PLN-M130. |
| 8 | 40"X20" EXHAUST OFFSET DOWN |
| 9 | LOUVER BY OTHERS |

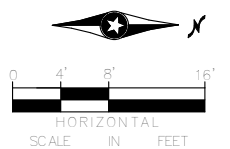 [illegible]

60% SUBMISSION - 09/28/15



OPERATIONS & MAINTENANCE FACILITY -V2B
MECHANICAL
MEZZANINE LEVEL - PARTIAL HVAC PLAN
AREA K

DISCIPLINE:	SHEET NAME:	
MECHANICAL	OMF-MECH-PLN	M-115K

SHEET
30
OF
263




KEY PLAN - SCALE: N.T.S.

The key plan shows a site layout with rooms labeled A through S. Rooms A, B, C, and D are in the top row. Rooms E, F, G, and H are in the second row, with room F shaded. Rooms J and K are in the third row. Rooms L, M, N, and O are in the bottom row. Rooms P, Q, R, and S are located to the right of the main building. A compass rose indicates North (N) is towards the top right. A scale bar shows distances in feet: 0, 4', 8', and 16'.

 	 	OPERATIONS & MAINTENANCE FACILITY -V2B MECHANICAL LEVEL TWO - PARTIAL HVAC PLAN AREA F			SHEET
60% SUBMISSION - 09/28/15		DISCIPLINE: MECHANICAL	SHEET NAME: OMF-MECH-PLN	M-120F	33
					OF
					263

1 36"X36" EXHAUST DUCT UP TO EXHAUST FAN.
REFER TO SHEET OMF-MECH-PLN-M130 FOR
CONTINUATION.

2 ROLLING SUPPLY OFFSET

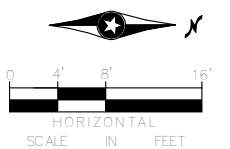[illegible]

METROPOLITAN
COUNCIL


SOUTHWEST

LEVEL TWO - PARTIAL HVAC PLAN AREA G

SHEET NAME:		
OMF-MECH-PLN	M-120G	

SHEET
34
OF
263

M-130A SCALE: 3/32" = 1'-0"
REF. SHEET: M-603 / REF. DETAIL: 1

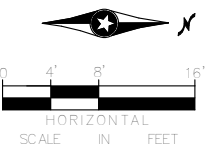[illegible]

OPERATIONS & MAINTENANCE FACILITY -V2B
MECHANICAL
ROOF LEVEL - PARTIAL HVAC AND PIPING
PLAN AREA A

SHEET NAME:	
OMF-MECH-PLN	M-130A

SHEET
37
OF
263



KEY PLAN - SCALE: N.T.S.

The key plan shows a building footprint with the following room layout:

- Top row: A, B, C (shaded), D
- Second row: E, F, G, H
- Third row: J, K
- Bottom row: L, M, N

Orientation: North arrow points towards the top right.

Scale: 0, 4', 8', 16' FEET.

[illegible]

 	 
60% SUBMISSION - 09/28/15	

OPERATIONS & MAINTENANCE FACILITY -V2B MECHANICAL ROOF LEVEL - PARTIAL HVAC AND PIPING PLAN AREA C			SHEET 39 OF 263
DISCIPLINE: MECHANICAL	SHEET NAME: OMF-MECH-PLN	M-130C	

9/21/2015 12:36:54 PM C:\Users\lisa\Documents\OMF Mech lisa.rvt



KEY PLAN - SCALE: N.T.S.

The key plan shows a site layout with buildings labeled A through N. Building D is hatched. A north arrow points towards the top right. A graphic scale bar is provided below the key plan, labeled 'HORIZONTAL' and 'SCALE IN FEET', with markings at 0, 4', 8', and 16'.

AECOM **LV** **ENGINEERING • LLC**
 CERTIFIED WOMEN'S
 BUSINESS ENTERPRISE

60% SUBMISSION - 09/28/15



OPERATIONS & MAINTENANCE FACILITY -V2B

MECHANICAL

ROOF LEVEL - PARTIAL HVAC AND PIPING

PLAN AREA D

DISCIPLINE: MECHANICAL	SHEET NAME: OMF-MECH-PLN	M-130D
----------------------------------	------------------------------------	---------------

9/21/2015 12:36:56 PM C:\Users\lisa\Documents\OMF Mech lisa.rvt



The key plan shows a building layout with rooms labeled A through S. Rooms A, B, C, D, E, F, G, H, J, K, L, M, and N are arranged in a rectangular footprint. Room F is shaded with diagonal lines. Rooms I, O, P, Q, R, and S are located outside the main rectangular footprint. To the right of the key plan is a north arrow pointing towards the top right and a graphic scale bar marked from 0 to 16 feet in 4-foot increments. Below the scale bar is the text "SCALE IN FEET".

KEY PLAN - SCALE: N.T.S.


[illegible]

OPERATIONS & MAINTENANCE FACILITY -V2B
MECHANICAL
ROOF LEVEL - PARTIAL HVAC AND PIPING
PLAN AREA F


DISCIPLINE:	SHEET NAME:	
MECHANICAL	OMF-MECH-PLN	M-130F

SHEET
42
OF
263

1 VENT FOR INDUSTRIAL EQUIPMENT #3720. REFER
TO INDUSTRIAL PLANS FOR SIZE AND LOCATION.

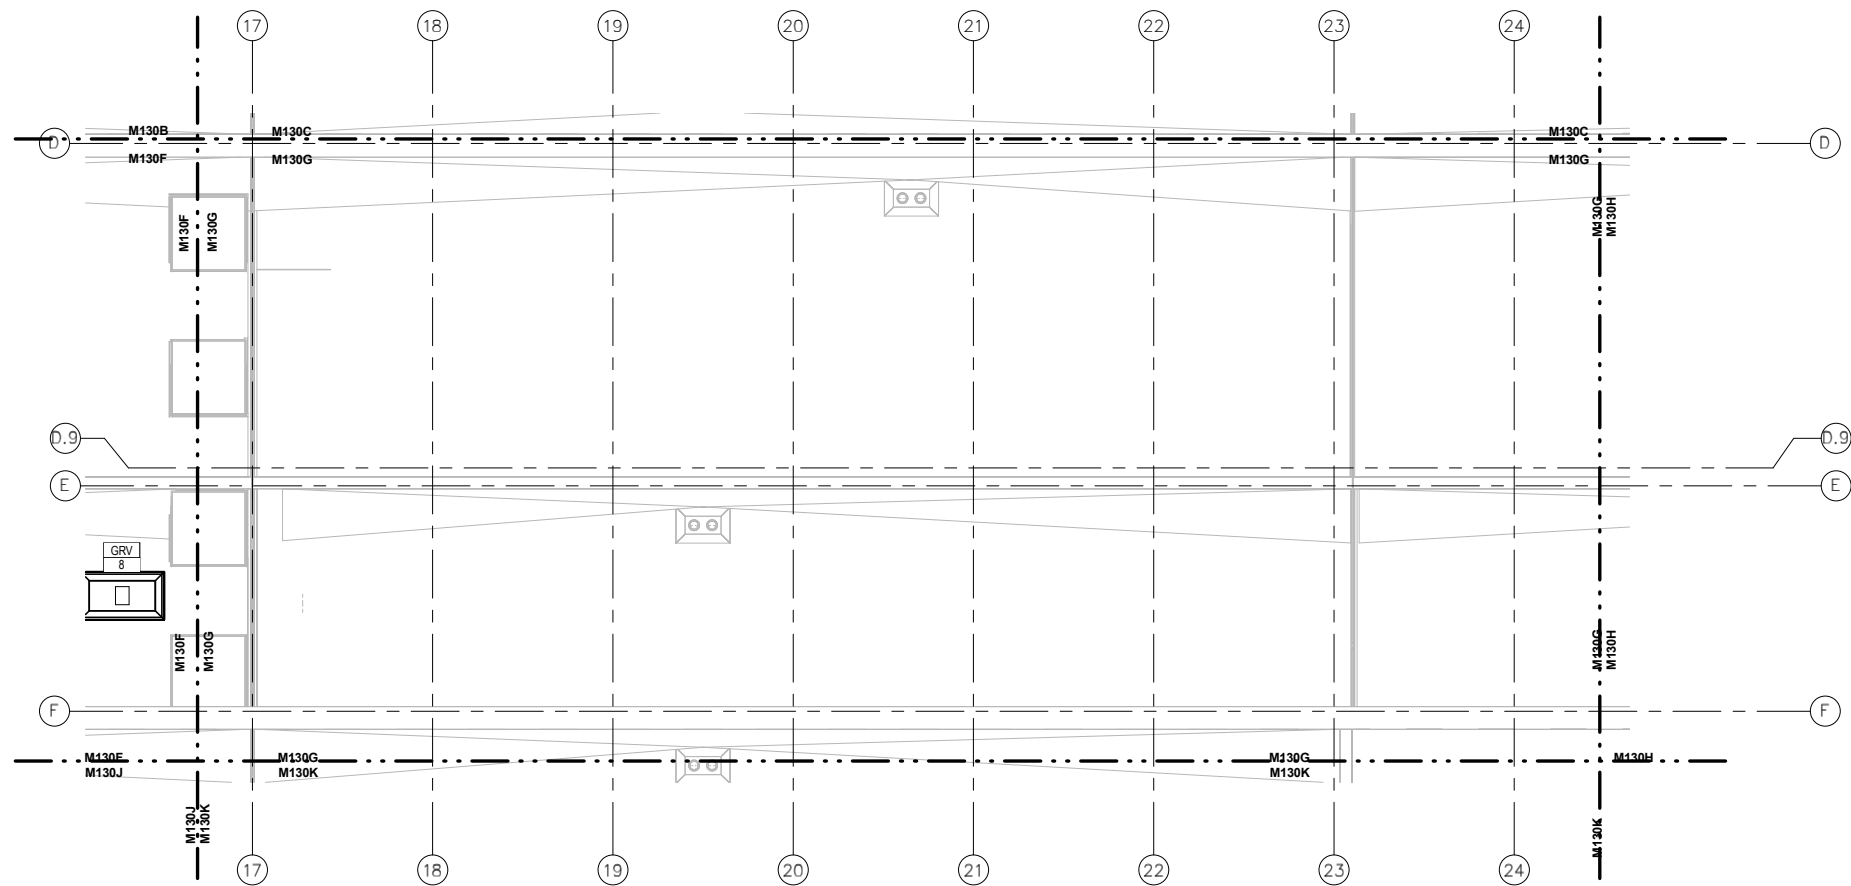

1 MECHANICAL ROOF PLAN - AREA G
M-130G SCALE: 3/32" = 1'-0"
REF. SHEET: M-603 / REF. DETAIL: 1

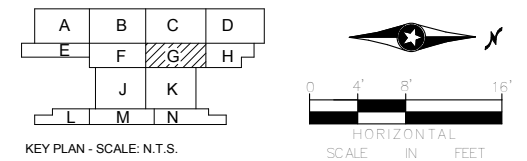[illegible]

60% SUBMISSION - 09/28/15




OPERATIONS & MAINTENANCE FACILITY -V2B
MECHANICAL
ROOF LEVEL - PARTIAL HVAC AND PIPING
PLAN AREA G

DISCIPLINE:	SHEET NAME:	
MECHANICAL	OMF-MECH-PLN	M-130G

SHEET
43
OF
263



SCALE: $3/32" = 1'-0"$
REF. SHEET: M-603 / REF. DETAIL: 1


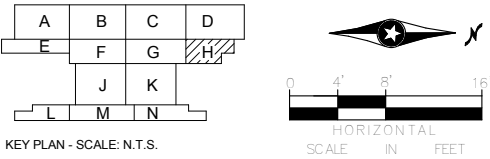
[illegible]**60% SUBMISSION - 09/28/15**

**OPERATIONS & MAINTENANCE FACILITY -V2B
MECHANICAL
ROOF LEVEL - PARTIAL HVAC AND PIPING
PLAN AREA H**

DISCIPLINE: **MECHANICAL**

SHEET NAME:	OMF-MECH-PLN	M-130H
-------------	--------------	--------

SHEET
44
OF
263

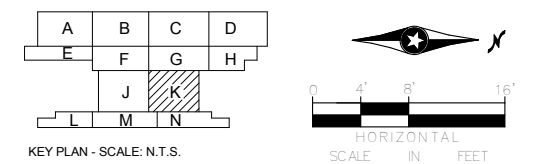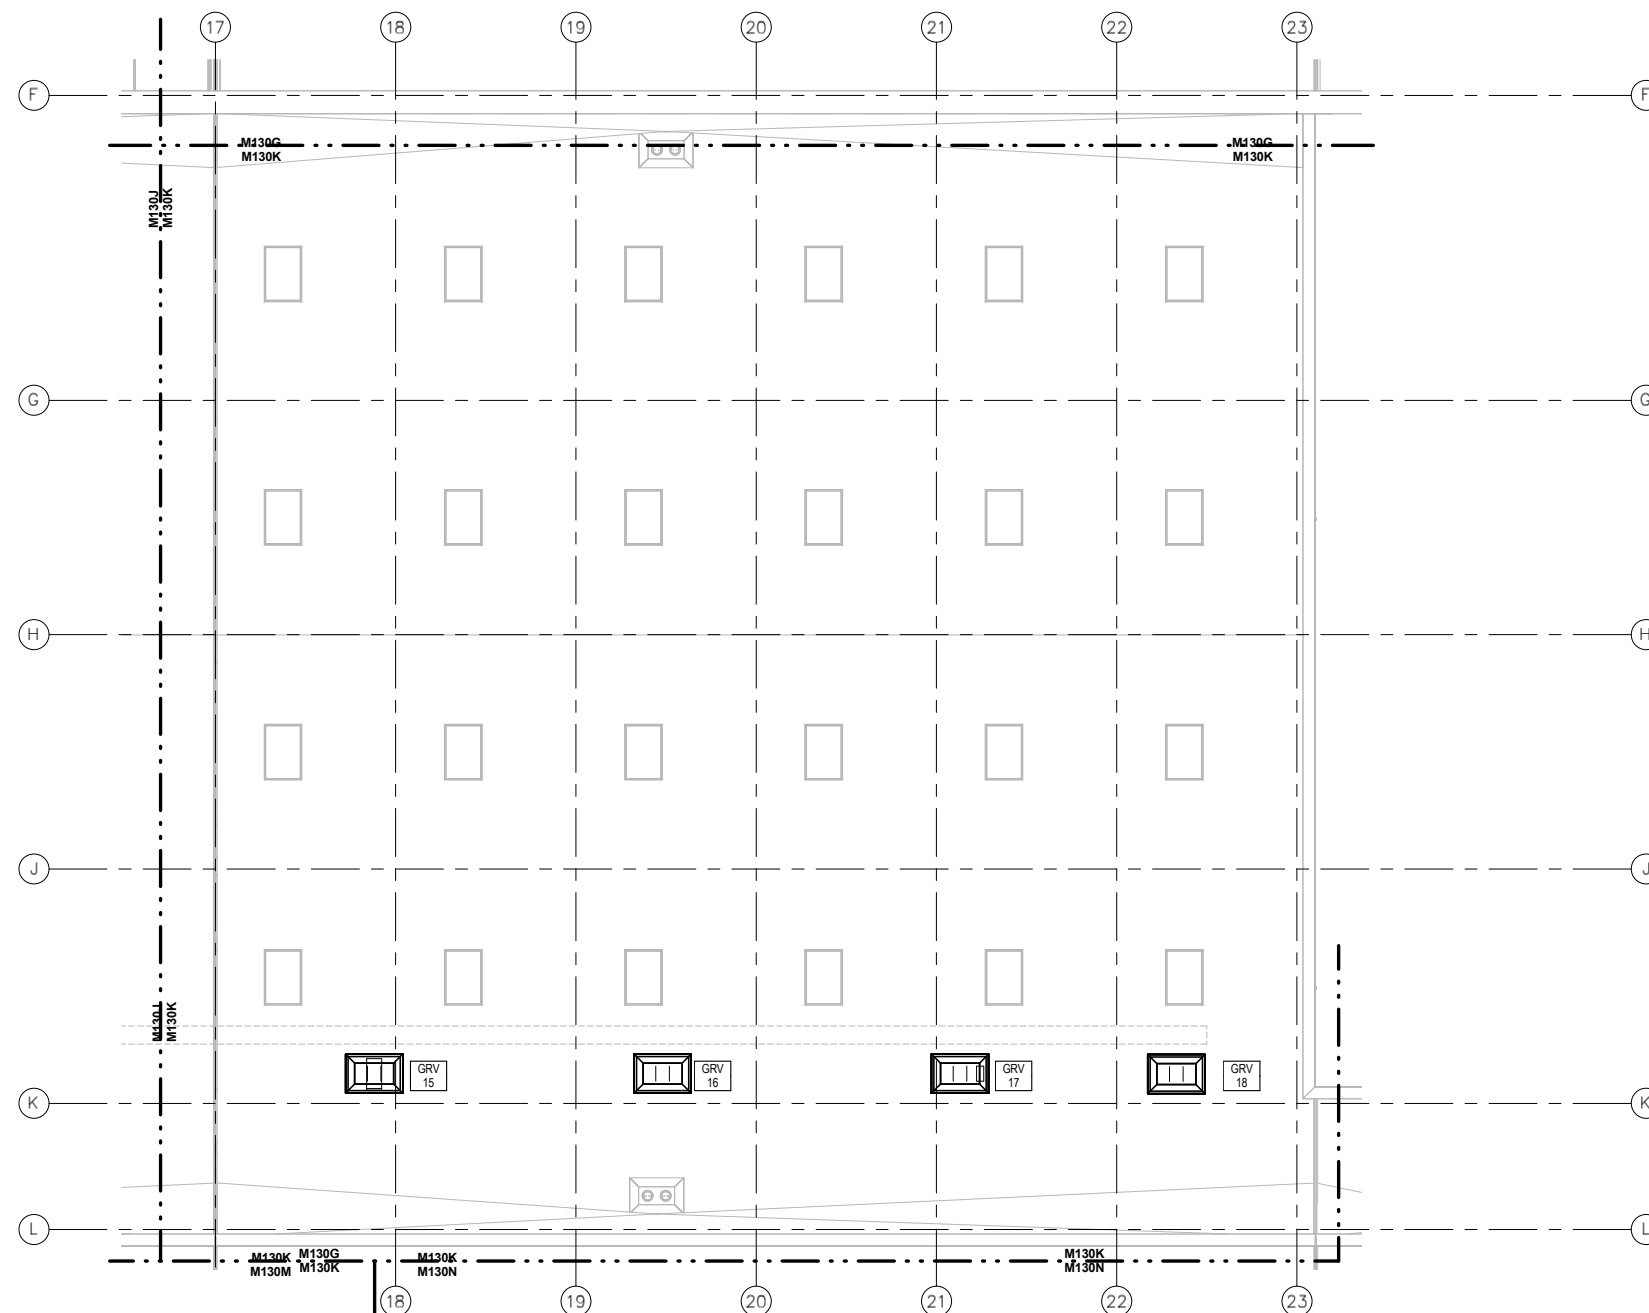

1 MECHANICAL ROOF PLAN - AREA K
M-130K SCALE: 3/32" = 1'-0"
REF. SHEET: M-603 / REF. DETAIL: 1

[illegible]

60% SUBMISSION - 09/28/15


OPERATIONS & MAINTENANCE FACILITY -V2B
MECHANICAL
ROOF LEVEL - PARTIAL HVAC AND PIPING
PLAN AREA K

DISCIPLINE:	SHEET NAME:	
MECHANICAL	OMF-MECH-PLN	M-130K

SHEET
46
OF
263



 
SCALE: $3/32" = 1'-0"$
REF. SHEET: M-603 / REF. DETAIL: 1



DISCIPLINE:	SHEET NAME:	
MECHANICAL	OMF-MECH-PLN	M-130L



 1
M-130M



AECOM **ENGINEERING • LLC**
CERTIFIED WOMEN'S
BUSINESS ENTERPRISE

60% SUBMISSION - 09/28/15

DISCIPLINE: **MECHANICAL**

SHEET NAME:	OMF-MECH-PLN	M-130M
-------------	--------------	--------




KEY PLAN - Scale: N.T.S.

[illegible]

**OPERATIONS & MAINTENANCE FACILITY -V2B
MECHANICAL
ROOF LEVEL - PARTIAL HVAC AND PIPING
PLAN AREA N**

DISCIPLINE:	SHEET NAME:	
MECHANICAL	OMF-MECH-PLN	M-130N


SHEET
49
OF
263

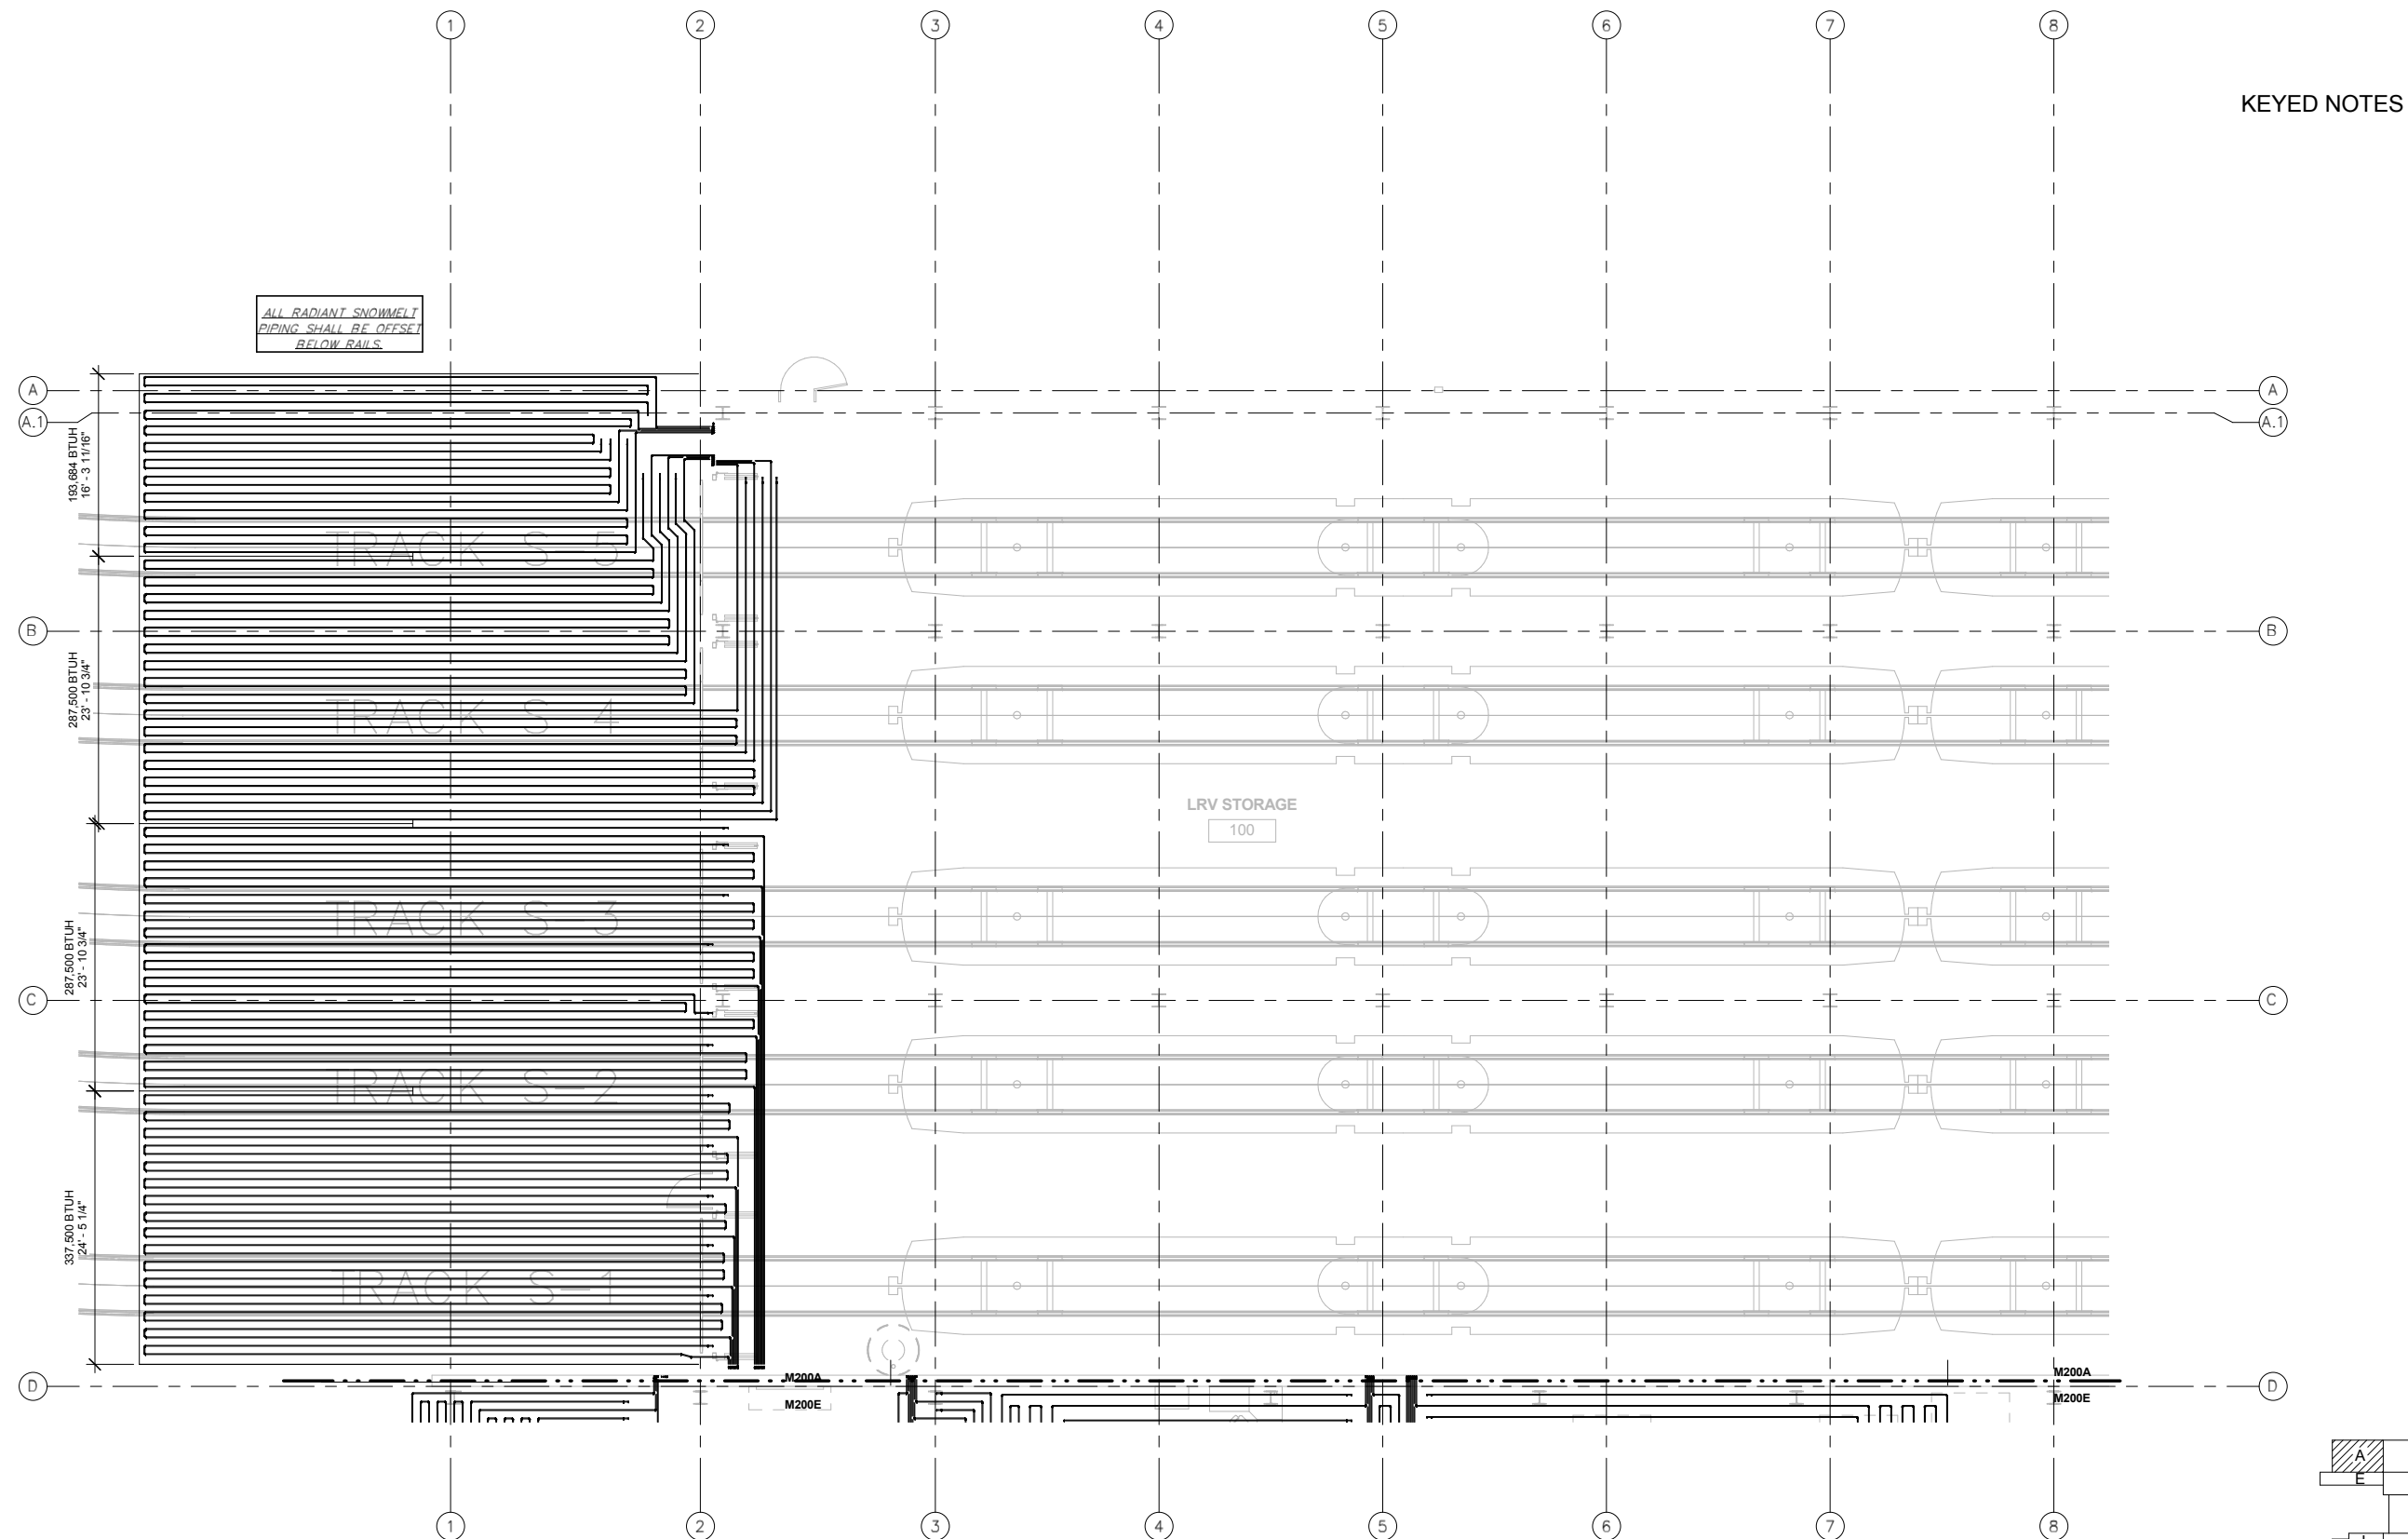

KEYED NOTES



KEY PLAN - SCALE: N.T.S.

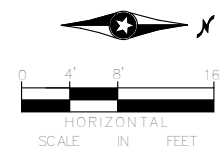

1 UNDERGROUND PIPING PLAN - AREA A

 
M-200A SCALE: 1/8" = 1'-0"
REF. SHEET: M-603 / REF. DETAIL: 1

[illegible]

LV
ENGINEERING • LLC
CERTIFIED WOMEN'S
BUSINESS ENTERPRISE



SOUTHWEST



60% SUBMISSION - 09/28/15

OPERATIONS & MAINTENANCE FACILITY -V2B
MECHANICAL
UNDERGROUND - PARTIAL RADIANT PIPING
PLANS AREA A

DISCIPLINE: **MECHANICAL**

SHEET NAME:		OMF-MECH-PLN	M-200A
-------------	--	--------------	--------

SHEET
51
OF
263


ALL RADIANT SNOWMELT
PIPING SHALL BE OFFSET
BELOW RAILS.

217,890 BTUH
18' - 0 5/8"


300,000 BTUH
23" - 10 3/4"

300,000 BTUH
23' - 10 3/4"

337,500 BTUH
27' - 0 5/8"

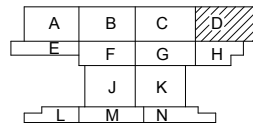

KEY PLAN - SCALE: N.T.S.

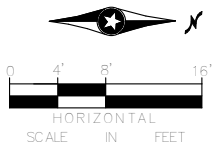

SCALE: 1/8" = 1'-0"

[illegible]

LV
ENGINEERING • LLC
CERTIFIED WOMEN'S
BUSINESS ENTERPRISE



SOUTHWEST

60% SUBMISSION - 09/28/15

**OPERATIONS & MAINTENANCE FACILITY -V2B
MECHANICAL
UNDERGROUND - PARTIAL RADIANT PIPING
PLANS AREA D**

DISCIPLINE:

MECHANICAL

SHEET NAME:

OMF-MECH-PLN

M-200D


SHEET

52

OF



263

9/21/2015 8:44:28 PM C:\Users\george\Documents\OMF_Mech_george.rvt

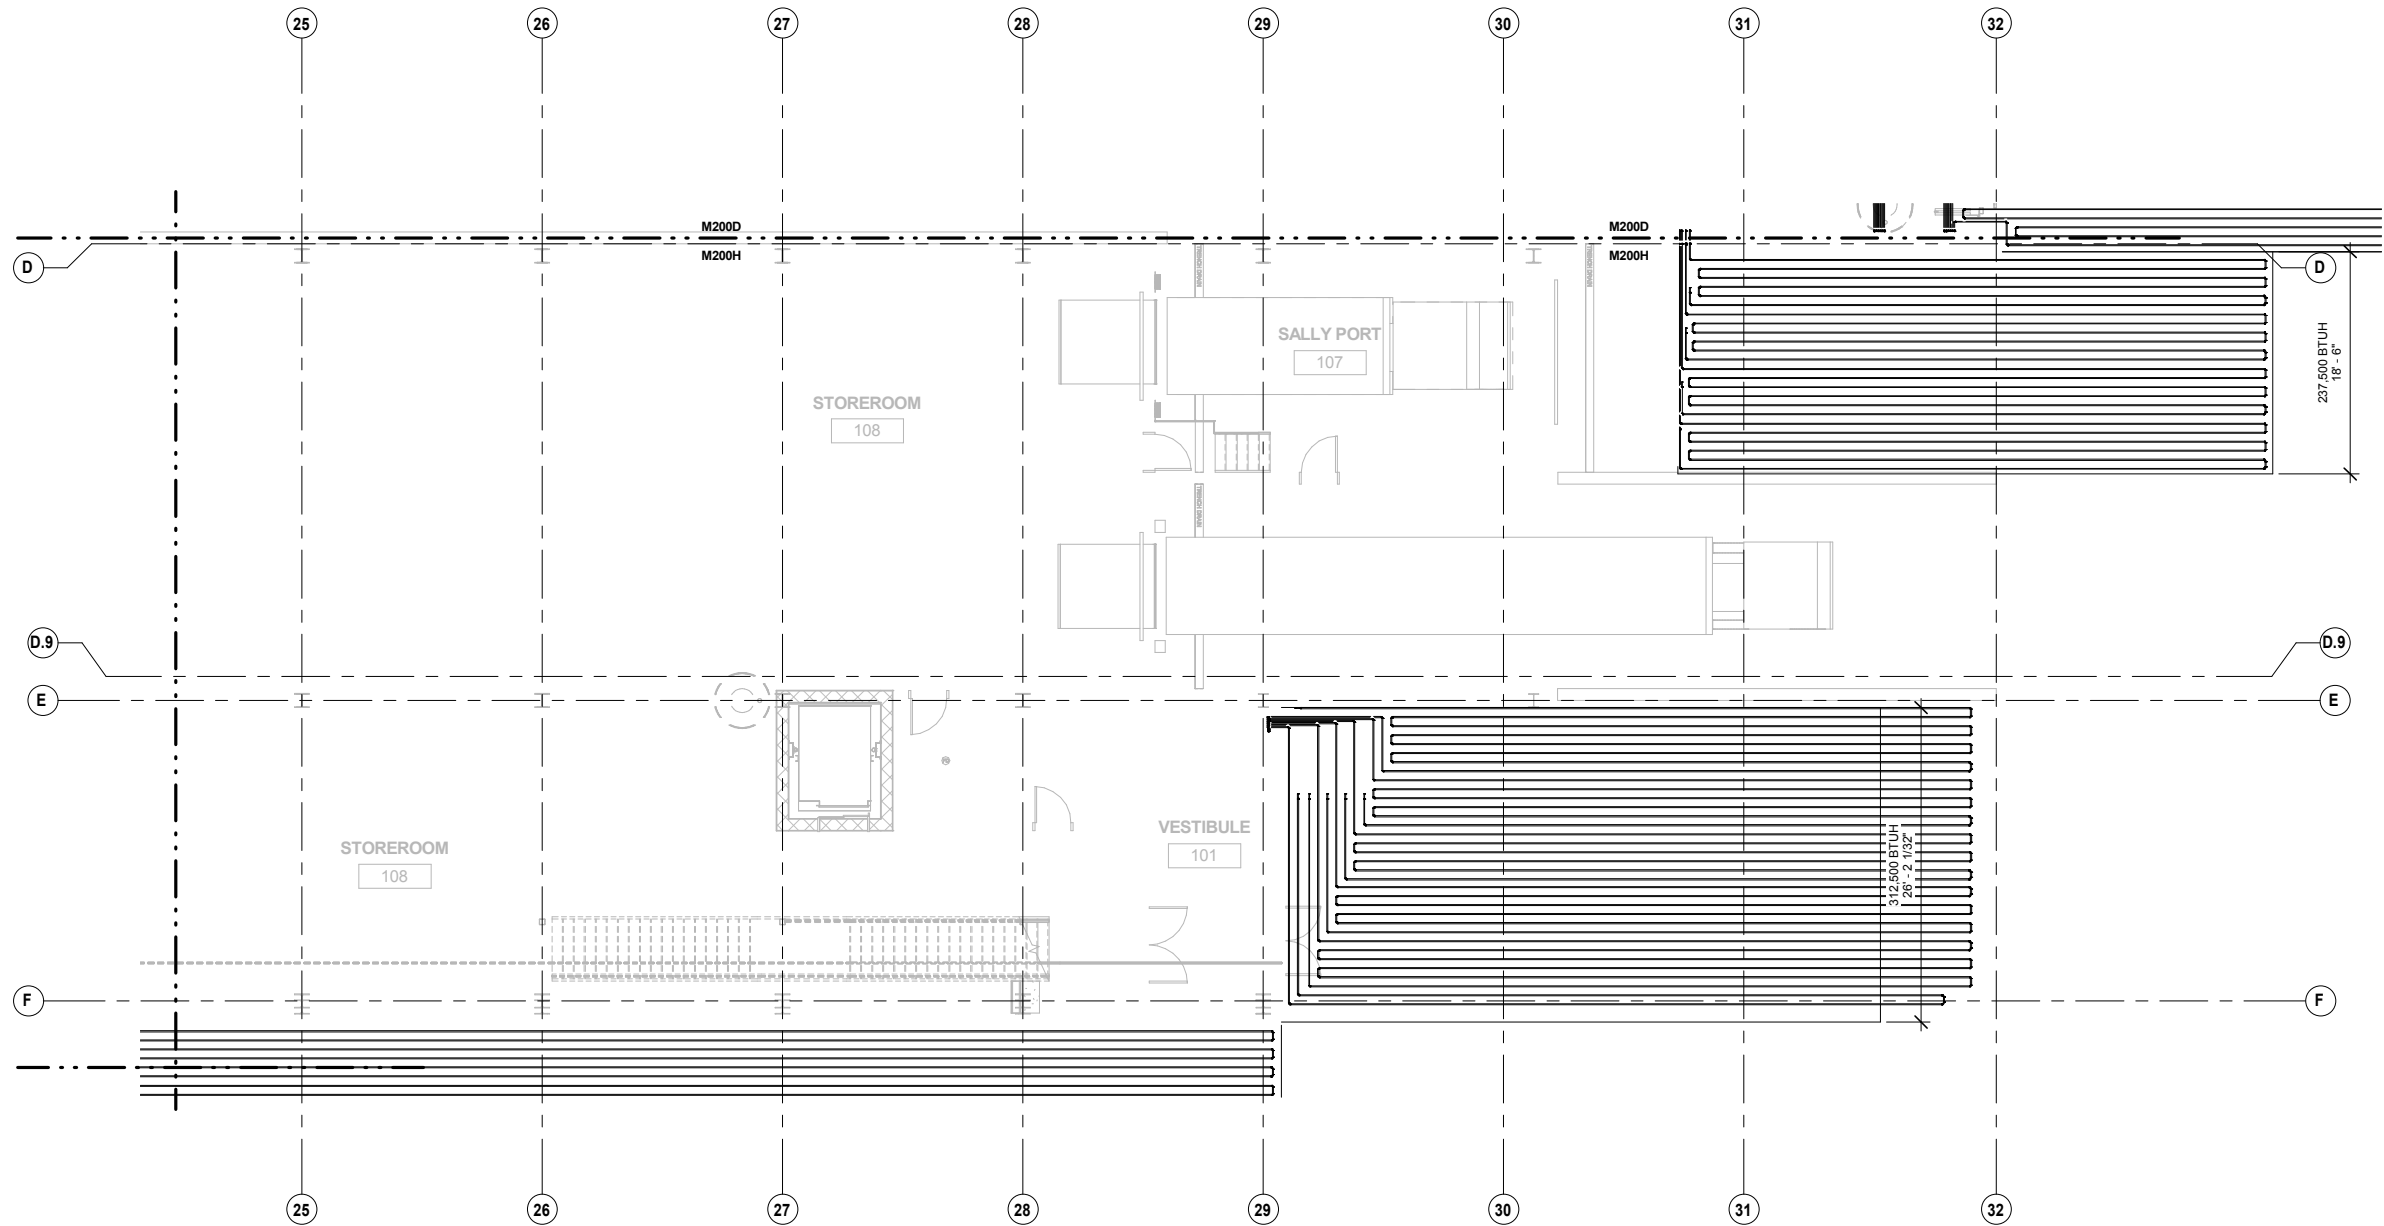

KEYED NOTES

1 UNDERGROUND PIPING PLAN - AREA H
M-200H SCALE: 1/8" = 1'-0"
REF. SHEET: M-603 / REF. DETAIL: 1

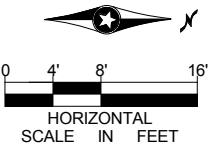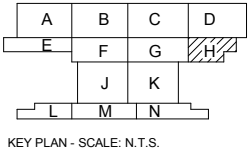

NO	DATE	BY	CHECK	DESIGN	REVISION / SUBMITTAL



ENGINEERING • LLC
CERTIFIED WOMEN'S
BUSINESS ENTERPRISE



60% SUBMISSION - 09/28/15


OPERATIONS & MAINTENANCE FACILITY -V2B
MECHANICAL
UNDERGROUND - PARTIAL RADIANT PIPING
PLANS AREA H

DISCIPLINE:
MECHANICAL

SHEET NAME:
OMF-MECH-PLN

M-200H

SHEET
54
OF
263

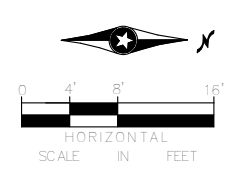

SCALE: 1/8" = 1'-0"

[illegible]

60% SUBMISSION - 09/28/15



DISCIPLINE:


MECHANICAL

SHEET NAME:



OMF-MECH-PLN

M-200J

SHEET
55
OF
263

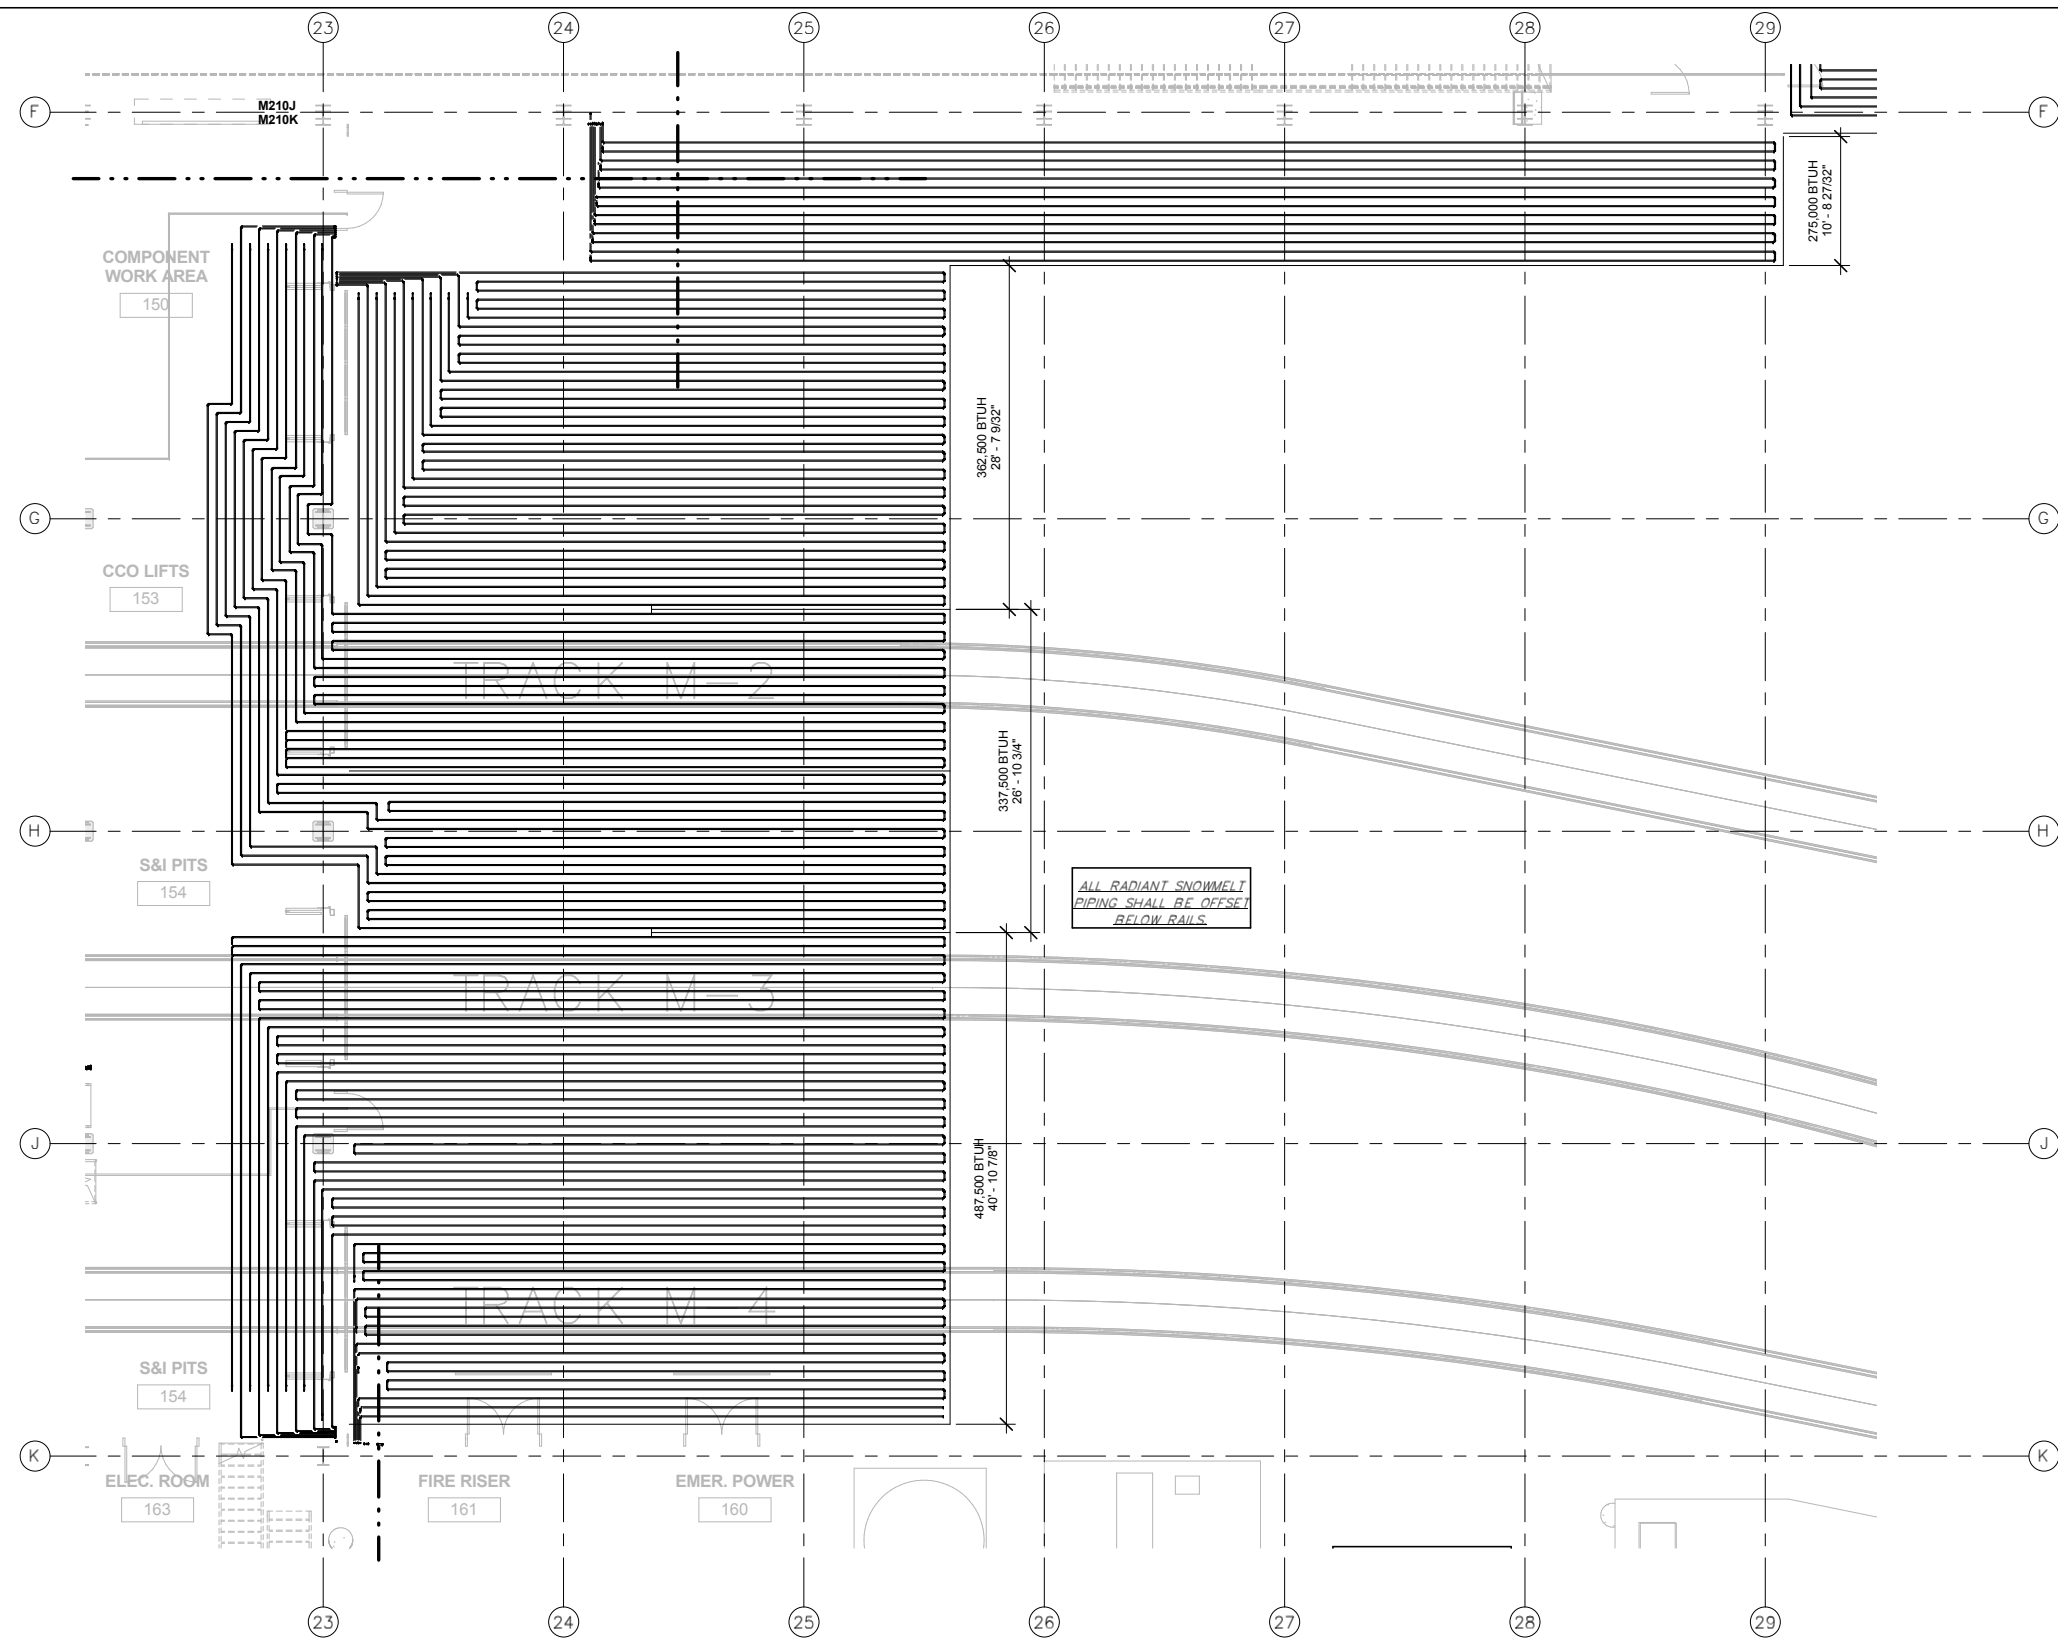

KEYED NOTES

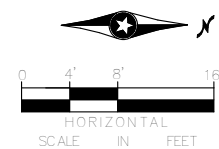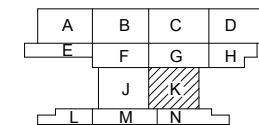

KEY PLAN - SCALE: N.T.S.

1 UNDERGROUND PIPING PLAN - AREA K
M-200K SCALE: 1/8" = 1'-0"
REF. SHEET: M-603 / REF. DETAIL: 1

[illegible]

60% SUBMISSION - 09/28/15

OPERATIONS & MAINTENANCE FACILITY -V2B MECHANICAL UNDERGROUND - PARTIAL RADIANT PIPING PLANS AREA K	S
---	---

DISCIPLINE:

MECHANICAL

 
SHEET NAME:

NET NAME: **OMF-MECH-PLN**

M-200K

SHEET
56
OF
263

9/21/2015 11:33:55 AM C:\Users\isa\Documents\OMF_Mech_isa.rvt

[illegible]


60% SUBMISSION - 09/28/15




OPERATIONS & MAINTENANCE FACILITY -V2B
MECHANICAL
UNDERGROUND - PARTIAL RADIANT PIPING
PLANS AREA N

DISCIPLINE:	SHEET NAME:	
MECHANICAL	OMF-MECH-PLN	M-200N

SHEET
58
OF
263

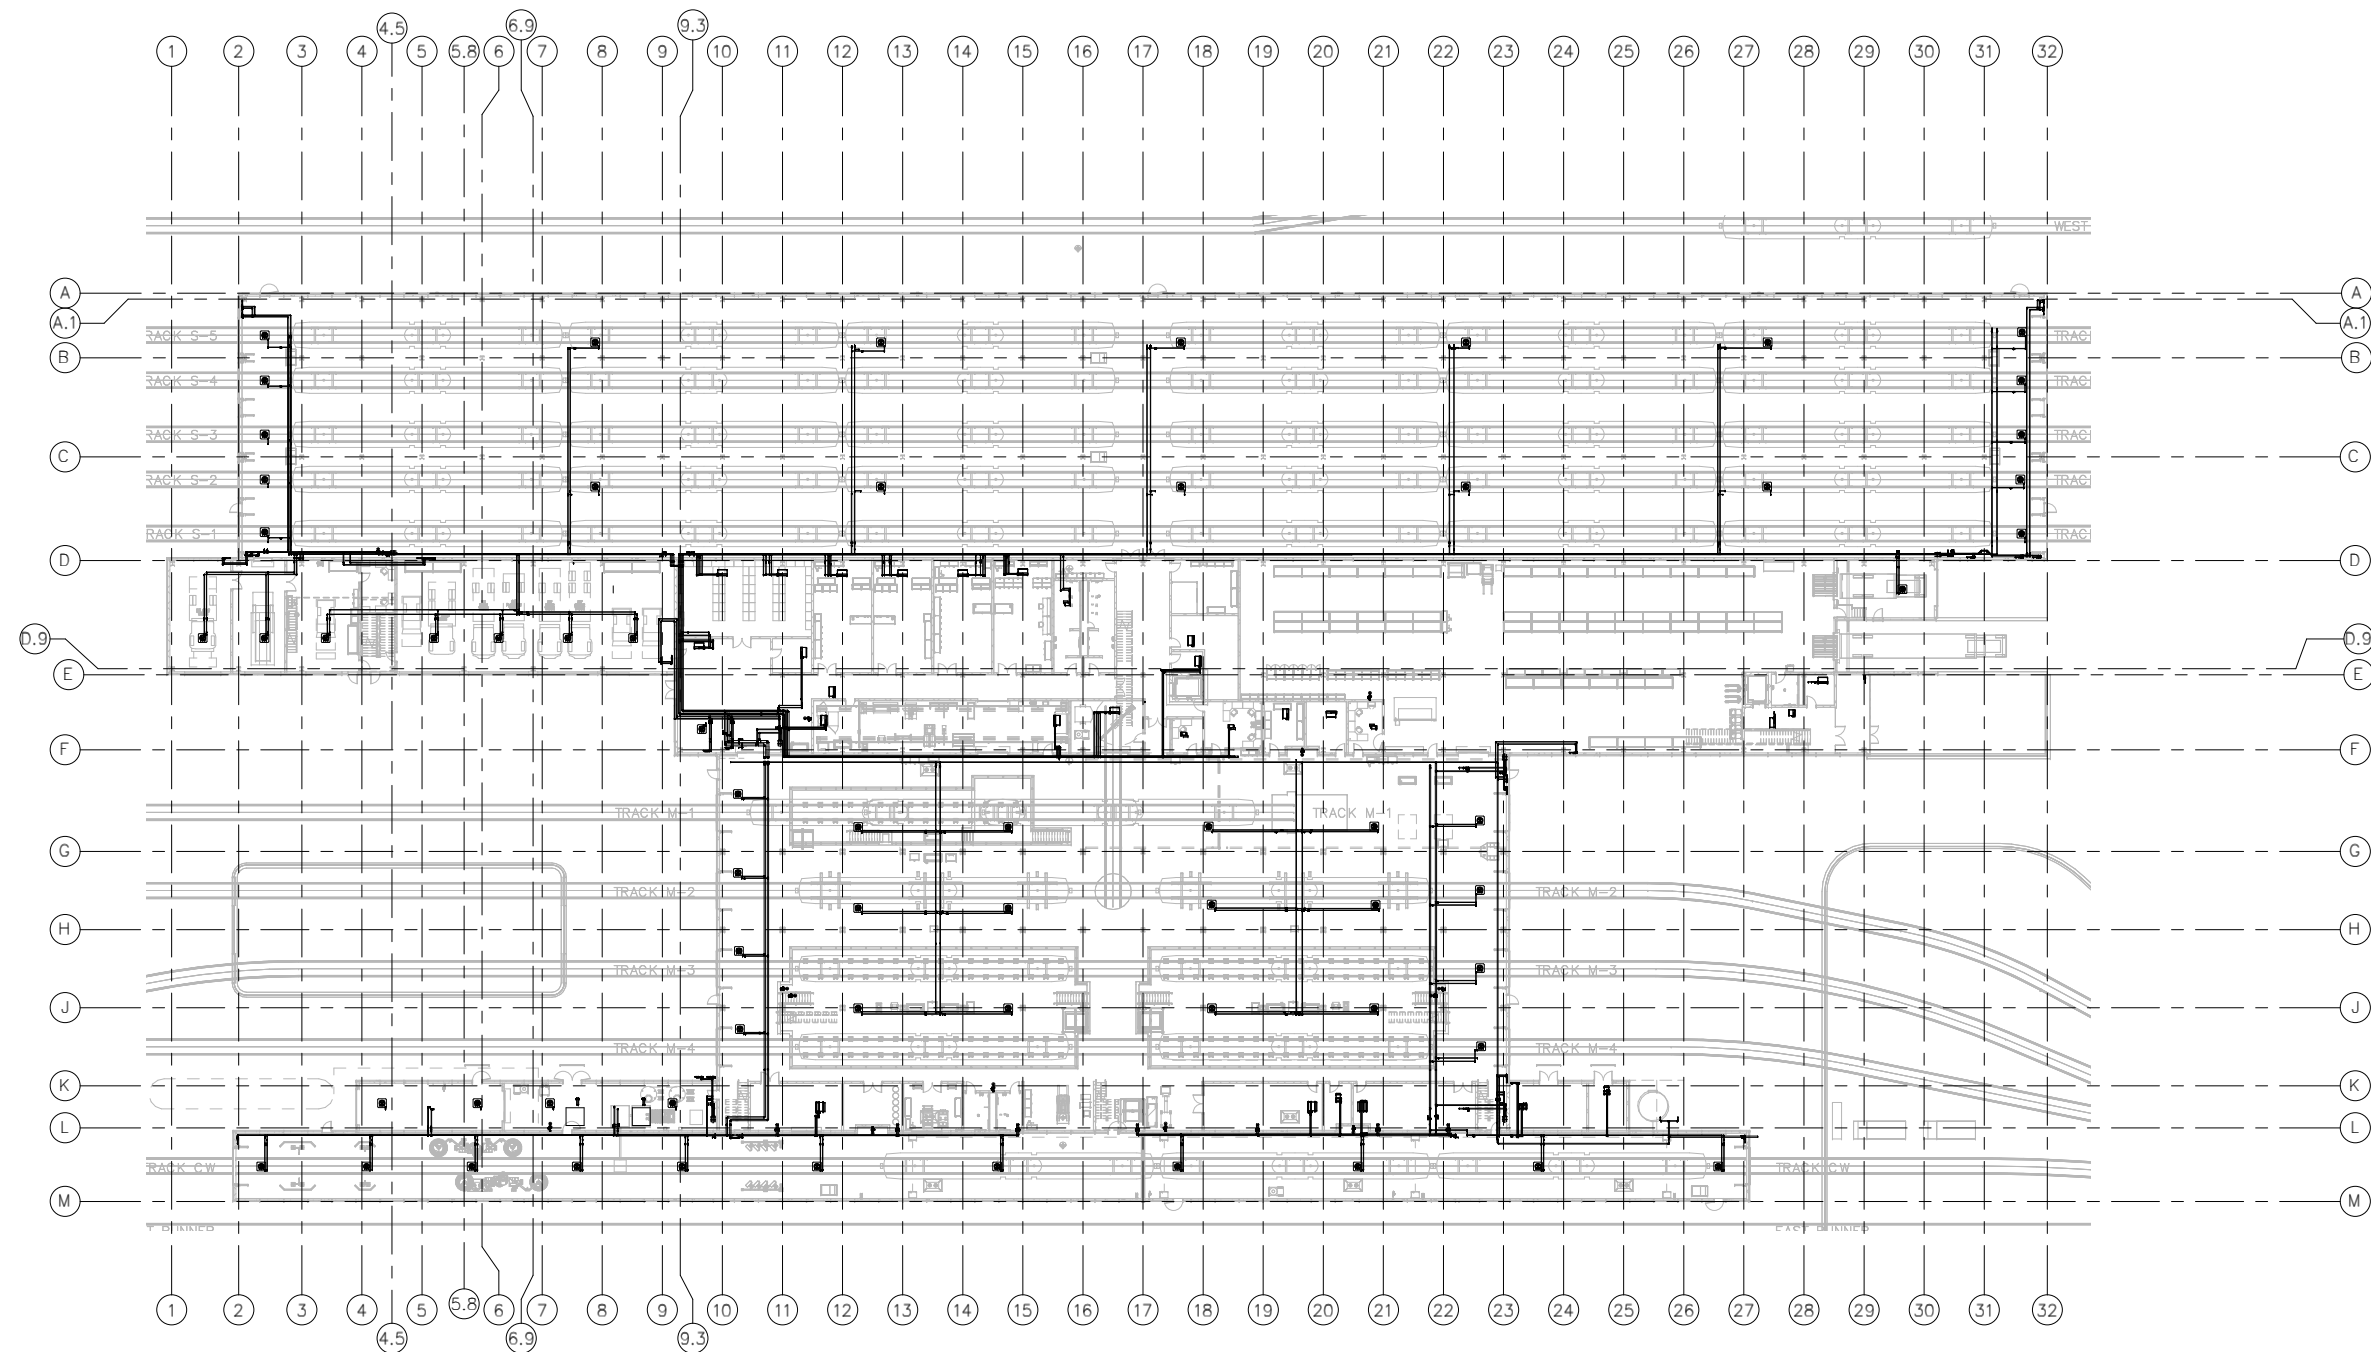



1 OVERALL LEVEL ONE PIPING PLAN
M-210 SCALE: 1/32" = 1'-0"
REF. SHEET: M-603 / REF. DETAIL: 1

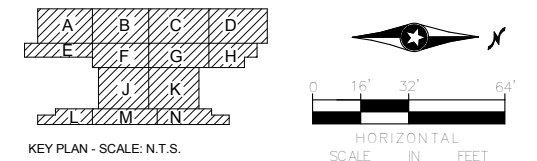[illegible]

OPERATIONS & MAINTENANCE FACILITY -V2B MECHANICAL LEVEL ONE OVERALL PIPING PLAN	S
---	---


DISCIPLINE:	SHEET NAME:	
MECHANICAL	OMF-MECH-PLN	M-210


SHEET
59
OF
263

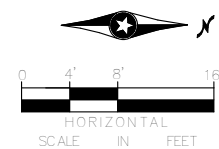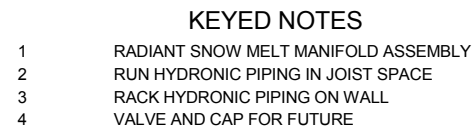


M-210A SCALE: 1/8" = 1'-0"
REF. SHEET: M-603 / REF. DETAIL: 1

   SHEET
60
OF
263










ENGINEERING • LLC

CERTIFIED WOMEN'S
BUSINESS ENTERPRISE

60% SUBMISSION - 09/28/15

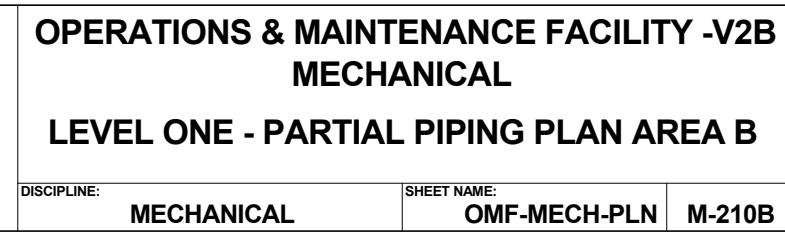


 
9/21/2015 11:34:20 AM C:\Users\lisa\Documents\OMF_Mech_lisa.rvt

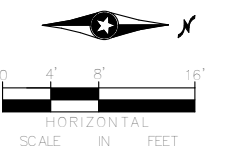**AECOM**

METROPOLITAN
COUNCIL

SOUTHWEST

SHEET NAME:		
OMF-MECH-PLN	M-210C	

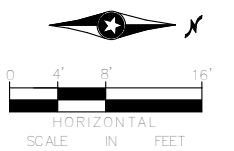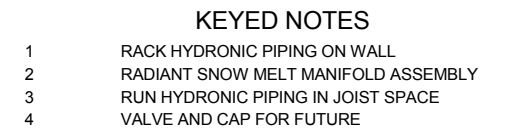


M-210D SCALE: 1/8" = 1'-0"
REF. SHEET: M-603 / REF. DETAIL: 1

AECOM **LV** **ENGINEERING • LLC**
CERTIFIED WOMEN'S BUSINESS ENTERPRISE



LEVEL ONE - PARTIAL PIPING PLAN AREA D


SHEET NAME:		
OMF-MECH-PLN	M-210D	

 

A graphic scale bar and north arrow. The scale bar is labeled with 0, 4', 8', and 16'. Below the bar, the text "HORIZONTAL SCALE IN FEET" is written. To the right of the scale bar is a north arrow pointing upwards, with a stylized 'N' to its right.

SHEET
65
OF
263

 1


[illegible]

DISCIPLINE:	SHEET NAME:	
MECHANICAL	OMF-MECH-PLN	M-210G


SHEET
66
OF
263

KEYED NOTES

RADIANT SNOW MELT MANIFOLD ASSEMBLY

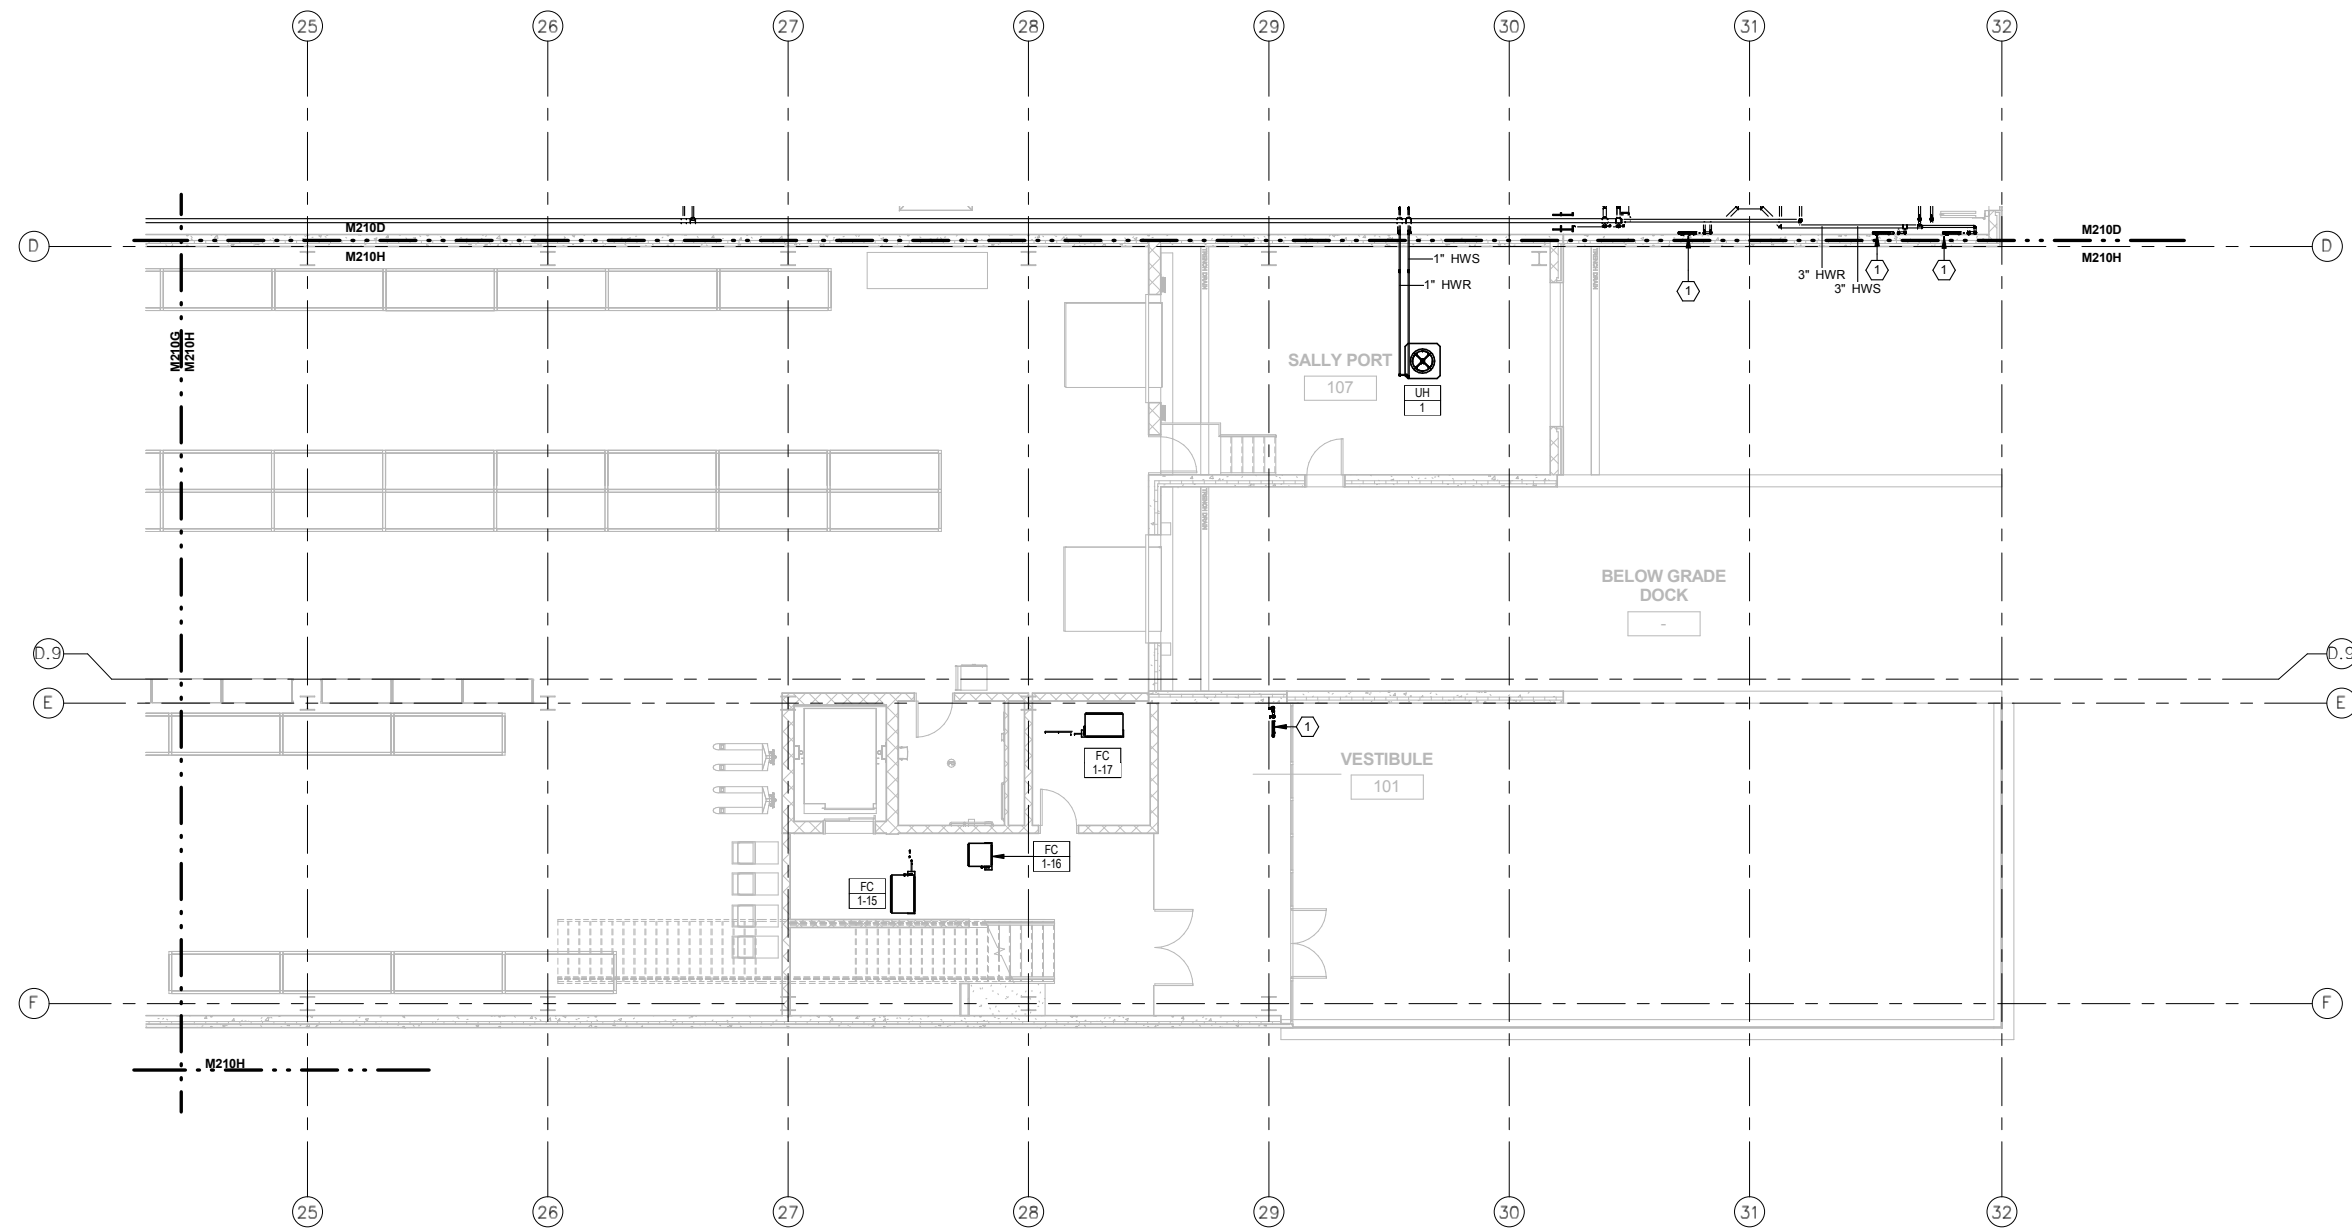


1 LEVEL ONE - AREA H - PIPING PLAN
M-210H SCALE: 1/8" = 1'-0"
REF. SHEET: M-603 / REF. DETAIL: 1

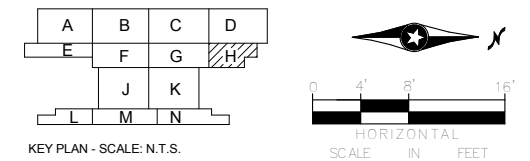[illegible]


OPERATIONS & MAINTENANCE FACILITY -V2B	S
MECHANICAL	

DISCIPLINE:	SHEET NAME:	
MECHANICAL	OMF-MECH-PLN	M-210H

SHEET
67
OF
263

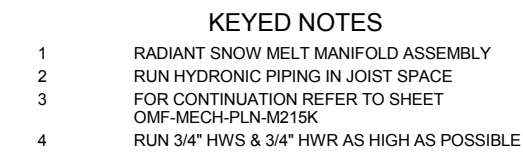[illegible]

OPERATIONS & MAINTENANCE FACILITY -V2B MECHANICAL LEVEL ONE - PARTIAL PIPING PLAN AREA K			SHEET 69 OF 263
DISCIPLINE: MECHANICAL	SHEET NAME: OMF-MECH-PLN	M-210K	

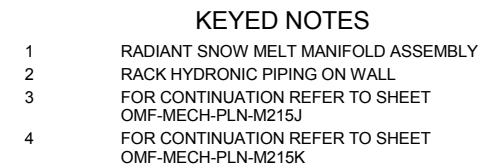

KEY PLAN - SCALE: N.T.S.


[illegible]

METROPOLITAN COUNCIL

SOUTHWEST

DISCIPLINE:	SHEET NAME:	
MECHANICAL	OMF-MECH-PLN	M-210M

SHEET
71
OF
263

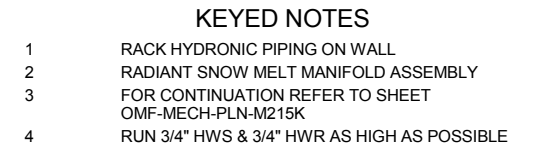


KEY PLAN - SCALE: N.T.S.

The key plan shows a site layout with rooms labeled A through S. The layout is as follows:

- Top row: A, B, C, D
- Second row: E, F, G, H
- Third row: J, K
- Bottom row: L, M, N, S

Room S is shaded with diagonal lines. To the right of the key plan is a north arrow pointing upwards, labeled 'N'. Below the north arrow is a scale bar with markings for 0, 4', 8', and 16'. The scale bar is labeled 'SCALE IN FEET' and 'HORIZONTAL'.


 	 	OPERATIONS & MAINTENANCE FACILITY -V2B MECHANICAL LEVEL ONE - PARTIAL PIPING PLAN AREA N		SHEET
60% SUBMISSION - 09/28/15		DISCIPLINE: MECHANICAL	SHEET NAME: OMF-MECH-PLN M-210N	72
				OF
				263

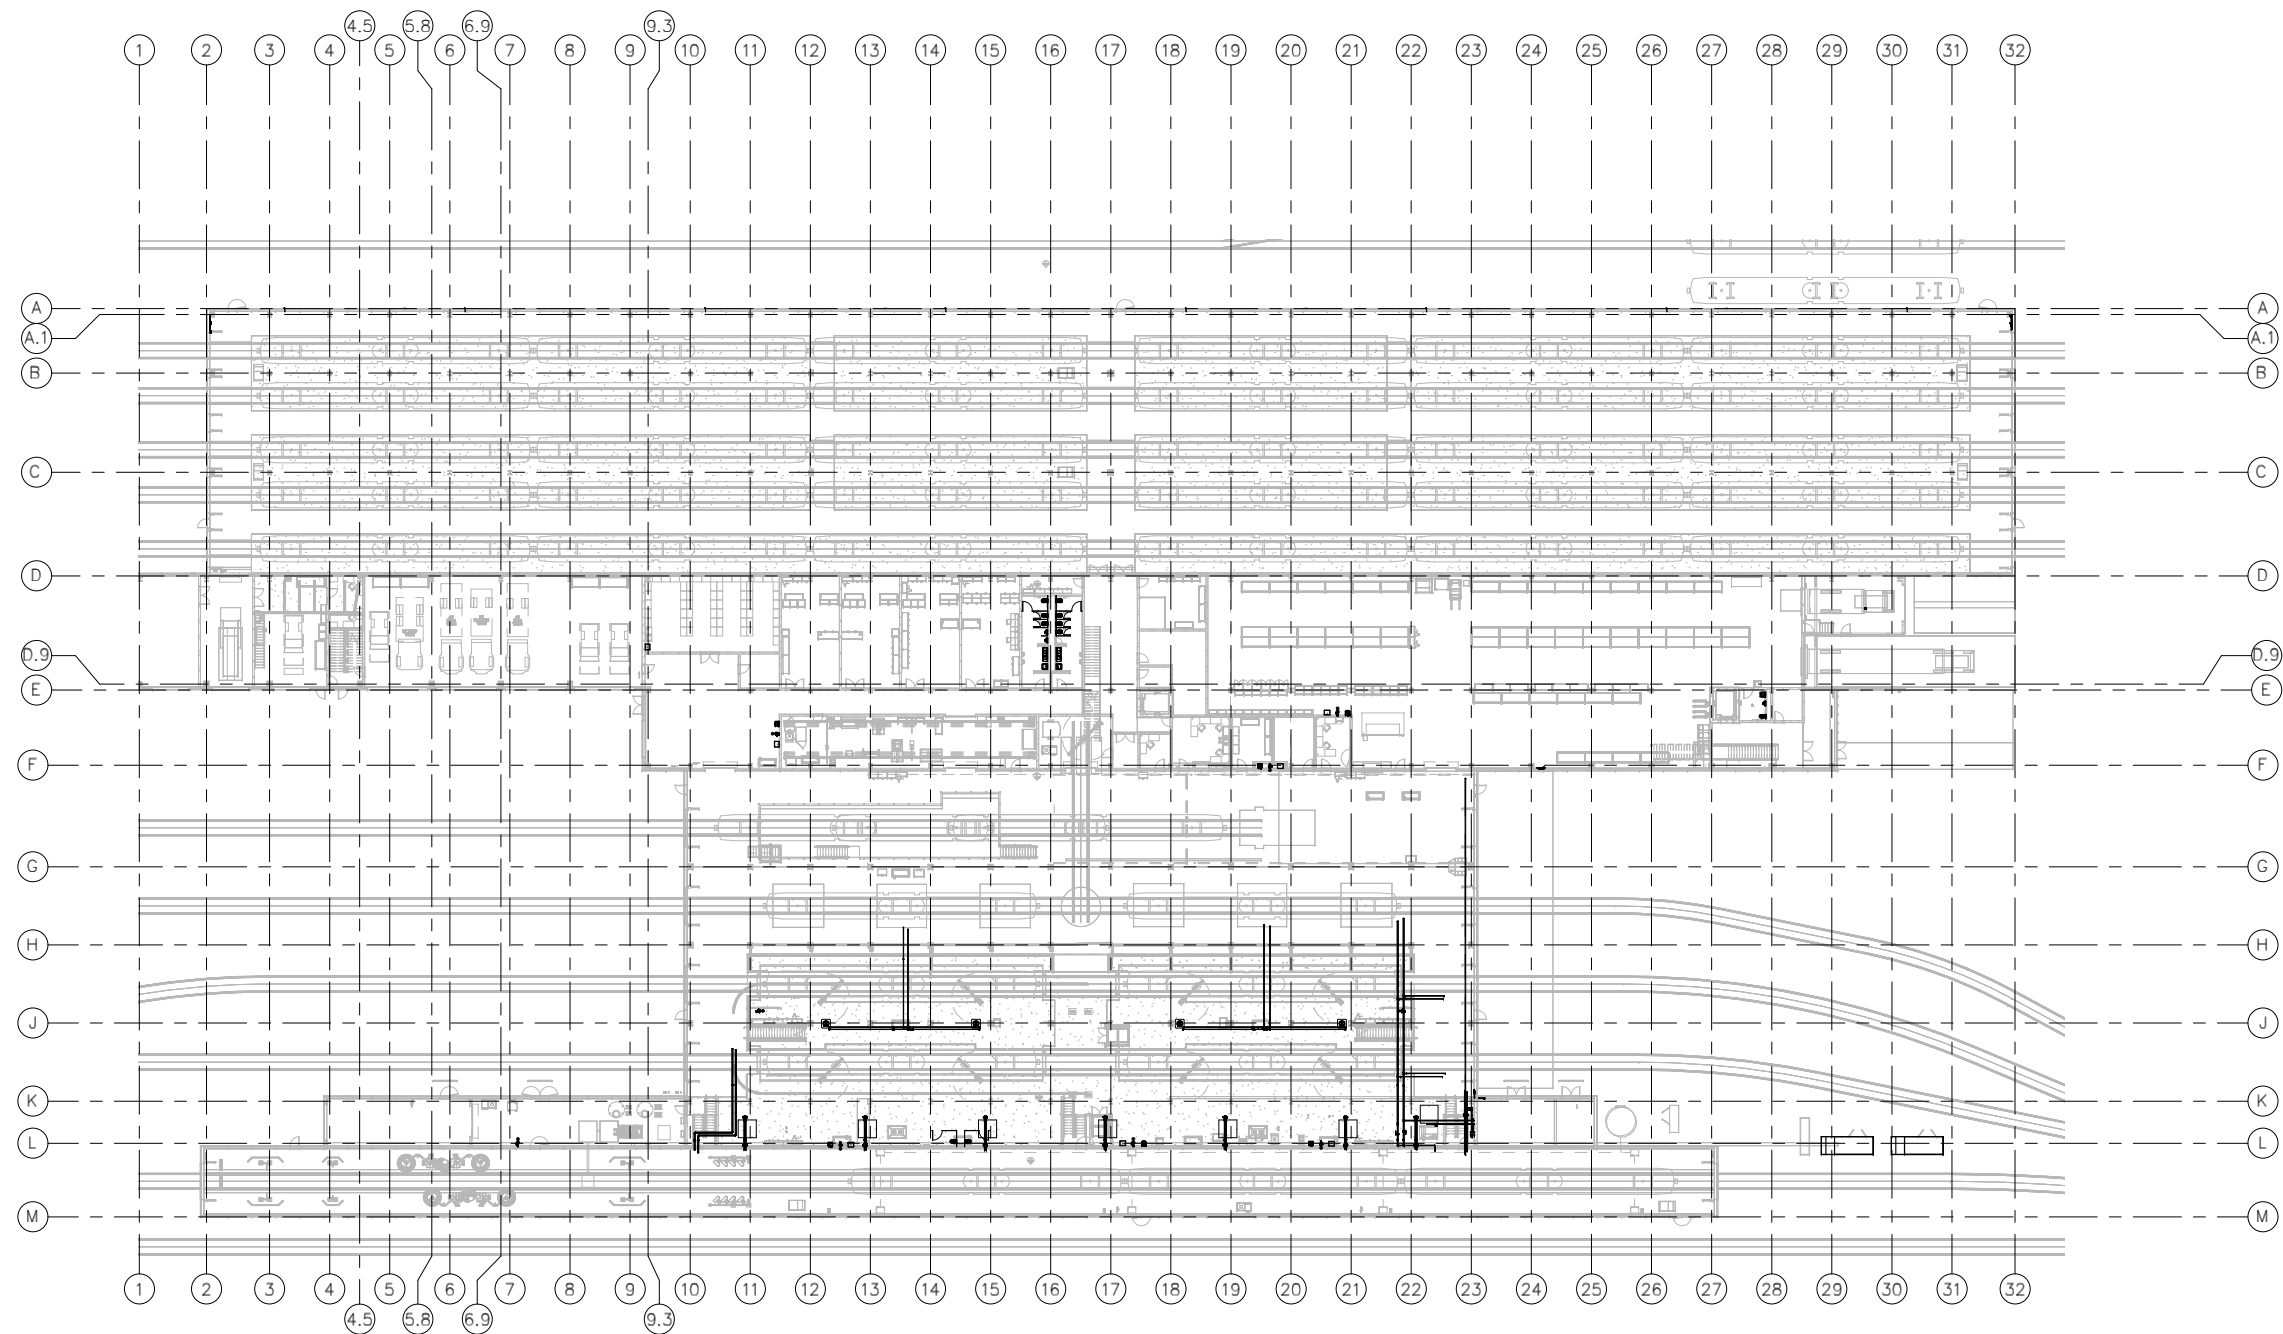


KEYED NOTES

1 OVERALL MEZZANINE LEVEL PIPING PLAN

SCALE: $1/32" = 1'-0"$
REF. SHEET: M-602 / REF. DETAIL: 2

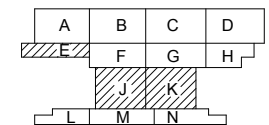

KEY PLAN - SCALE: N.T.S.

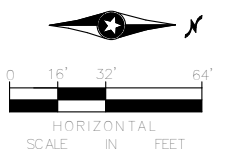[illegible]

AECOM

60% SUBMISSION - 09/28/15




OPERATIONS & MAINTENANCE FACILITY -V2B
MECHANICAL
MEZZANINE LEVEL OVERALL PIPING FLOOR
PLAN


DISCIPLINE: **MECHANICAL**

SHEET NAME:		
OMF-MECH-PLN		M-215

SHEET
73
OF
263

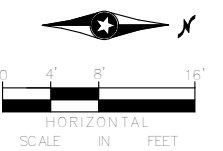


DISCIPLINE:	SHEET NAME:	
MECHANICAL	OMF-MECH-PLN	M-215J

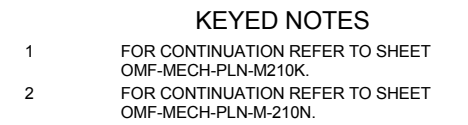[illegible]

OPERATIONS & MAINTENANCE FACILITY -V2B
MECHANICAL
MEZZANINE LEVEL - PARTIAL PIPING PLAN
AREA K

SHEET NAME:		OMF-MECH-PLN	M-215K
-------------	--	--------------	--------

SHEET
75
OF
263

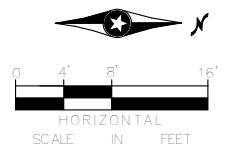[illegible]

OPERATIONS & MAINTENANCE FACILITY -V2B	S
MECHANICAL	


DISCIPLINE:	SHEET NAME:	
MECHANICAL	OMF-MECH-PLN	M-220H

SHEET
80
OF
263


9/21/2015 11:35:54 AM C:\Users\lisa\Documents\OMF_Mech_lisa.rvt

KEYED NOTES

- 1 8" CPVC COMBUSTION AIR ROUTE TO LOUVER. LOUVER PROVIDED BY OTHERS
2 8" STAINLESS STEEL FLUE UP THRU ROOF. REFER TO DETAIL TERMINATION
3 44X38 RA DN FOR CONTINUATION REFER TO SHEET OMF-MECH-PLN-M110F
4 GLYCOL MAKE UP WATER UNIT. REFER TO SPECIFICATION ???
5 OUTSIDE AIR 96X48. EXTEND UP TO GRV. FOR CONTINUATION REFER TO SHEET OMF-MECH-PLN-M130G

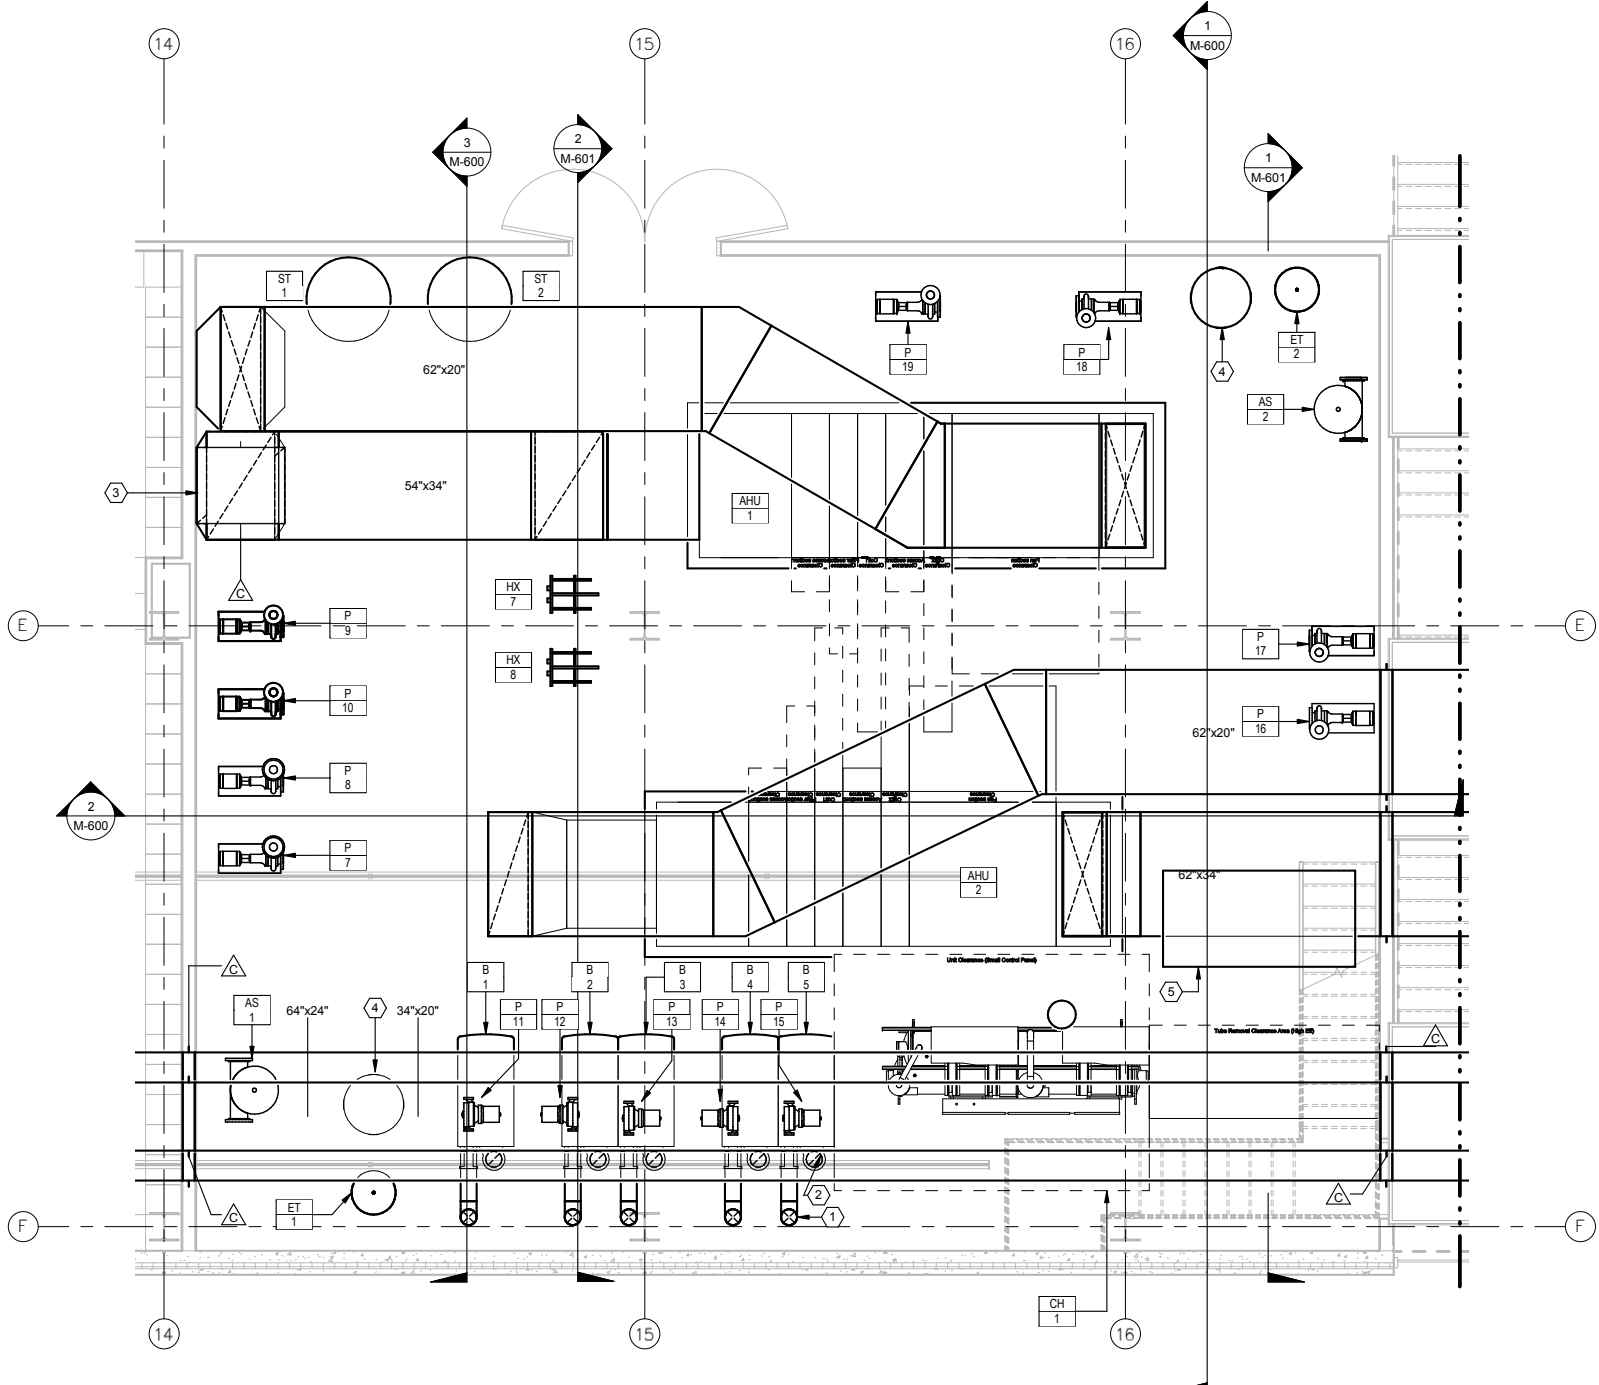

1 ENLARGED MECHANICAL ROOM HVAC PLAN
M-500 SCALE: 1/4" = 1'-0"

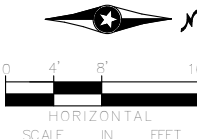[illegible]



60% SUBMISSION - 09/28/15



**OPERATIONS & MAINTENANCE FACILITY -V2B
MECHANICAL
ENLARGED MECHANICAL PLANS 1**

DISCIPLINE:	SHEET NAME:	
MECHANICAL	OMF-MECH-PLN	M-500

 SHEET
81
OF
263

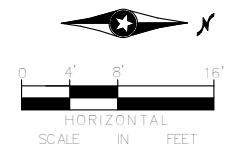

1
M-501

ENLARGED MECHANICAL ROOM PIPING PLAN

SCALE: 1/4" = 1'-0"

REF. SHEET: M-220E / REF. DETAIL: 1

[illegible]

60% SUBMISSION - 09/28/15

OPERATIONS & MAINTENANCE FACILITY -V2B	S
MECHANICAL	

ENLARGED MECHANICAL PLANS 2

DISCIPLINE:

MECHANICAL

SHEET NAME:

OMF-MECH-PLN

M-501

SHEET

32

DF

63

PLUMBING GENERAL NOTES

1. THESE DRAWINGS ARE DIAGRAMMATIC AND INTENDED TO INDICATE THE GENERAL ARRANGEMENT OF SYSTEMS AND EQUIPMENT. THEY ARE INTENDED TO SHOW SIZE, CAPACITY, APPROXIMATE LOCATION, DIRECTION AND GENERAL RELATIONSHIP OF ONE WORK PHASE TO ANOTHER, BUT NOT THE EXACT DETAIL OR ARRANGEMENT.
2. PROVIDE ALL MATERIALS, EQUIPMENT, AND PERFORM ALL LABOR REQUIRED TO INSTALL COMPLETE. OPERABLE PLUMBING SYSTEMS AS INDICATED ON THE DRAWINGS, AND AS SPECIFIED AND REQUIRED BY CODE.
3. ANY OF THESE SYMBOLS AND ABBREVIATIONS SHOWN ON THIS DRAWING MAY APPEAR ON THE PROJECT DRAWINGS. USE ONLY THOSE WHICH ARE APPLICABLE TO THIS PROJECT.
4. ELEVATIONS AS SHOWN ON THE DRAWINGS ARE TO THE BOTTOM OF ALL PRESSURE PIPING AND TO THE INVERT OF ALL GRAVITY PIPING
5. IN GENERAL, ALL PIPING AND DUCTWORK SHALL BE RUN CONCEALED IN CEILING SPACES. CERTAIN ROOMS HAVE NO SUSPENDED CEILING. PIPING AND DUCTWORK ABOVE THESE ROOMS SHALL BE RUN EXPOSED.
6. PITCH ALL PIPING AS SPECIFIED TO PERMIT THOROUGH DRAINAGE. PROVIDE AND INSTALL DRAIN VALVES AT ALL LOW POINTS WITHIN THE BUILDING.
7. TEMPERATURE SENSORS LOCATED AT OUTSIDE WALLS SHALL BE MOUNTED ON INSULATED SUB-BASED TO MINIMIZE WALL EFFECT. AFTER INSTALLATION FILL INSULATED SUB-BASE W/PLASTIC FOAM INSULATION.
8. WHEN CONFLICTS BETWEEN FLOW DIAGRAMS AND FLOOR PLANS OCCUR ON PIPE SIZING AND ACCESSORIES SUCH AS GAUGES, THERMOSTATS, FLOW METERS, VALVES, ECT. THE FLOW DIAGRAM AND DETAILS SHALL TAKE PRECEDENCE.
9. DO NOT LOCATE ANY EQUIPMENT IN THE TUBE, COIL, OR FILTER PULP AREAS REQUIRED FOR CHILLERS, COILS, BOILERS, AHU'S ETC.
10. WELDING TO STRUCTURAL MEMBERS IS NOT PERMITTED.
11. SUPPLY AIR UNIT CONSTRUCTION SHALL PERMIT COIL, FILTER, AND FAN REMOVAL WITHOUT DISMANTLING UNIT HOUSING.
12. MINIMUM CLEARANCE FROM FINISHED FLOOR TO BOTTOM OF HORIZONTAL PIPES AND DUCTWORK IN MECHANICAL ROOMS IS 7'-0".
13. ALL HORIZONTAL WATER PIPING REDUCERS SHALL BE ECCENTRIC, FLAT ON TOP. AS DETAILED ON MR SERIES DRAWINGS:
14. DO NOT USE BULL HEAD TEES ON WATER PIPING.
15. PIPE ALL COOLING, HEATING, AND REHEAT COILS FOR COUNTERFLOW OF AIR AND WATER.
16. INSTALL ALL NEW TEMPERATURE TRANSMITTERS FOR NEW VAV TERMINALS.
17. LOCATE ALL VALVES IN VERTICAL PIPING A MAXIMUM OF 6'-0" ABOVE FLOOR TO ALLOW FOR OPERATION WITHOUT USE OF A LADDER.
18. ALL NEW WORK IS SHOWN WITH SOLID (DARK) LINES AND ALL EXISTING IS SHOWN WITH SCREENED (LIGHT) LINES.
19. WHERE CAPS OR SHEET METAL CLOSURES ARE SHOWN ON EXISTING PIPING OR EXISTING DUCTWORK, SEAL WATER OR AIR TIGHT, AND REINSULATE CAPS AND CLOSURES TO MATCH EXISTING. REINSULATE AS SPECIFIED WITH THE SAME THICKNESS AS EXISTING
20. NO PIPING, DUCTWORK OR EQUIPMENT SHALL BE ABANDONED IN PLACE UNLESS SPECIFICALLY NOTED OTHERWISE. REMOVE ALL ABANDONED PIPING, DUCTWORK, AND EQUIPMENT.
21. WHERE A NEW PIPE DESIGNATION IS SHOWN ON AN EXISTING PIPE, RELABEL AS SPECIFIED.
22. ALL UNUSED PORTIONS OF THE LOUVERS WILL BE BLANKED-OFF AS SPECIFIED IN DIVISION 10.
23. ALL INVERTS SHOWN FOR CHILLED WATER, HEATING WATER, AND STEAM PIPING ARE FOR REPRESENTATION OF SLOPE AND PLACEMENT OF PIPES. ACTUAL LOCATION SHALL BE COORDINATED BY THE CONTRACTOR.
24. SEE ARCHITECTURAL PLANS FOR EXACT LOCATIONS AND SIZES OF ALL TERMINAL DEVICES (GRILLES, REGISTERS, LBD'S, LCD'S, ECT)
25. SEE EQUIPMENT SCHEDULES FOR EQUIPMENT DESIGNATIONS.
26. DUCTWORK DIMENSIONS ARE CLEAR INSIDE DIMENSIONS.
27. COORDINATE ROUTING OF DUCTWORK WITH LIGHTING AND SPRINKLER. COORDINATE ROUTING OF DUCTWORK WITH LIGHTING AND SPRINKLER LAYOUTS AND ARCHITECTURAL DETAILS.
28. SUBMIT SHOP DRAWINGS FOR LOCATION OF ALL ACCESS PANELS, INDICATING: LOCATION, SIZE, TYPE, AND STYLE. THE CONTRACTOR SHALL RELOCATE AND OR ADJUST MECHANICAL EQUIPMENT AND OR DEVICES TO ALLOW FOR A SYMMETRICAL DESIGN OF ACCESS PANEL LOCATIONS AS REQUIRED AND APPROVED BY THE ARCHITECT.
29. CONTRACTOR SHALL SURVEY THE SITE PRIOR TO PREPARATION OF BID AND PRIOR TO PREPARATION OF SHOP DRAWINGS. INFORMATION SHOWN IN THESE DRAWINGS IS BASED ON THE AVAILABLE DRAWINGS OF THE BASE BUILDING. WORK UNDER THIS CONTRACT SHALL REFLECT ACTUAL EXISTING CONDITIONS. CONTRACTOR SHALL MAKE REVISIONS AS NECESSARY TO REFLECT EXISTING CONDITIONS AT NO COST TO THE OWNER. THIS SHALL INCLUDE SHOP DRAWING PREPARATION AS WELL AS CONSTRUCTION COST.
30. PROVIDE FLEXIBLE DUCTWORK AND ROUND DUCTWORK TO DIFFUSERS OF SAME SIZE OF DIFFUSER'S NECK. REFER TO DIFFUSER SCHEDULE FOR SIZE OF DIFFUSER'S NECK.

PLUMBING GENERAL NOTES

- CONNECTIONS TO EXISTING PIPING SHALL BE MADE BY THE USE OF A PIPE TEE FITTING TO MATCH EXISTING PIPING.
- DUCTWORK TO THE INLET OF TERMINAL UNITS SHALL MATCH SIZE OF INLET OF TERMINAL UNIT.
- PROVIDE UP AND DOWN TRANSITIONS AS NECESSARY TO INSTALL DUCT & PIPE AROUND IRUM & EXISTING EQUIPMENT AND BUILDING STRUCTURE. MAKE ADJUSTMENT TO DUCTWORK AND PIPING AS NECESSARY TO COORDINATE WITH EXISTING AND NEW ELEMENTS: PIPES, DUCTS, CONDUITS, BEAMS AND BUILDING STRUCTURAL MEMBERS.
- PROVIDE DUCT TRANSITIONS TO ALL EXISTING TERMINAL UNITS. DUCT TRANSITIONS SHALL CONNECT EXISTING TERMINAL UNITS TO DUCTWORK PROVIDED BY THIS CONTRACT. REFER TO DRAWINGS FOR DUCT SIZES. VISIT SITE AND OBTAIN OUTLET SIZE OF EXISTING TERMINAL UNITS.
- CONTRACTOR TO COORDINATE LOCATION OF ALL THERMOSTATS/HUMIDISTATS AND HUMIDITY SENSORS WITH THE LATEST FURNITURE LAYOUT DRAWINGS. HEIGHT OF DEVICES SHALL BE PER ELEVATIONS ON ARCHITECTURAL DRAWINGS OR IN SPECIFICATION EXCEPT AS OTHERWISE TO COMPLY WITH AMERICANS WITH DISABILITIES ACT REQUIREMENTS.
- ALL DUCTWORK AND PIPING NEEDS TO BE INSTALLED AS HIGH AS POSSIBLE AND TIGHT TO THE SLAB ABOVE. REFER TO THE ARCHITECTURAL CEILING PLANS FOR CEILING HEIGHT REQUIREMENTS.
- SEE ARCHITECTURAL DRAWINGS AND SPECIFICATIONS FOR PENETRATION REQUIREMENTS AT UL-RATED ASSEMBLIES.
- NOTIFY THE CAR OF ANY REQUIRED SHUT-DOWN OF EXISTING SYSTEMS TO PERFORM WORK. SCHEDULE SHUT-DOWNS WITH THE CAR BEFORE PROCEEDING WITH THE WORK.
- WORK THAT AFFECTS CRITICAL SERVICES MAY NEED TO BE PERFORMED AFTER NORMAL WORKING HOURS. COORDINATE THIS WORK WITH THE CAR.
- COORDINATE ALL WORK WITH OTHER TRADES TO AVOID CONFLICTS WITH EXISTING AND NEW PIPING, VENTILATION, PLUMBING, ELECTRICAL CONDUIT, CABLE TRAYS ETC.
- WHERE RELOCATIONS ARE REQUIRED, COORDINATE WITH OTHER TRADES TO DETERMINE THE MOST PRACTICAL METHOD OF RESOLUTION WITH THE LEAST IMPACT FROM AN OVERALL PROJECT PERSPECTIVE.
- COORDINATE PIPING CONNECTIONS TO FIXTURES AND EQUIPMENT WITH ARCHITECTURAL ELEVATIONS AND EQUIPMENT SUPPLIERS.
- INSTALL ALL EQUIPMENT AND APPURTENANCE IN ACCORDANCE WITH MANUFACTURER'S RECOMMENDATIONS, CONTRACT DOCUMENT AND APPLICABLE CODES AND REGULATIONS.
- PROVIDE VIBRATIONS ISOLATION FOR ALL EQUIPMENT TO PREVENT TRANSMISSION OF BIRATION TO THE BUILDING STRUCTURE.
- PROVIDE SHUTOFF VALVES IN ALL PIPING SYSTEM BRANCHES.
- UNLESS OTHERWISE NOTED, ALL PIPING IS OVERHEAD, TIGHT OT THE UNDERSIDE OF SLAB, ABOVE DOORS & WINDOWS, WITH SPACE OF R INSULATION.
- INSTALL ALL PIPING WITHOUT FORCING OR SPRINGING AND SO THAT ALL VALVES, STRINERS, UNIONS, TRAPS, FLANGES, AND OTHER APPURTENANCES REQUIRING ACCESS ARE ACCESSIBLE.
- ALL VALVES (EXCEPT CONTROL VALVES) AND STRAINERS SHALL BE THE FULL SIZE OF THE PIPE BEFORE REDUCING THE SIZE TO MAKE CONNECTIONS TO THE EQUIPMENT AND CONTROLS.
- UNLESS OTHERWISE NOTED, DRAINS SHALL BE INSTALLED AT THE LOW POINT OF ROOFS, AREAWAYS, FLOORS, ETC.
- ALL CLEANOUTS SHALL BE THE FULL SIZE OF THE PIPE FOR PIPES 6" AND SMALLER, AND SHALL BE 6" FOR PIPE SIZES LARGER THAN 6". PROVIDE CLEANOUTS IN SANITARY AND STORM SYSTEMS AT ALL ENDS OF RUNS, AT CHANGES IN DIRECTION, NEAR THE BASE OF STACKS, EVERY 100'-0" IN HORIZONTAL RUNS AND ELSEWHERE AS DIRECTED OR AS DIRECTED BY CODE.
- ALL BALANCING VALVES AND BUTTERFLY VALVES SHALL BE PROVIDED WITH POSITION INDICATORS AND MAXIMUM ADJUSTABLE STOPS (MEMORY STOPS).
- ALL VALVES SHALL BE INSTALLED SO THE VALVE REMAINS IN SERVICE WHEN THE EQUIPMENT OR PIPING ON THE EQUIPMENT SIDE OF THE VALVE IS MOVED.
- ALL PIPING WORK SHALL BE COORDINATED WITH ALL TRADES INVOLVED. OFFSETS IN PIPING AROUND OBSTRUCTIONS SHALL BE PROVIDED AT NO ADDITIONAL COST TO THE CAR.
- ALL TEST SHALL BE COMPLETED BEFORE ANY EQUIPMENT OR PIPING INSULATIONS IS APPLIED.
- CONCRETE HOUSEKEEPING PADS TO SUE EQUIPMENT SHALL BE SIZED AND LOCATED BY THE CONTRACTOR. MINIMUM CONCRETE PAD THICKNESS SHALL BE 4" PAD SHALL EXTEND BEYOND THE EQUIPMENT A MINIMUM OF 6" ON EACH SIDE. CONCRETE HOUSEKEEPING PADS SHALL BE PROVIDED BY THE GENERAL CONTRACTOR. IT SHALL BE THE RESPONSIBILITY OF THE PLUMBING CONTRACTOR TO CORRIADINE THE SIZE AND LOCATIONS OF THE CONCRETE HOUSEKEEPING WITH THE GENERLA CONTRACTOR.
- SEE ARCHITECTURAL PLANS FOR FINAL LOCATIONS BUT NOT LIMITED TO WATER CLOSERS, LAVATORIES, SINKS, SHOWERS.
- SEE INDUSTRIAL PLANS (1-001 THRU 1-209) FOR LOCATIONS BUT NOT LIMITED TO HOSE BIBS, COMPRESSOR REDUCING AND BRANCH CONNECTIONS, COMPRESSORS, FLOOR SINKS, EMERGENCY EYEWASHES, EMERGENCY SHOWERS, THE MAINS AND BRANCH PIPING TO EQUIPMENT IS SHOWN IN THESE DRAWINGS AND SHALL BE INSTALLED BY THIS CONTRACTOR.

CODES MANUALS AND STANDARDS AS THEY APPLY

AMERICAN NATIONAL STANDARD INSTITUTE (ANSI);
AMERICAN SOCIETY OF HEATING, REFRIGERATION AND AIR CONDITIONING ENGINEERS (ASHRAE);
AMERICAN SOCIETY OF MECHANICAL ENGINEERS (ASME);
AMERICAN SOCIETY FOR TESTING AND MATERIALS (ASTM) PUBLICATIONS;
CITY CODES;
COUNTY ORDINANCES
INTERNATIONAL BUILDING CODE (IBC) PUBLICATIONS
MINNESOTA STATE STATE BUILDING CODE (MSBC);
NATIONAL ELECTRICAL CODE (NEC);
NATIONAL ELECTRICAL MANUFACTURES ASSOCIATIONS (NEMA) STANDARDS;
NATIONAL FIRE PROTECTION ASSOCIATION (NFPA) PUBLICATIONS
UNDERWRITERS LABORATORIES (UL) STANDARDS;

[illegible]

DRAWING SYMBOLS LEGEND

NOT ALL SYMBOLS DEPICTED ON THIS LEGEND ARE USED IN THE MECHANICAL DRAWINGS

SHEET NUMBER

P101

3. SHEET NUMBER
2. SHEET TYPE
1. DISCIPLINE CODE

SHEET NUMBERING EXPLANATION:

- DISCIPLINE DESIGNATOR** - SIGNIFIES THE SHEET DISCIPLINE
- SHEET TYPE DESIGNATOR** - SIGNIFIES THE TYPE OF INFORMATION ON THE SHEET
 - GENERAL (SYMBOLS, LEGENDS, NOTES, ETC.)
 - PLAN VIEWS
 - ELEVATION VIEWS
 - BUILDING SECTIONS
 - WALL SECTIONS
 - EXTERIOR DETAILS
 - VERTICAL CIRCULATION
 - INTERIOR ELEVATIONS / DETAILS
 - SCHEDULES
- SHEET SEQUENCE NUMBER** - SIGNIFIES EITHER THE NUMBER OF THE FLOOR SHOWN ON THE SHEET OR THE NEXT SEQUENTIAL NUMBER OF THAT SERIES OF SHEETS.

ROOM NAME & NUMBER TAG

ROOM NAME
A100

3. ROOM DESIGNATION
2. LEVEL NUMBER
1. BUILDING AREA DESIGNATION

ROOM NUMBER TAG EXPLANATION:

- BUILDING AREA DESIGNATION** - SIGNIFIES THE BUILDING AREA DESIGNATION THAT THE ROOM OCCURS IN
- LEVEL NUMBER** - SIGNIFIES THE LEVEL ON WHICH THE ROOM IS LOCATED
- ROOM DESIGNATION** - SIGNIFIES THE SEQUENTIAL ROOM NUMBER FOR A PARTICULAR BUILDING AREA

CONSTRUCTION PIPE TYPES

DOUBLE LINE SINGLE LINE

FUTURE

NEW

NORTH ARROW

DATUM POINT

MATCH LINE

MATCH LINE
SEE 1/M102

SHEET NUMBER ON WHICH CONTINUATION IS FOUND

BREAK LINE

DRAWING TITLE

TITLE

DRAWING

1/4" = 1'-0"

SCALE

PLAN OR DETAIL DESIGNATION

EQUIPMENT TAG

1531

MATERIAL IDENTIFICATION CODE

BUILDING SECTION TAG

DETAIL NUMBER

1

M102

SHEET NUMBER

DETAIL/ELEVATION TAG

DETAIL NUMBER

1

M102

SHEET NUMBER

GRAPHIC SCALE

0 2' 4' 8'

SCALE: 1" = 4'-0"

GRID LINES AND DESIGNATORS

KEY NOTE

XXX

VERTICAL ELEVATION

LEVEL 2
118'-6"

SPOOT ELEVATION

LEVEL 2
118'-6"

PARTIAL PLAN & DETAIL TAG

PLAN OR DETAIL NUMBER

1

M102

SHEET NUMBER

EXTERIOR ELEVATION TAG

ELEVATION DESIGNATION

1

M102

SHEET NUMBER

DRAWING REVISIONS

REVISION NUMBER

3

```

graph TD
    B1A[B-1 A] --- MA[MECHANICAL ABBREVIATIONS]
    B1A --- N[NUMBER]
    B1A --- UD[UNIT DESIGNATION]
    N --- 1[1]
    N --- 2[2]
    UD --- A[A]
    UD --- B[B]
  
```

<u>SYMBOL</u>	<u>ABBR</u>	<u>DESCRIPTION</u>
LRHS	LRHS	LOW TEMPERATURE REHEAT WATER SUPPLY
LRHR	LRHR	LOW TEMPERATURE REHEAT WATER RETURN
LHWS	LHWS	LOW TEMPERATURE HOT WATER SUPPLY
LHWR	LHWR	LOW TEMPERATURE HOT WATER RETURN
RS	RS	RADIATION WATER SUPPLY
RR	RR	RADIATION WATER RETURN
RHS	RHS	REHEAT WATER SUPPLY
RHR	RHR	REHEAT WATER RETURN
HWS	HWS	PRIMARY HEATING WATER SUPPLY
HWR	HWR	PRIMARY HEATING WATER RETURN
CHWS	CHWS	CHILLED WATER SUPPLY
CHWR	CHWR	CHILLED WATER RETURN
CWS	CWS	CONDENSER WATER SUPPLY
CWR	CWR	CONDENSER WATER RETURN
SCHWS	SCHWS	SECONDARY CHILLED WATER SUPPLY
SCHWR	SCHWR	SECONDARY CHILLED WATER RETURN
10#	10#	10 PSI STEAM (OR PRESSURE AS INDICATED)
HPR	HPR	HIGH PRESSURE STEAM RETURN
LPR	LPR	LOW PRESSURE STEAM RETURN
PC	PC	PUMPED CONDENSATE
HRS	HRS	HEAT RECOVERY SUPPLY
HRR	HRR	HEAT RECOVERY RETURN
LIQ	LIQ	REFRIGERANT (LIQUID)
SUC	SUC	REFRIGERANT (SUCTION)
HG	HG	HOT GAS
FOO	FOO	FUEL OIL OVERFLOW
FOR	FOR	FUEL OIL RETURN
FOS	FOS	FUEL OIL SUPPLY
FOV	FOV	FUEL OIL VENT
DI	DI	DEIONIZED WATER
DS	DS	DISTILLED WATER
RO	RO	REVERSE OSMOSIS WATER
90A	90A	NINETY POUND GENERAL AIR (OR OR PRESSURE, AS INDICATED)
G	G	GAS - NATURAL
VE	VE	VACUUM EXHAUST
CO2	CO2	CARBON DIOXIDE
CW	CW	COLD WATER
NP	NP	NON - POTABLE COLD WATER
HW	HW	HOT WATER
RHW	RHW	RECIRCULATION HOT WATER
140°F HW	140°F HW	140°F HW (TEMP AS NOTED)
140°F RHW	140°F	RECIRCULATING HOT WATER (TEMP AS NOTED)
F	RHW	FIRE SERVICE
FV	F	FLAMMABLE VENT
FW	FW	FLAMMABLE WASTE
CSW	FW	COLD SOFT WATER
MCW	CSW	MAKE - UP COLD WATER
ISD	MCW	INTERIOR SUB DRAIN
W	ISD	SOIL OR WASTE (SANITARY)
V	V	VENT (SANITARY)
POL	POL	PUMPED DISCHARGE LINE (SANITARY)
RWC	POL	RAIN WATER CONDUCTOR (STORM)
ORWC	ORWC	OVERFLOW RAIN WATER CONDUCTOR (STORM)
ARW	ARW/C	ACID RESISTANT SOIL OR WASTE
ARV	ARV	ACID RESISTANT VENT
LPCW	ARV	LOW PRESSURE COLD WATER
HA	LPCW	HOUSE AIR
A	HA	COMPRESSED AIR
VV	A	VAPOR VENT
V	VV	VENT OFFSET
D	V	INDIRECT DRAIN
TW	D	TEMPERED WATER
HT	TW	HEAT TRACE
WT	HT	INDIRECT WASTE
CMV	IW	COMBINATION WASTE AND VENT
	CMV	

1. PIPE CONNECTION
2. PIPE CONNECTION
3. TOP CONNECTION
4. BOTTOM CONNECTION
5. PIPE DROP
6. PIPE RISE
7. SHUT OFF VALVE
8. BALANCING VALVE
9. PIPE BREAK
10. STRAINER
11. STRAINER W/BLOWDOWN VALVE
12. UNION
13. MOTORIZED VALVE - 2 WAY
14. MOTORIZED VALVE - 3 WAY
15. CHECK VALVE
16. DRAIN VALVE
17. FLOW ARROW
18. ARROW INDICATES DIRECTION OF PIPE PITCH
19. FLEXIBLE CONNECTION
20. PIPE/DUCT CAP
21. PRESSURE AND TEMPERATURE STATION
22. TEMPERATURE TRANSMITTER IN PIPE WELL
23. RELIEF VALVE
24. PIPE GUIDE
25. ANCHOR PRESSURE GAGE
26. THERMOMETER
27. AIR VENT
28. VENTURI WATER FLOW MEASURING STATION
29. TURBIN WATER FLOW MEASURING STATION
30. METER
31. EXPANSION COMPENSTOR
32. FLOW ALARM
33. INLINE PUMP
34. CONCENTRIC PIPE REDUCER
35. ECCENTRIC PIPE REDUCER (FLAT ON TOP)
36. ECCENTRIC PIPE REDUCER (FLAT ON BOTTOM)
37. REDUCED PRESSURE ZONE BACKFLOW PREVENTER
38. SOLENOID VALVE
39. SHOCK ABSORBER (SA) (PDI SYMBOL)
40. CLEAN OUT
41. NITROGEN CONTROL CABINET
42. PRESSURE GAUGE

					1. PRESSURE TRANSMITTER
(1)	(2)	(3)	(4)	(5)	2. DIFFERENTIAL PRESSURE TRANSMITTER
					3. STATIC PRESSURE TRANSMITTER
					4. NETWORK CONTROLLER/ROUTER (NCR)
					5. MULTI FUNCTION CONTROLLER (MFC)
					6. VARIABLE FREQUENCY DRIVE
(6)	(7)	(8)			7. OVERTEMP DETECTOR
					8. DIFFERENTIAL PRESSURE MONITOR
					9.

[illegible]

METROPOLITAN
COUNCIL

STANDARD SYMBOLS AND LEGENDS

PLUMBING

OMF-PLM-GEN

P-003

63

[illegible]

SUMP PUMP AND SEWAGE EJECTOR SCHEDULE														
MARK	SYSTEM SERVED	LOCATION	PUMP TYPE	DESIGN CAPACITY (GPM)	DISCHARGE HEAD (FT)	MOTOR		BASIN SIZE			INLET (IN)	INLET ABOVE BOTTOM (IN)	VENT (IN)	REMARKS
						HP	RPM	DIAMETER (IN)	LENGTH (IN)	WIDTH (IN)				
SE 1		CLEAN STORAGE ROOM 119		0	0.0	7.50	0	4"			0"	0"	0"	3"
SE 2				0	0.0	3.00	0	0"			0"	0"	0"	4"
SE 3				0	0.0	2.00	0	0"			0"	0"	0"	4"
SE 4				0	0.0	3.00	0	0"			0"	0"	0"	4"

[illegible][illegible][illegible]

WATER SOFTENER SCHEDULE											
UNIT ID	LOCATION	EXCHANGE CAPACITY (GALLONS)	BRINE TANK SIZE (GALLONS)	RESIN (CUBIC FEET)	POUNDS OF SALT PER REGENERATION	MAXIMUM PRESSURE DROP (PSI)	MAXIMUM FLOW (GPM)	CONTINUOUS FLOW (GPM)	GRAINS HARDNESS_INLET (GRAINS)	GRAINS HARDNESS_OUTLET (GRAINS)	REMARKS
				0.00	0.00 kip	0.00	0	0	0	0	

TRAP PRIMER SCHEDULE								
UNIT ID	LOCATION	SYSTEM SERVED	TYPE EQUIPMENT	INLET PIPE DIAMETER	OUTLET PIPE DIAMETER	VOLTAGE	PHASE	REMARKS

DOMESTIC HOT WATER STORAGE TANK SCHEDULE							
UNIT ID	SYSTEM	LOCATION	VOLUME	LWT	NOMINAL HEIGHT	NOMINAL DIAMETER	REMARKS

PLUMBING FIXTURE SCHEDULE REVIT										
UNIT ID	FIXTURE TYPE	WASTE (IN)	VENT (IN)	COLD (IN)	HOT (IN)	CWFU	HWFU	MANUFACTURER	MODEL	DESCRIPTION
4" VTR			4"							
AD-1						0	0			
CO-1	FLOOR CLEANOUT					0	0			
DF-1								Elkay	LZS8WSSP	
EEW-1	EMERGENCY EYEWASH & SHOWER					0		Bradley Corporation	S19-310TT	Combination Drench Shower/Eye/Face Wash Unit
FD-1						0	0			
FD-2						0	0			
FD-3						0	0			
FWT										
L-1A		2"	2"	3/8"	3/8"					
L-2						0	0	Elkay Manufacturing	EWMA4820C	Wash-Up Lavatory Sinks
L-3						0	0	Elkay Manufacturing		Wash-Up Lavatory Sinks
L-3A						0	0	Elkay Manufacturing	WCLWO1923OSDC	Wash-Up Lavatory Sinks
L-4						0	0	Elkay Manufacturing		Wash-Up Lavatory Sinks
ORD-1										
P										
P13	STAINLESS STEEL SINK	1 1/2"	1 1/2"	1/2"	1/2"	1.5	1.5			
P29B	HOSE BIB			3/4"						
RD-1										
SE-2			0"							
SP-2			0"							
SS-1		3"	1 1/2"	3/4"	3/4"					
TD-1										
TD-2										
UR-1										
UR-1A										
WC-1				1"			0			
WC-1A				1"			0			
WH	WALL HYDRANT			3/4"		2	0			RECESSED WALL HYDRANT
WH-1	WALL HYDRANT			3/4"		2	0			RECESSED WALL HYDRANT
YH-1	WALL HYDRANT			3/4"		2	0			RECESSED WALL HYDRANT

NO	DATE	BY	CHECK	DESIGN	REVISION / SUBMITTAL	<
----	------	----	-------	--------	----------------------	---

KEYED NOTES

- 1 TERMINATE STORM 5'-0" OUTSIDE OF BUILDING. 6" STORM INV 96.0' (CIVIL-902.64), REFER TO CIVIL FOR CONTINUATION & COORDINATION.
- 2 1" NON-POTABLE WATER UP. FOR CONTINUATION REFER TO SHEET OMF-PLM-PLN-110A.

1 UNDERGROUND - PLUMBING PLAN - AREA A
 SCALE: 1/8" = 1'-0"

KEY PLAN - SCALE: N.T.S.

HORIZONTAL SCALE: 1" = 16'

[illegible]

SHEET
88
OF
263

1

A	B	C	D
E	F	G	H
	J	K	
L	M	N	

[illegible]


METROPOLITAN
COUNCIL

SOUTHWEST

89
OF
263

P-100B

TERMINATE STORM 5'-0" OUTSIDE OF BUILDING. 6"
STORM INV 96.0' (CIVIL-902.64), REFER TO CIVIL FOR
CONTINUATION & COORDINATION.

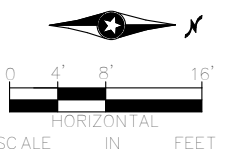[illegible]

P-100C

SHEET
90
OF
263



AECOM **LV** **ENGINEERING • LLC**
 CERTIFIED WOMEN'S
 BUSINESS ENTERPRISE

60% SUBMISSION - 09/28/15




SHEET
91
OF
263

KEYED NOTES

1. TERMINATE STORM 5'-0" OUTSIDE OF BUILDING. 6" STORM INV. 96.0' (CIVIL-902.64), REFER TO CIVIL FOR CONTINUATION & COORDINATION.
2. TERMINATE SANITARY 5'-0" OUTSIDE OF BUILDING. 6" SANITARY INV. 80.86' (CIVIL 897.5), REFER TO CIVIL FOR CONTINUATION & COORDINATION.

9/21/2015 12:05:09 PM C:\Users\lisa\Documents\OMF_Plumb_lisa.rvt

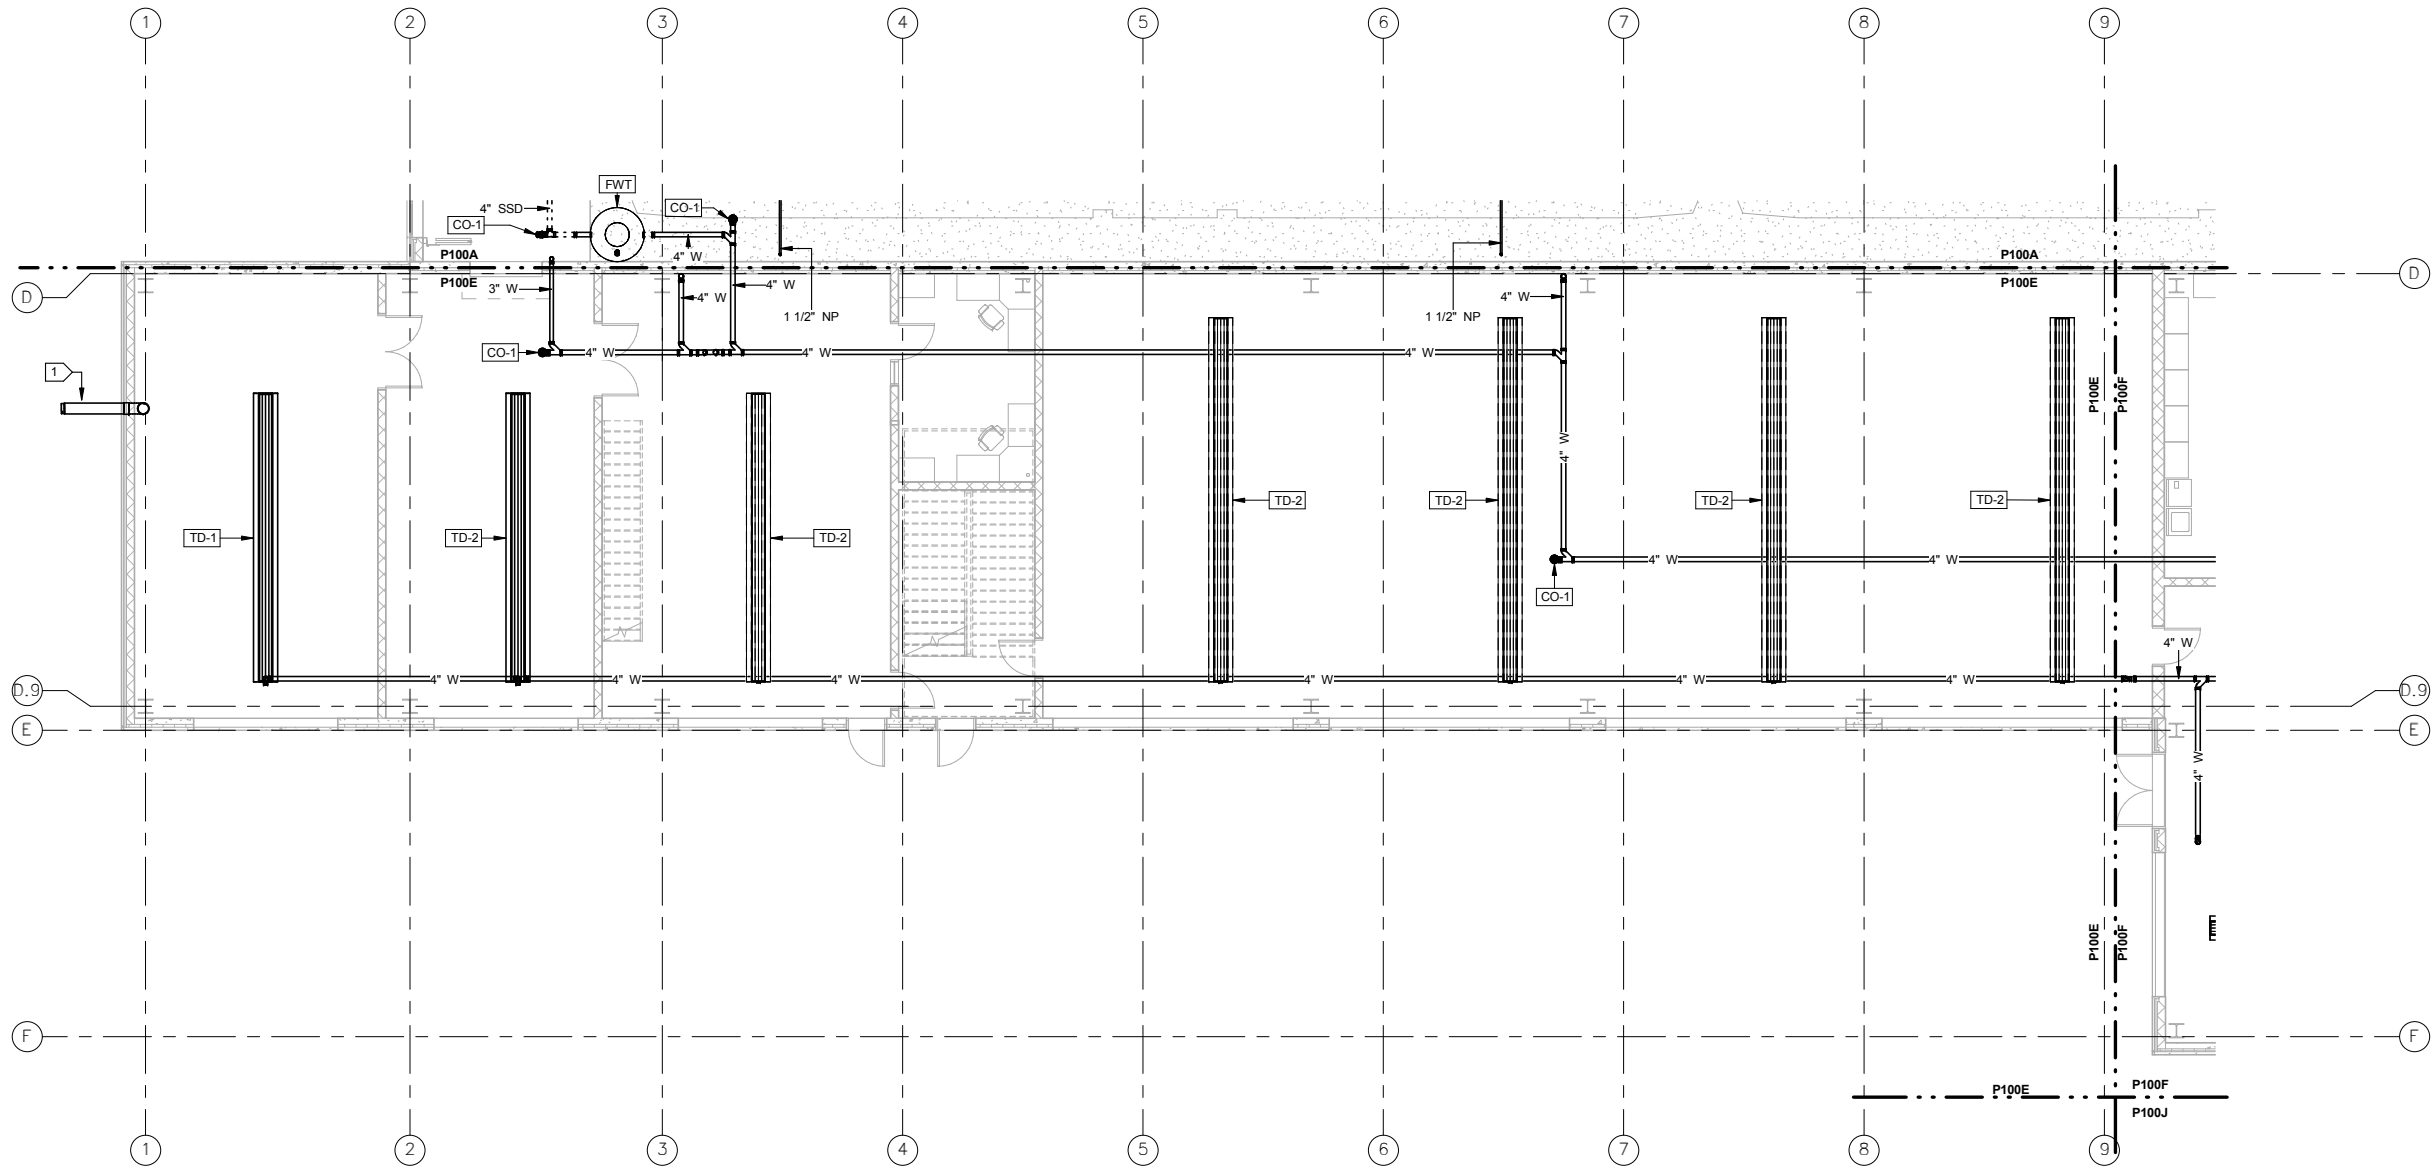


1


KEYED NOTES

TERMINATE STORM 5'-0" OUTSIDE OF BUILDING. 12" STORM INV 96.0' (CIVIL-902.64), REFER TO CIVIL FOR CONTINUATION & COORDINATION.

1 UNDERGROUND - PLUMBING PLAN - AREA E
P-100E SCALE: 1/8" = 1'-0"

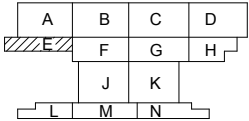


KEY PLAN - SCALE: N.T.S.

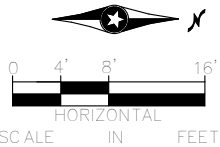


NO	DATE	BY	CHECK	DESIGN	REVISION / SUBMITTAL

 AECOM	 ENGINEERING • LLC CERTIFIED WOMEN'S BUSINESS ENTERPRISE	 METROPOLITAN COUNCIL	 SOUTHWEST	OPERATIONS & MAINTENANCE FACILITY -V2B			SHEET 92 OF 263
				PLUMBING UNDERGROUND - PARTIAL PLUMBING PLAN AREA E			
60% SUBMISSION - 09/28/15				DISCIPLINE: PLUMBING	SHEET NAME: OMF-PLM-PLN	P-100E	

KEYED NOTES

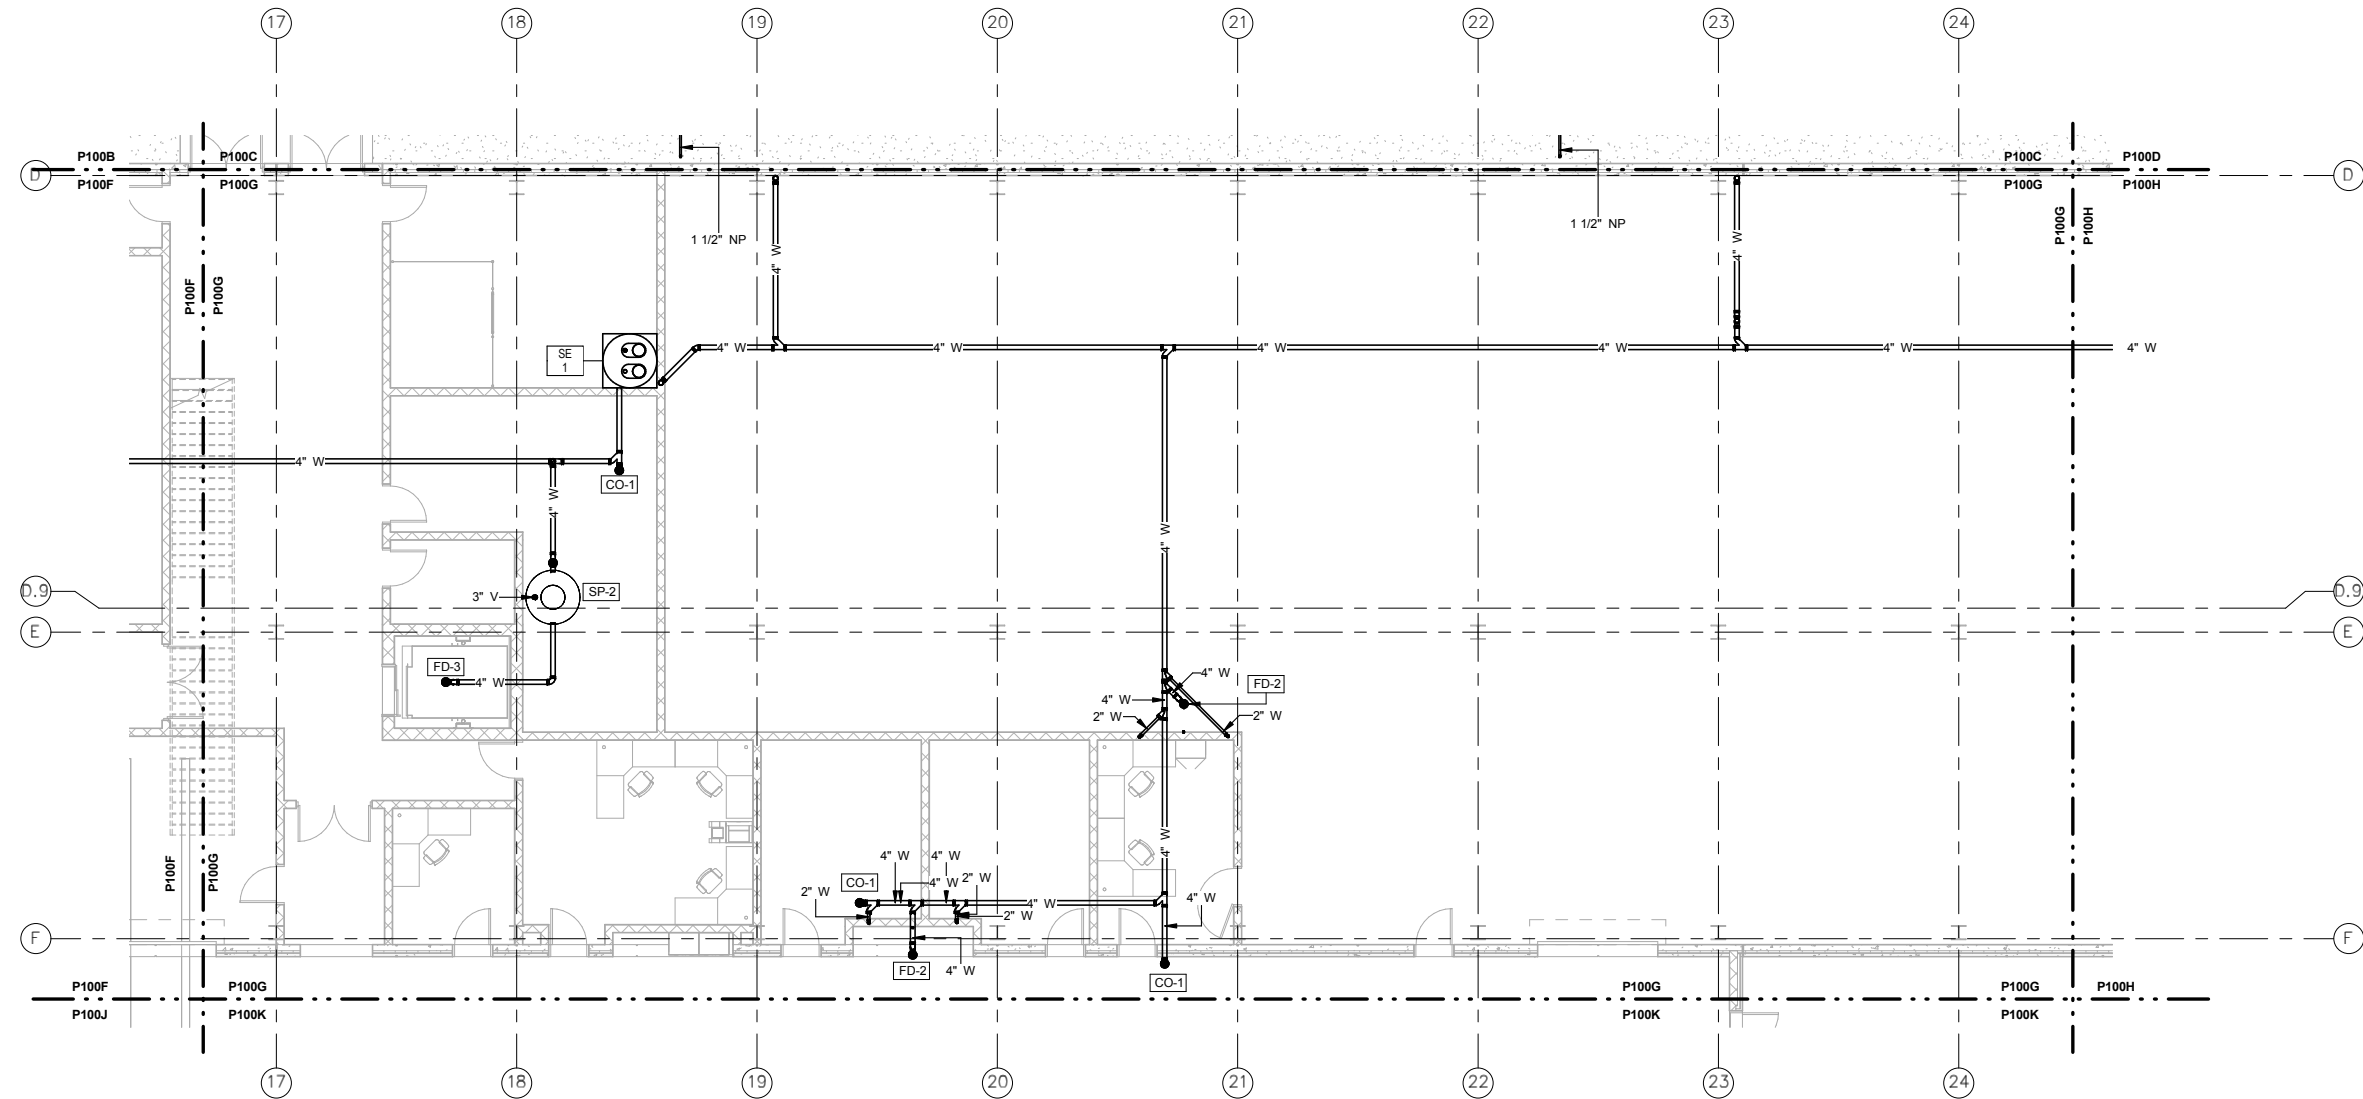

1 UNDERGROUND - PLUMBING PLAN - AREA G
P-100G SCALE: 1/8" = 1'-0"

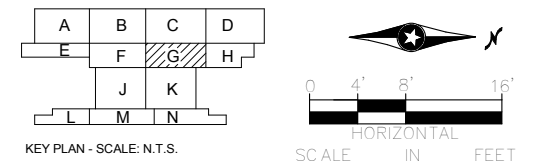[illegible]

60% SUBMISSION - 09/28/15




OPERATIONS & MAINTENANCE FACILITY -V2B
PLUMBING
UNDERGROUND - PARTIAL PLUMBING PLAN
AREA G

DISCIPLINE:	SHEET NAME:	
PLUMBING	OMF-PLM-PLN	P-100G


SHEET
94
OF
263

9/21/2015 12:05:15 PM C:\Users\lisa\Documents\OMF_Plumb_lisa.rvt

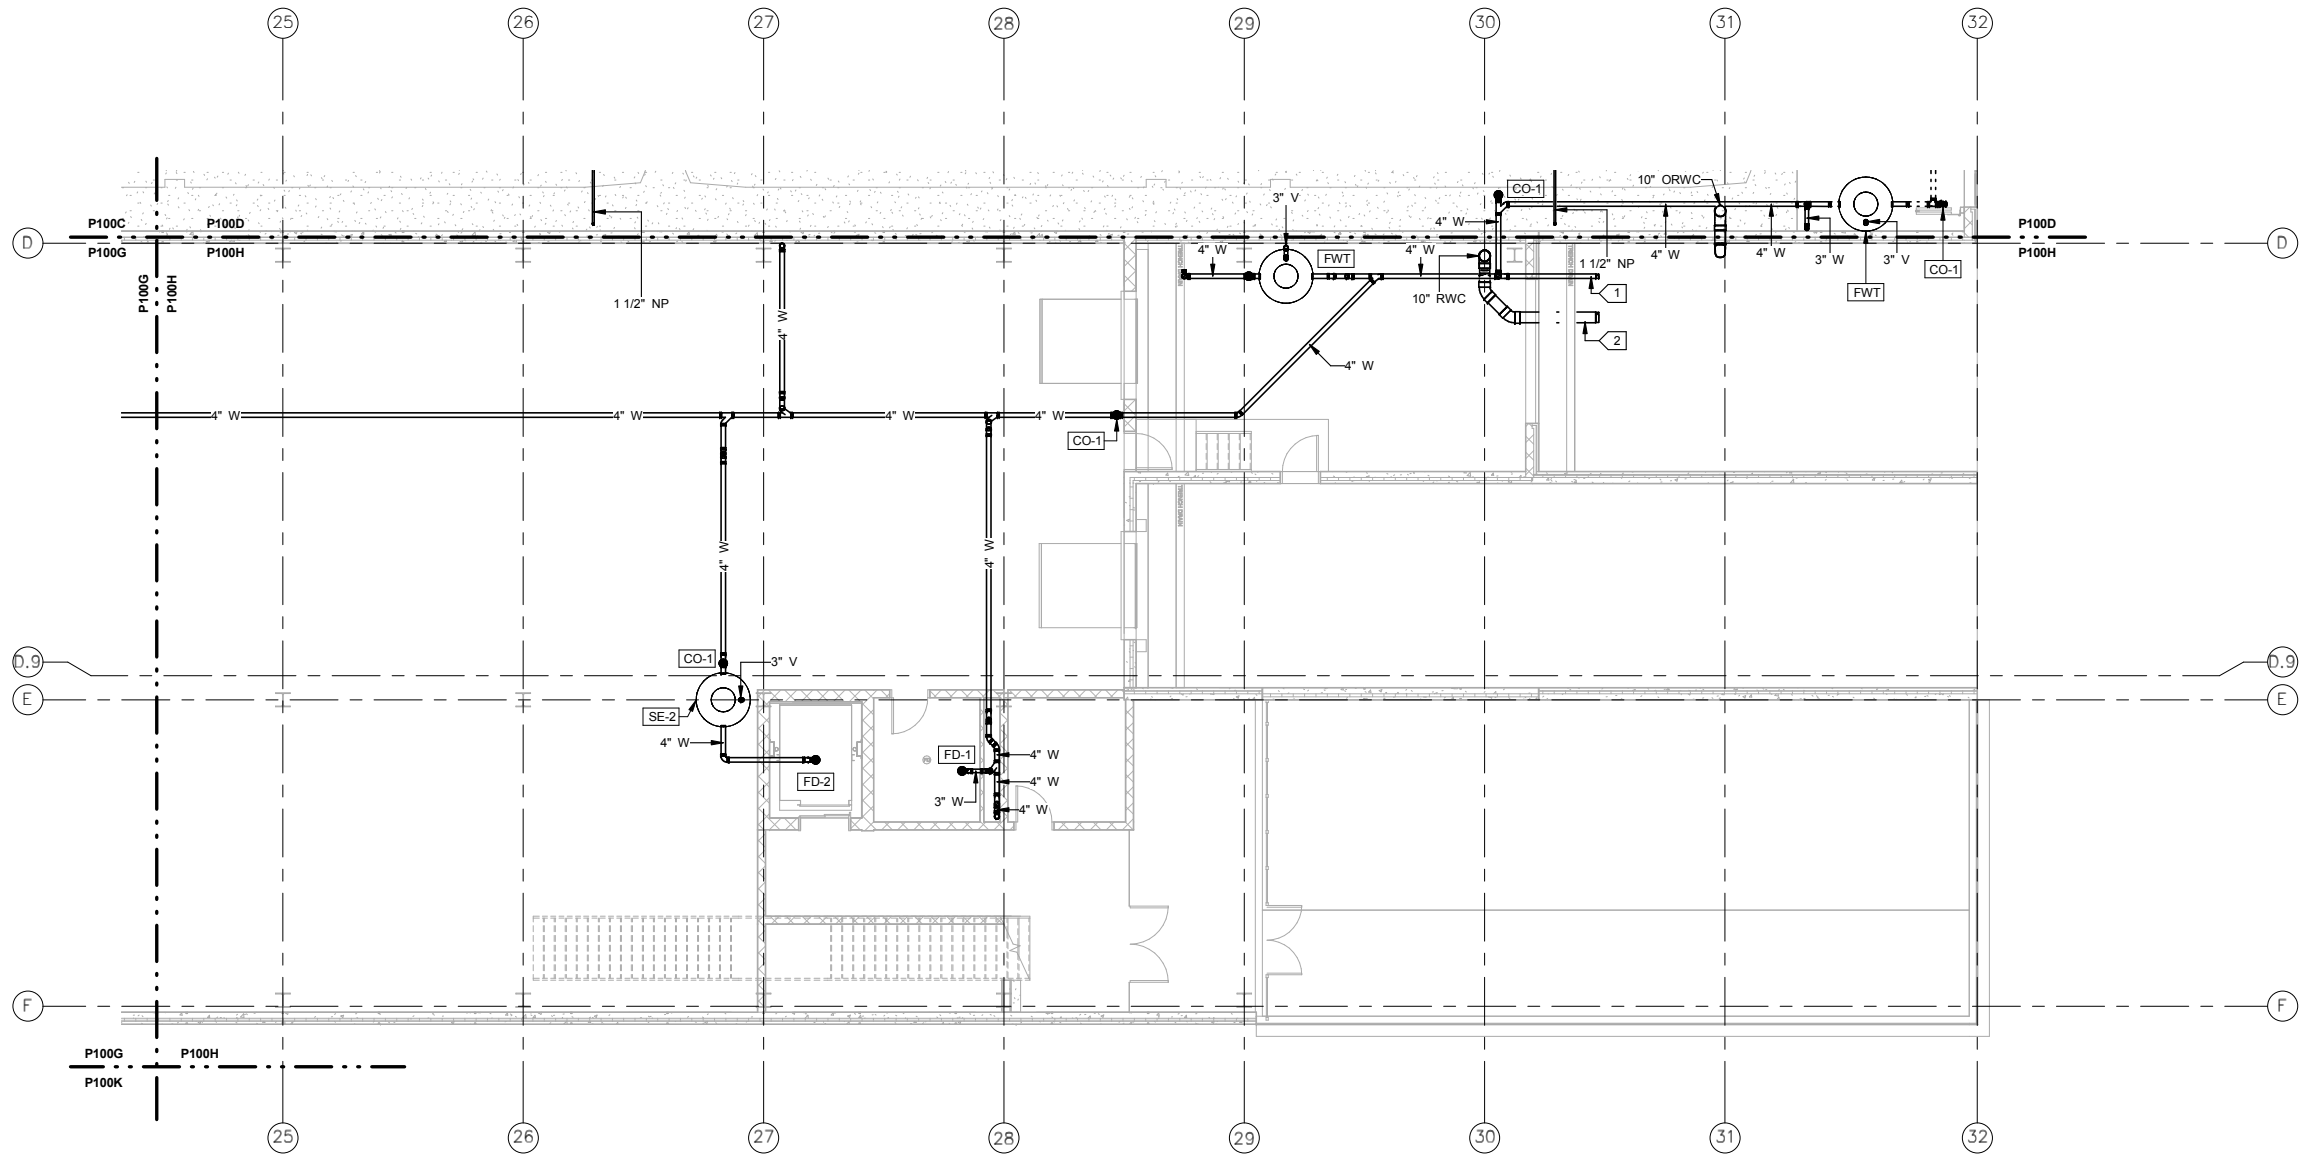


- KEYED NOTES**
- 1 TERMINATE SANITARY 5'-0" OUTSIDE OF BUILDING. 6" SANITARY INV. 80.86' (CIVIL 897.5). REFER TO CIVIL FOR CONTINUATION & COORDINATION.
 - 2 TERMINATE STORM 5'-0" OUTSIDE OF BUILDING. 12" STORM INV 94.0' (CIVIL-900.56), REFER TO CIVIL FOR CONTINUATION & COORDINATION.

1 UNDERGROUND - PLUMBING PLAN - AREA H
P-100H SCALE: 1/8" = 1'-0"

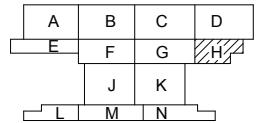

KEY PLAN - SCALE: N.T.S.

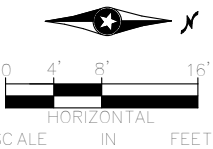


NO	DATE	BY	CHECK	DESIGN	REVISION / SUBMITTAL

AECOM

ENGINEERING • LLC
CERTIFIED WOMEN'S
BUSINESS ENTERPRISE



 SOUTHWEST




60% SUBMISSION - 09/28/15

OPERATIONS & MAINTENANCE FACILITY -V2B
PLUMBING
UNDERGROUND - PARTIAL PLUMBING PLAN
AREA H


DISCIPLINE:
PLUMBING

SHEET NAME:
OMF-PLM-PLN P-100H

SHEET
95
OF
263

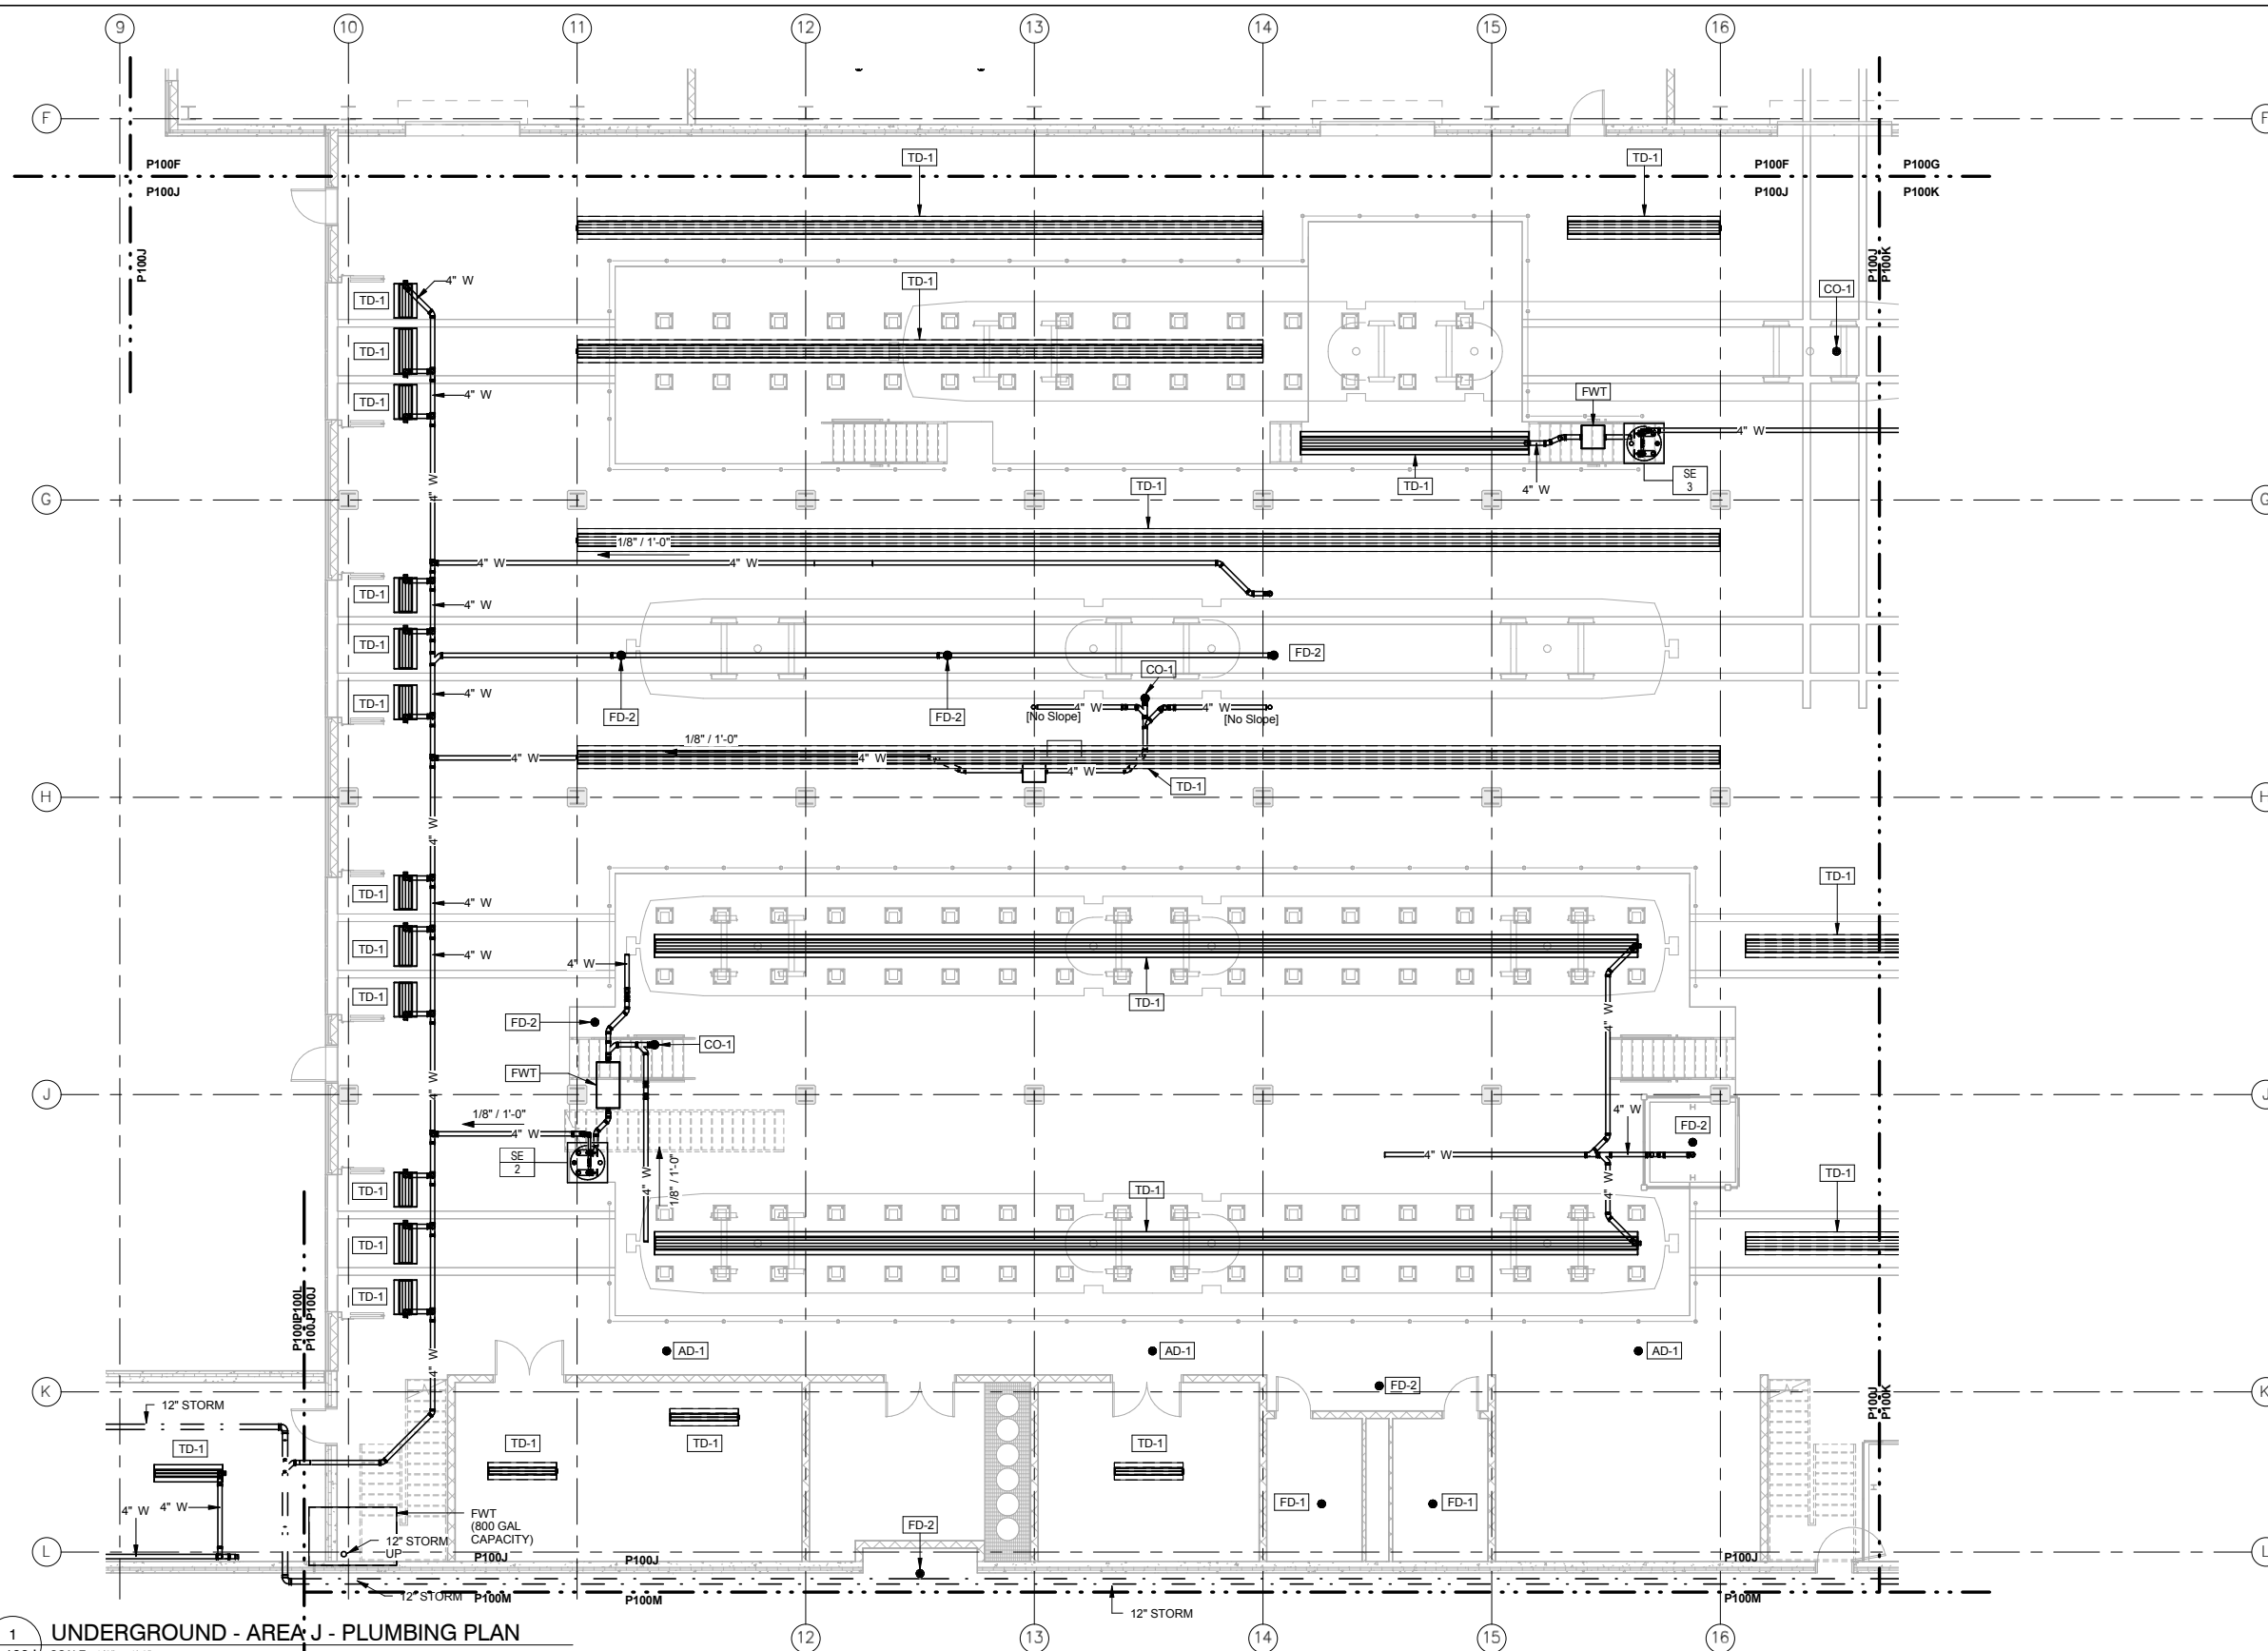

KEYED NOTES

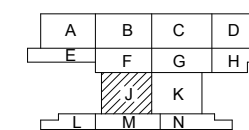

KEY PLAN - SCALE: N.T.



1 UNDERGROUND - AREA J - PLUMBING PLAN
P-100J SCALE: 1/8" = 1'-0"

[illegible]**AECOM**

ENGINEERING • LLC
CERTIFIED WOMEN'S
BUSINESS ENTERPRISE

60% SUBMISSION - 09/28/15




**OPERATIONS & MAINTENANCE FACILITY -V2B
PLUMBING
UNDERGROUND - PARTIAL PLUMBING PLAN
AREA J**

DISCIPLINE: **PLUMBING**

SHEET NAME:	OMF-PLM-PLN	P-100J
-------------	-------------	--------

3 SHEET
96
OF
263

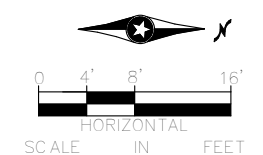

KEY PLAN - SCALE: N.T.S.

HORIZONTAL
SCALE IN FEET

[illegible]

SOUTHWEST

60% SUBMISSION - 09/28/15

OPERATIONS & MAINTENANCE FACILITY -V2B
PLUMBING
UNDERGROUND - PARTIAL PLUMBING PLAN
AREA K

DISCIPLINE:

 
PLUMBING

SHEET NAME:

NAME: **OMF-PLM-PLN**

P-100K

SHEET
97
OF
263



KEY PLAN - SCALE: N.T.S.


The key plan shows a building layout with rooms labeled A through N. Rooms A, B, C, and D are in the top row. Rooms E, F, G, and H are in the second row. Rooms J and K are in the third row. Rooms L, M, and N are in the bottom row. A north arrow points towards the top right. A horizontal scale bar is shown below the plan, with markings at 0, 4', 8', and 16'.

[illegible]



OPERATIONS & MAINTENANCE FACILITY -V2B
PLUMBING
UNDERGROUND - PARTIAL PLUMBING PLAN
AREA L

P-100L

SHEET
98
OF
263

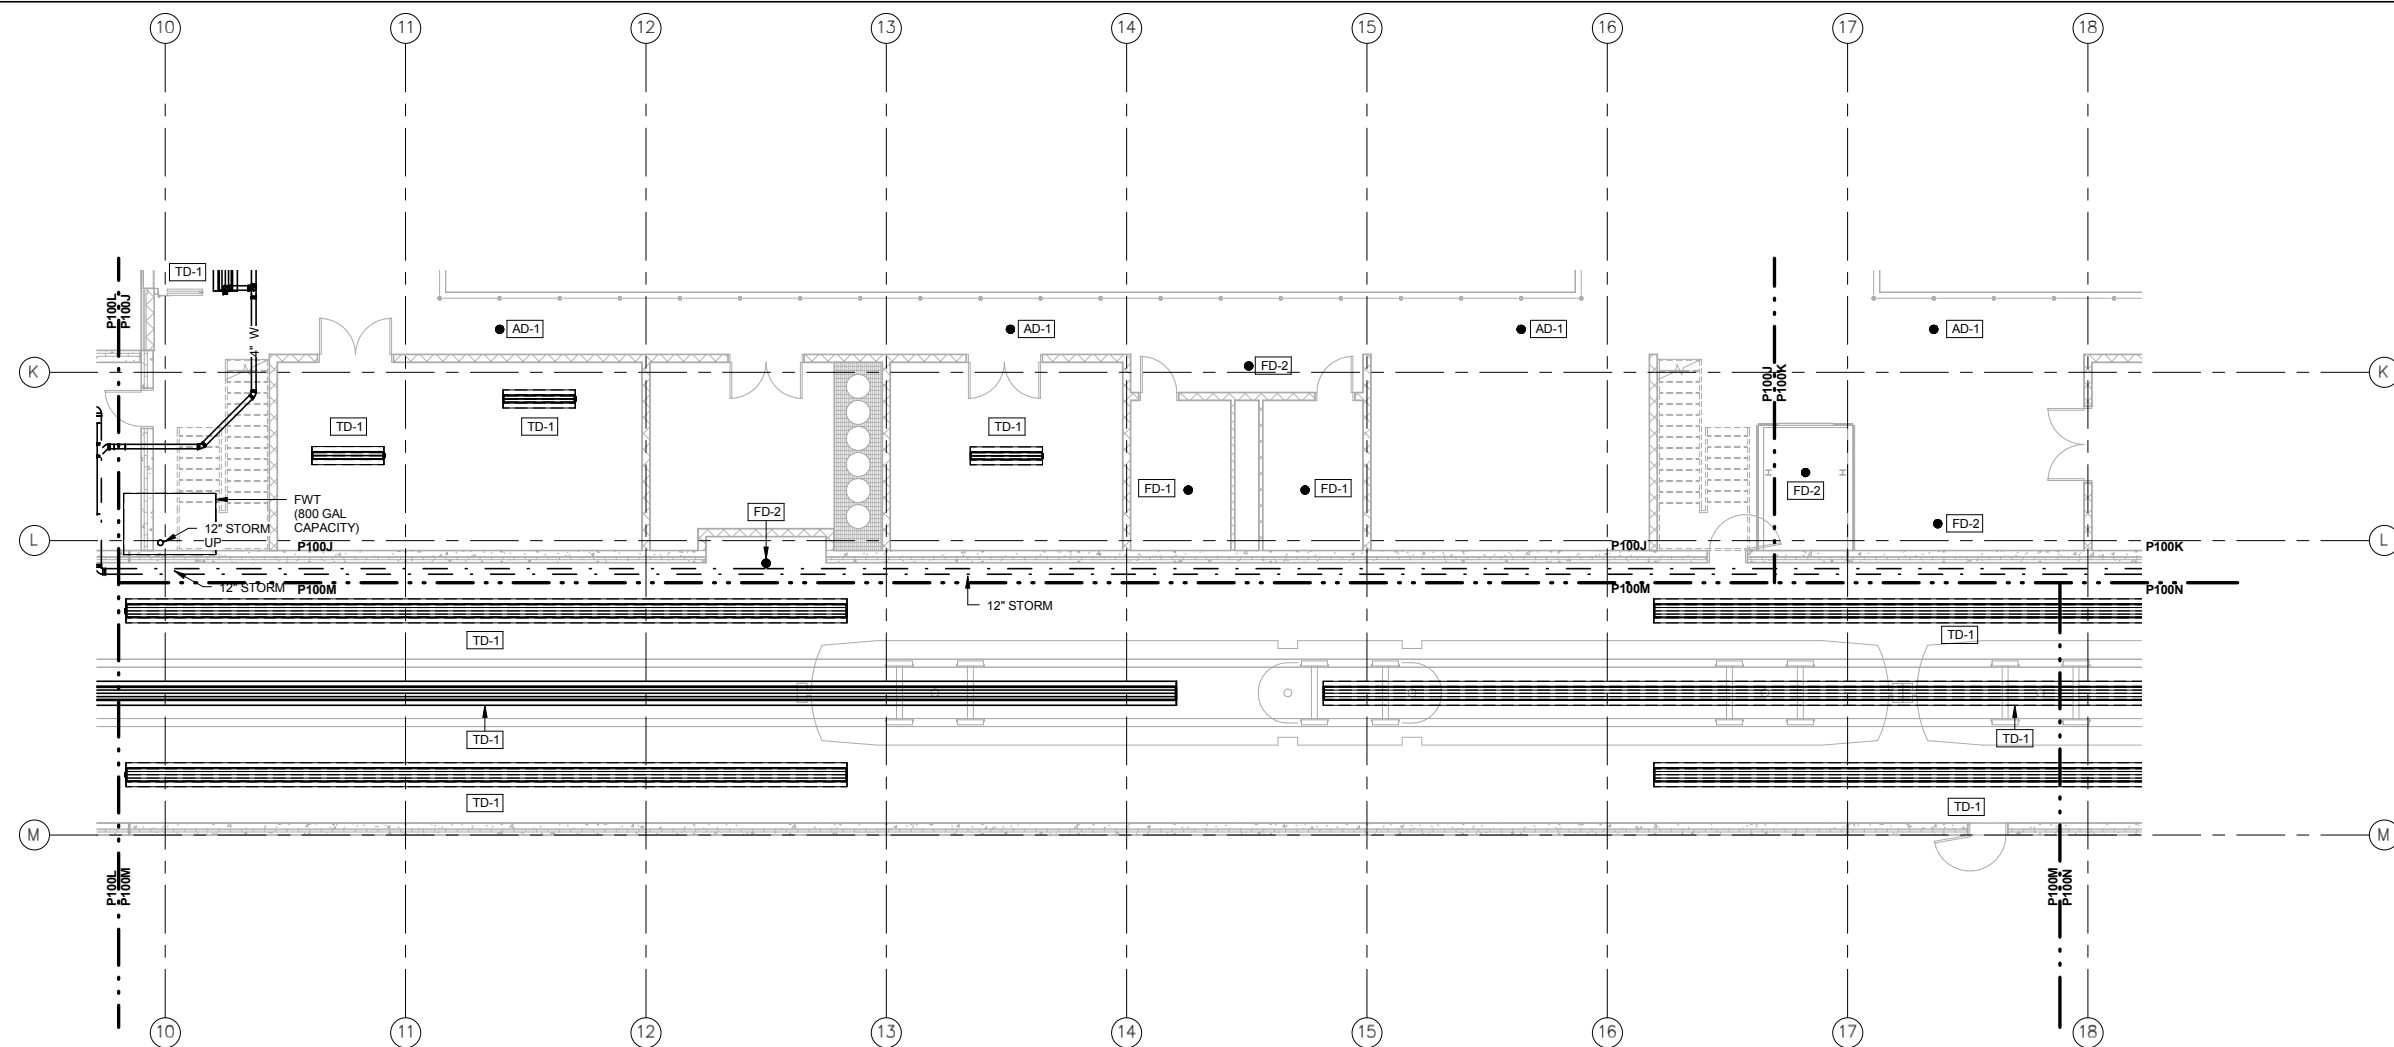

1 UNDERGROUND - PLUMBING PLAN - AREA M
P-100M SCALE: 1/8" = 1'-0"

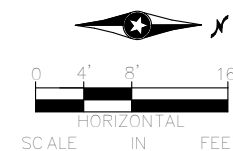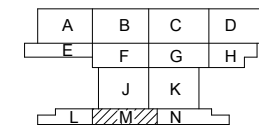
[illegible]

OPERATIONS & MAINTENANCE FACILITY -V2B
PLUMBING
UNDERGROUND - PARTIAL PLUMBING PLAN
AREA M

DISCIPLINE:	SHEET NAME:	
PLUMBING	OMF-PLM-PLN	P-100M



 TERMINATE WATER SERVICE 5'-0" OUTSIDE OF BUILDING. 8" COMBINED DOMESTIC AND FIRE PROTECTION SERVICE INV. 92.5' (CIVIL 898.40). SEE CIVIL FOR CONTINUATION & COORDINATION.


[illegible]

DISCIPLINE: **PLUMBING**


SHEET NAME:	OMF-PLM-PLN	P-100N
-------------	-------------	--------

3 SHEET
100
OF
263

KEYED NOTES

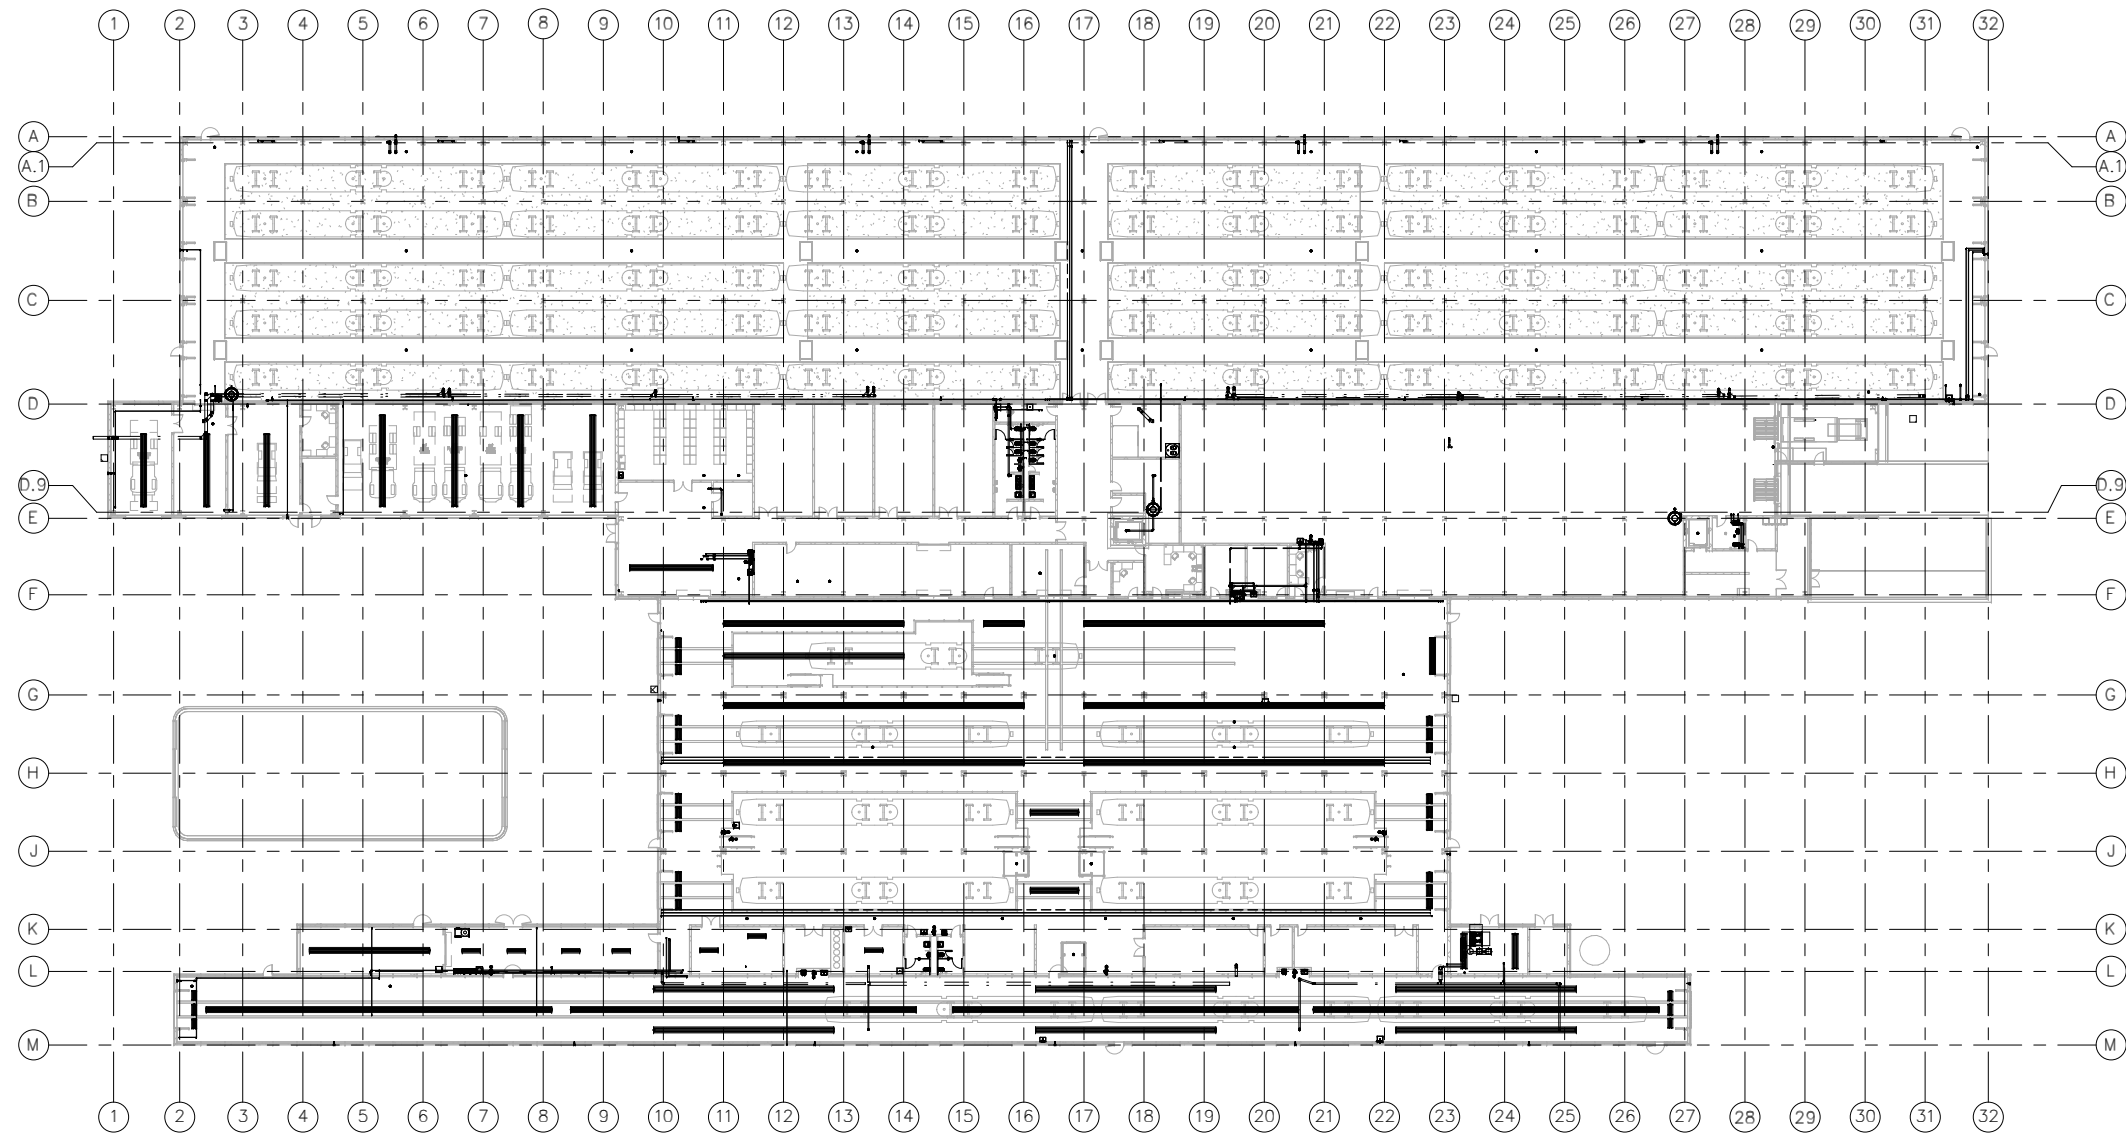

1 OVERALL LEVEL ONE PLUMBING PLAN

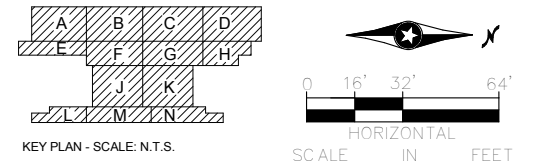[illegible]

60% SUBMISSION - 09/28/15

OPERATIONS & MAINTENANCE FACILITY -V2B
PLUMBING
LEVEL ONE OVERALL PLUMBING FLOOR
PLAN

DISCIPLINE:

PLUMBING



SHEET NAME:

OMF-PLM-PLN

P-110

SHEET
101
OF
263

1. SEE INDUSTRIAL PLAN (I-001-I-208) FOR LOCATIONS OF HOSE BIBBS, COMPRESSOR REELS, COMPRESSED AIR CONNECTIONS, COMPRESSORS, FLOOR SINKS, EMERGENCY EYEWASH, EMERGENCY SHOWERS, WATER CLOSETS, LAVATORIES, SINKS, SHOWERS. THE MAINS TO THE APPROXIMATE FIXTURE LOCATIONS ARE SHOWN IN THESE PLUMBING ADVANCED DESIGN SHEETS.

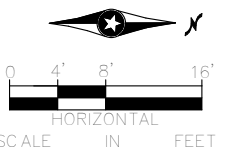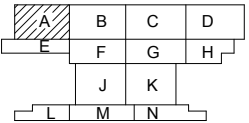[illegible]

ENGINEERING • LLC
CERTIFIED WOMEN'S
BUSINESS ENTERPRISE



METROPOLITAN
COUNCIL


SOUTHWEST

DISCIPLINE: **PLUMBING**

SHEET NAME:	
OMF-PLM-PLN	P-110A

SHEET
102
OF
263

1. SEE INDUSTRIAL PLAN (I-001-I-208) FOR LOCATIONS OF HOSE BIBBS, COMPRESSOR REELS, COMPRESSED AIR CONNECTIONS, COMPRESSORS, FLOOR SINKS, EMERGENCY EYEWASH, EMERGENCY SHOWERS, WATER CLOSETS, LAVATORIES, SINKS, SHOWERS. THE MAINS TO THE APPROXIMATE FIXTURE LOCATIONS ARE SHOWN IN THESE PLUMBING ADVANCED DESIGN SHEETS.


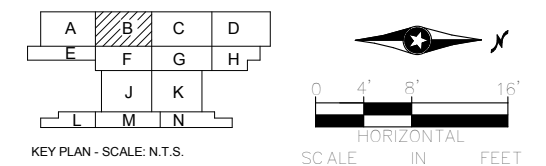
[illegible]

OPERATIONS & MAINTENANCE FACILITY -V2B
PLUMBING
LEVEL ONE - PARTIAL PLUMBING PLAN
AREA B

DISCIPLINE:	SHEET NAME:
PLUMBING	OMF-PLM-PLN P-110B

SHEET
103
OF
263

1. SEE INDUSTRIAL PLAN (I-001-I-208) FOR LOCATIONS OF HOSE BIBBS, COMPRESSOR REELS, COMPRESSED AIR CONNECTIONS, COMPRESSORS, FLOOR SINKS, EMERGENCY EYEWASH, EMERGENCY SHOWERS, WATER CLOSETS, LAVATORIES, SINKS, SHOWERS. THE MAINS TO THE APPROXIMATE FIXTURE LOCATIONS ARE SHOWN IN THESE PLUMBING ADVANCED DESIGN SHEETS.

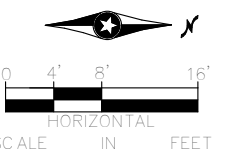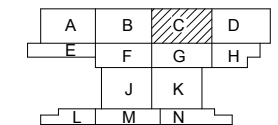[illegible]

LV
ENGINEERING • LLC
CERTIFIED WOMEN'S
BUSINESS ENTERPRISE



METROPOLITAN
COUNCIL

SOUTHWEST

DISCIPLINE:


SHEET NAME:

P-110C

HEET
104
OF
263


SHEET NOTES:

1. ALL PIPING IS ROUTED HIGH (20')
2. DUE TO HIGH ROUTING (20'), PIPING CAN BE SEEN ON THIS PLAN SHEET AND SHEET P-301
3. COMPRESSOR SUPPLIES 100 PSI WITH REGULATORS IN-LINE PROVIDING TOOL NEEDS
4. SEE DESIGN NARRATIVE FOR VENTING
5. SEE INDUSTRIAL PLAN (I-001-I-208) FOR LOCATIONS OF HOSE BIBBS, COMPRESSOR REELS, COMPRESSED AIR CONNECTIONS, COMPRESSORS, FLOOR SINKS, EMERGENCY EYEWASH, EMERGENCY SHOWERS, WATER CLOSETS, LAVATORIES, SINKS, SHOWERS. THE MAINS TO THE APPROXIMATE FIXTURE LOCATIONS ARE SHOWN IN THESE PLUMBING ADVANCED DESIGN SHEETS.

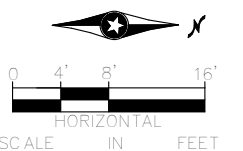

SHEET
105
OF
263

P-110D

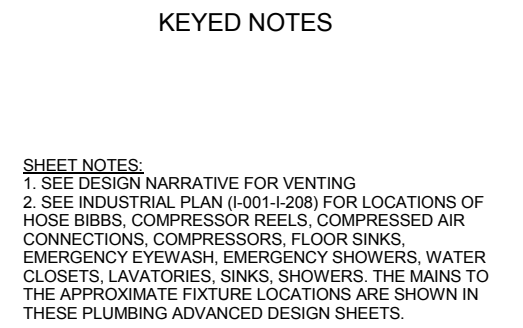

KEY PLAN - SCALE: N.T.S.


The key plan shows a site layout with rooms labeled A through N. The layout is as follows:

- Top row: A, B, C, D
- Second row: E, F (hatched), G, H
- Third row: J, K
- Bottom row: L, M, N


Below the key plan is a compass rose indicating North (N) and a scale bar. The scale bar is marked in feet: 0, 4', 8', and 16'. The text "HORIZONTAL" is written above the scale bar.

 	 	OPERATIONS & MAINTENANCE FACILITY -V2B PLUMBING LEVEL ONE - PARTIAL PLUMBING PLAN AREA F		SHEET 107 OF 263
60% SUBMISSION - 09/28/15		DISCIPLINE: PLUMBING	SHEET NAME: OMF-PLM-PLN P-110F	

KEYED NOTES

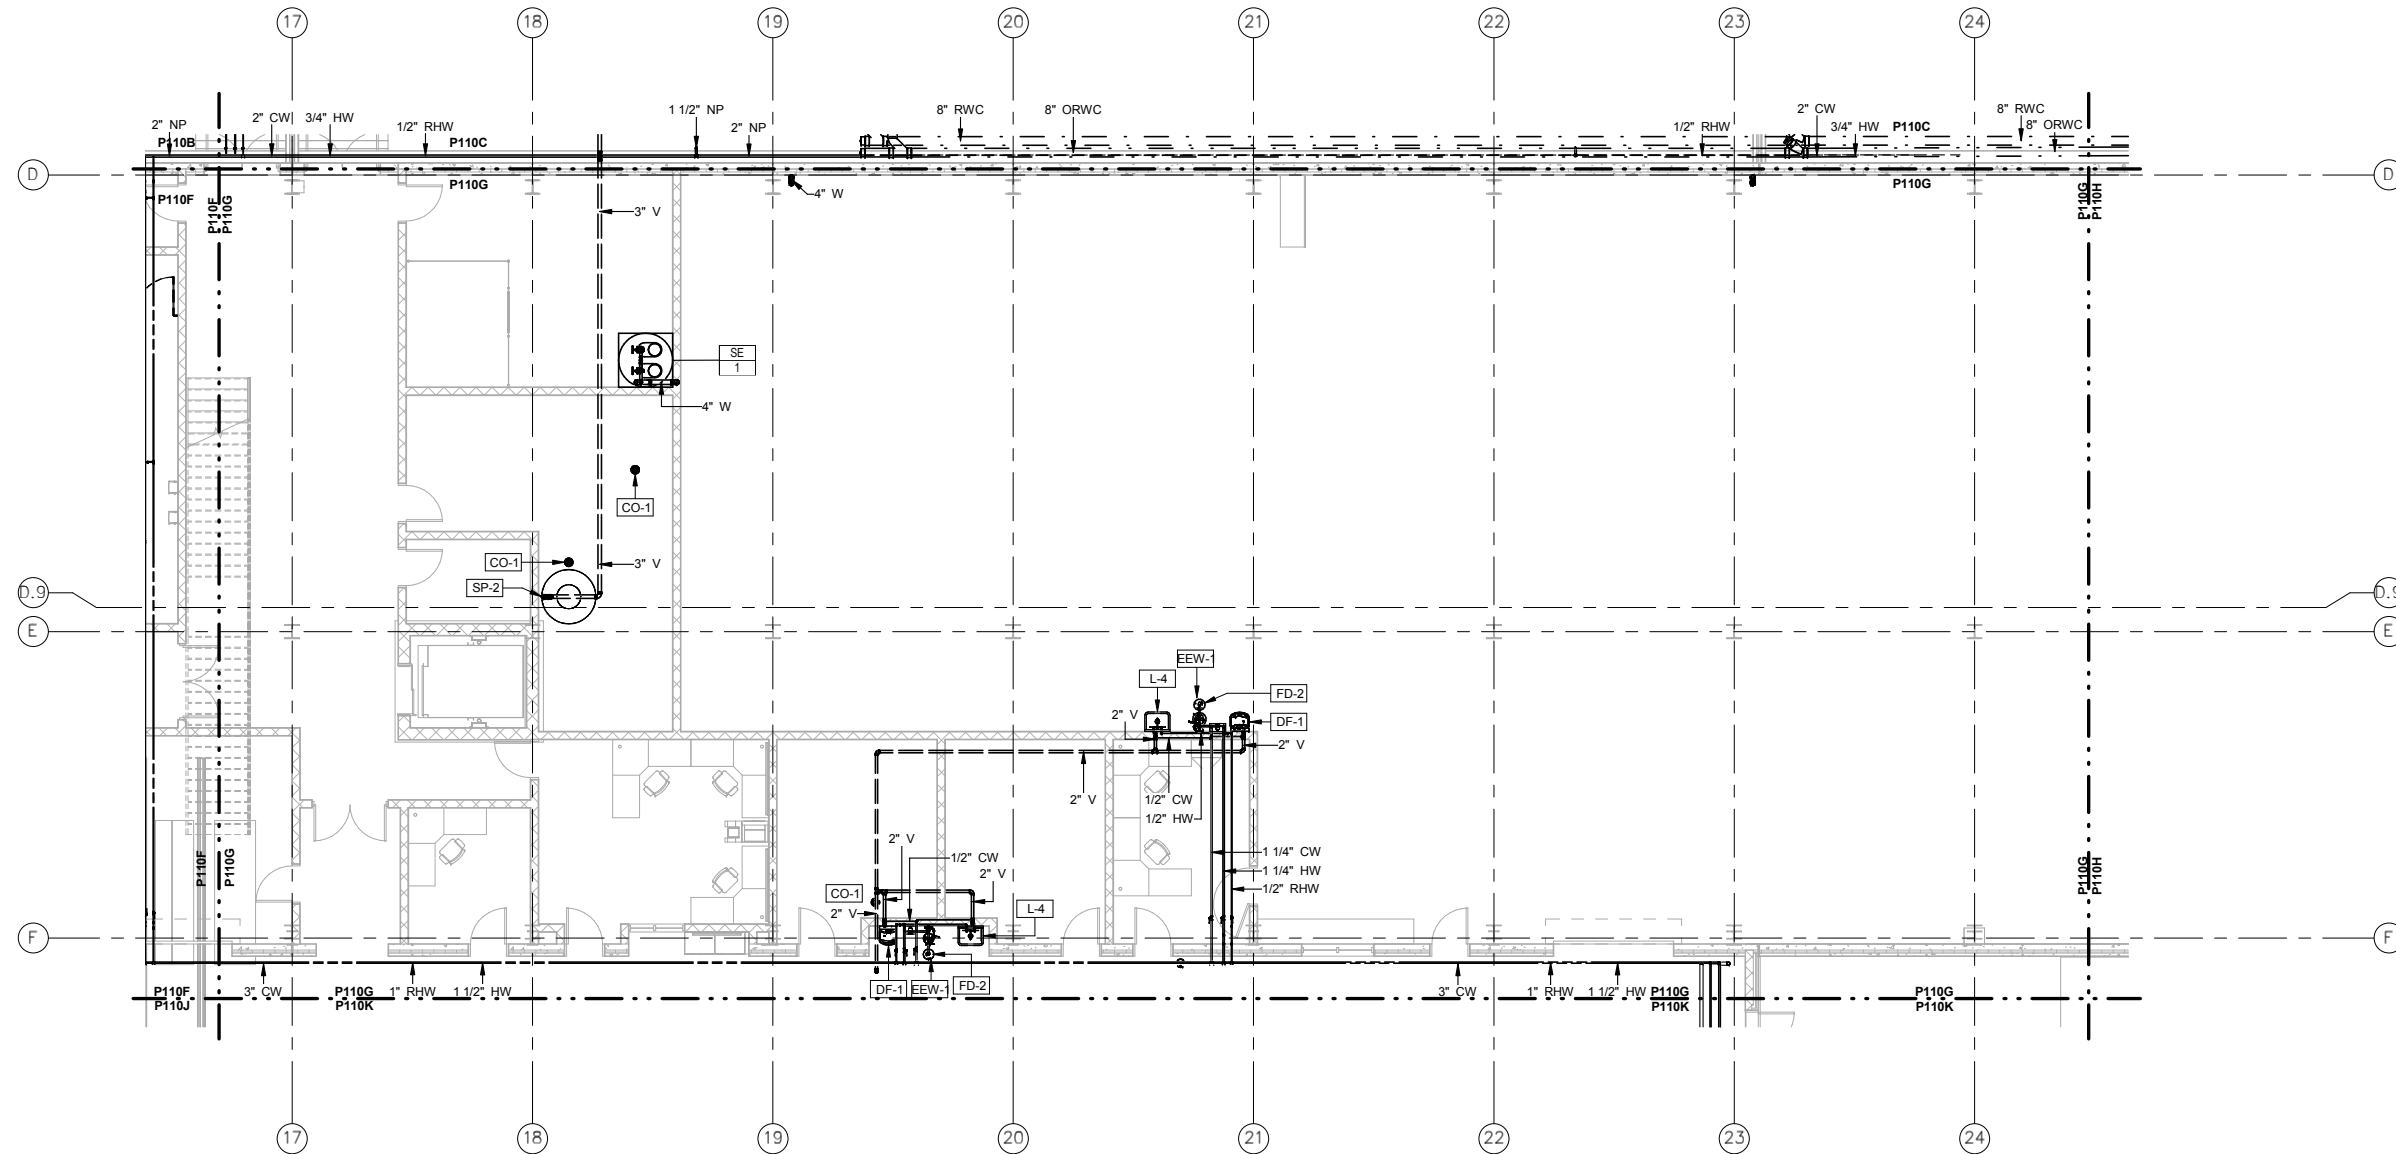

1 LEVEL ONE - PLUMBING PLAN - AREA G
P-110G SCALE: 1/8" = 1'-0"

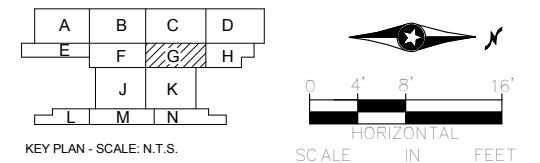[illegible]**AECOM**

LV
ENGINEERING • LLC
CERTIFIED WOMEN'S
BUSINESS ENTERPRISE



METROPOLITAN
COUNCIL

SOUTHWEST

OPERATIONS & MAINTENANCE FACILITY -V2B
PLUMBING
LEVEL ONE - PARTIAL PLUMBING PLAN
AREA G

SHEET
108
OF
263

60% SUBMISSION - 09/28/15

DISCIPLINE:

PLUMBING


SHEET NAME:

NAME: **OMF-PLM-PLN**


P-110G

KEYED NOTES


- SHEET NOTES:**
- 1. ALL PIPING IS ROUTED HIGH (25.5') TO AVOID CRANE PATHS AND TO SERVE MEZZANINE ELEVATIONS
 - 2. DUE TO HIGH ROUTING, PIPING CAN BE SEEN ON THIS PLAN SHEET AND SHEET P-203
 - 3. SEE DESIGN NARRATIVE FOR VENTING
 - 4. COMPRESSOR SUPPLIES 100 PSI WITH REGULATORS IN LINE FOR TOOL NEEDS
 - 5. SEE INDUSTRIAL PLAN (I-001-I-208) FOR LOCATIONS OF HOSE BIBBS, COMPRESSOR REELS, COMPRESSED AIR CONNECTIONS, COMPRESSORS, FLOOR SINKS, EMERGENCY EYEWASH, EMERGENCY SHOWERS, WATER CLOSETS, LAVATORIES, SINKS, SHOWERS. THE MAINS TO THE APPROXIMATE FIXTURE LOCATIONS ARE SHOWN IN THESE PLUMBING ADVANCED DESIGN SHEETS.

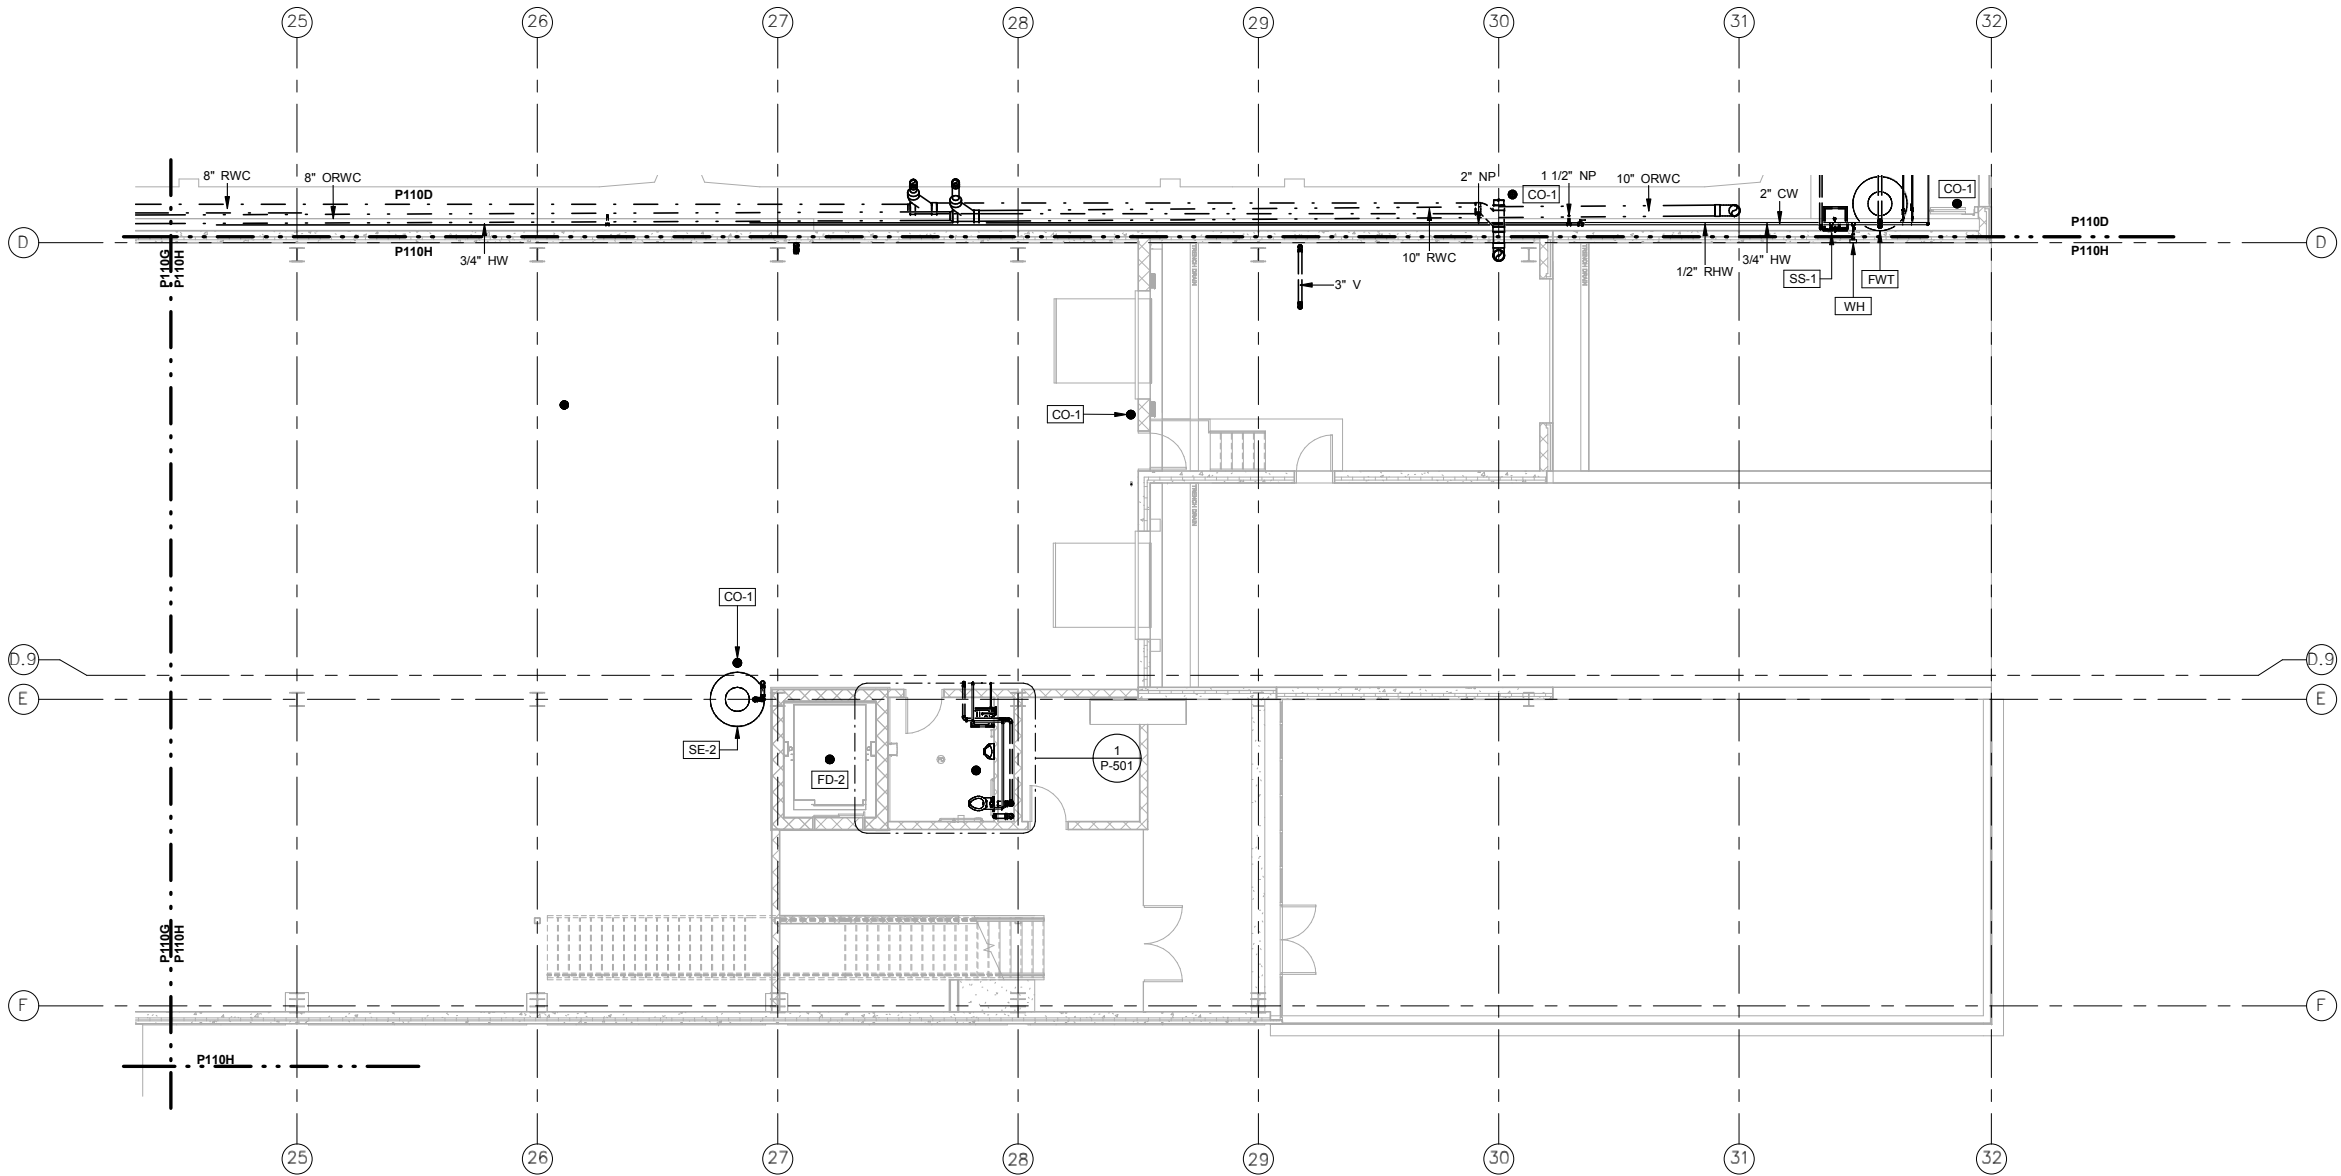

1 LEVEL ONE - PLUMBING PLAN - AREA H
P-110H SCALE: 1/8" = 1'-0"

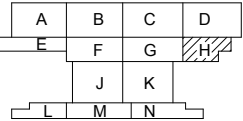

KEY PLAN - SCALE: N.T.S.

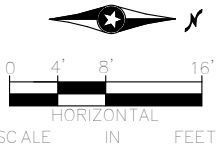

NO	DATE	BY	CHECK	DESIGN	REVISION / SUBMITTAL

AECOM

ENGINEERING • LLC
CERTIFIED WOMEN'S BUSINESS ENTERPRISE

METROPOLITAN
C O U N C I L

SOUTHWEST

60% SUBMISSION - 09/28/15

OPERATIONS & MAINTENANCE FACILITY -V2B
PLUMBING
LEVEL ONE - PARTIAL PLUMBING PLAN
AREA H


DISCIPLINE: **PLUMBING**
SHEET NAME: **OMF-PLM-PLN**
P-110H

SHEET
109
OF
263



	A	B	C	D
E		F	G	H
		J	K	
L		M	N	

KEY PLAN - SCALE: N.T.S.

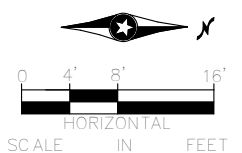[illegible]

LV
ENGINEERING • LLC
CERTIFIED WOMEN'S
BUSINESS ENTERPRISE



HEET
110
OF
263


DISCIPLINE:

PLUMBING

SHEET NAME:

NAME: **OMF-PLM-PLN**

P-110J

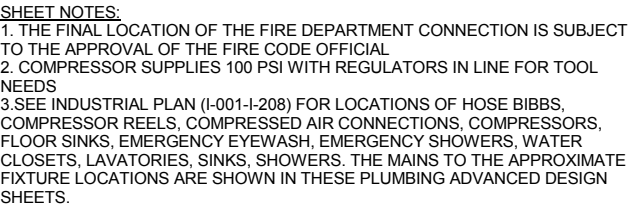


SHEET NOTES

1. THE FINAL LOCATION OF THE FIRE DEPARTMENT CONNECTION IS SUBJECT TO THE APPROVAL OF THE FIRE CODE OFFICIAL

2. COMPRESSOR SUPPLIES 100 PSI WITH REGULATORS IN LINE FOR TOOL NEEDS

 3. SEE INDUSTRIAL PLAN (I-001-I-208) FOR LOCATIONS OF HOSE BIBBS, COMPRESSOR REELS, COMPRESSED AIR CONNECTIONS, COMPRESSORS, FLOOR SINKS, EMERGENCY EYEWASH, EMERGENCY SHOWERS, WATER CLOSETS, LAVATORIES, SINKS, SHOWERS. THE MAINS TO THE APPROXIMATE FIXTURE LOCATIONS ARE SHOWN IN THESE PLUMBING ADVANCED DESIGN SHEETS.



KEY PLAN - SCALE: N.T.S.

SCALE IN FEET

[illegible]

ENGINEERING • LLC
CERTIFIED WOMEN'S
BUSINESS ENTERPRISE



SHEET
111
OF
263

DISCIPLINE:

PLUMBING



SHEET NAME:

OMF-PLM-PLN

P-110K

OPERATIONS & MAINTENANCE FACILITY -V2B PLUMBING LEVEL ONE - PARTIAL PLUMBING PLAN AREA L			SHEET 112 OF 263
DISCIPLINE:	PLUMBING	SHEET NAME:	OMF-PLM-PLN P-110L

 1 LEVEL ONE - PLUMBING PLAN - AREA M
P-110M SCALE: 1/8" = 1'-0"

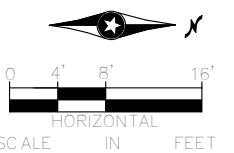[illegible]

60% SUBMISSION - 09/28/15



OPERATIONS & MAINTENANCE FACILITY -V2B
PLUMBING
LEVEL ONE - PARTIAL PLUMBING PLAN
AREA M

DISCIPLINE:


PLUMBING

SHEET NAME:



NAME: **OMF-PLM-PLN**

P-110M

SHEET
113
OF
263

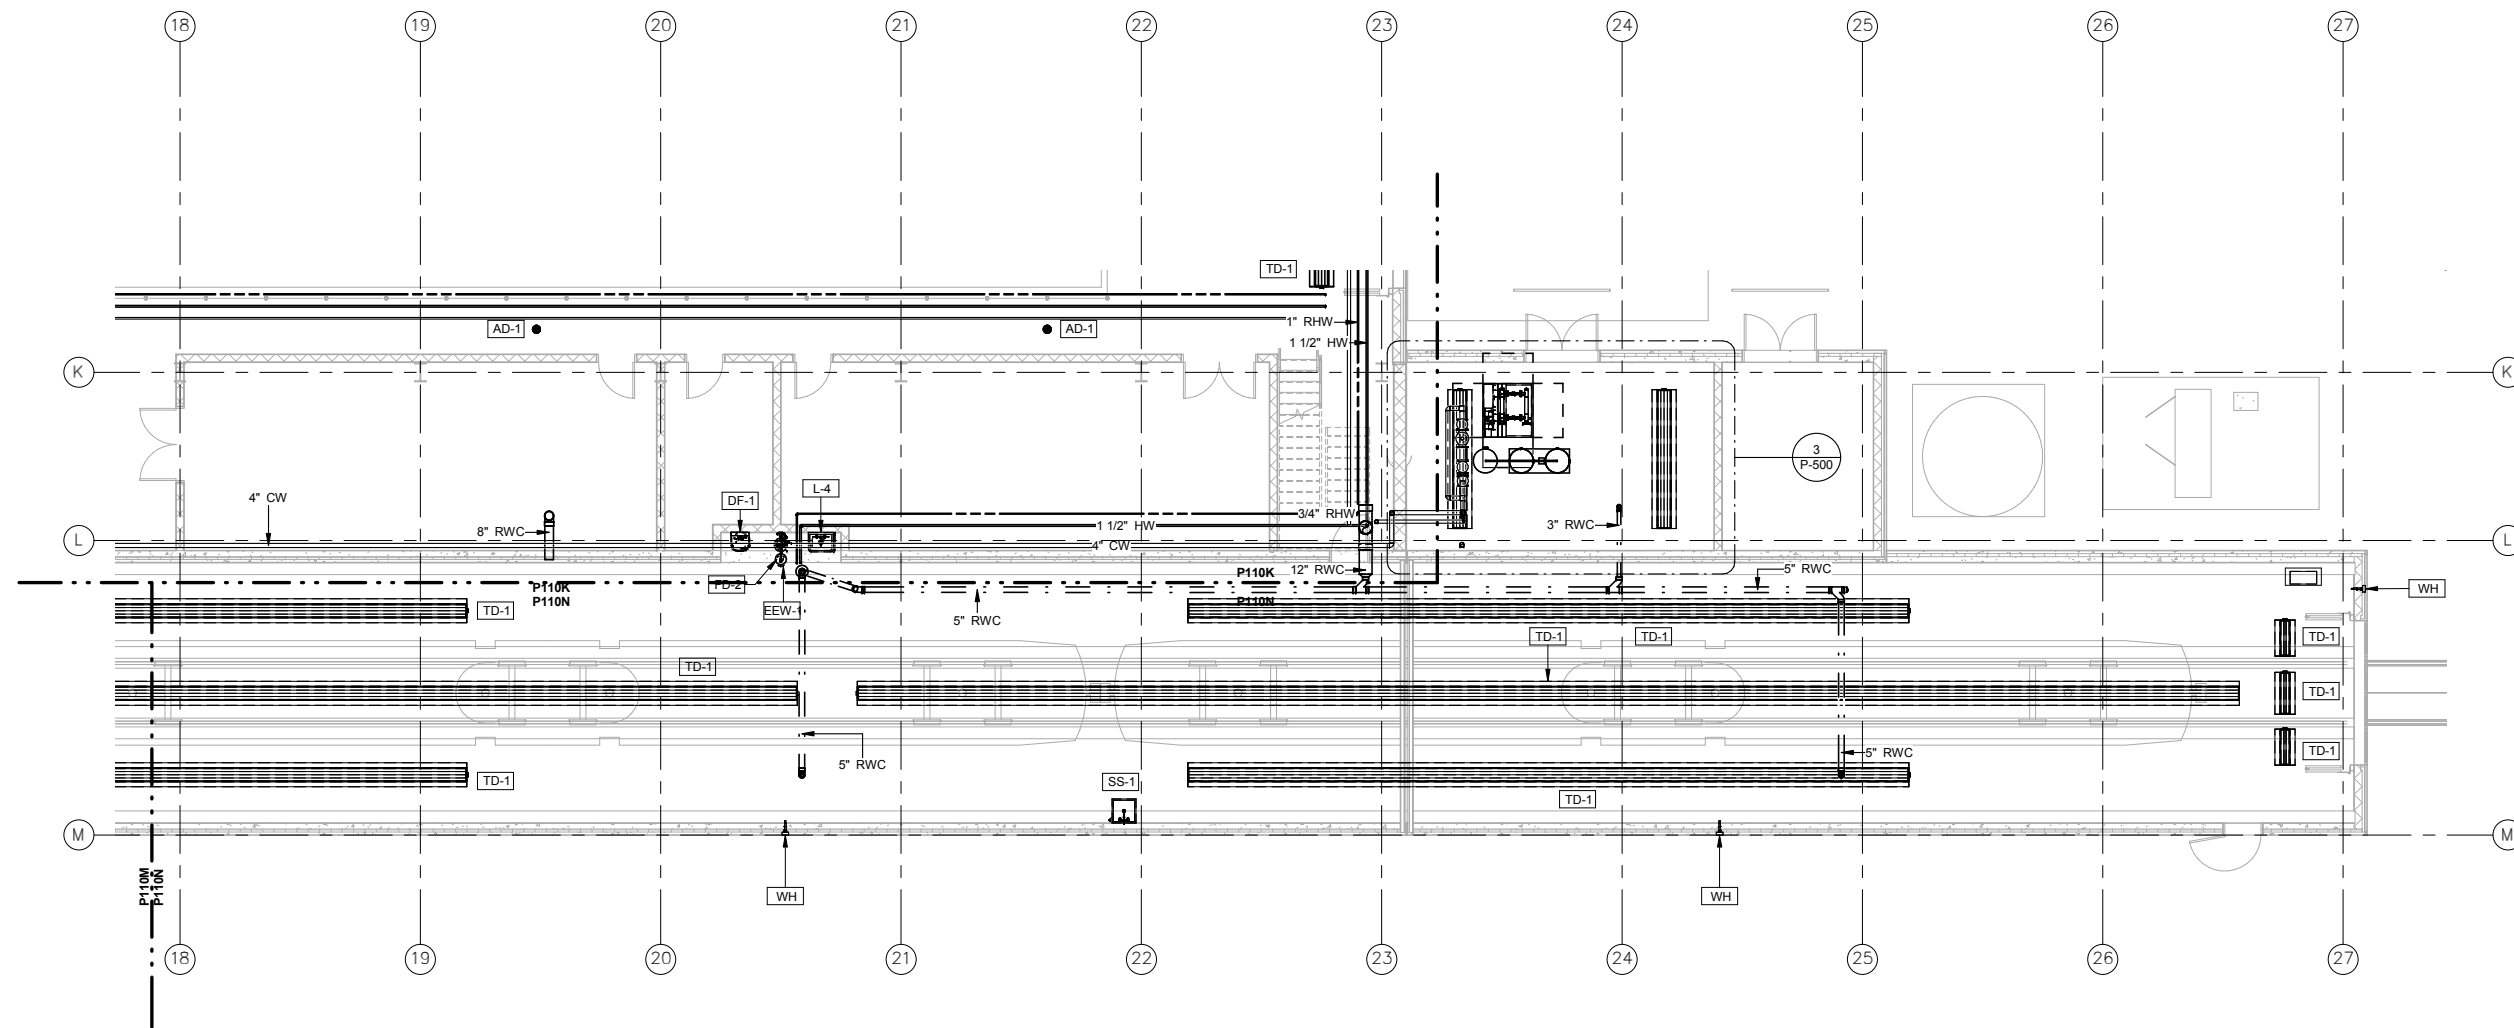

1 LEVEL ONE - PLUMBING PLAN - AREA N
P-110N SCALE: 1/8" = 1'-0"

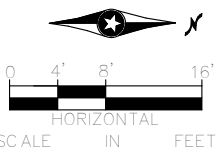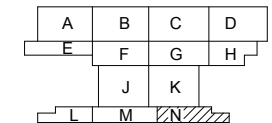[illegible]

60% SUBMISSION - 09/28/15



SOUTHWEST

**OPERATIONS & MAINTENANCE FACILITY -V2B
PLUMBING
LEVEL ONE - PARTIAL PLUMBING PLAN
AREA N**

DISCIPLINE: **PLUMBING**

SHEET NAME:	
OMF-PLM-PLN	P-110N

SHEET
114
OF
263

[illegible]

OPERATIONS & MAINTENANCE FACILITY -V2B

PLUMBING

MEZZANINE LEVEL OVERALL PLUMBING

 
FLOOR PLAN

P-115

SHEET
115
OF
263



SCALE: 1/8" = 1'-0"

[illegible]


OPERATIONS & MAINTENANCE FACILITY -V2B
PLUMBING
MEZZANINE LEVEL - PARTIAL PLUMBING
PLAN AREA E

SHEET
116
OF
263



SHEET NOTES:

1. ALL PIPING IS ROUTED HIGH (25.5') TO AVOID CRANE PATHS AND TO SERVE MEZZANINE ELEVATIONS
2. DUE TO HIGH ROUTING, PIPING CAN BE SEEN ON THIS PLAN SHEET AND SHEET P-107
3. COMPRESSOR PROVIDES 100 PSI WITH REGULATORS IN LINE TO PROVIDE TOOL NEED
4. SEE INDUSTRIAL PLAN (I-001-I-208) FOR LOCATIONS OF HOSE BIBBS, COMPRESSOR REELS, COMPRESSED AIR CONNECTIONS, COMPRESSORS, FLOOR SINKS, EMERGENCY EYE WASH, EMERGENCY SHOWERS, WATER CLOSETS, LAVATORIES, SINKS, SHOWERS. THE MAINS TO THE APPROXIMATE FIXTURE LOCATIONS ARE SHOWN IN THESE PLUMBING ADVANCED DESIGN SHEETS.

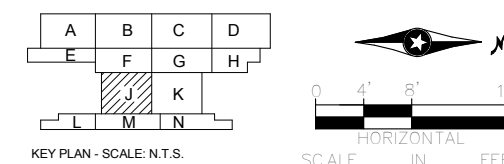

1 MEZZANINE LEVEL - PLUMBING PLAN - AREA J
P-115J SCALE: 1/8" = 1'-0"

[illegible]

AECOM **ENGINEERING • LLC**
CERTIFIED WOMEN'S
BUSINESS ENTERPRISE

60% SUBMISSION - 09/28/15




**OPERATIONS & MAINTENANCE FACILITY -V2B
PLUMBING
MEZZANINE LEVEL - PARTIAL PLUMBING
PLAN AREA J**

DISCIPLINE: **PLUMBING**

SHEET NAME:	OMF-PLM-PLN	P-115J
-------------	-------------	--------

SHEET
117
OF
263

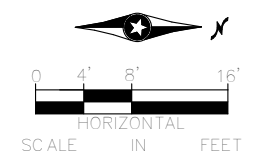[illegible]

60% SUBMISSION - 09/28/15

OPERATIONS & MAINTENANCE FACILITY -V2B
PLUMBING
MEZZANINE LEVEL - PARTIAL PLUMBING
PLAN AREA K

DISCIPLINE:

PLUMBING


SHEET NAME:

NAME: **OMF-PLM-PLN**


P-115K

SHEET
118
OF
263


KEYED NOTES

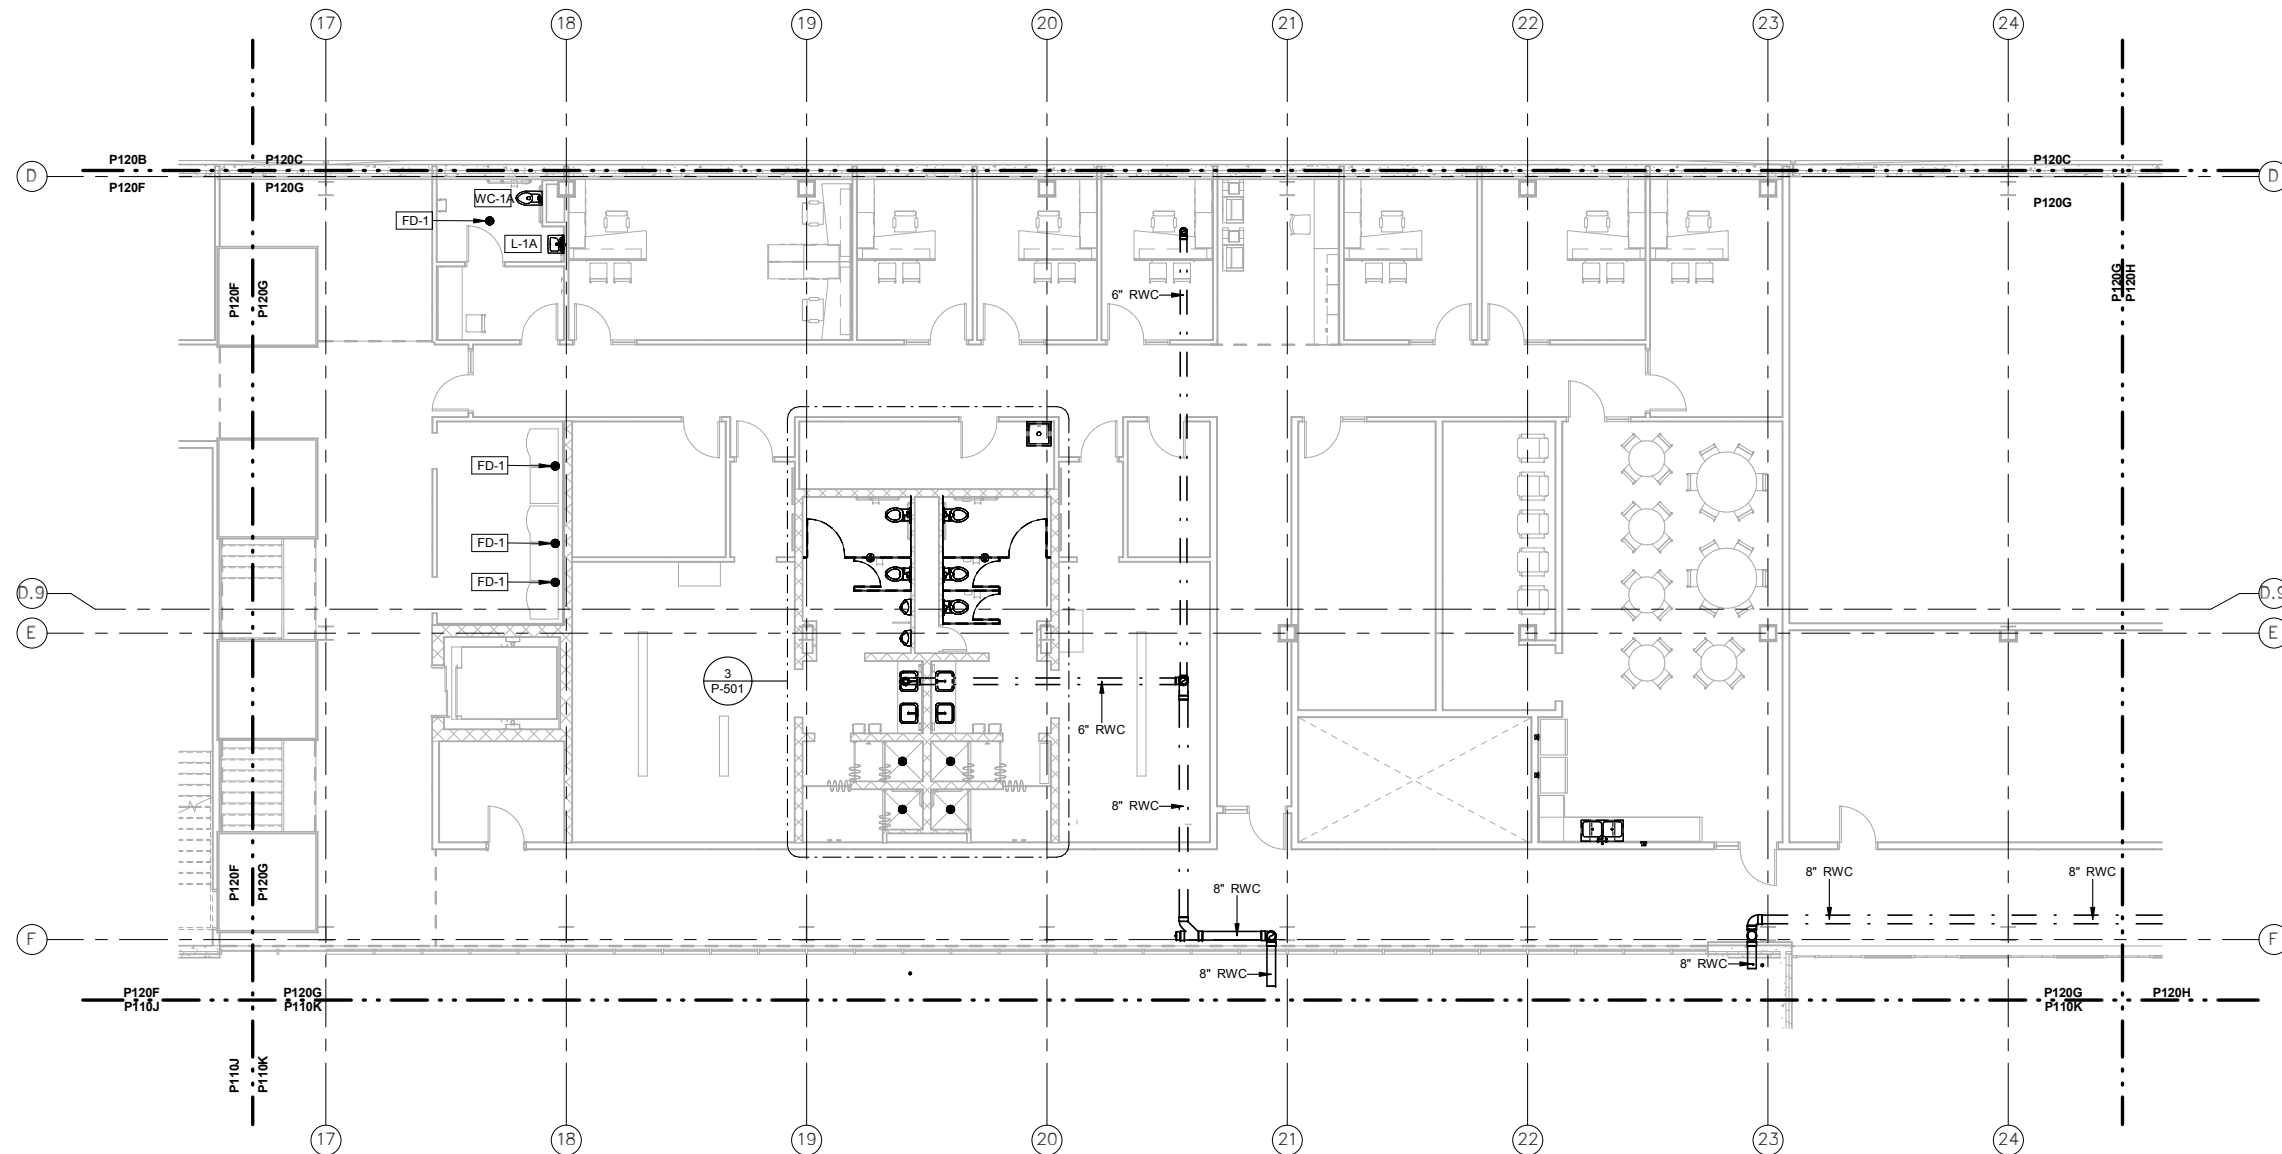

1 LEVEL TWO - PLUMBING PLAN - AREA G
P-120G SCALE: 1/8" = 1'-0"

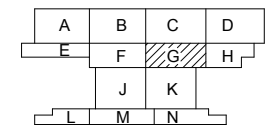

KEY PLAN - SCALE: N.T.S.

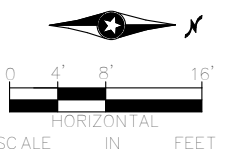[illegible]

LV
ENGINEERING • LLC
CERTIFIED WOMEN'S
BUSINESS ENTERPRISE



SOUTHWEST

60% SUBMISSION - 09/28/15

OPERATIONS & MAINTENANCE FACILITY -V2B
PLUMBING
LEVEL TWO - PARTIAL PLUMBING PLAN
AREA G

DISCIPLINE:


PLUMBING

SHEET NAME:


NAME: **OMF-PLM-PLN**

P-120G

122
OF
263

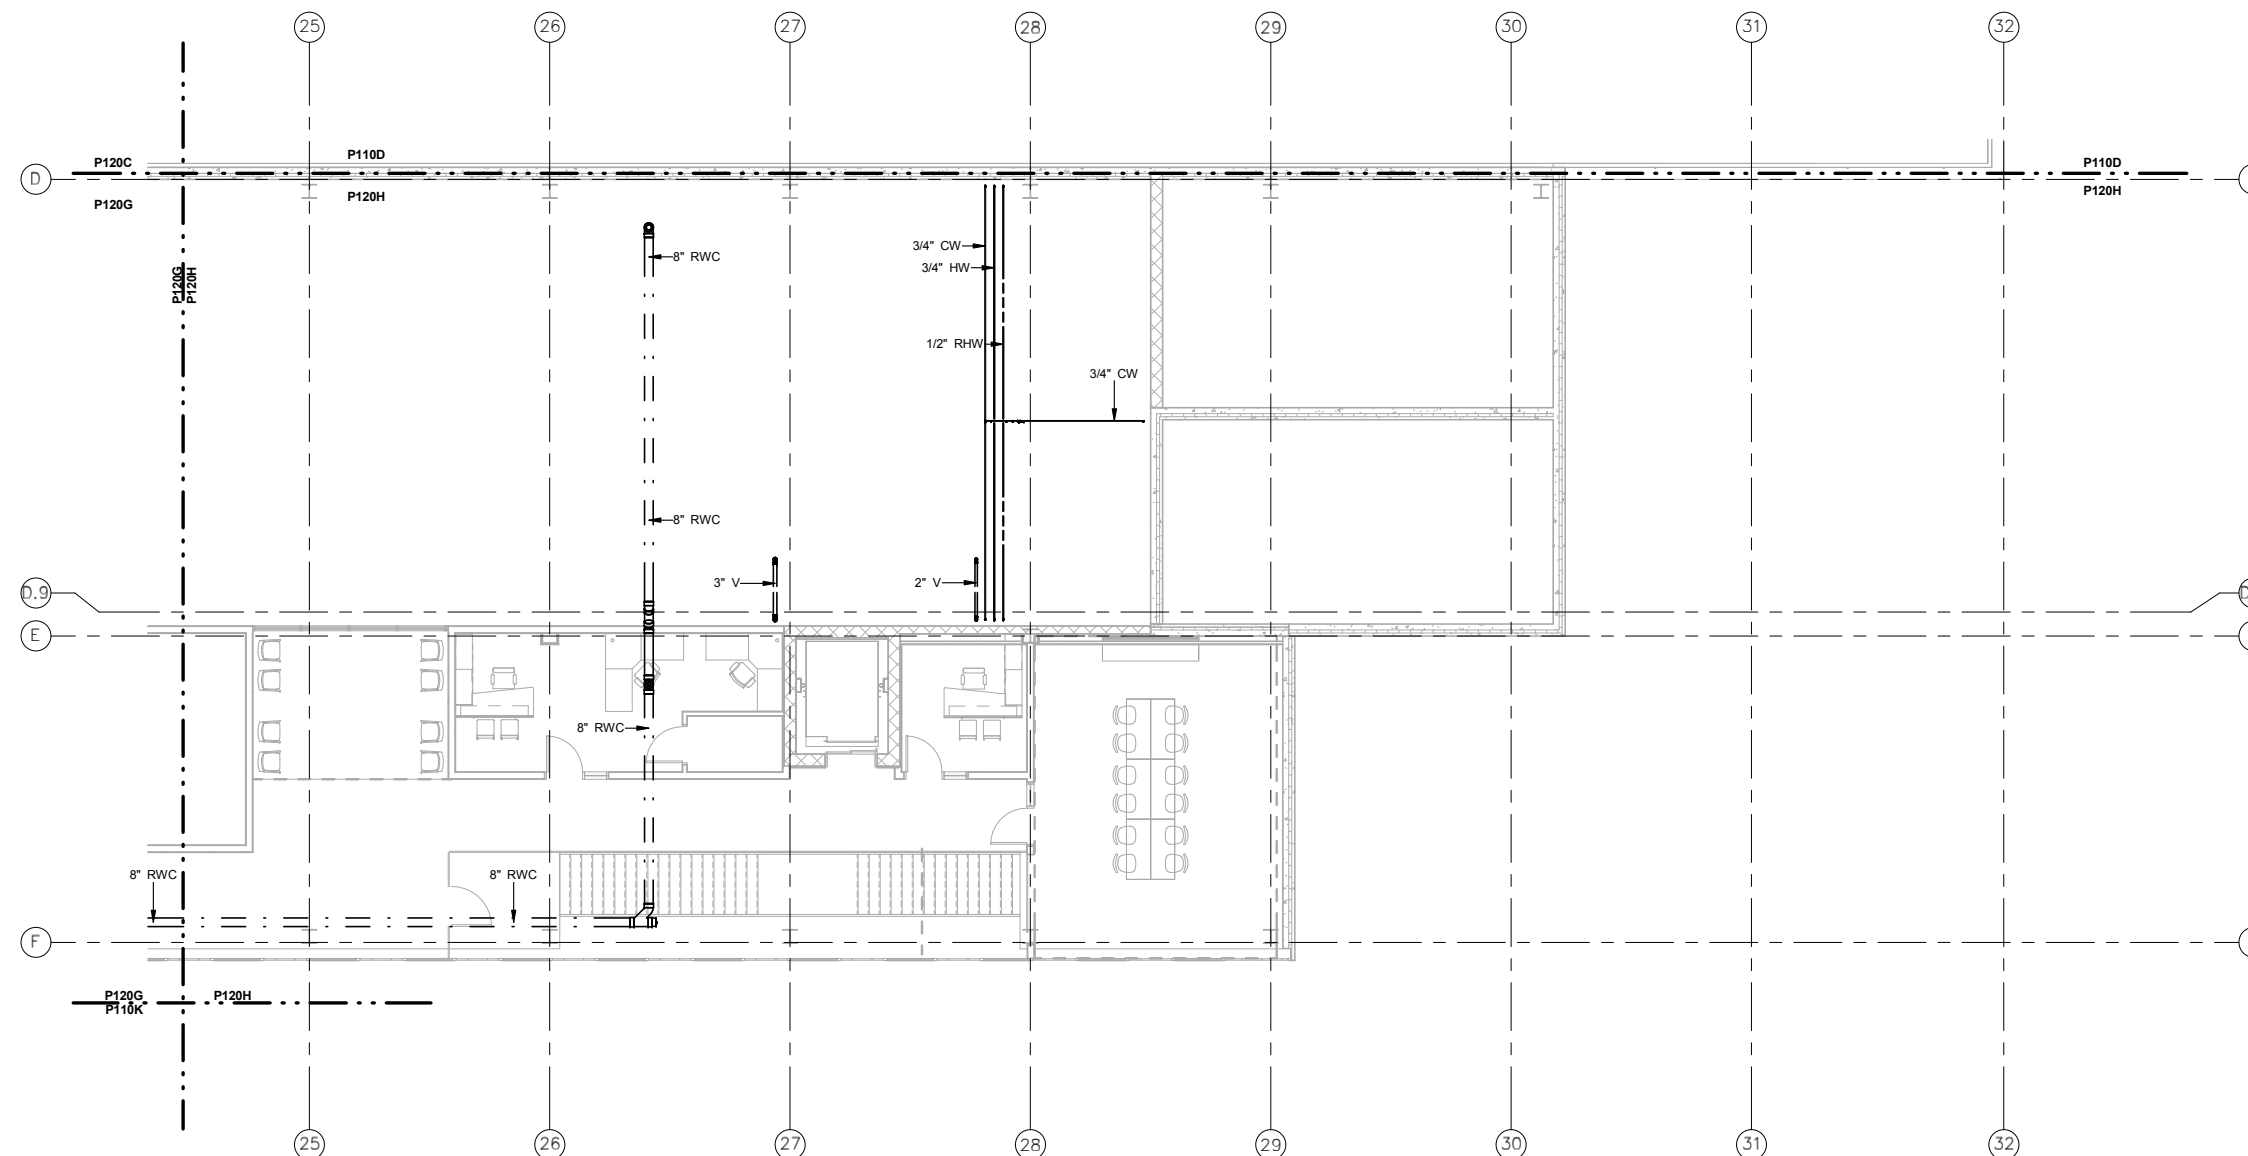

1 LEVEL TWO PLUMBING PLAN - AREA H
P-120H SCALE: 1/8" = 1'-0"

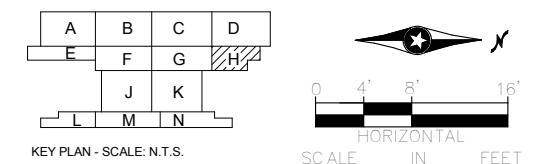[illegible]

60% SUBMISSION - 09/28/15


OPERATIONS & MAINTENANCE FACILITY -V2B
PLUMBING
LEVEL TWO - PARTIAL PLUMBING PLAN
AREA H

DISCIPLINE: **PLUMBING**

SHEET NAME:		OMF-PLM-PLN	P-120H
-------------	--	-------------	--------


SHEET
123
OF
263

9/21/2015 12:07:25 PM C:\Users\lisa\Documents\OMF_Plumb_lisa.rvt

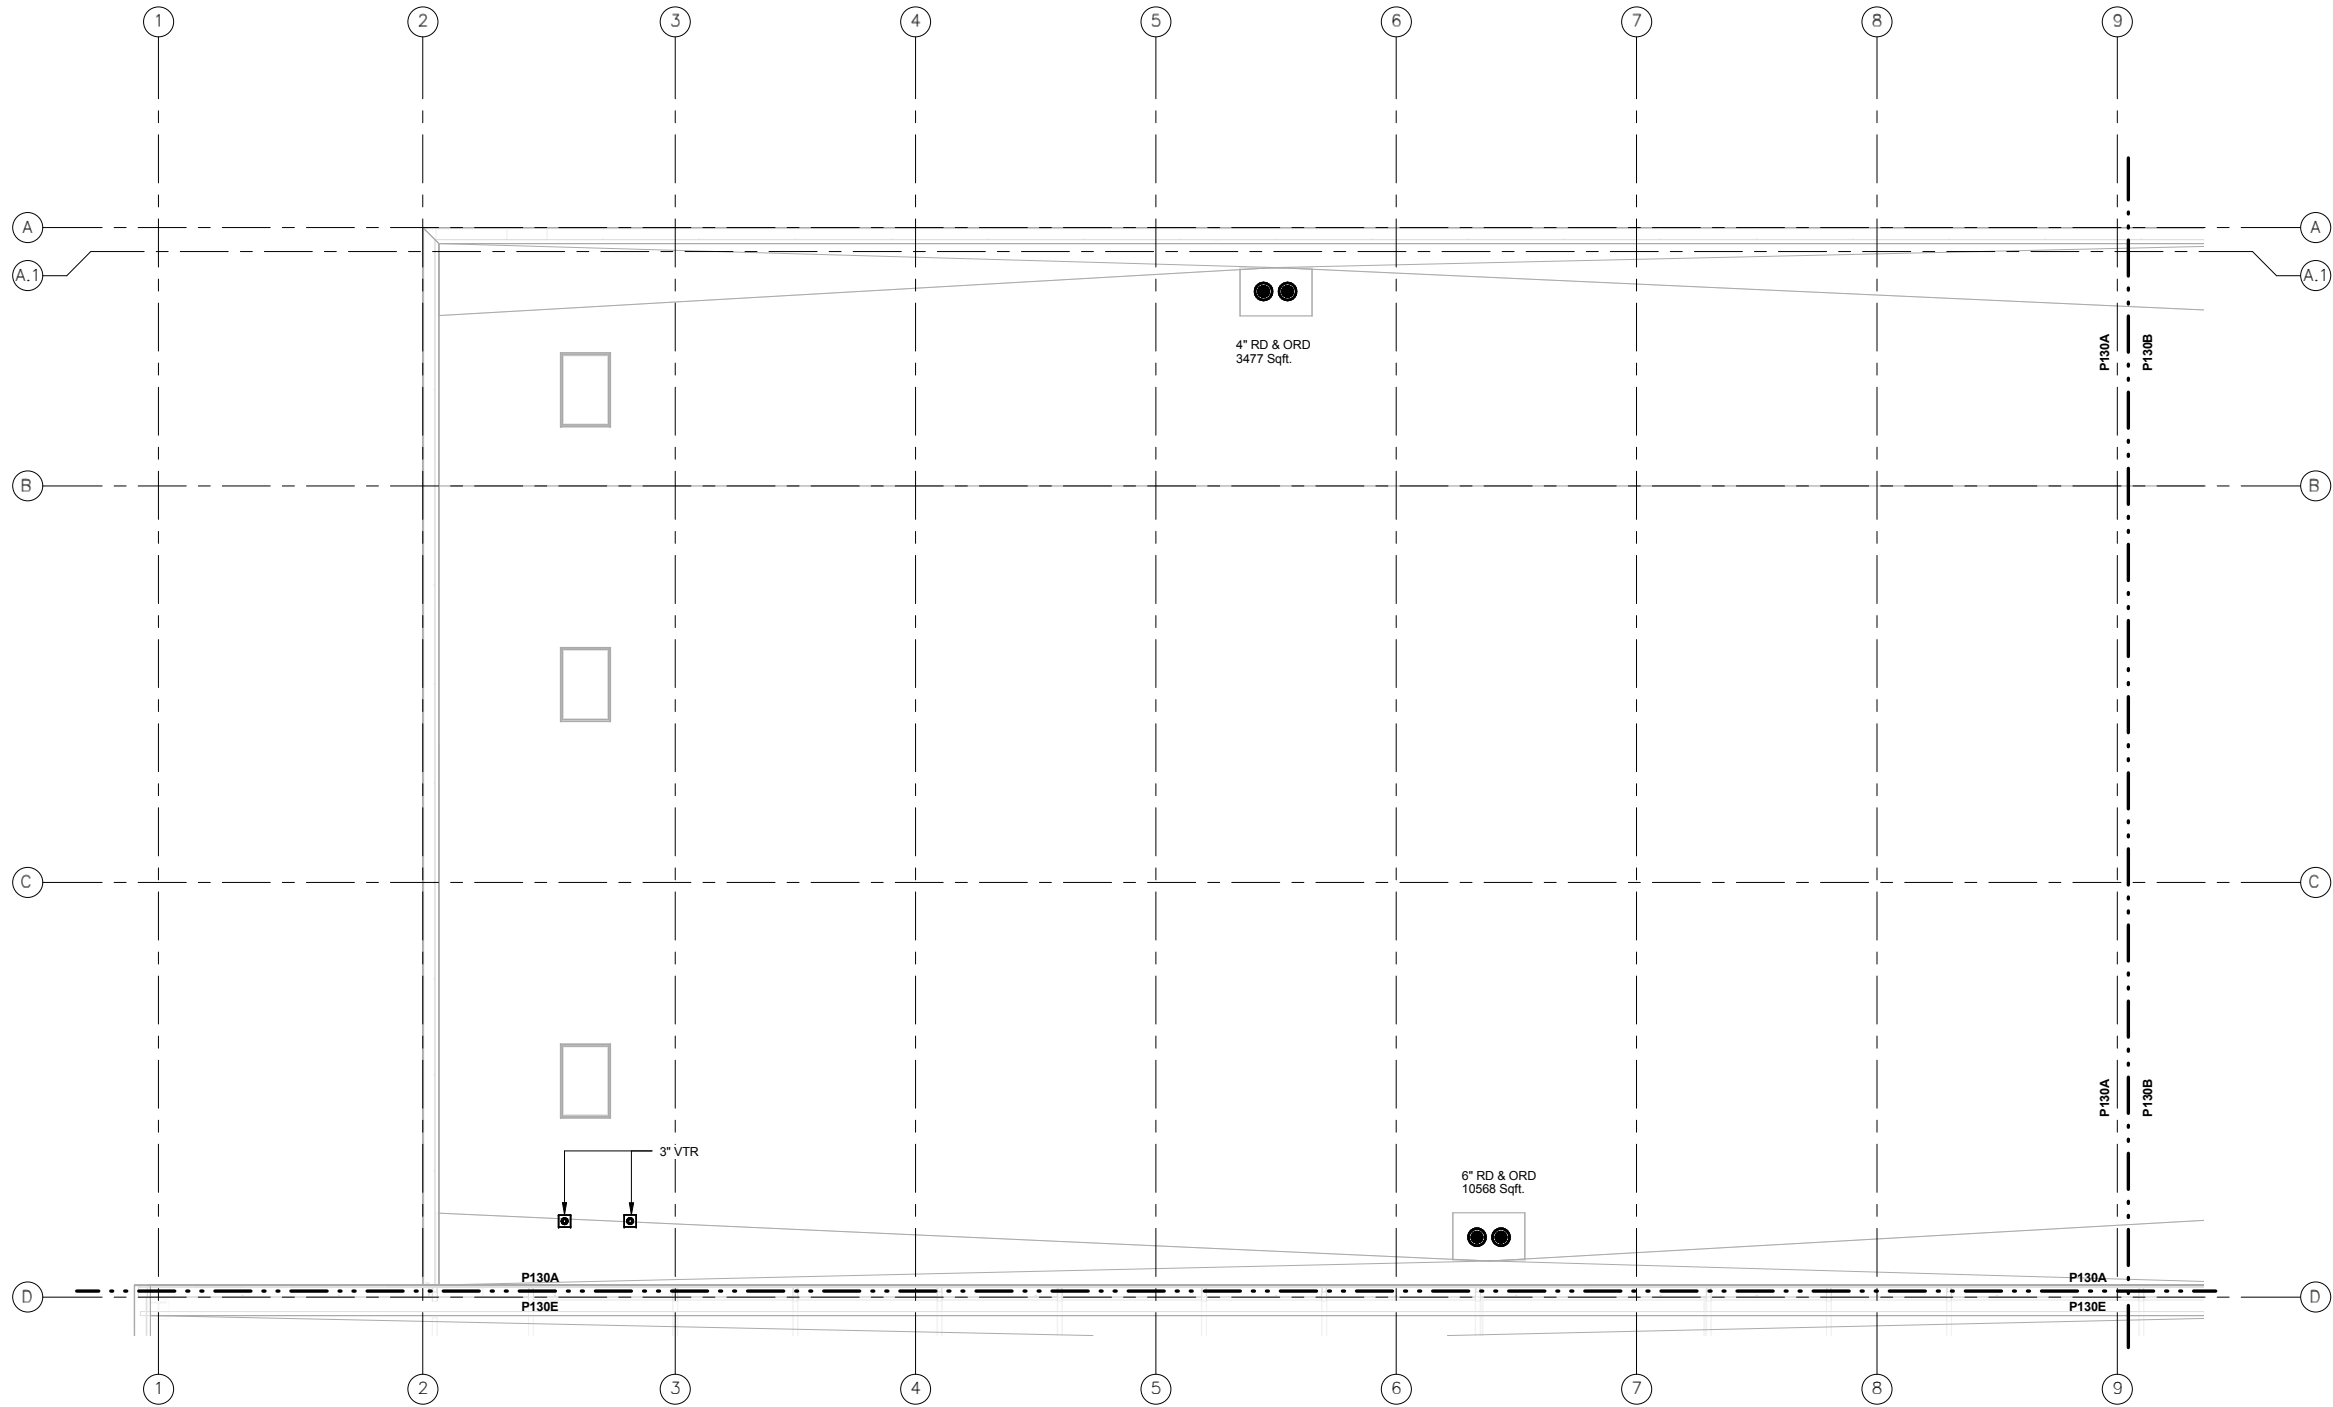


KEYED NOTES

1 ROOF LEVEL - PARTIAL PLUMBING PLAN - AREA A
P-130A SCALE: 1/8" = 1'-0"

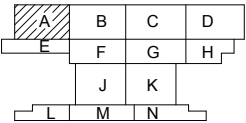

KEY PLAN - SCALE: N.T.S.

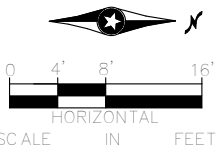

NO	DATE	BY	CHECK	DESIGN	REVISION / SUBMITTAL



60% SUBMISSION - 09/28/15



OPERATIONS & MAINTENANCE FACILITY -V2B
PLUMBING
ROOF LEVEL - PARTIAL PLUMBING PLAN
AREA A


DISCIPLINE:
PLUMBING

SHEET NAME:
OMF-PLM-PLN


P-130A

SHEET
125
OF
263


KEYED NOTES

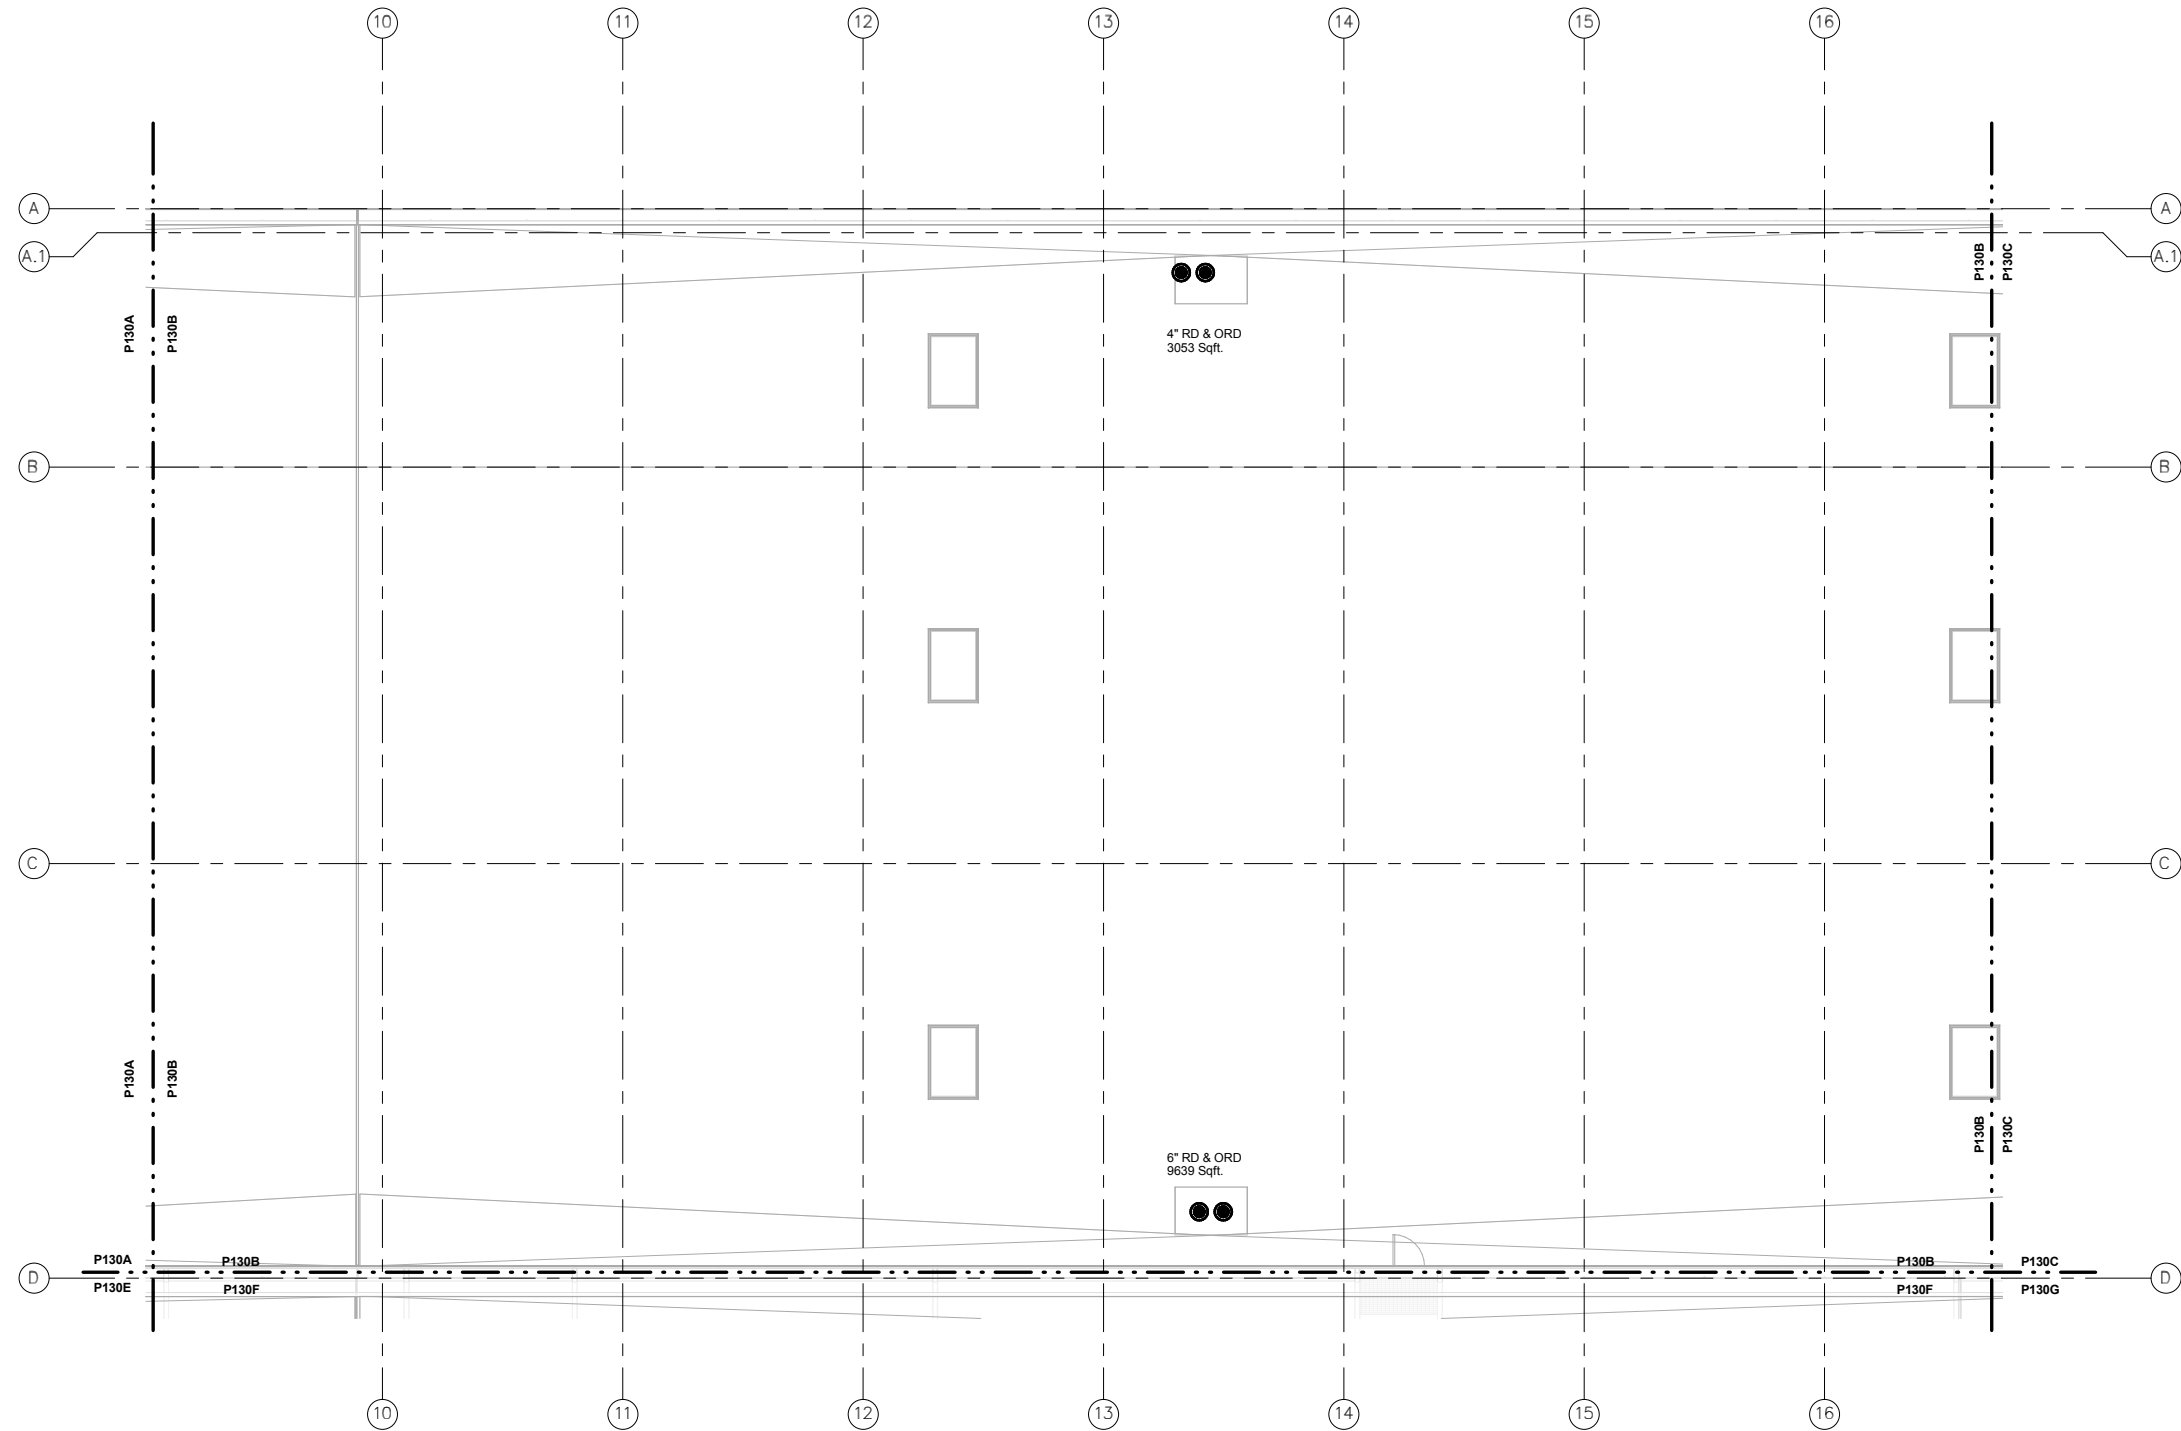

1 ROOF LEVEL - PARTIAL PLUMBING PLAN - AREA B
P-130B SCALE: 1/8" = 1'-0"

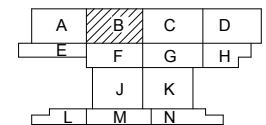

KEY PLAN - SCALE: N.T.S.

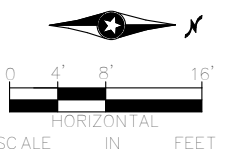[illegible]

60% SUBMISSION - 09/28/15



OPERATIONS & MAINTENANCE FACILITY -V2B
PLUMBING
ROOF LEVEL - PARTIAL PLUMBING PLAN
AREA B

DISCIPLINE:

PLUMBING

SHEET NAME:


OMF-PLM-PLN

P-130B


SHEET
126
OF
263

9/21/2015 12:07:27 PM C:\Users\lisa\Documents\OMF_Plumb_lisa.rvt


KEYED NOTES

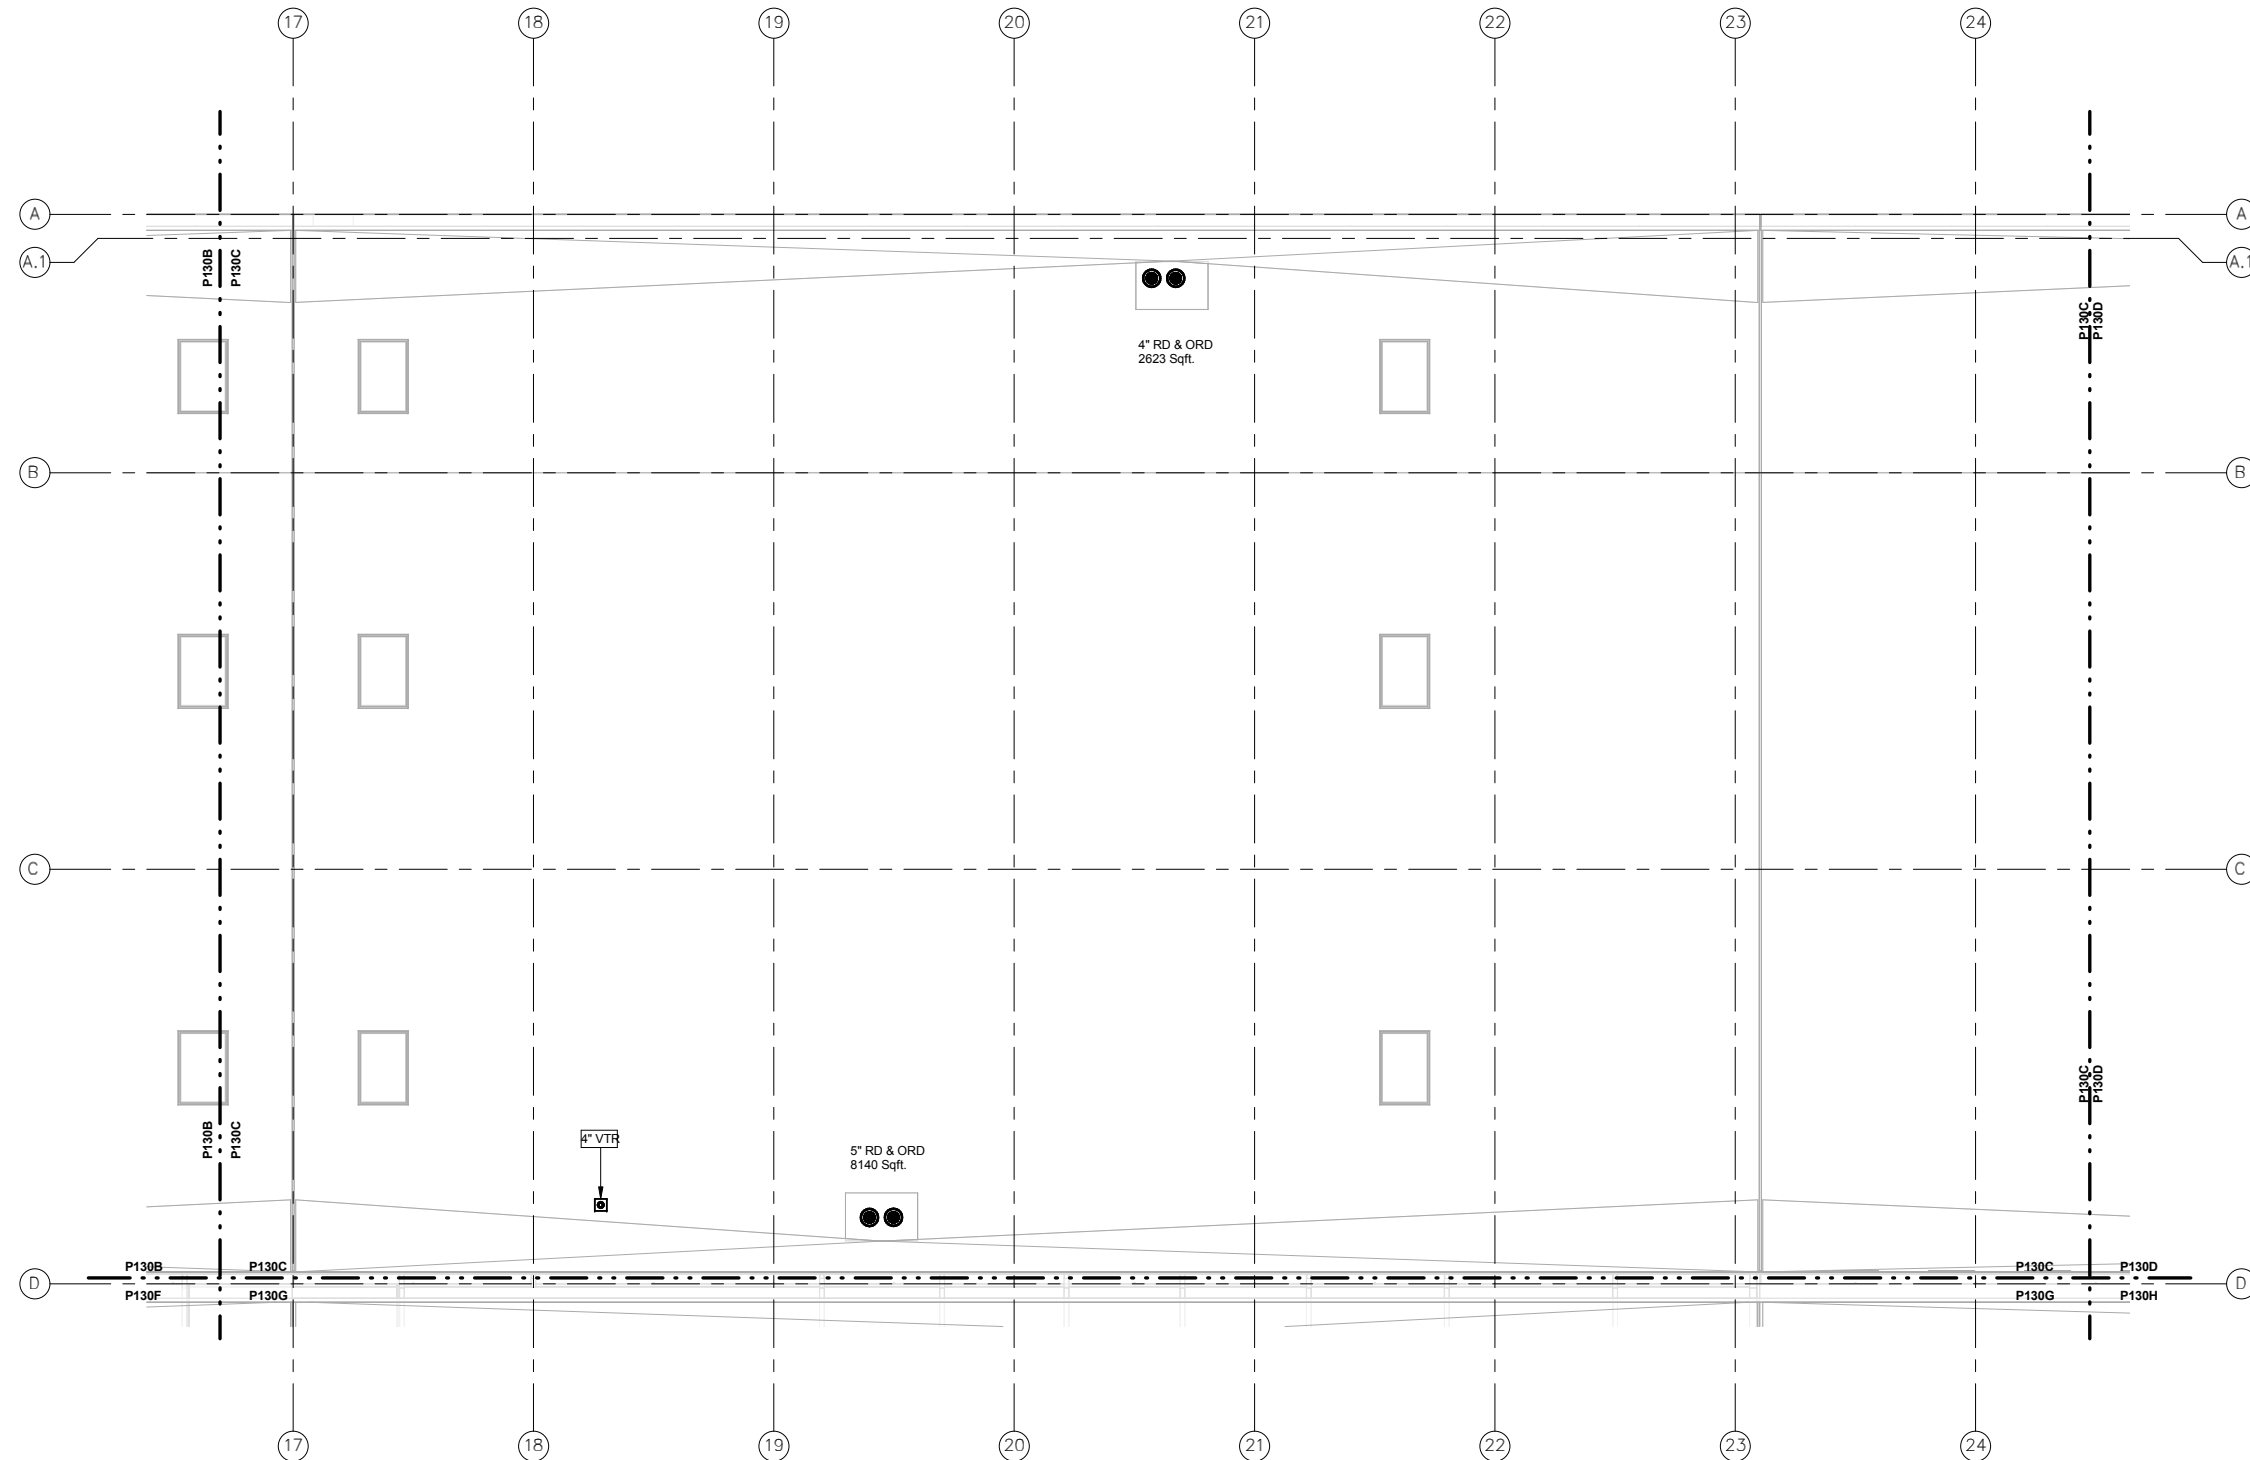

1 ROOF LEVEL - PARTIAL PLUMBING PLAN - AREA C
P-130C SCALE: 1/8" = 1'-0"

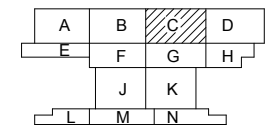

KEY PLAN - SCALE: N.T.S.

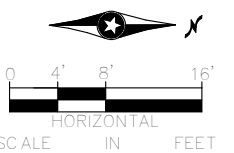[illegible]

60% SUBMISSION - 09/28/15



OPERATIONS & MAINTENANCE FACILITY -V2B
PLUMBING
ROOF LEVEL - PARTIAL PLUMBING PLAN
AREA C

DISCIPLINE:

PLUMBING


SHEET NAME:

OMF-PLM-PLN


P-130C

SHEET
127
OF
263

KEYED NOTES

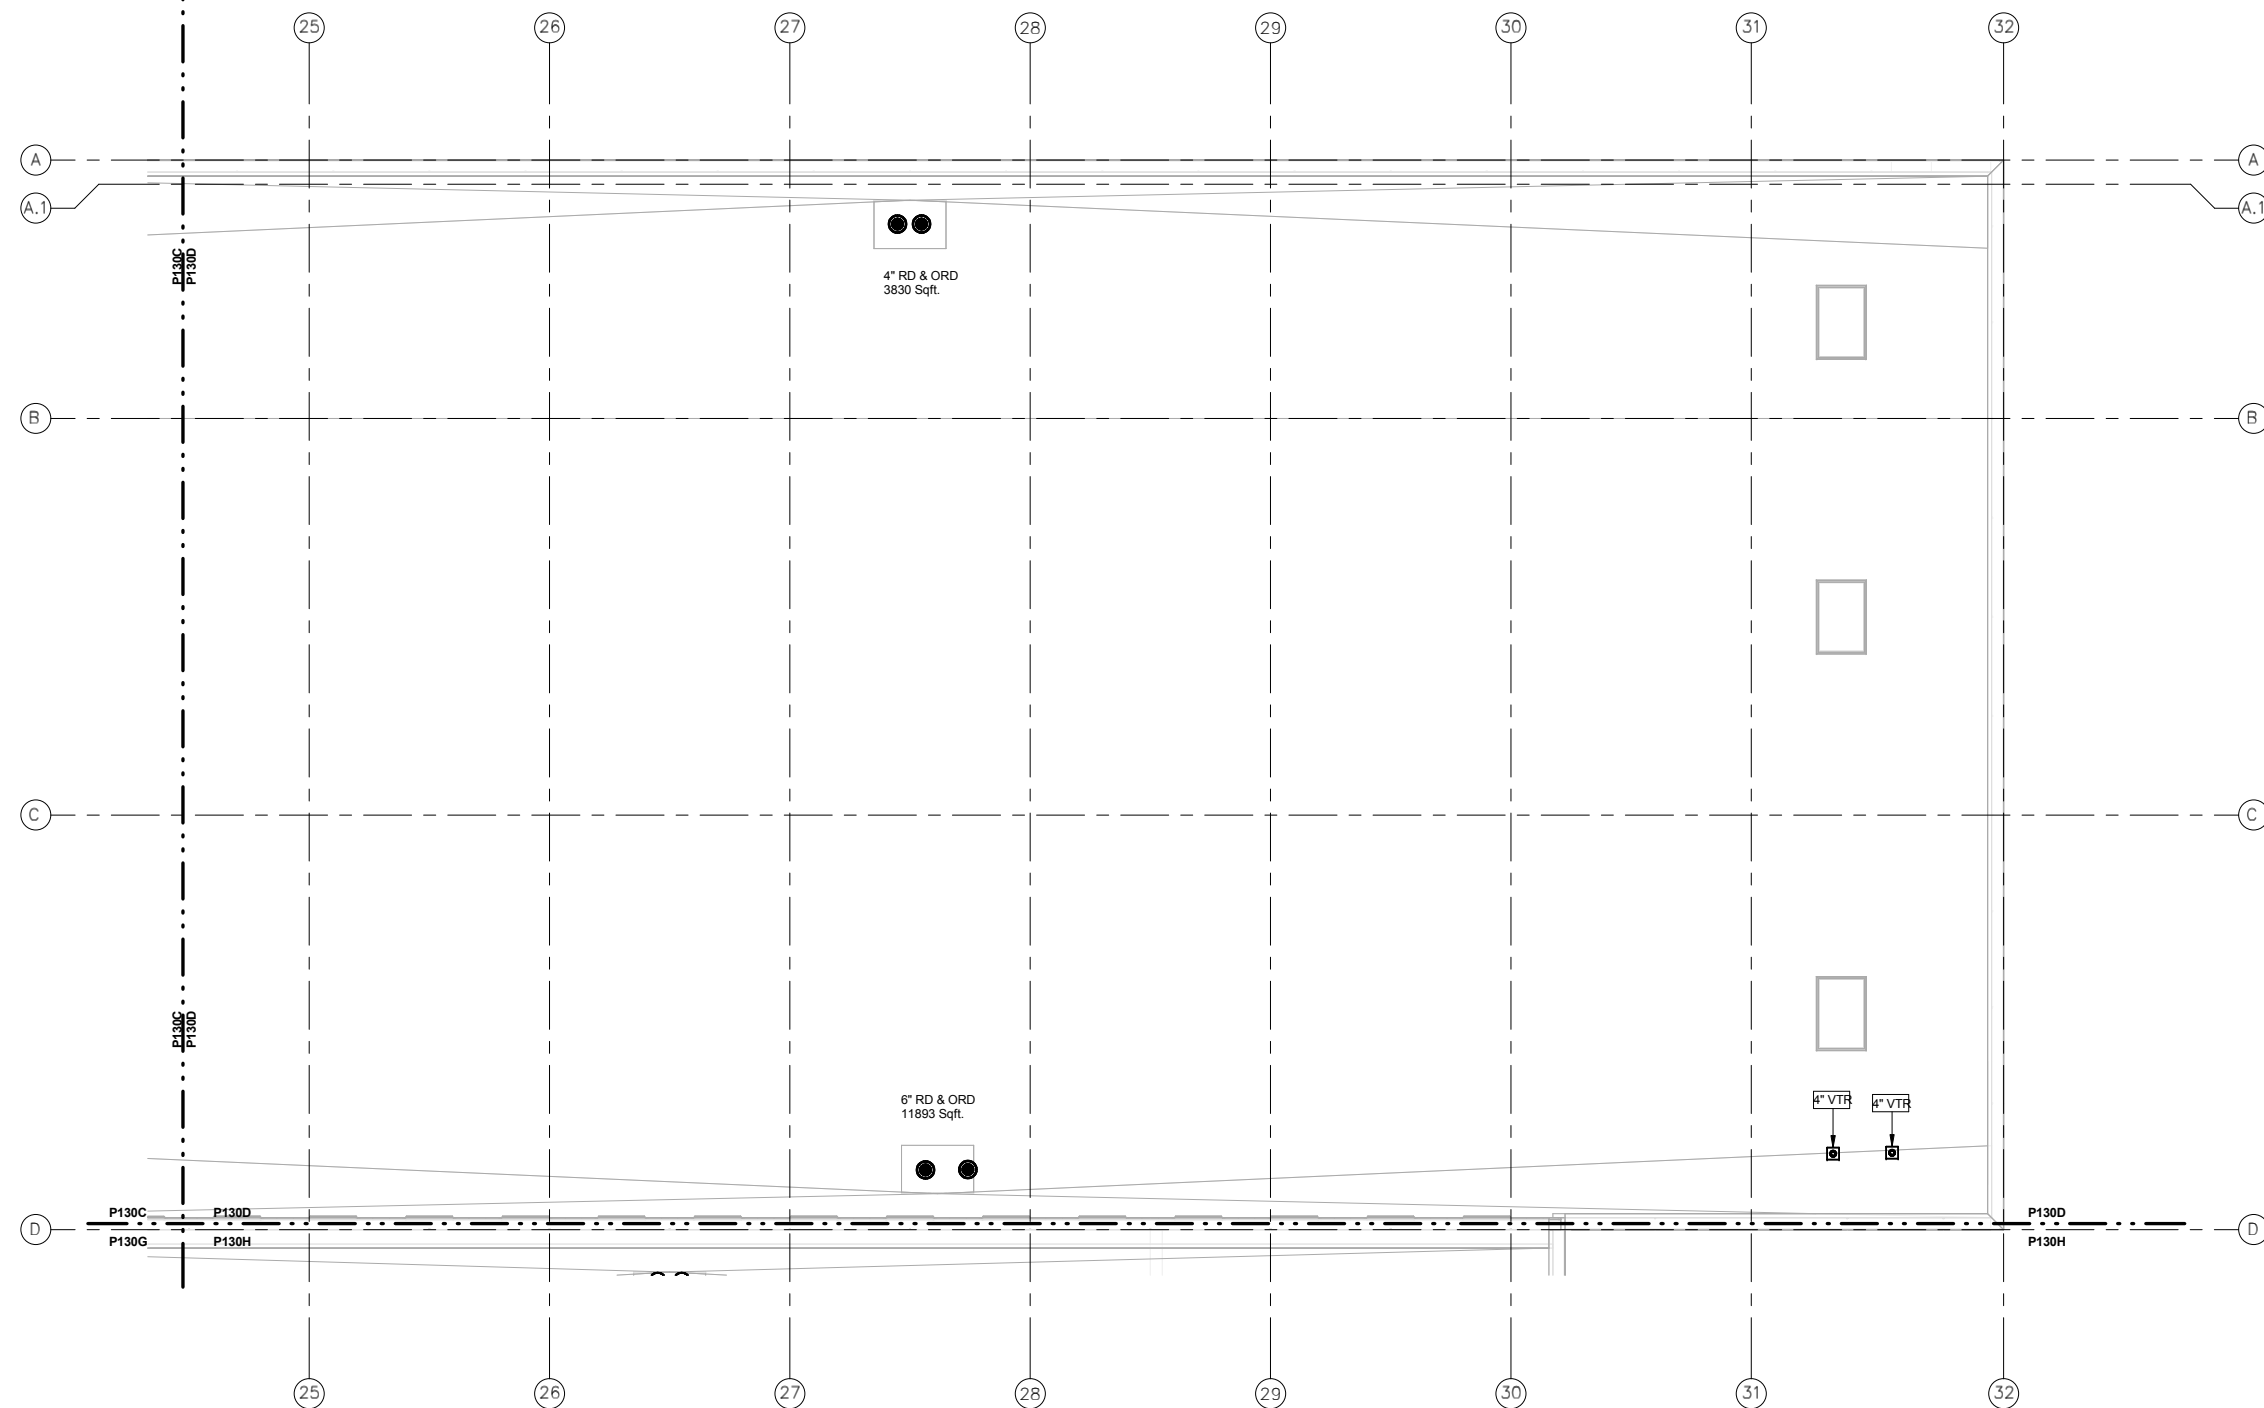

1 ROOF LEVEL - PARTIAL PLUMBING PLAN - AREA D
P-130D SCALE: 1/8" = 1'-0"

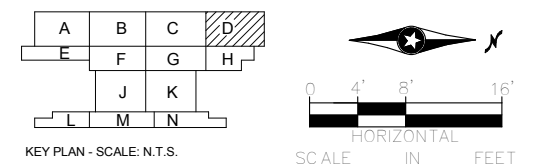[illegible]

60% SUBMISSION - 09/28/15




OPERATIONS & MAINTENANCE FACILITY -V2B
PLUMBING
ROOF LEVEL - PARTIAL PLUMBING PLAN
AREA D

DISCIPLINE:	SHEET NAME:	
PLUMBING	OMF-PLM-PLN	P-130D


SHEET
128
OF
263

9/21/2015 12:07:31 PM C:\Users\lisa\Documents\OMF_Plumb_lisa.vrt

KEYED NOTES

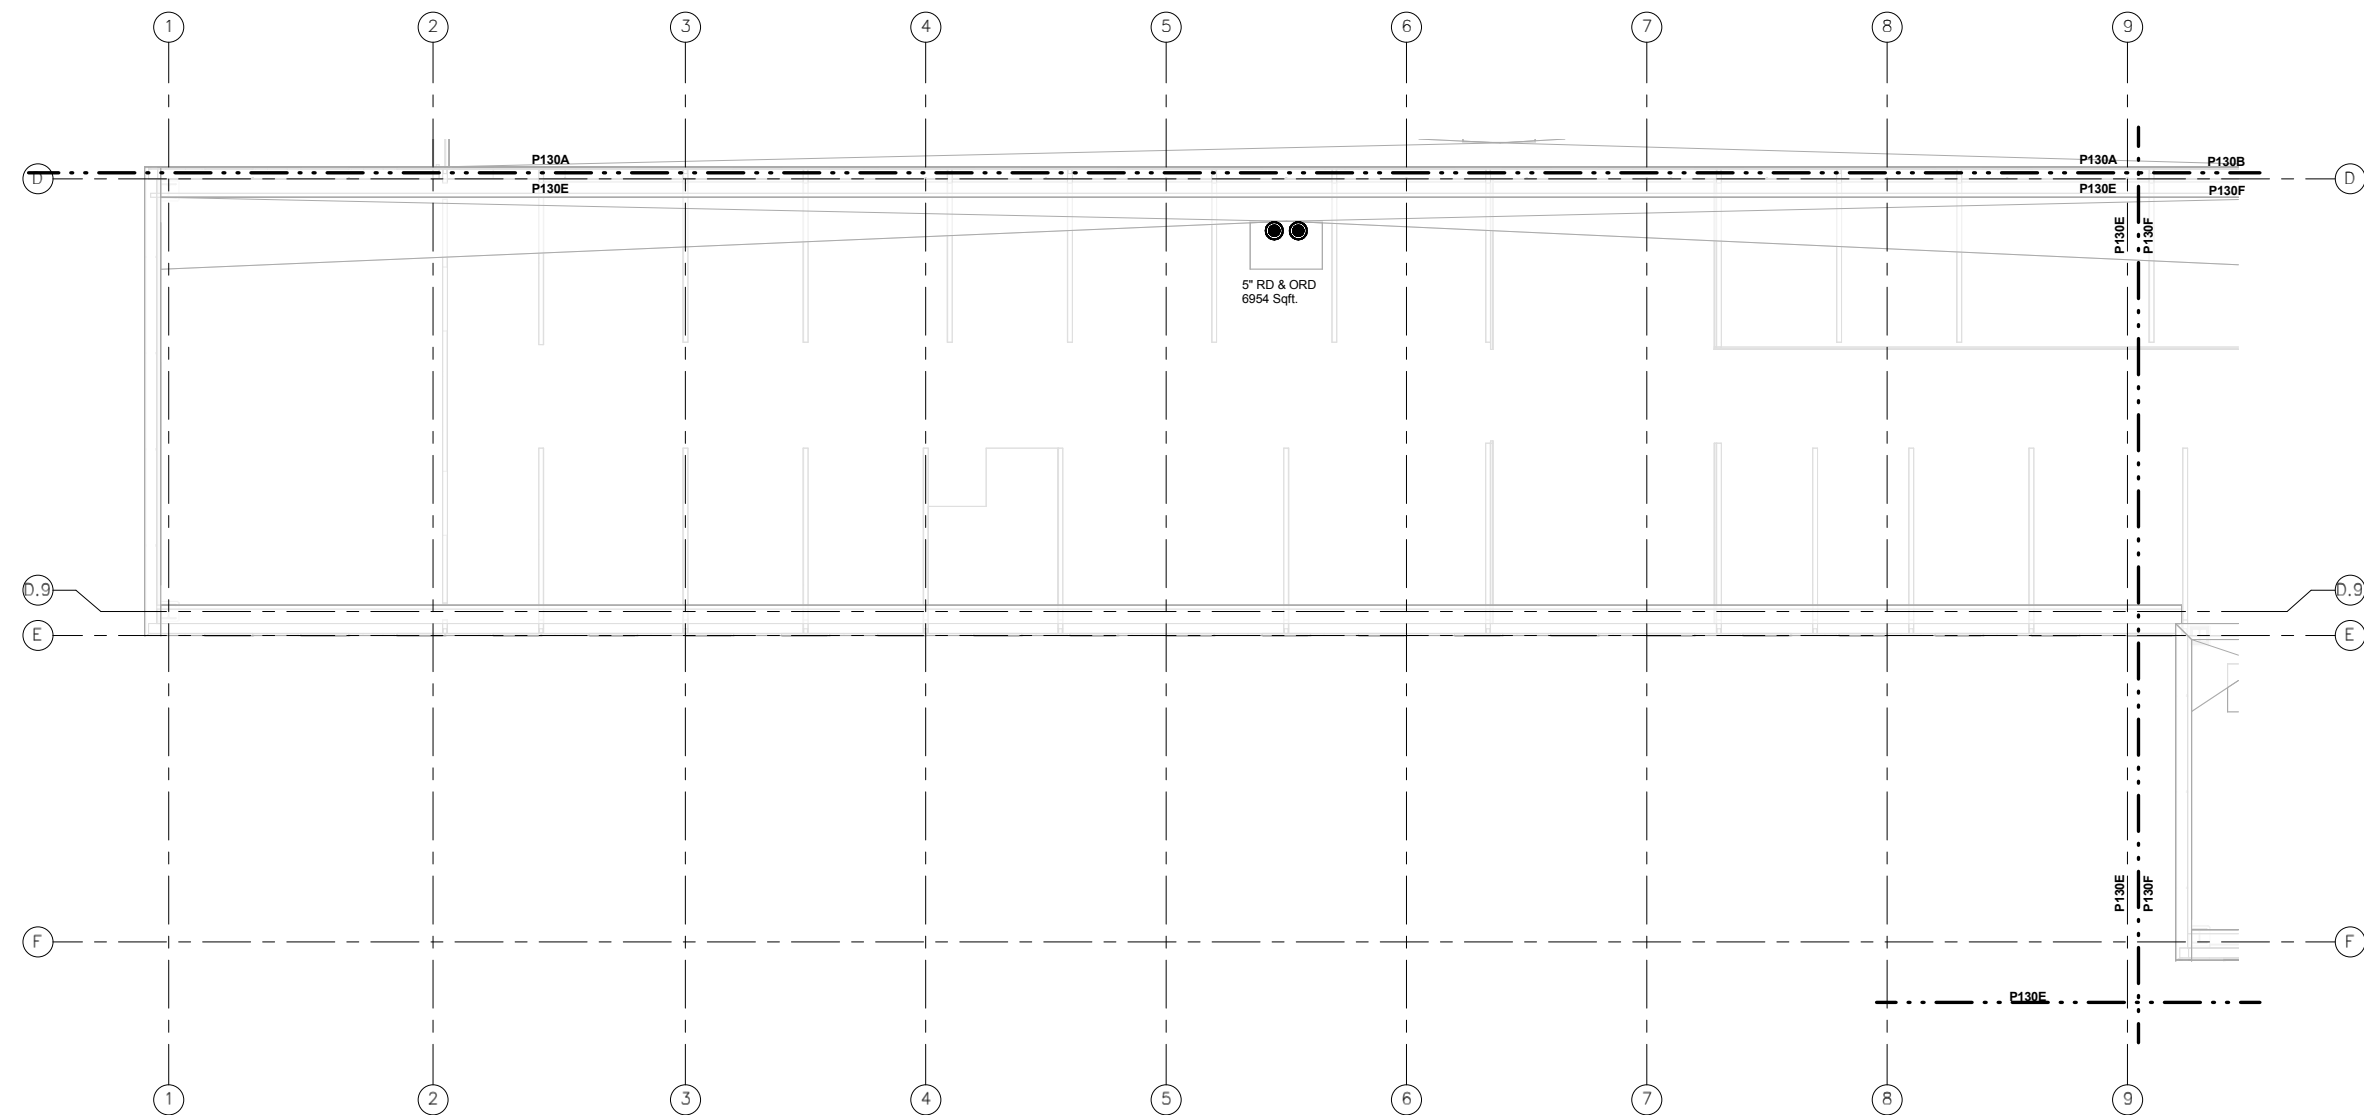

1 ROOF LEVEL - PLUMBING PLAN - AREA E
P-130E SCALE: 1/8" = 1'-0"

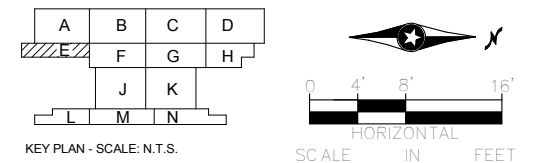[illegible]

60% SUBMISSION - 09/28/15




OPERATIONS & MAINTENANCE FACILITY -V2B
PLUMBING
ROOF LEVEL - PARTIAL PLUMBING PLAN
AREA E


DISCIPLINE:	SHEET NAME:	
PLUMBING	OMF-PLM-PLN	P-130E

SHEET
129
OF
263


KEYED NOTES

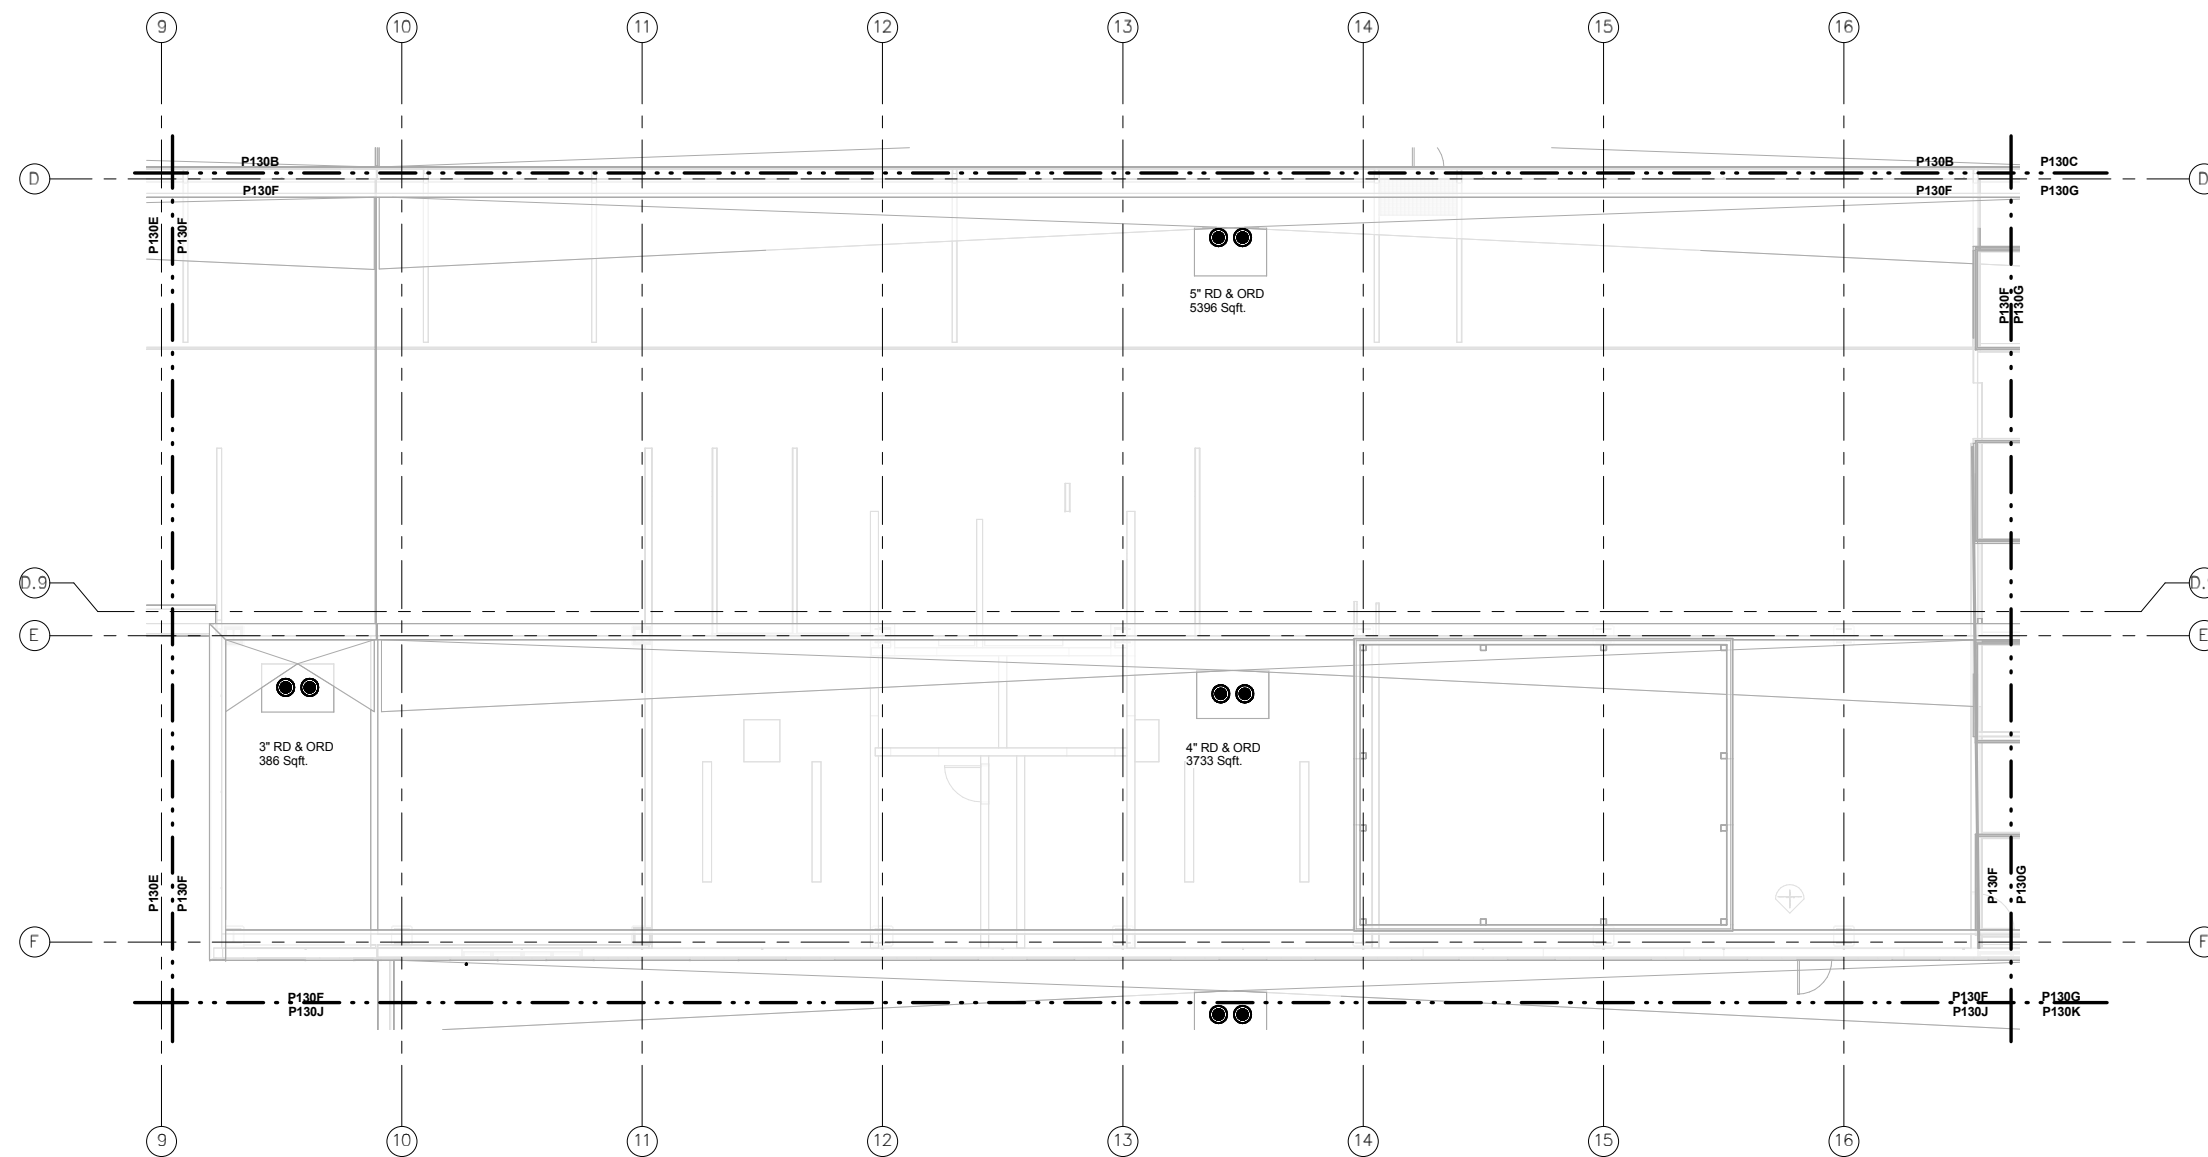

1 ROOF LEVEL - PLUMBING PLAN - AREA F
P-130F SCALE: 1/8" = 1'-0"

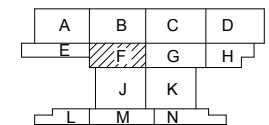

KEY PLAN - SCALE: N.T.S.

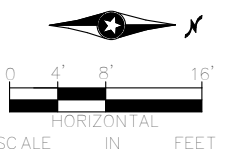[illegible]




60% SUBMISSION - 09/28/15



OPERATIONS & MAINTENANCE FACILITY -V2B
PLUMBING
ROOF LEVEL - PARTIAL PLUMBING PLAN
AREA F

DISCIPLINE:

PLUMBING


SHEET NAME:

NAME: **OMF-PLM-PLN**


P-130F

SHEET
130
OF
263

KEYED NOTES

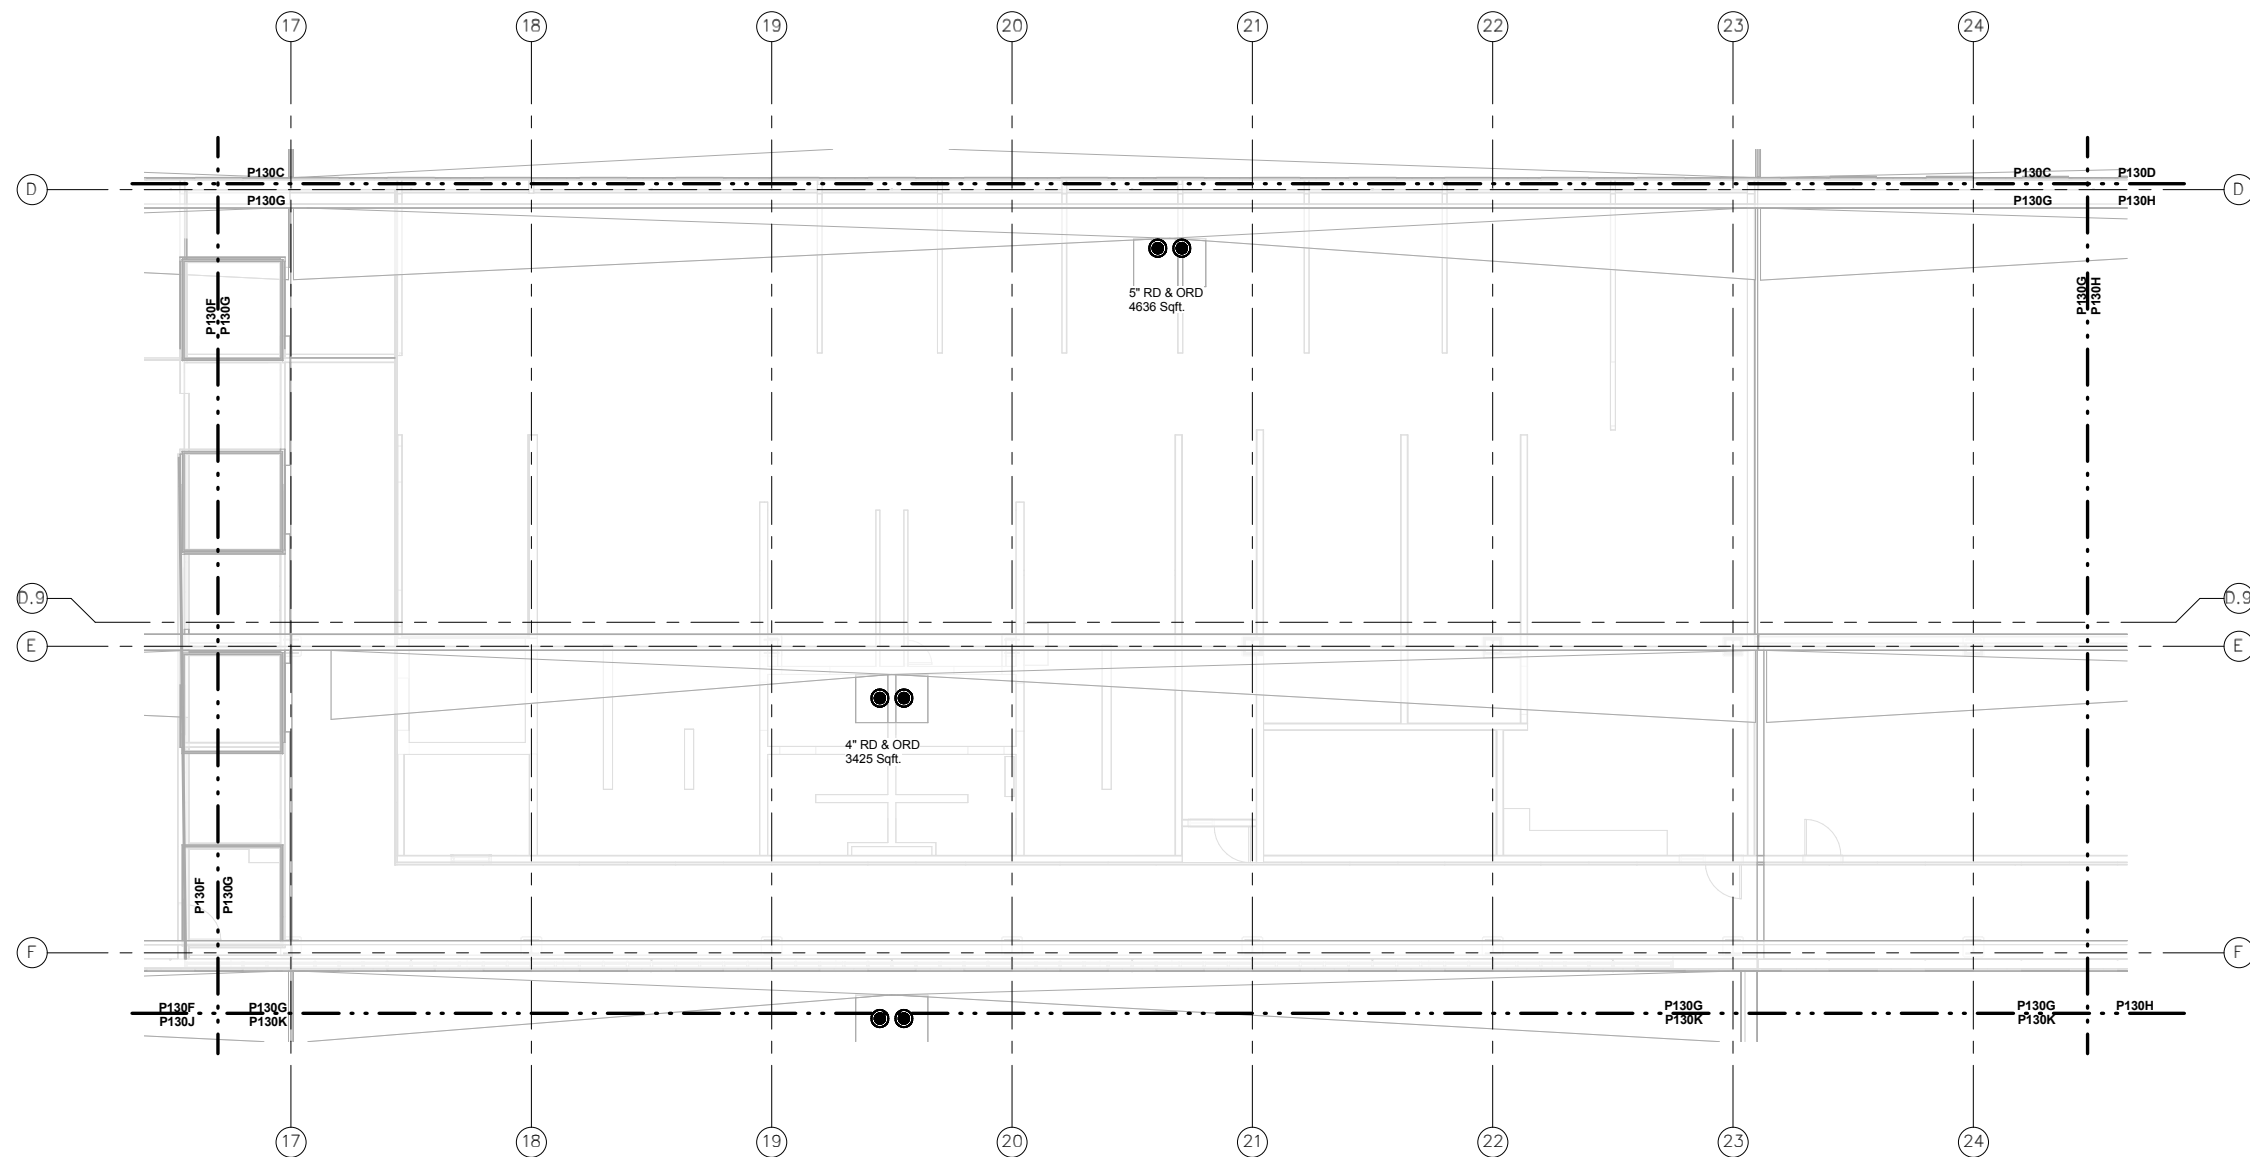

1 ROOF LEVEL - PLUMBING PLAN - AREA G
P-130G SCALE: 1/8" = 1'-0"

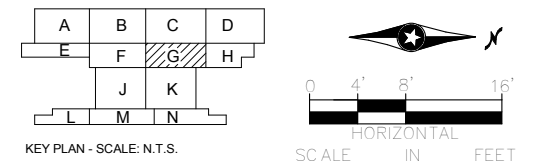[illegible]

60% SUBMISSION - 09/28/15




OPERATIONS & MAINTENANCE FACILITY -V2B
PLUMBING
ROOF LEVEL - PARTIAL PLUMBING PLAN
AREA G


DISCIPLINE:	SHEET NAME:	
PLUMBING	OMF-PLM-PLN	P-130G

SHEET
131
OF
263


KEYED NOTES

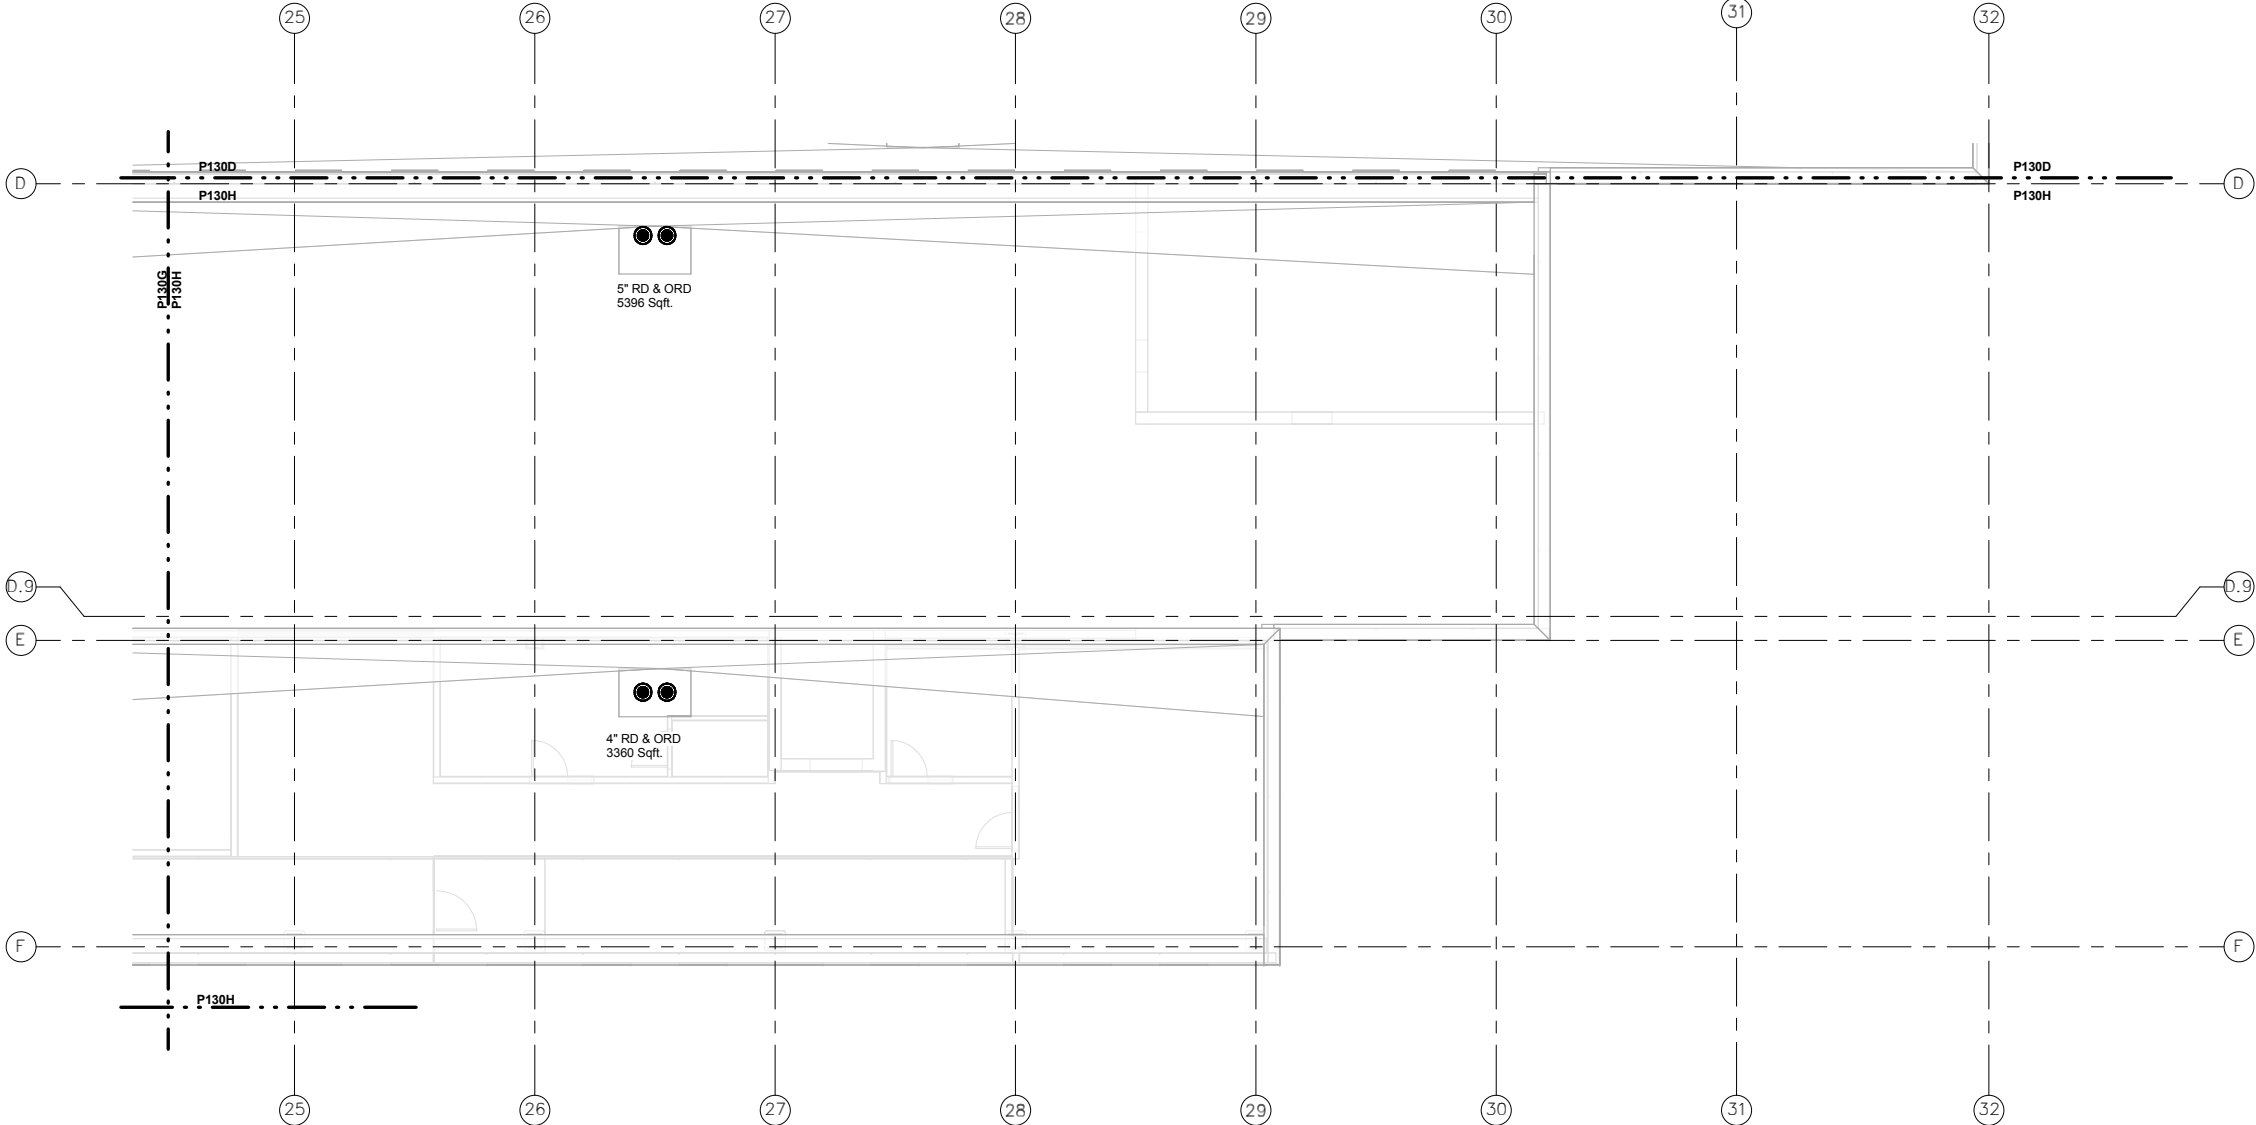

 1 ROOF LEVEL - PLUMBING PLAN - AREA H
P-130H SCALE: 1/8" = 1'-0"



KEY PLAN - SCALE: N.T.S.

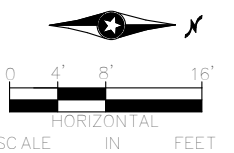[illegible]**60% SUBMISSION - 09/28/15**

OPERATIONS & MAINTENANCE FACILITY -V2B
PLUMBING
ROOF LEVEL - PARTIAL PLUMBING PLAN
AREA H

DISCIPLINE:


PLUMBING

SHEET NAME:


OMF-PLM-PLN

-130H

SHEET
132
OF
263

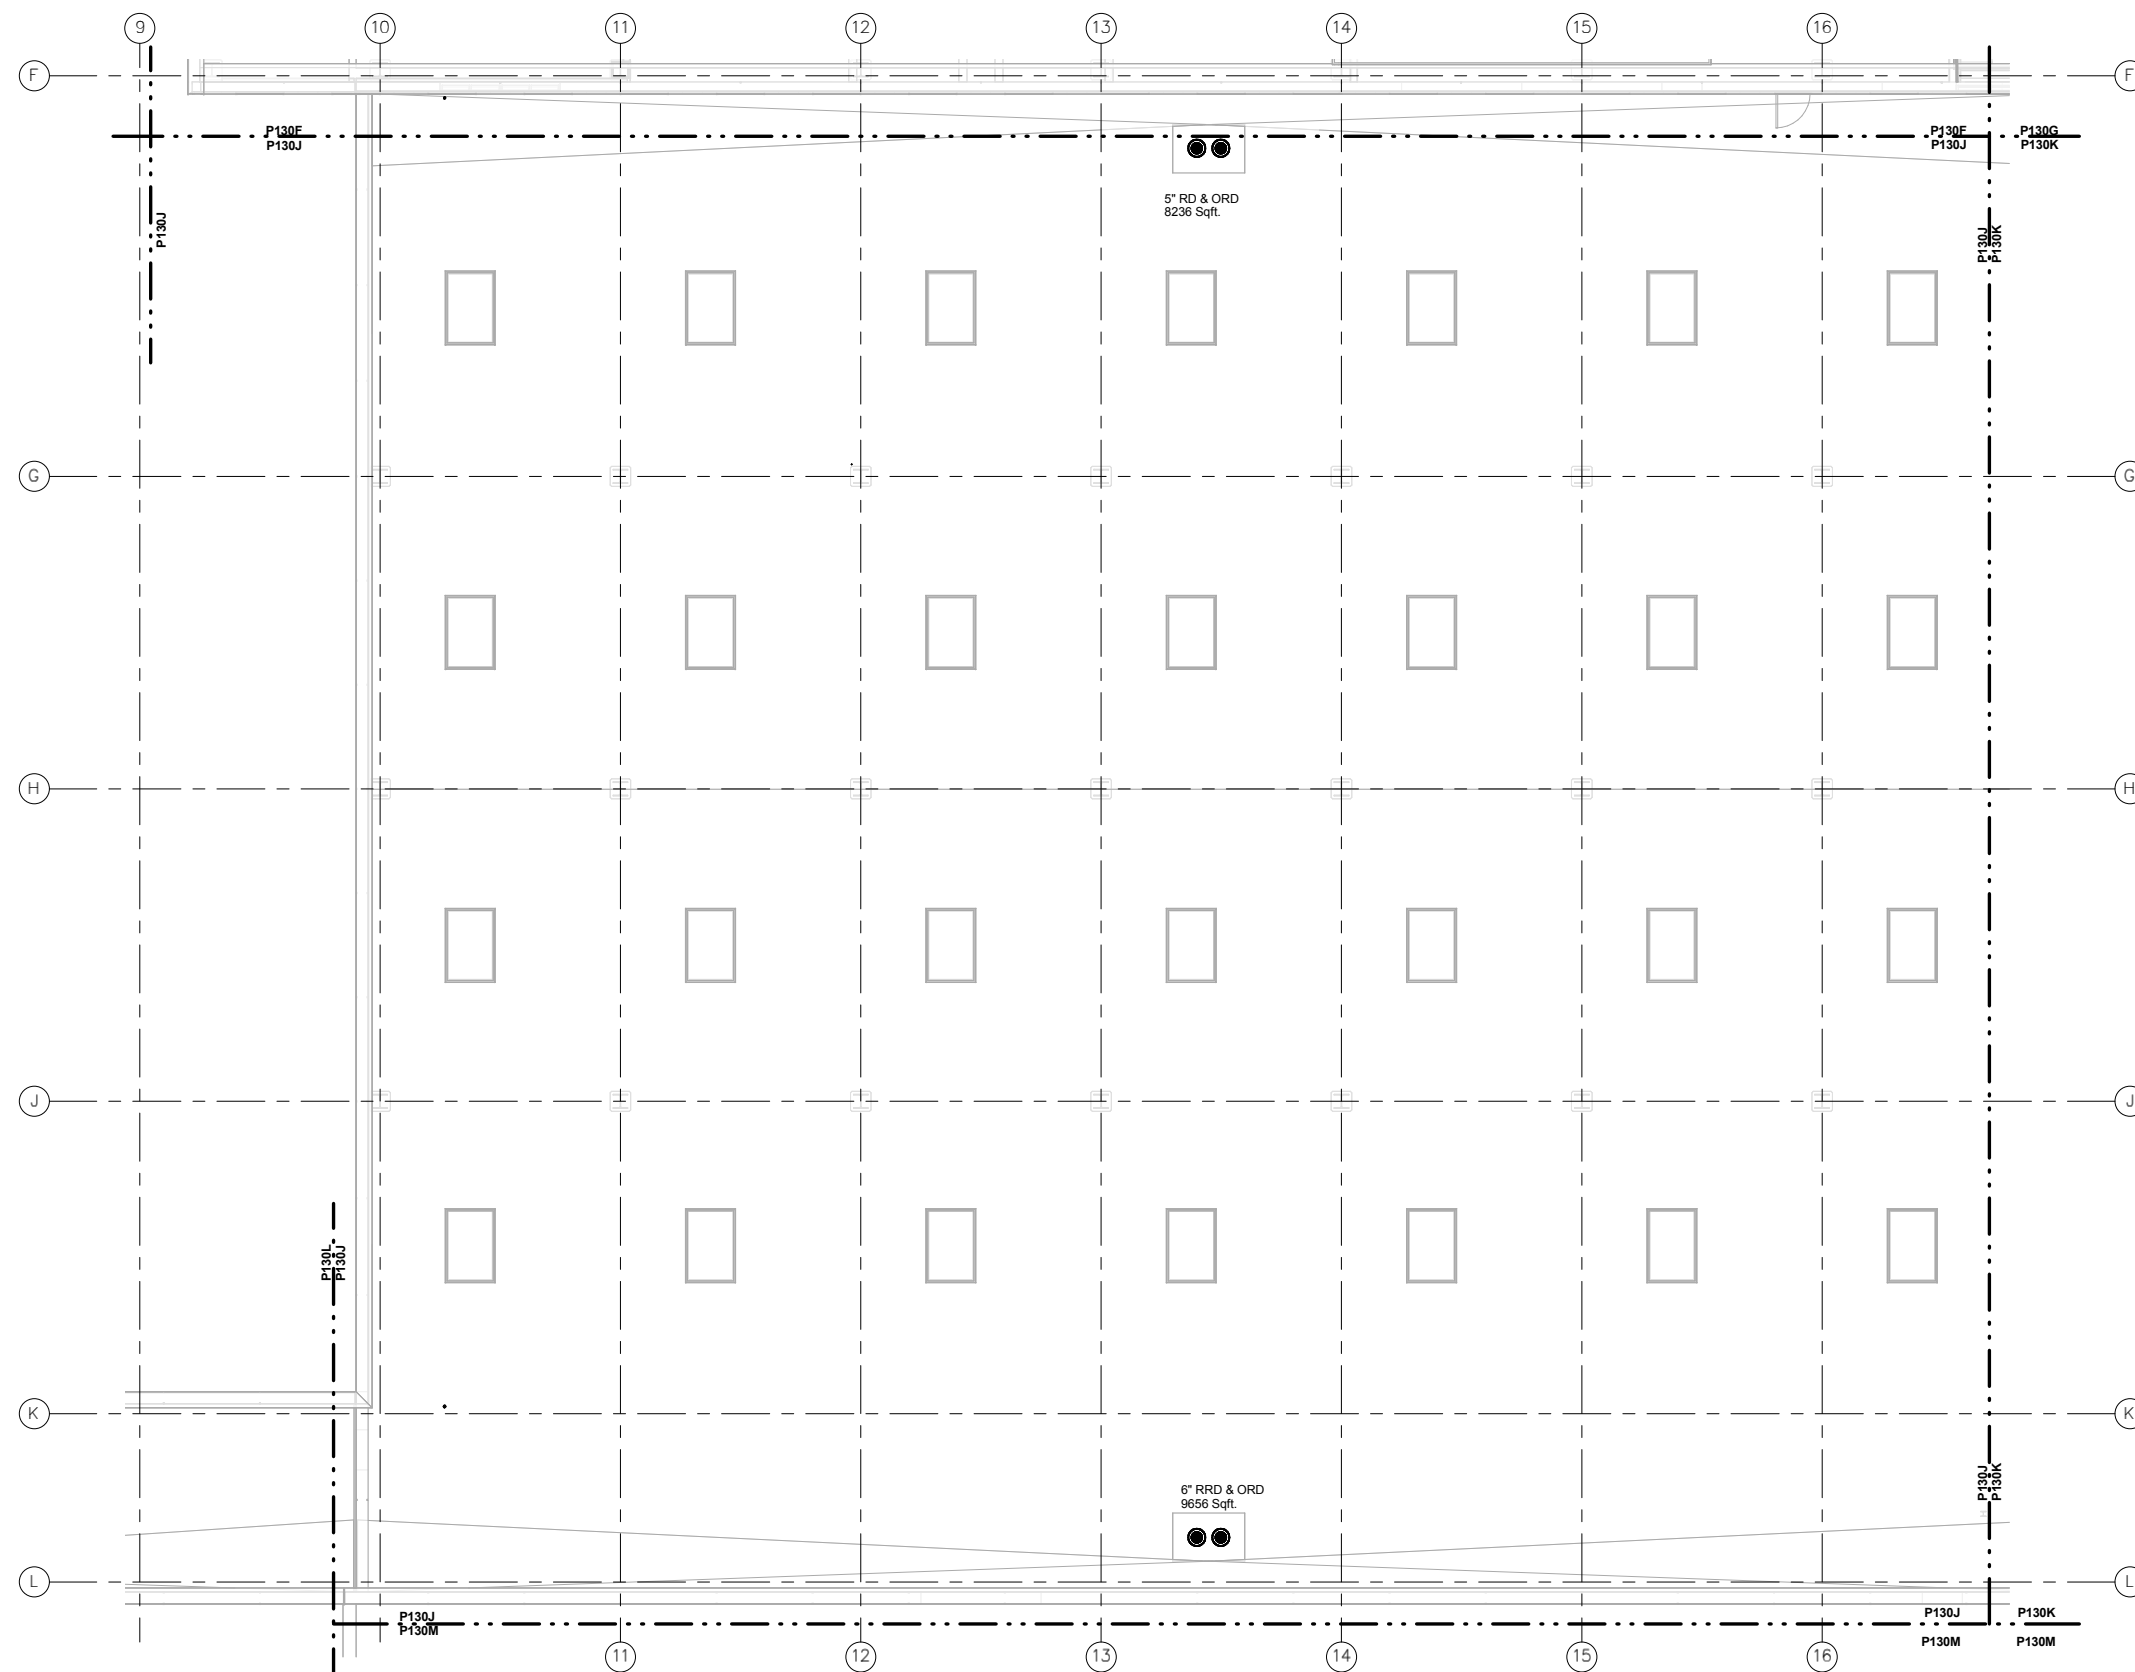

KEYED NOTES

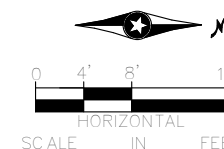

1 ROOF LEVEL - PLUMBING PLAN - AREA J
P-130J SCALE: 1/8" = 1'-0"

[illegible]

60% SUBMISSION - 09/28/15

OPERATIONS & MAINTENANCE FACILITY -V2B
PLUMBING
ROOF LEVEL - PARTIAL PLUMBING PLAN
AREA J

DISCIPLINE:


PLUMBING

	SHEET NAME:
--	--------------------


NAME: **OMF-PLM-PLN**

P-130J

3	SHEET
	133
	OF
	263

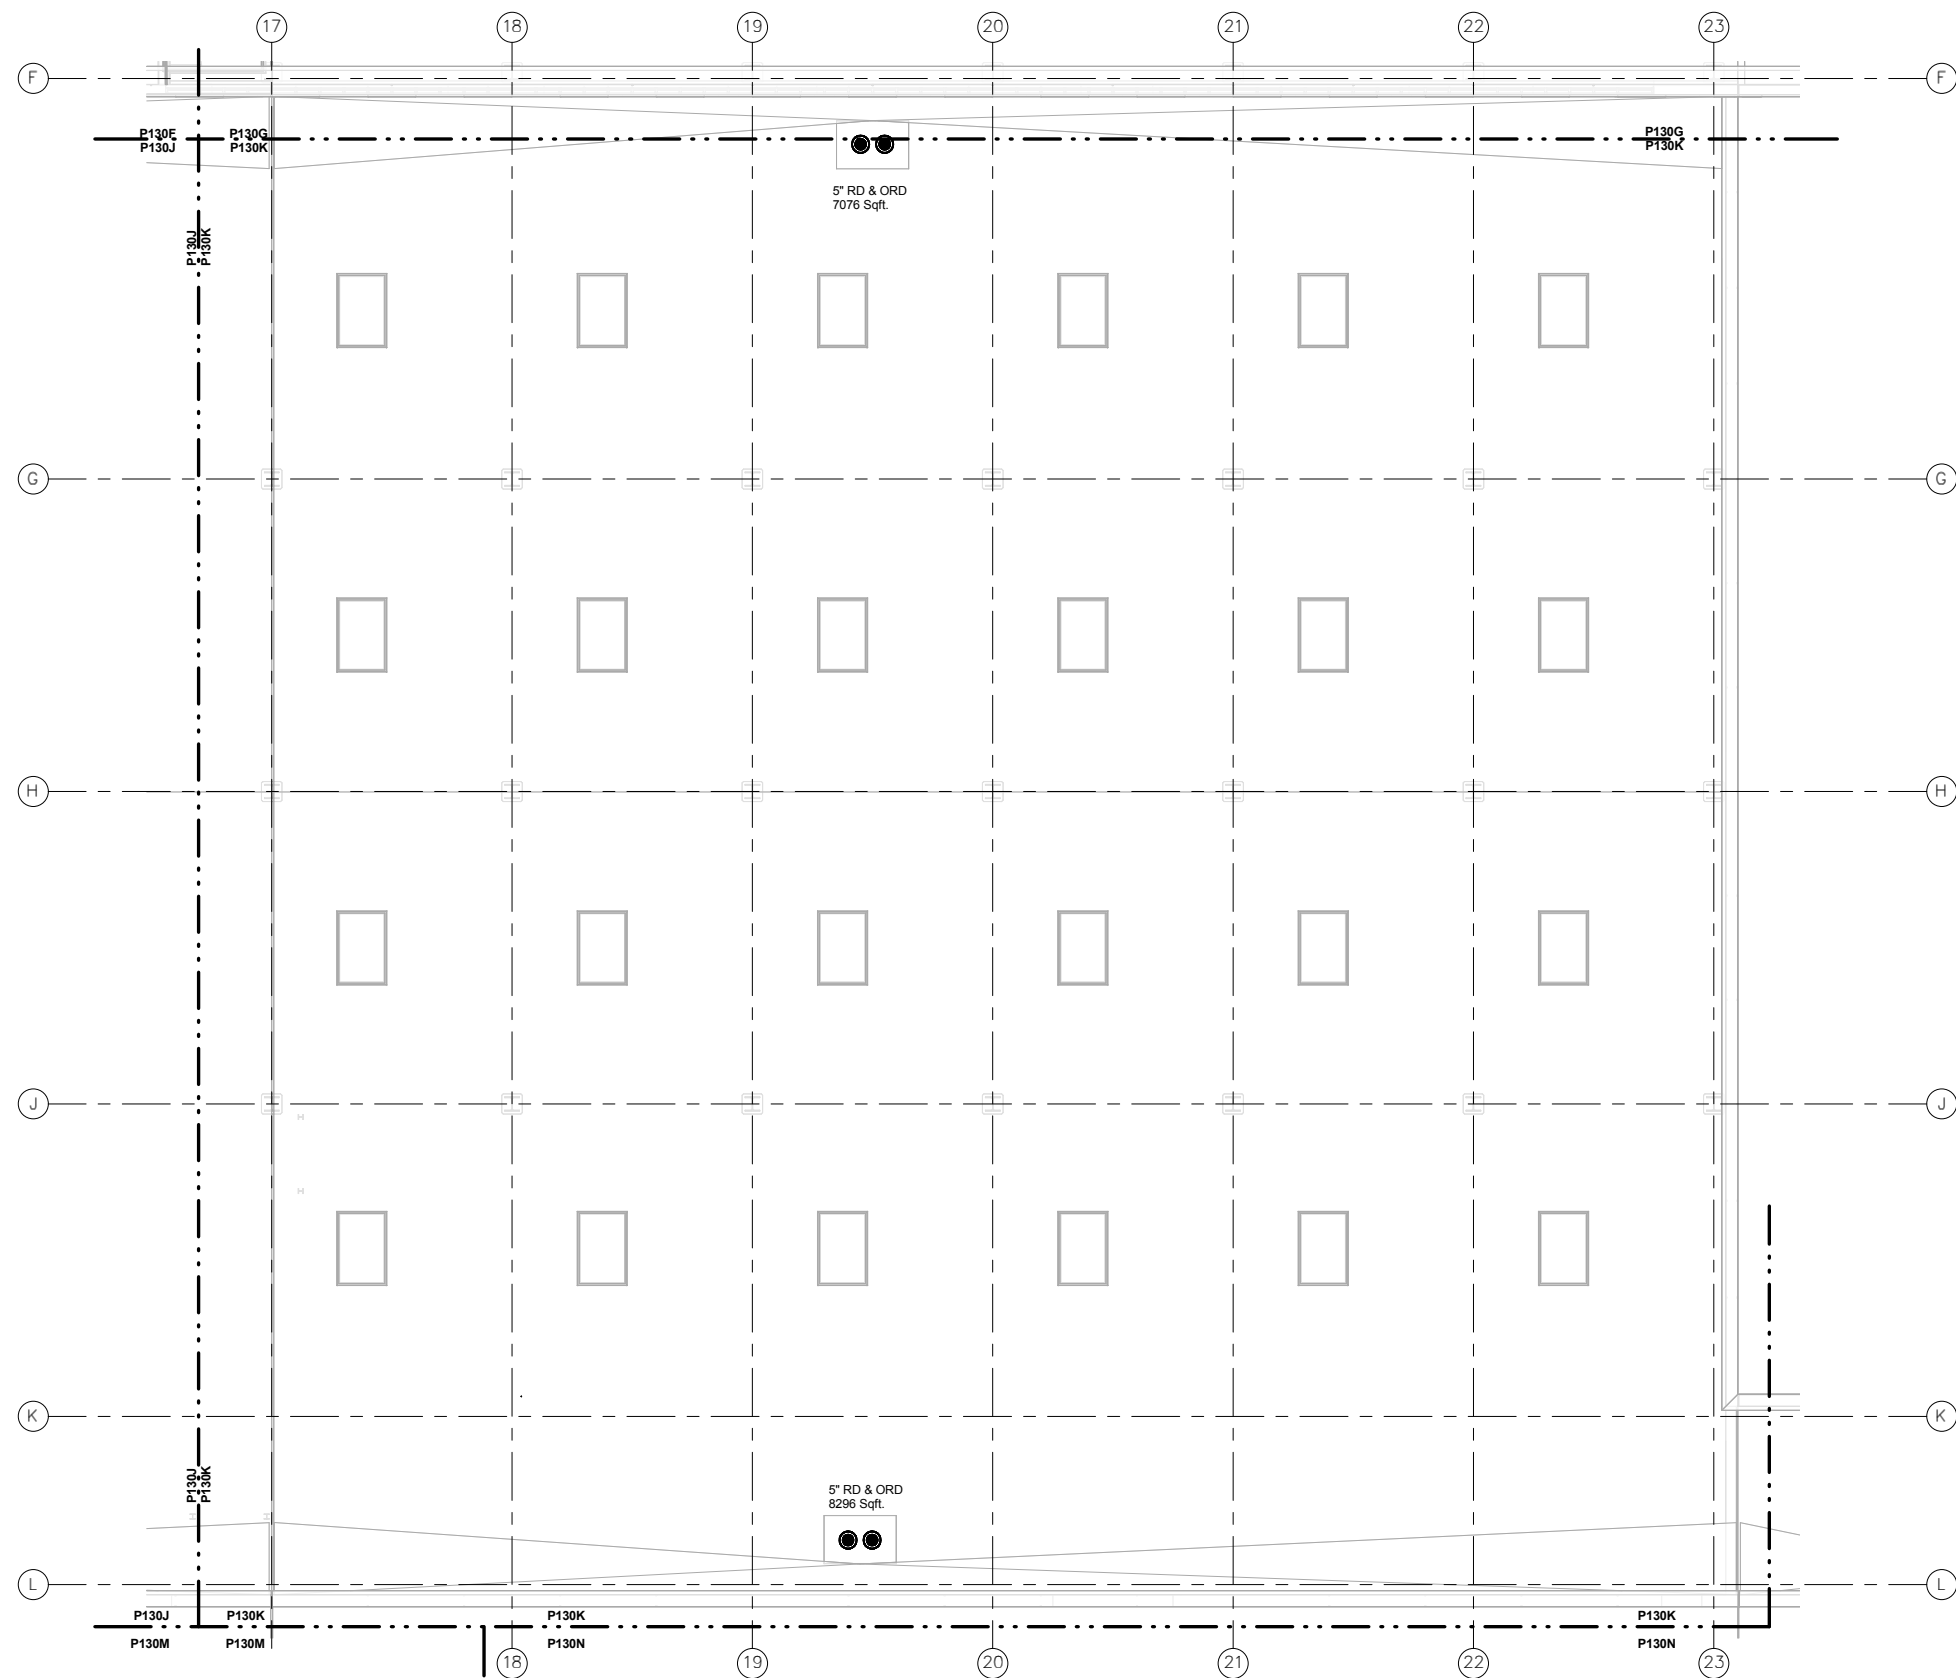

KEYED NOTES

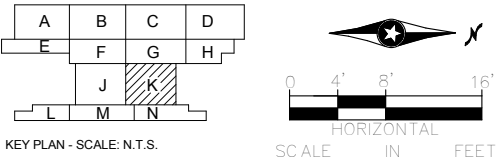

1 ROOF LEVEL - PLUMBING PLAN - AREA K
P-130K SCALE: 1/8" = 1'-0"


[illegible]**60% SUBMISSION - 09/28/15**

**OPERATIONS & MAINTENANCE FACILITY -V2B
PLUMBING
ROOF LEVEL - PARTIAL PLUMBING PLAN
AREA K**


DISCIPLINE:	SHEET NAME:	
PLUMBING	OMF-PLM-PLN	P-130K

SHEET
134
OF
263

KEYED NOTES

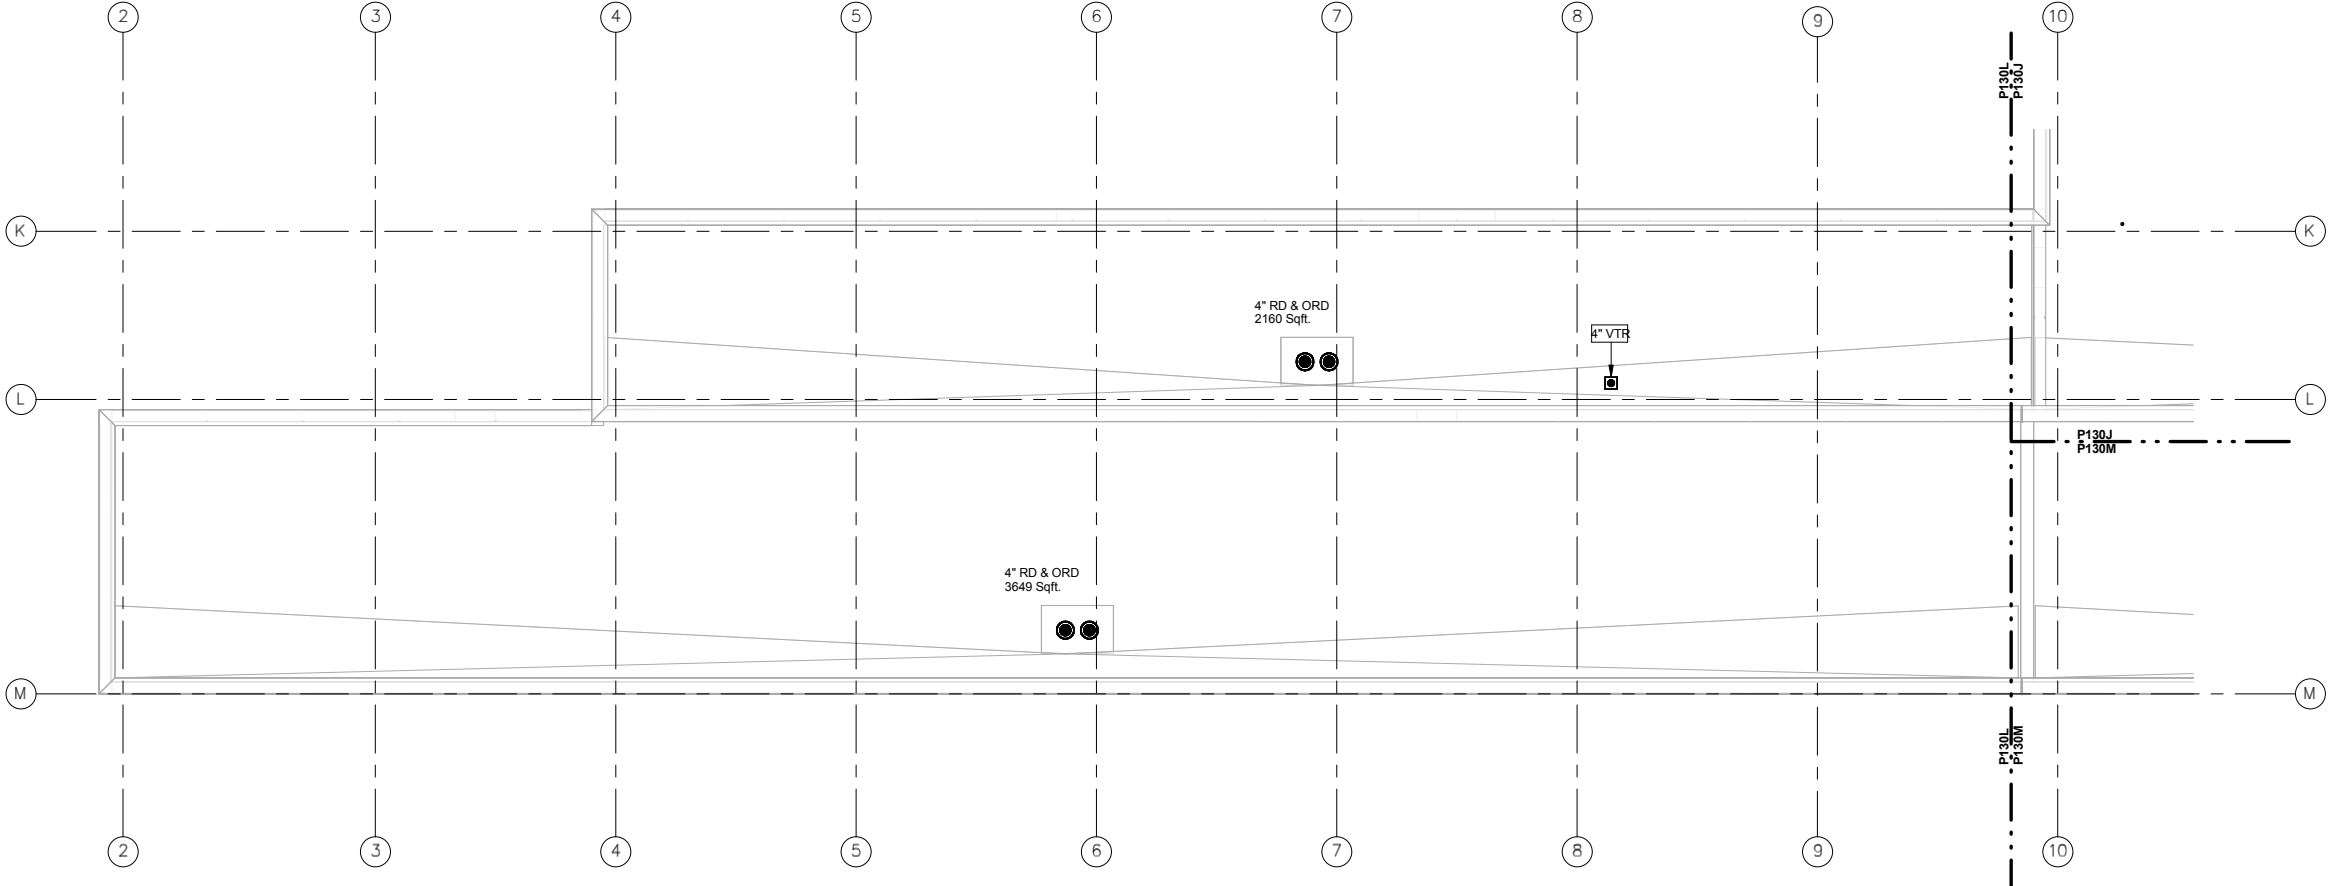

1 ROOF LEVEL - PARTIAL PLUMBING PLAN - AREA L
P-1301 SCALE: 1/8" = 1'-0"

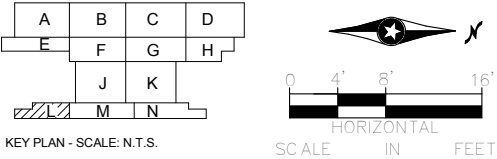[illegible]**60% SUBMISSION - 09/28/15**

OPERATIONS & MAINTENANCE FACILITY -V2B
PLUMBING
ROOF LEVEL - PARTIAL PLUMBING PLAN
AREA L

DISCIPLINE:

PLUMBING


SHEET NAME:

OMF-PLM-PLN


P-130L

SHEET
135
OF
263

KEYED NOTES

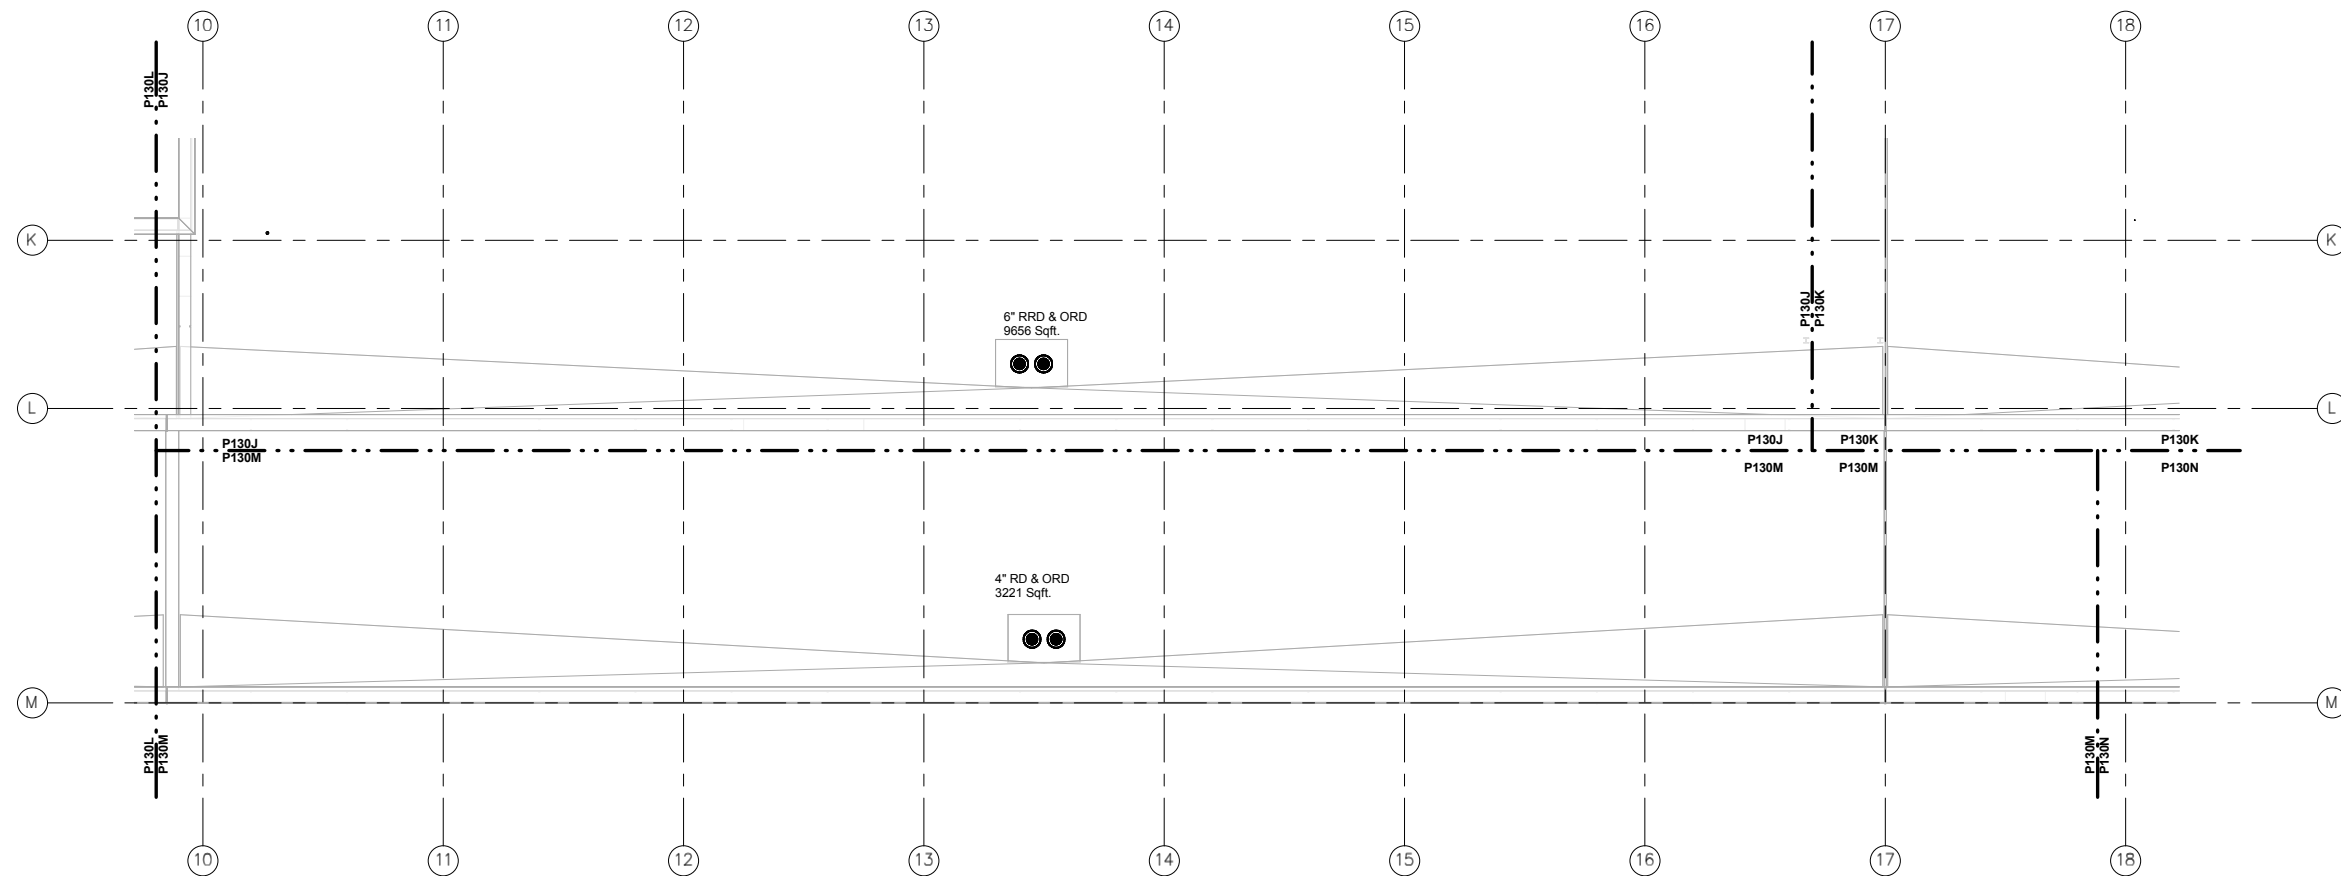

1 ROOF LEVEL - PLUMBING PLAN - AREA M
P-130M SCALE: 1/8" = 1'-0"

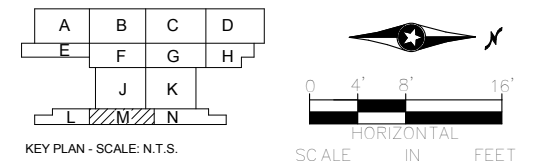[illegible]

60% SUBMISSION - 09/28/15




OPERATIONS & MAINTENANCE FACILITY -V2B
PLUMBING
ROOF LEVEL - PARTIAL PLUMBING PLAN
AREA M


DISCIPLINE:	SHEET NAME:	
PLUMBING	OMF-PLM-PLN	P-130M

SHEET
136
OF
263


KEYED NOTES

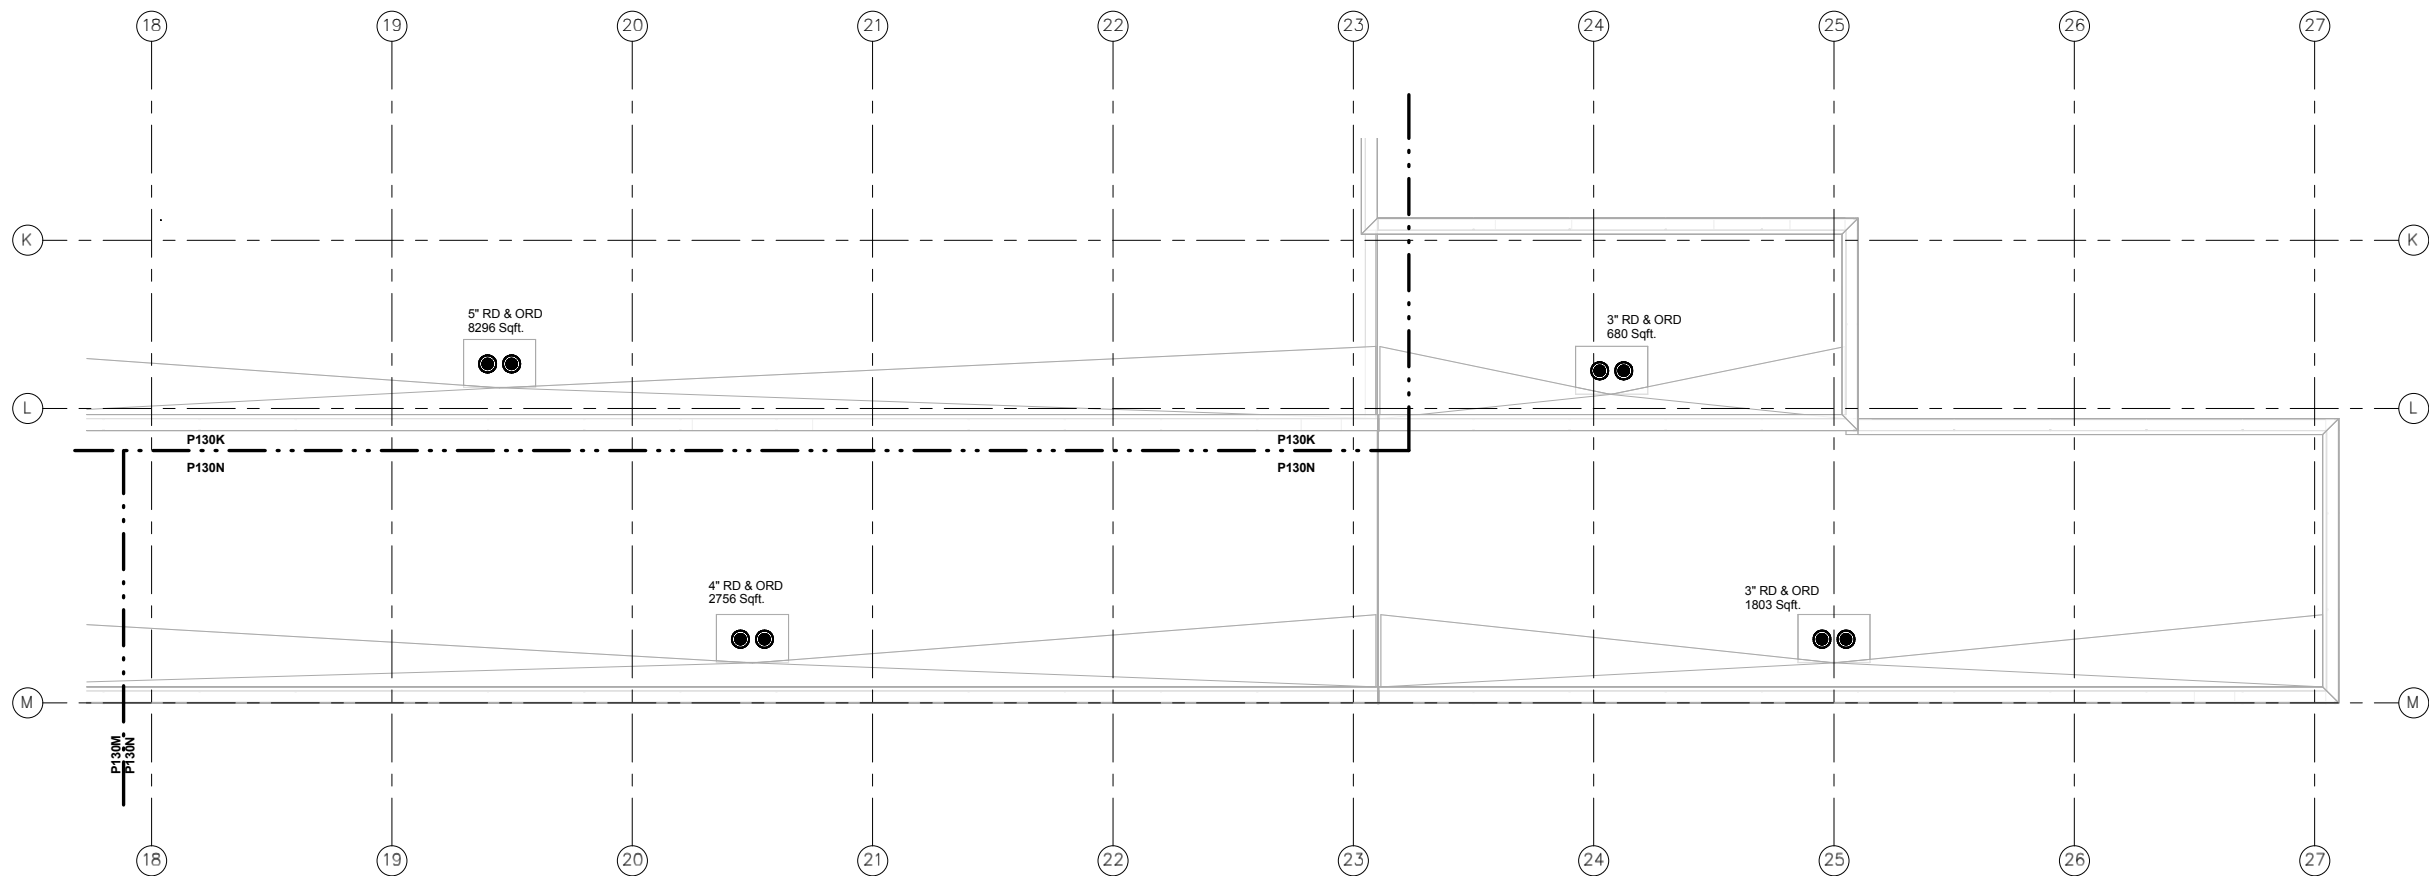

1 ROOF LEVEL - PLUMBING PLAN - AREA N
P-130N SCALE: 1/8" = 1'-0"

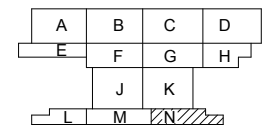

KEY PLAN - SCALE: N.T.S.

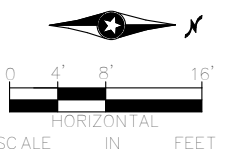[illegible]

60% SUBMISSION - 09/28/15



OPERATIONS & MAINTENANCE FACILITY -V2B
PLUMBING
ROOF LEVEL - PARTIAL PLUMBING PLAN
AREA N

DISCIPLINE:

 
PLUMBING

SHEET NAME:

OMF-PLM-PLN

P-130N


SHEET
137
OF
263




The key plan shows a site layout with building footprints labeled A through S. The buildings are arranged in a grid-like fashion. Building A is at the top left, followed by B, C, and D. Below A is E, which is hatched. Below E is F, which is also hatched. To the right of F is G, and below G is H. Below H is I, which is hatched. Below I is J, and to the right of J is K. Below K is L, and to the right of L is M. Below M is N, and to the right of N is O, which is hatched. Below O is P, and to the right of P is Q, which is hatched. Below Q is R, and to the right of R is S, which is hatched. The site is bounded by a road to the north and a road to the east. A north arrow is located to the right of the site plan, pointing towards the top right. A scale bar is located below the north arrow, showing a scale of 0 to 16 feet, with markings at 4, 8, and 16 feet. The scale is labeled 'SCALE IN FEET'.

KEY PLAN - SCALE: N.T.S.

AECOM ENGINEERING • LLC CERTIFIED WOMEN'S BUSINESS ENTERPRISE METROPOLITAN COUNCIL SOUTHWEST	OPERATIONS & MAINTENANCE FACILITY -V2B PLUMBING LEVEL ONE - PARTIAL COMPRESSED AIR PLAN AREA E	SHEET 139 OF 263
60% SUBMISSION - 09/28/15	DISCIPLINE: PLUMBING SHEET NAME: OMF-PLM-PLN P-210E	

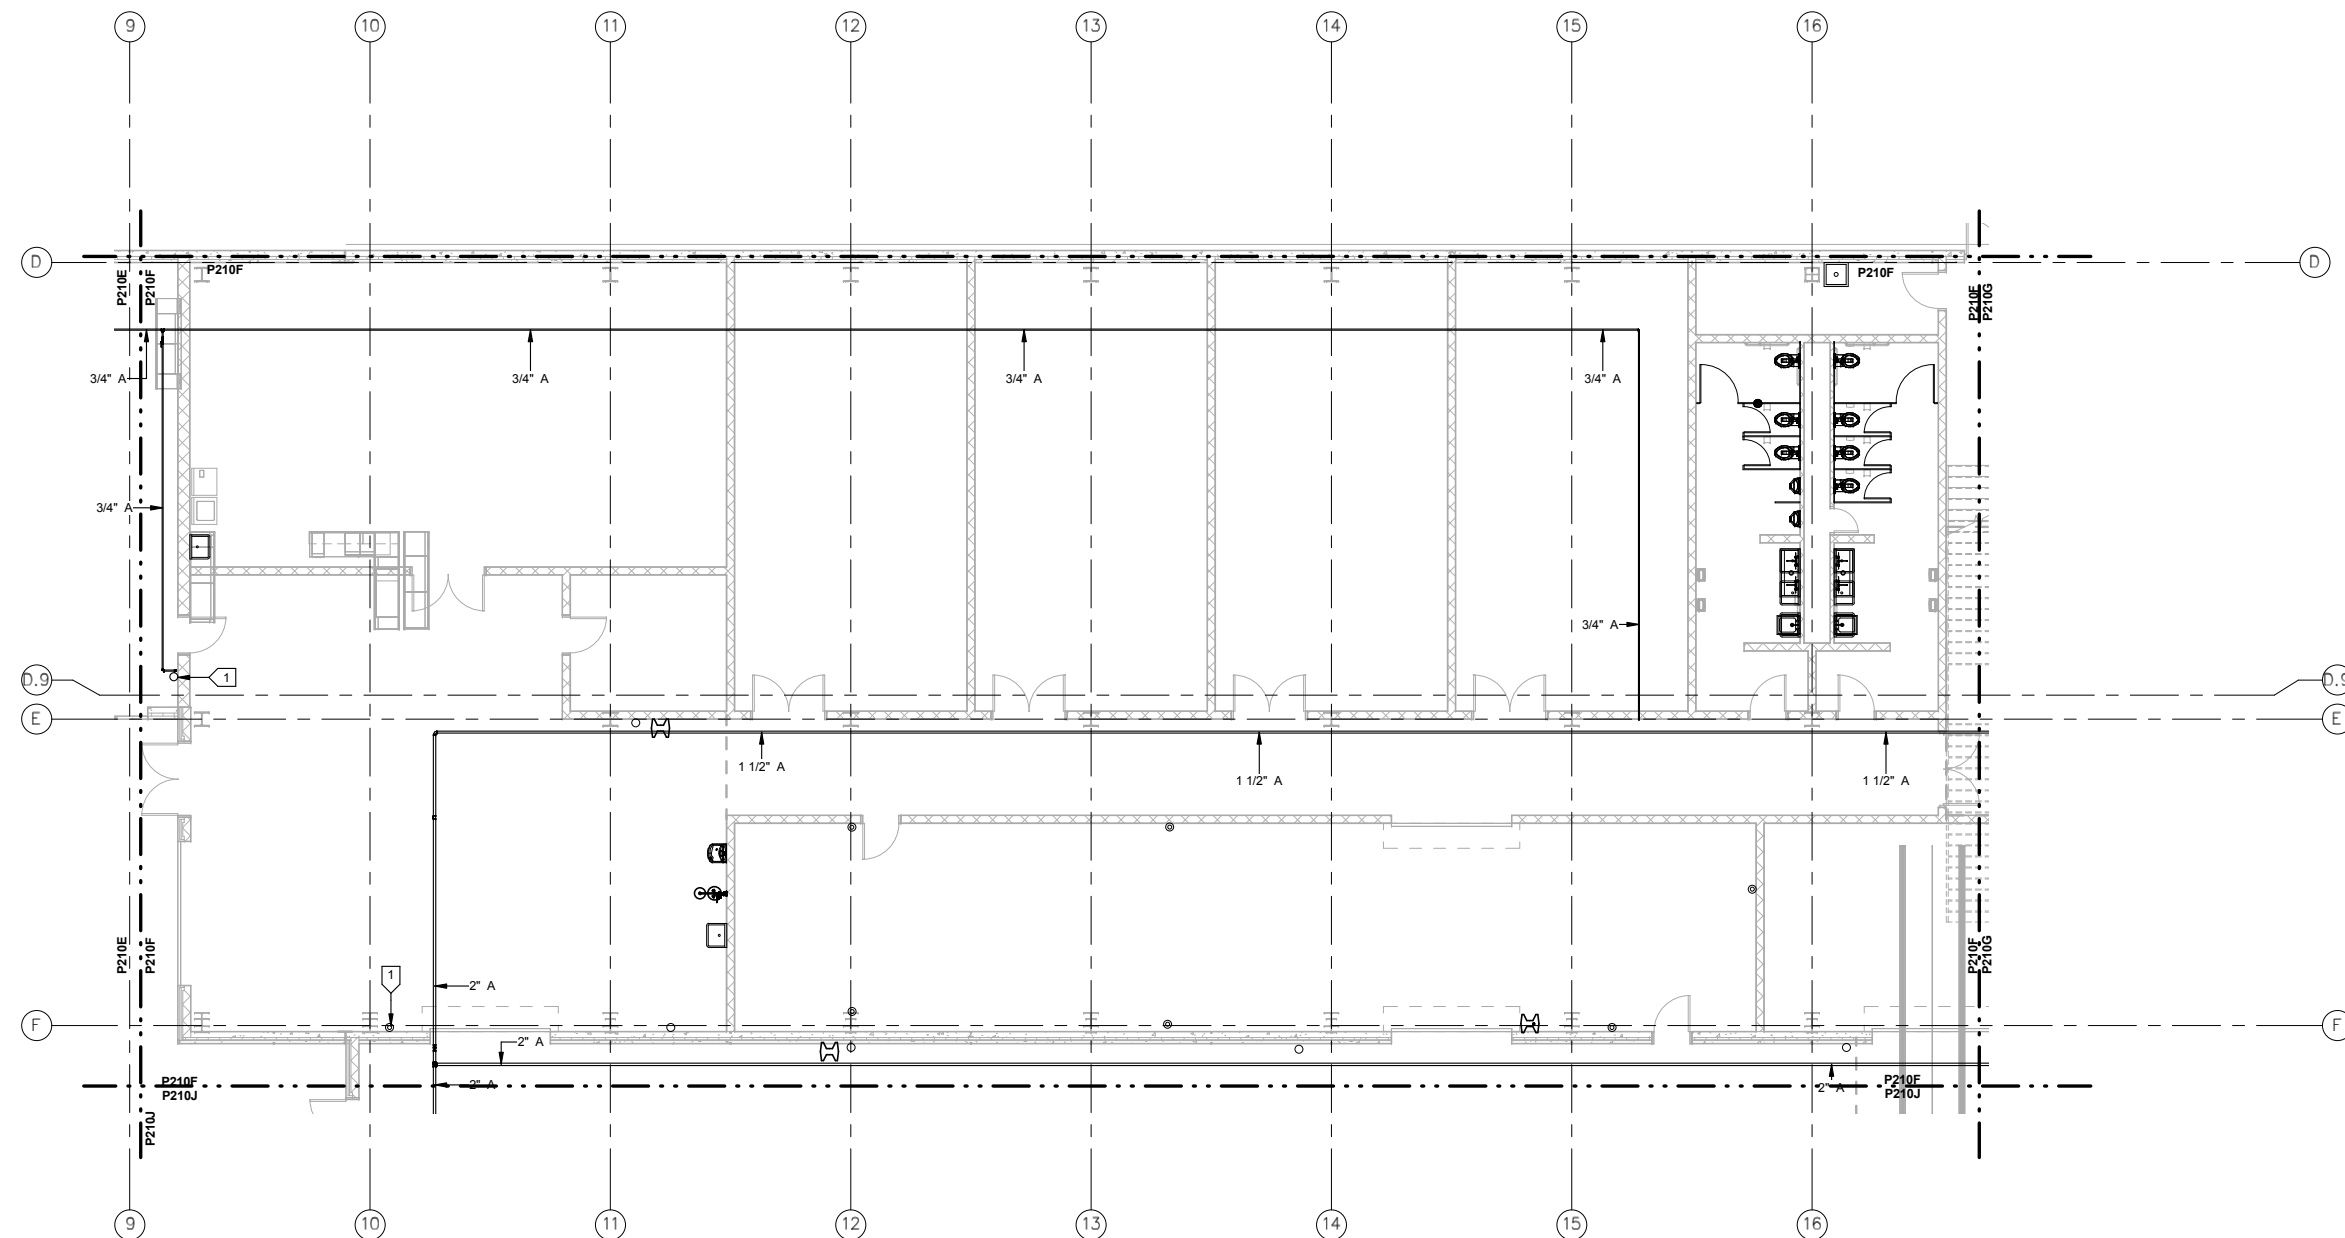

1 LEVEL ONE - AREA F - COMPRESSED AIR PLAN
P-210F SCALE: 1/8" = 1'-0"

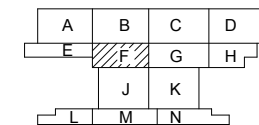[illegible]

60% SUBMISSION - 09/28/15

OPERATIONS & MAINTENANCE FACILITY -V2B
PLUMBING
LEVEL ONE - PARTIAL COMPRESSED AIR
PLAN AREA F

DISCIPLINE:

SHEET NAME:

P-210F

SHEET
140
OF
263

KEY PLAN - SCALE: N.T.S.


The key plan shows a site layout with building footprints labeled A through N. A north arrow points towards the top right. A scale bar indicates distances in feet, with markings at 0, 4', 8', and 16'.

[illegible]


OPERATIONS & MAINTENANCE FACILITY -V2B
PLUMBING
LEVEL ONE - PARTIAL COMPRESSED AIR
PLAN AREA G

P-210G

SHEET
141
OF
263

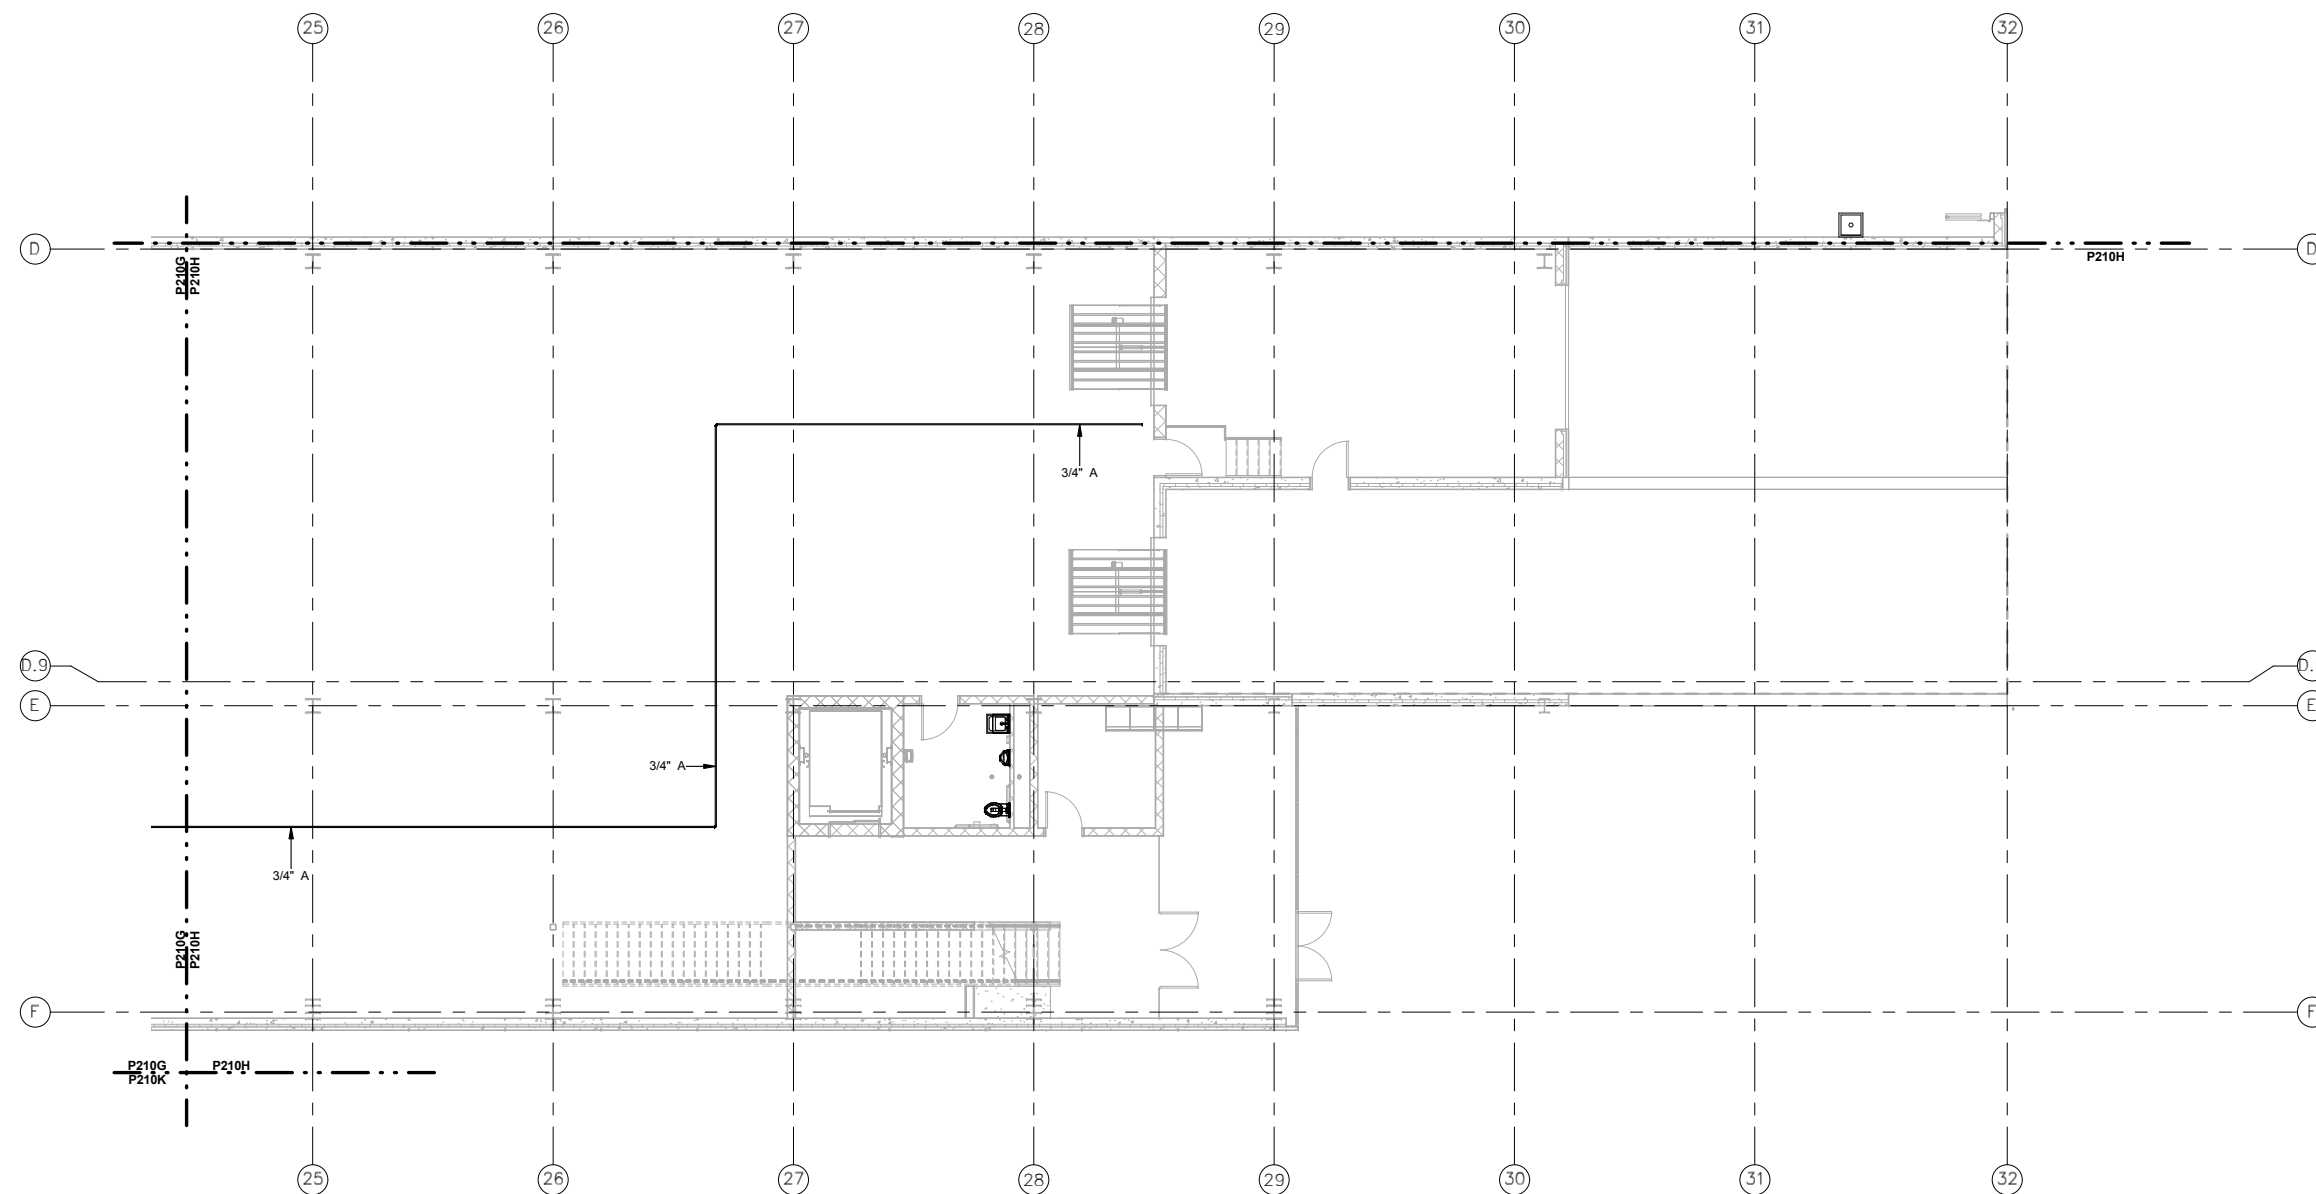

1 LEVEL ONE - AREA H - COMPRESSED AIR PLAN
P-210H SCALE: 1/8" = 1'-0"

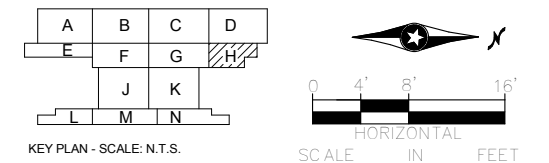[illegible]



60% SUBMISSION - 09/28/15



OPERATIONS & MAINTENANCE FACILITY -V2B
PLUMBING
LEVEL ONE - PARTIAL COMPRESSED AIR
PLAN AREA H

DISCIPLINE:	SHEET NAME:	
PLUMBING	OMF-PLM-PLN	P-210H

 
SHEET
142
OF
263

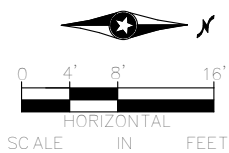[illegible]

SHEET
143
OF
263

P-210J

 60% SUBMISSION - 09/28/15



AECOM **ENGINEERING • LLC**
CERTIFIED WOMEN'S BUSINESS ENTERPRISE



OPERATIONS & MAINTENANCE FACILITY -V2B
PLUMBING
LEVEL ONE - PARTIAL COMPRESSED AIR
PLAN AREA K

DISCIPLINE:

PLUMBING


SHEET NAME:

NAME: **OMF-PLM-PLN**

P-210K


SHEET
144
OF
263

9/21/2015 12:08:17 PM C:\Users\lisa\Documents\OMF_Plumb_lisa.rvt

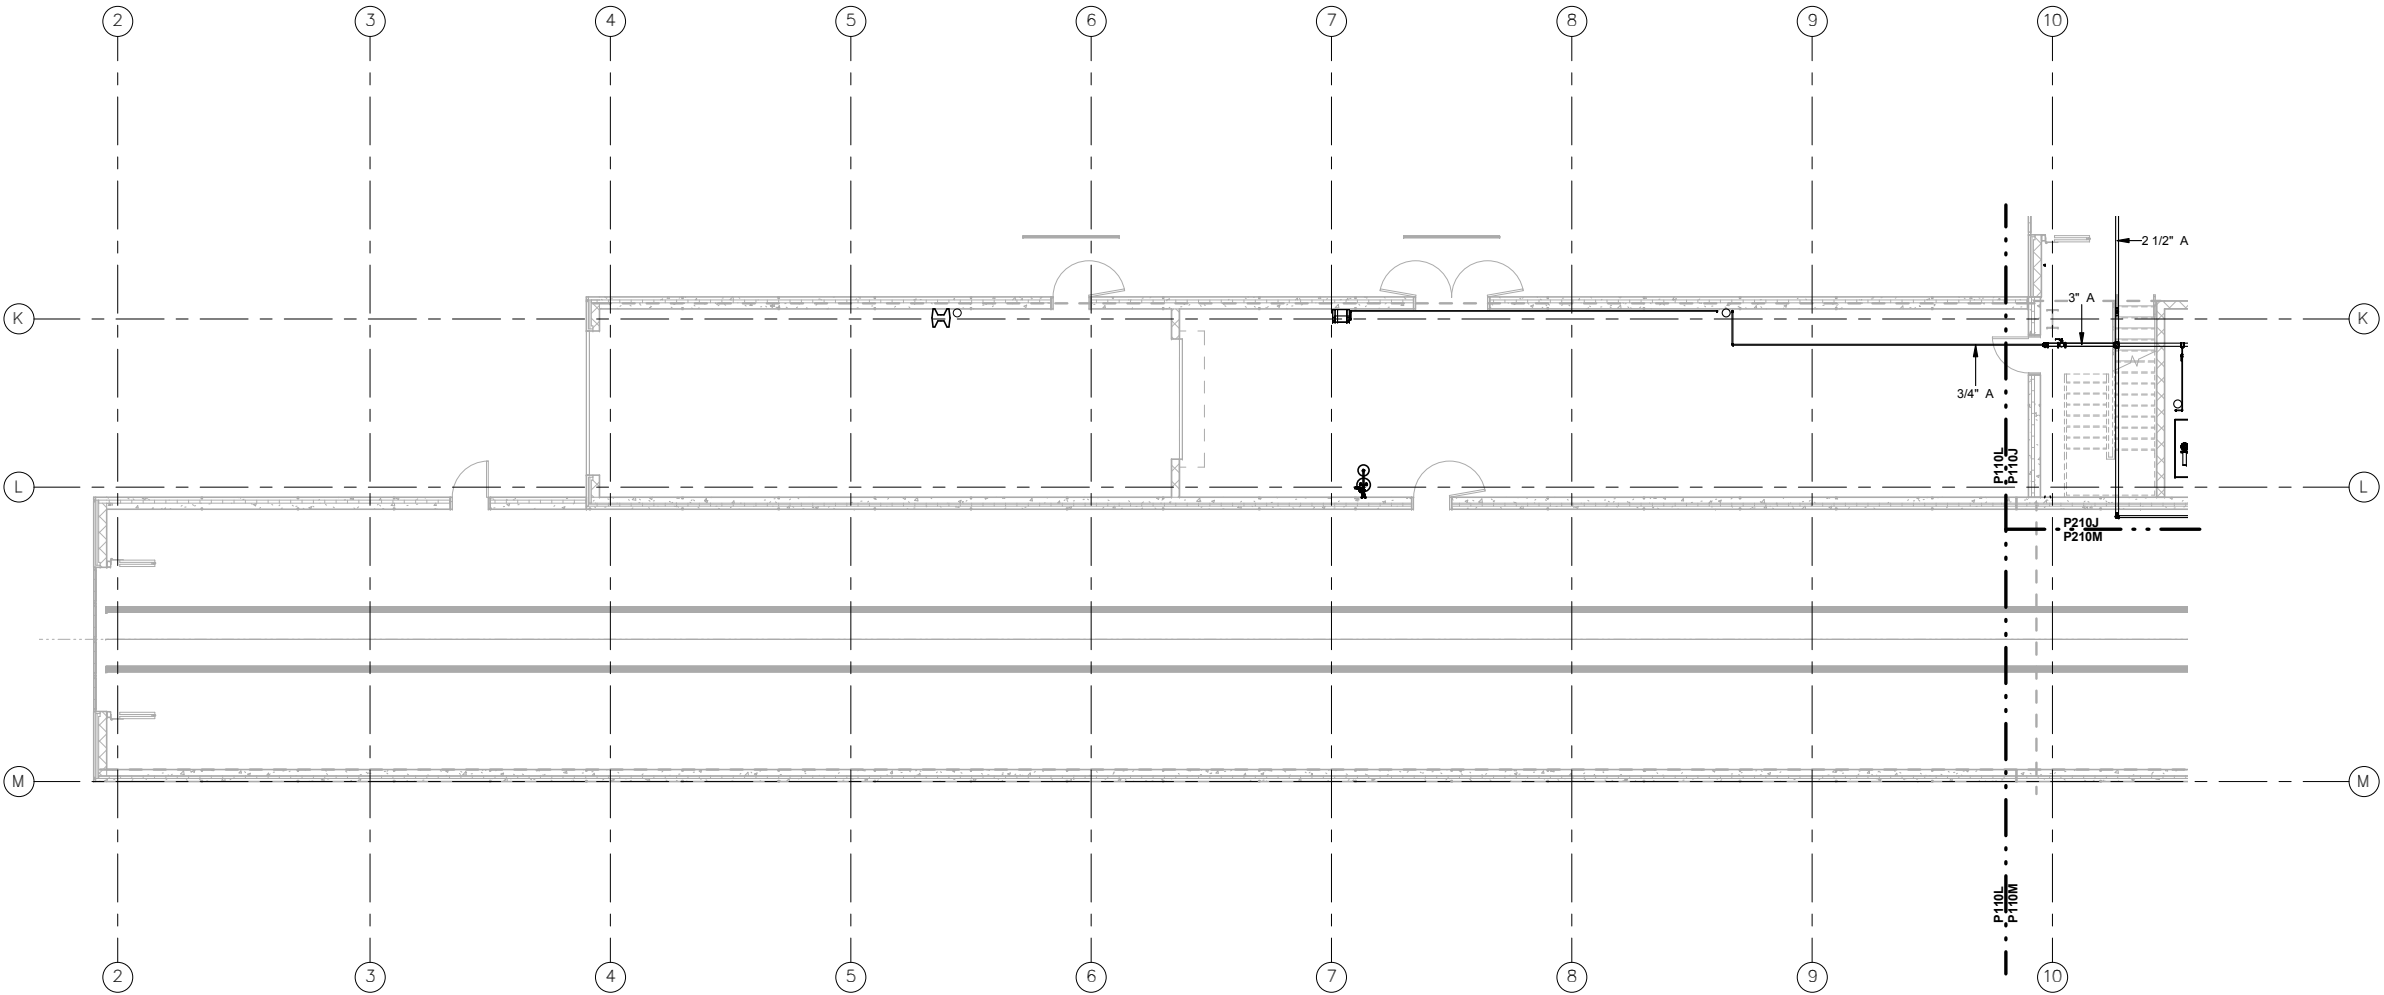


KEYED NOTES

1
P-210L
LEVEL ONE - AREA L - COMPRESSED AIR PLAN
SCALE: 1/8" = 1'-0"

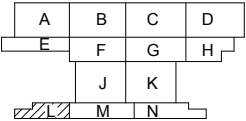

KEY PLAN - SCALE: N.T.S.

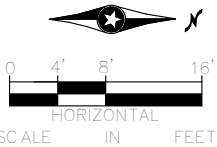

NO	DATE	BY	CHECK	DESIGN	REVISION / SUBMITTAL



ENGINEERING • LLC
CERTIFIED WOMEN'S
BUSINESS ENTERPRISE



60% SUBMISSION - 09/28/15


OPERATIONS & MAINTENANCE FACILITY -V2B
PLUMBING
LEVEL ONE - PARTIAL COMPRESSED AIR
PLAN AREA L

DISCIPLINE:
PLUMBING

SHEET NAME:
OMF-PLM-PLN

P-210L

9/21/2015 12:08:22 PM C:\Users\lisa\Documents\OMF_Plumb_lisa.rvt

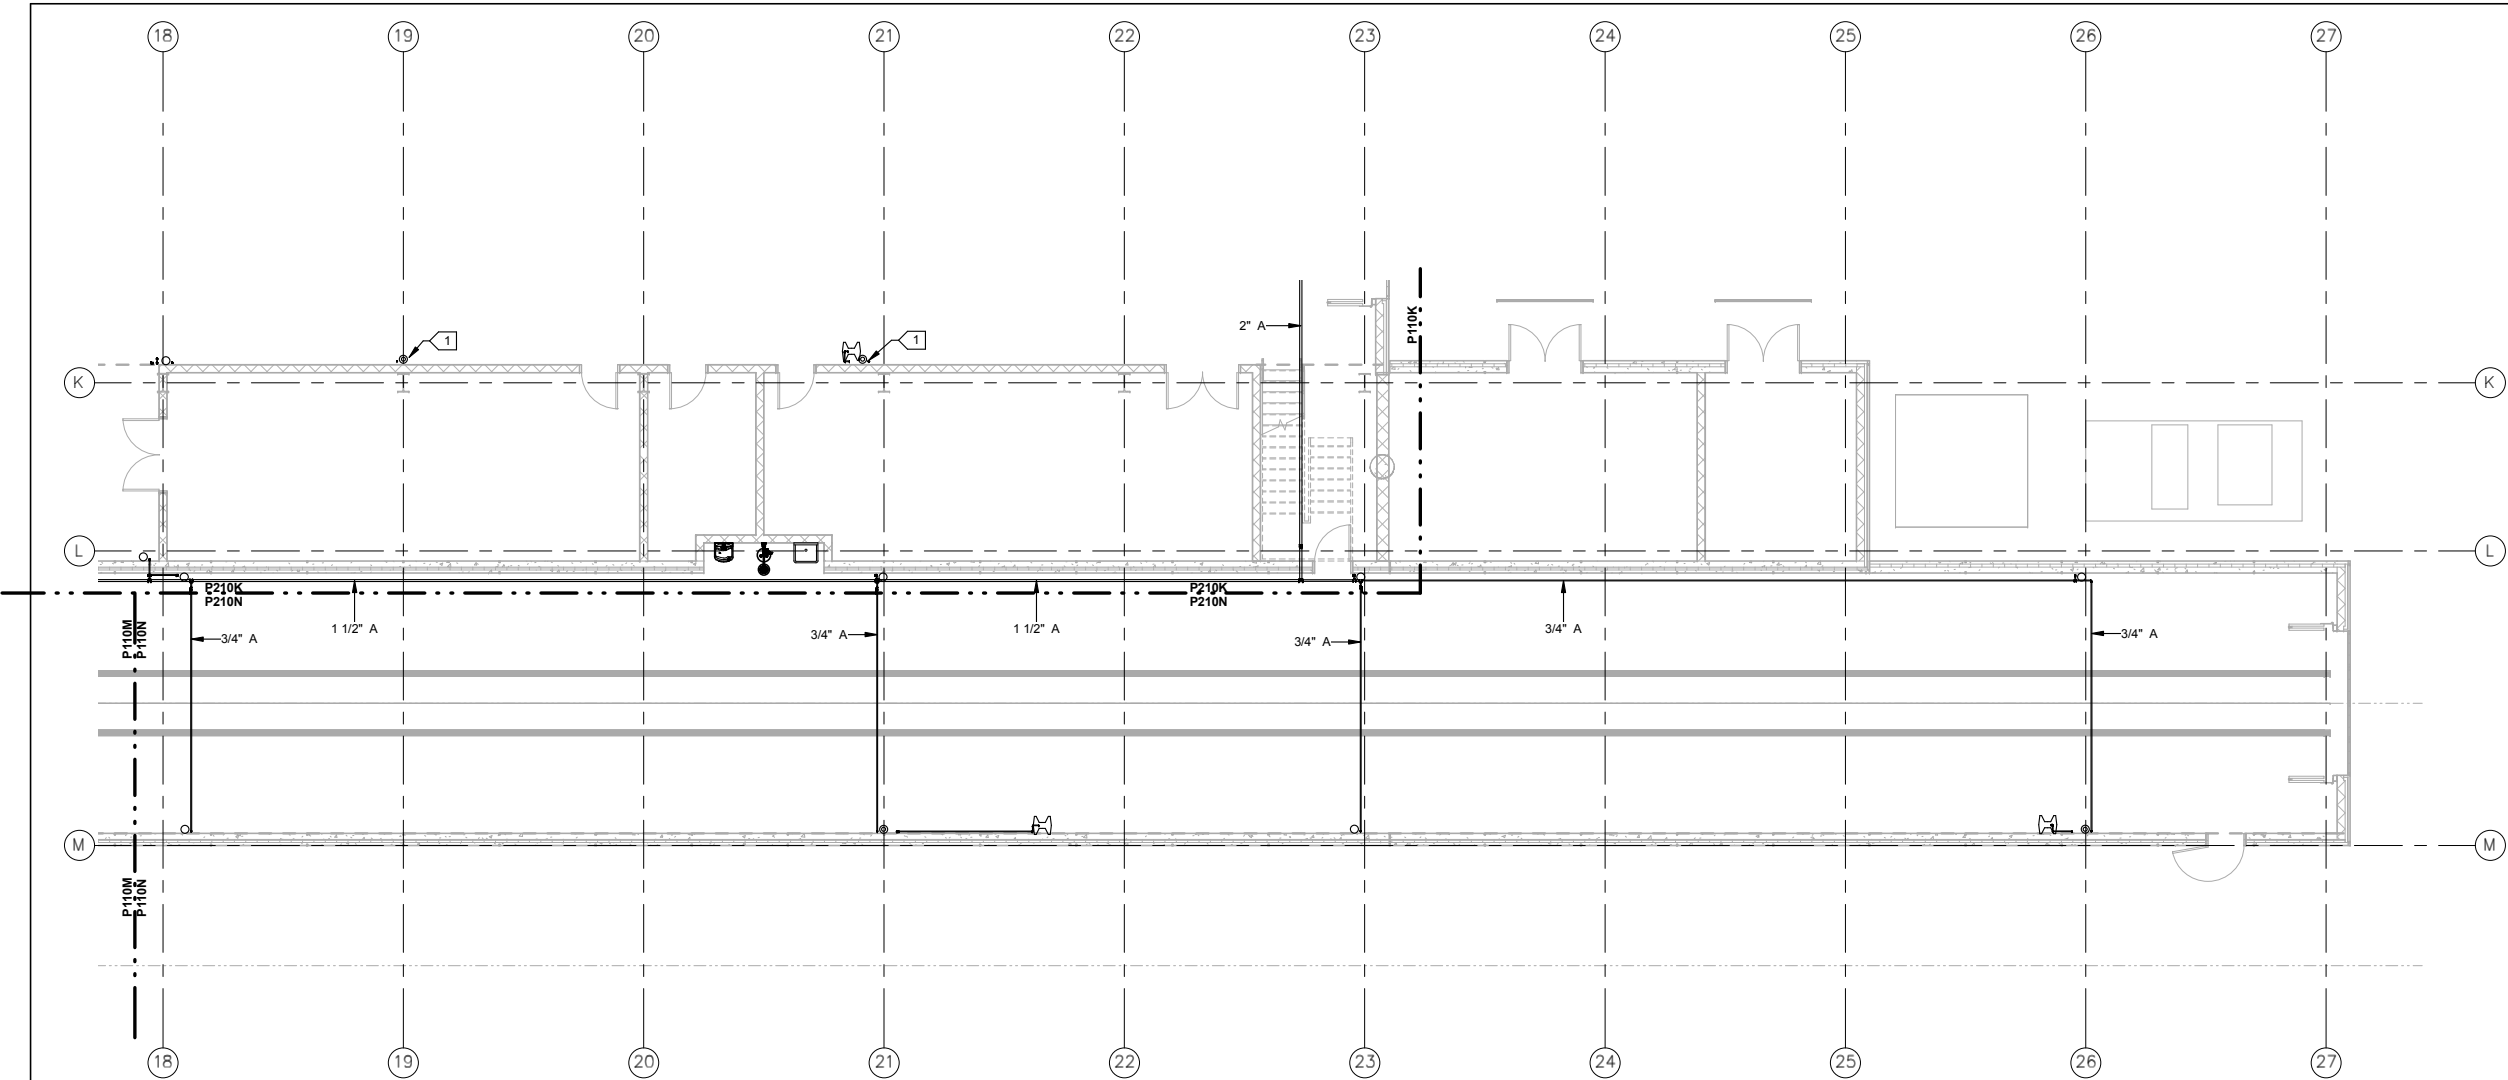

1


KEYED NOTES

3/4" DOWN TO PRESSURE REGULATOR AND DRYER.
REFER TO INDUSTRIAL PLANS FOR OUTLET
CONFIGURATIONS.


1
P-210N

LEVEL ONE - AREA N - COMPRESSED AIR PLAN

SCALE: 1/8" = 1'-0"

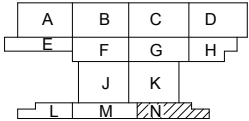


KEY PLAN - SCALE: N.T.S.

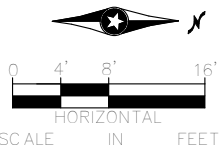


NO	DATE	BY	CHECK	DESIGN	REVISION / SUBMITTAL


		OPERATIONS & MAINTENANCE FACILITY -V2B		SHEET 147 OF 263
		PLUMBING LEVEL ONE - PARTIAL COMPRESSED AIR PLAN AREA N		
60% SUBMISSION - 09/28/15		DISCIPLINE: PLUMBING	SHEET NAME: OMF-PLM-PLN P-210N	

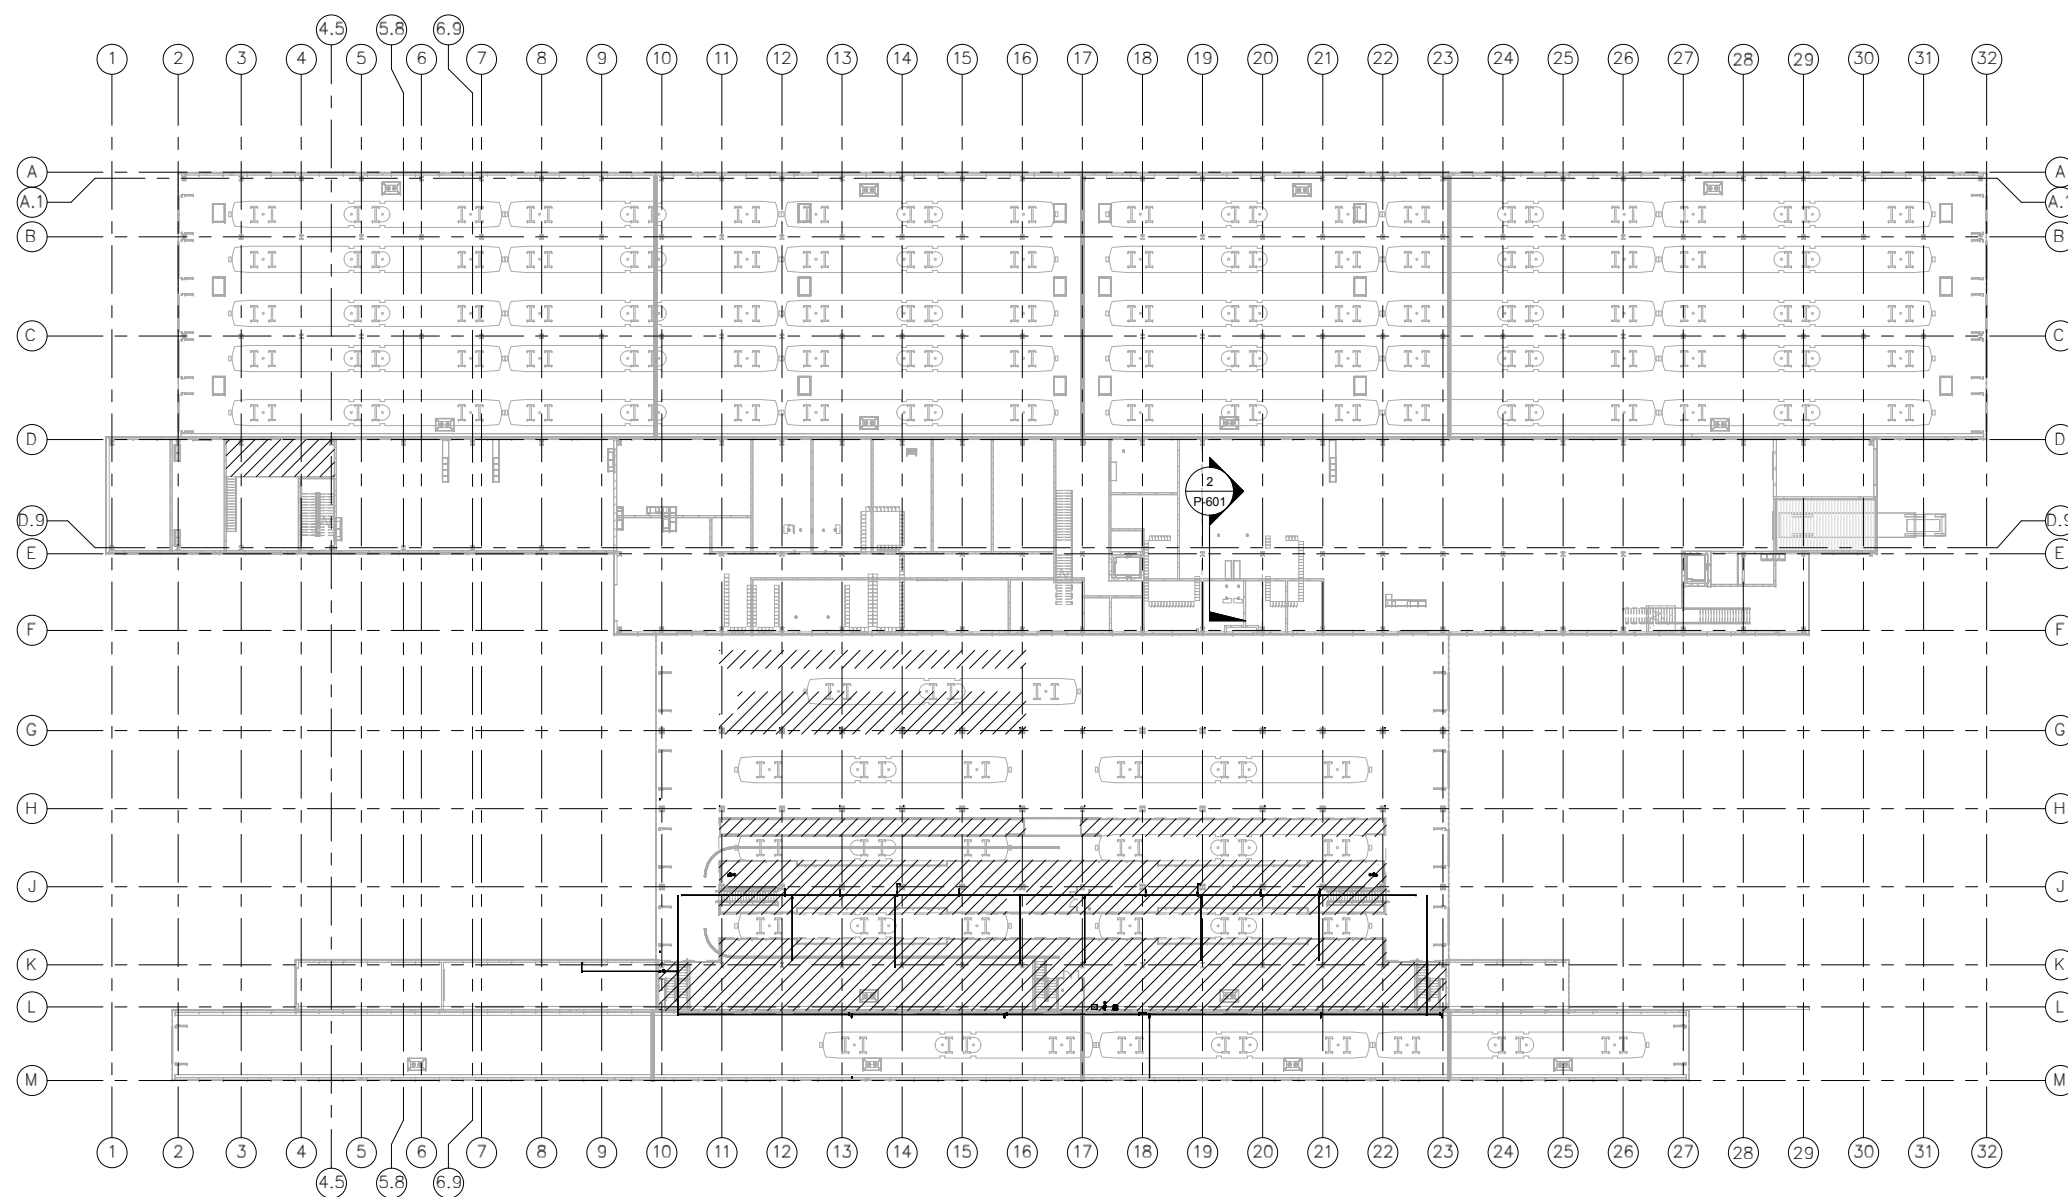

1 OVERALL MEZZANINE COMPRESSED AIR PLAN
P-215 SCALE: 1/32" = 1'-0"

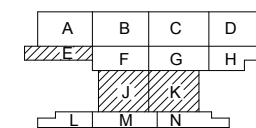

KEY PLAN - SCALE: N.T.S.

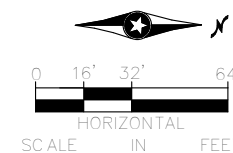[illegible]

60% SUBMISSION - 09/28/15

**OPERATIONS & MAINTENANCE FACILITY -V2B
PLUMBING
MEZZANINE LEVEL OVERALL COMPRESSED
AIR FLOOR PLAN**

DISCIPLINE:


PLUMBING

	SHEET NAME:
--	--------------------

NAME. **OMF-PLM-PLN**

P-215

3	SHEET
	148
	OF
	263

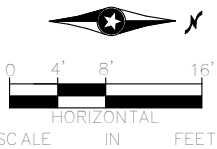[illegible]


60% SUBMISSION - 09/28/15

**OPERATIONS & MAINTENANCE FACILITY -V2B
PLUMBING
MEZZANINE LEVEL - PARTIAL COMPRESSED
AIR PLAN AREA K**

DISCIPLINE: **PLUMBING**

SHEET NAME:	
OMF-PLM-PLN	P-215K

SHEET
150
OF
263

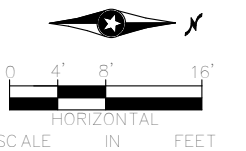[illegible]




60% SUBMISSION - 09/28/15



ENLARGED PLUMBING PLANS 2

DISCIPLINE:	SHEET NAME:	
PLUMBING	OMF-PLM-PLN	P-501

SHEET
152
OF
263

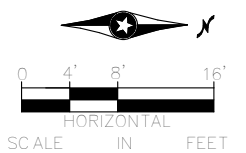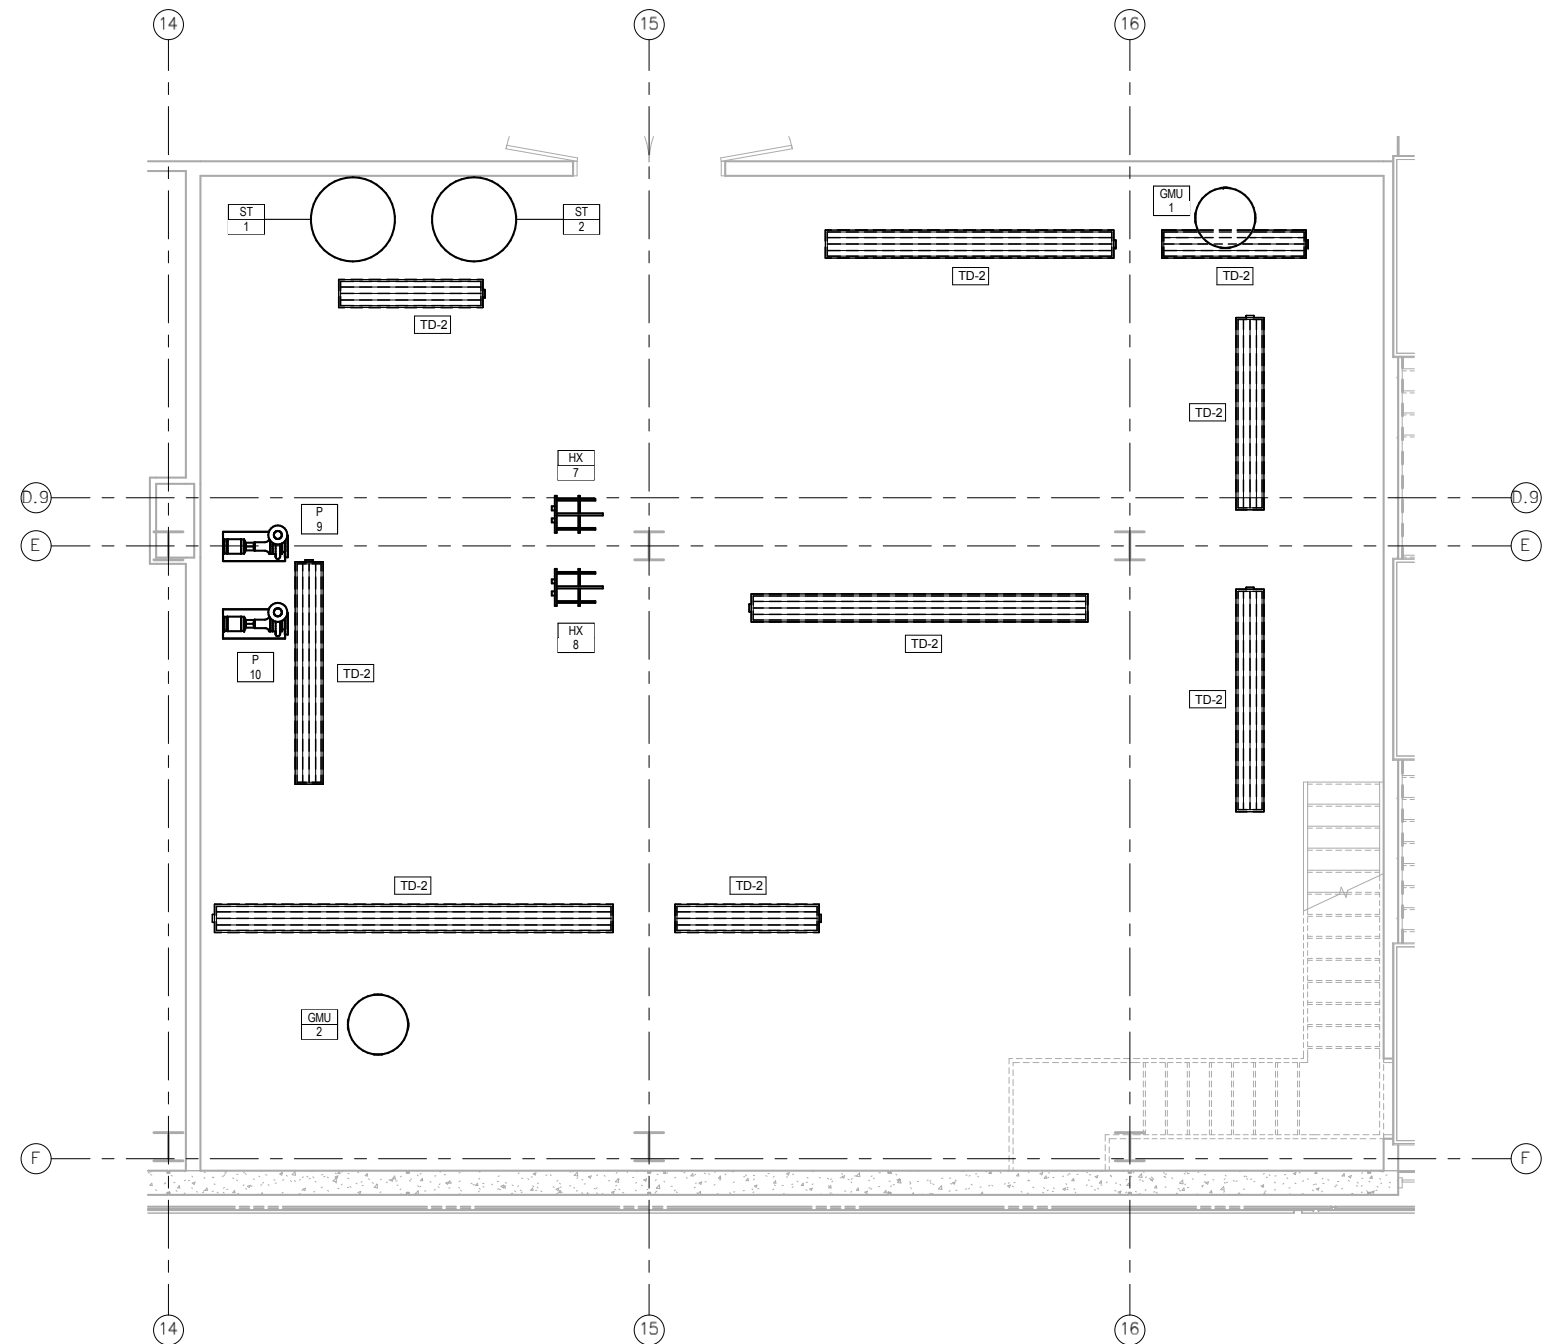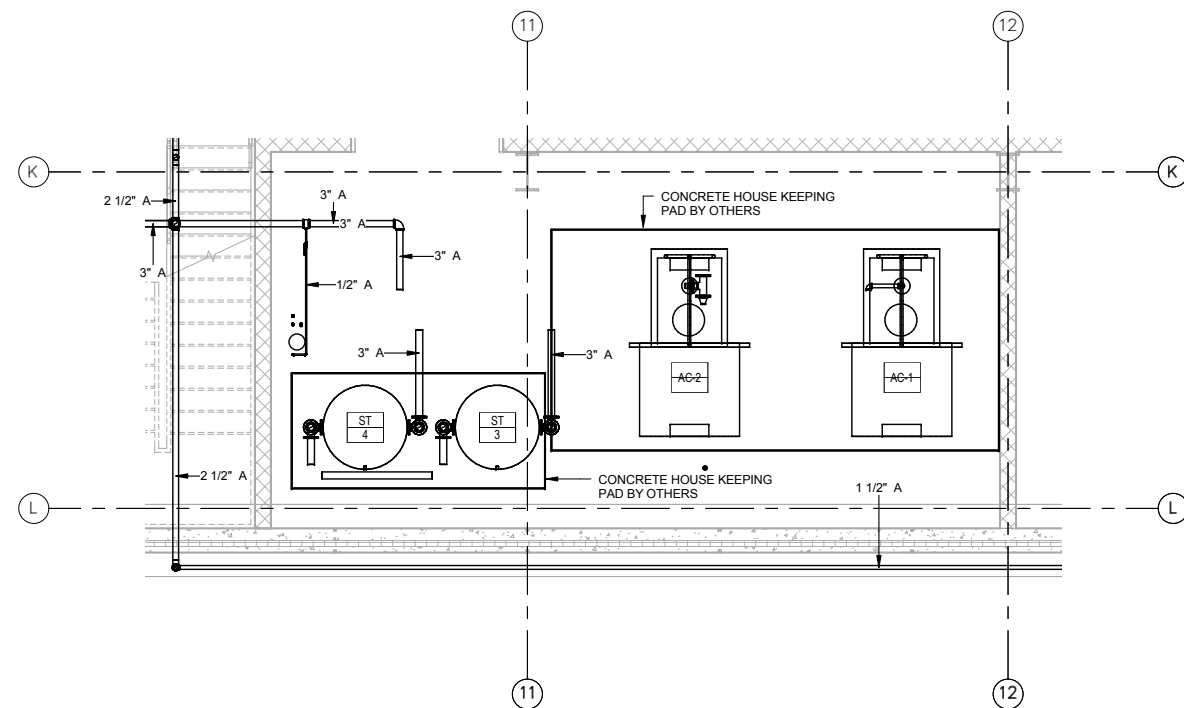[illegible]**AECOM**

LV
ENGINEERING • LLC
CERTIFIED WOMEN'S
BUSINESS ENTERPRISE

60% SUBMISSION - 09/28/15



OPERATIONS & MAINTENANCE FACILITY -V2B	S
PLUMBING	

ENLARGED PLUMBING PLANS 3

DISCIPLINE:

PLUMBING

SHEET NAME:

NAME: **OMF-PLM-PLN**

P-502


SHEET

153

OF

263


9/22/2015 11:24:00 AM C:\Users\stevensj\Documents\OMF_FIREPROTECTION_stevensj.rvt

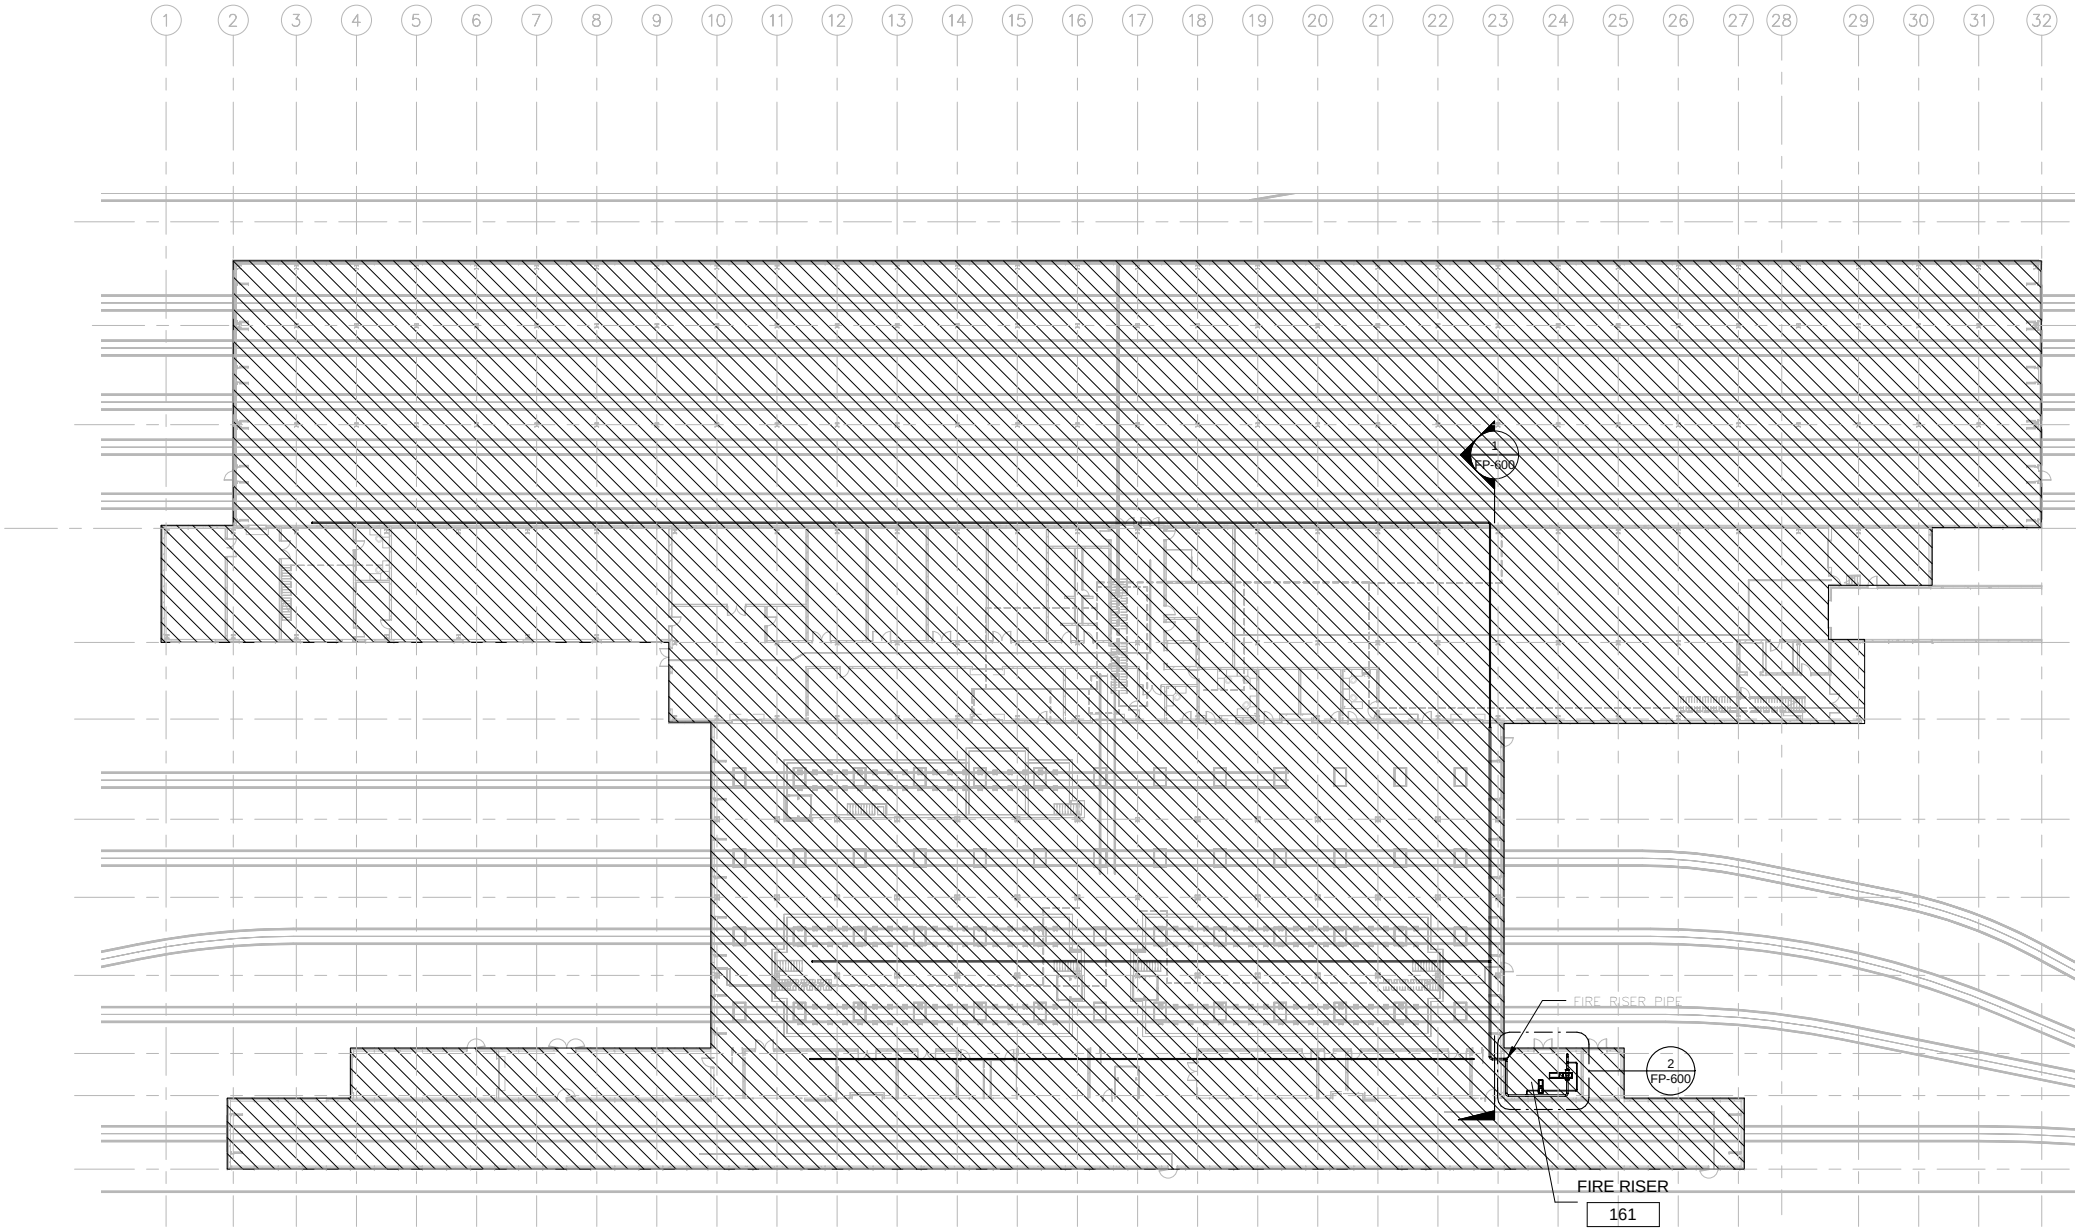


GENERAL NOTES

1. CONTRACTOR SHALL DESIGN/BUILD A COMPLETE SPRINKLER SYSTEM IN ACCORDANCE WITH NFPA 13 AND MINNESOTA BUILDING CODE 2015 WITH ALL REQUIRED FIRE ALARM SYSTEM SUPERVISORY SWITCHES, SENSORS AND FIRE DEPARTMENT CONNECTIONS. THE SYSTEM SHALL PROVIDE COVERAGE FOR THE ENTIRE BUILDING, INCLUDING THE CEILING SPACE AREA, ALL MATERIAL, HANGER COMPONENTS AND INSTALLATION METHODS SHALL BE IN COMPLIANCE WITH NFPA 13. TESTING STATIONS SHALL BE INSTALLED AT THE END OF EACH SPRINKLER RISER, WITH DISCHARGE PIPING INSTALLED THROUGH THE WALLS. THE TEST VALVES SHALL BE INSTALLED AT THE END OF EACH RISER IN THE SUSPENDED CEILING.
2. CONTRACTOR SHALL DETERMINE VOLUME AND PRESSURE OF INCOMING WATER SUPPLY FROM WATER FLOW TEST DATA AND THEN DESIGN THE SYSTEM TO NFPA 13 AND MINNESOTA BUILDING CODE 2015 LIGHT HAZARD AND MODERATE HAZARD REQUIREMENTS.

1 OVERALL LEVEL ONE FIRE PROTECTION PLAN
FP-110 SCALE: 1/32" = 1'-0"

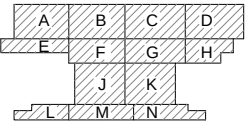

KEY PLAN - SCALE: N.T.S.

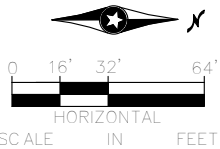

NO	DATE	BY	CHECK	DESIGN	REVISION / SUBMITTAL

AECOM

60% SUBMISSION - 09/28/15



OPERATIONS & MAINTENANCE FACILITY-V2B
FIRE PROTECTION
LEVEL ONE OVERALL PLAN


DISCIPLINE:
FIRE PROTECTION

SHEET NAME:
OMF-FP-PLN

FP-110

SHEET
154
OF
263

9/22/2015 11:24:05 AM C:\Users\stevensj\Documents\OMF_FIREPROTECTION_stevensj.rvt

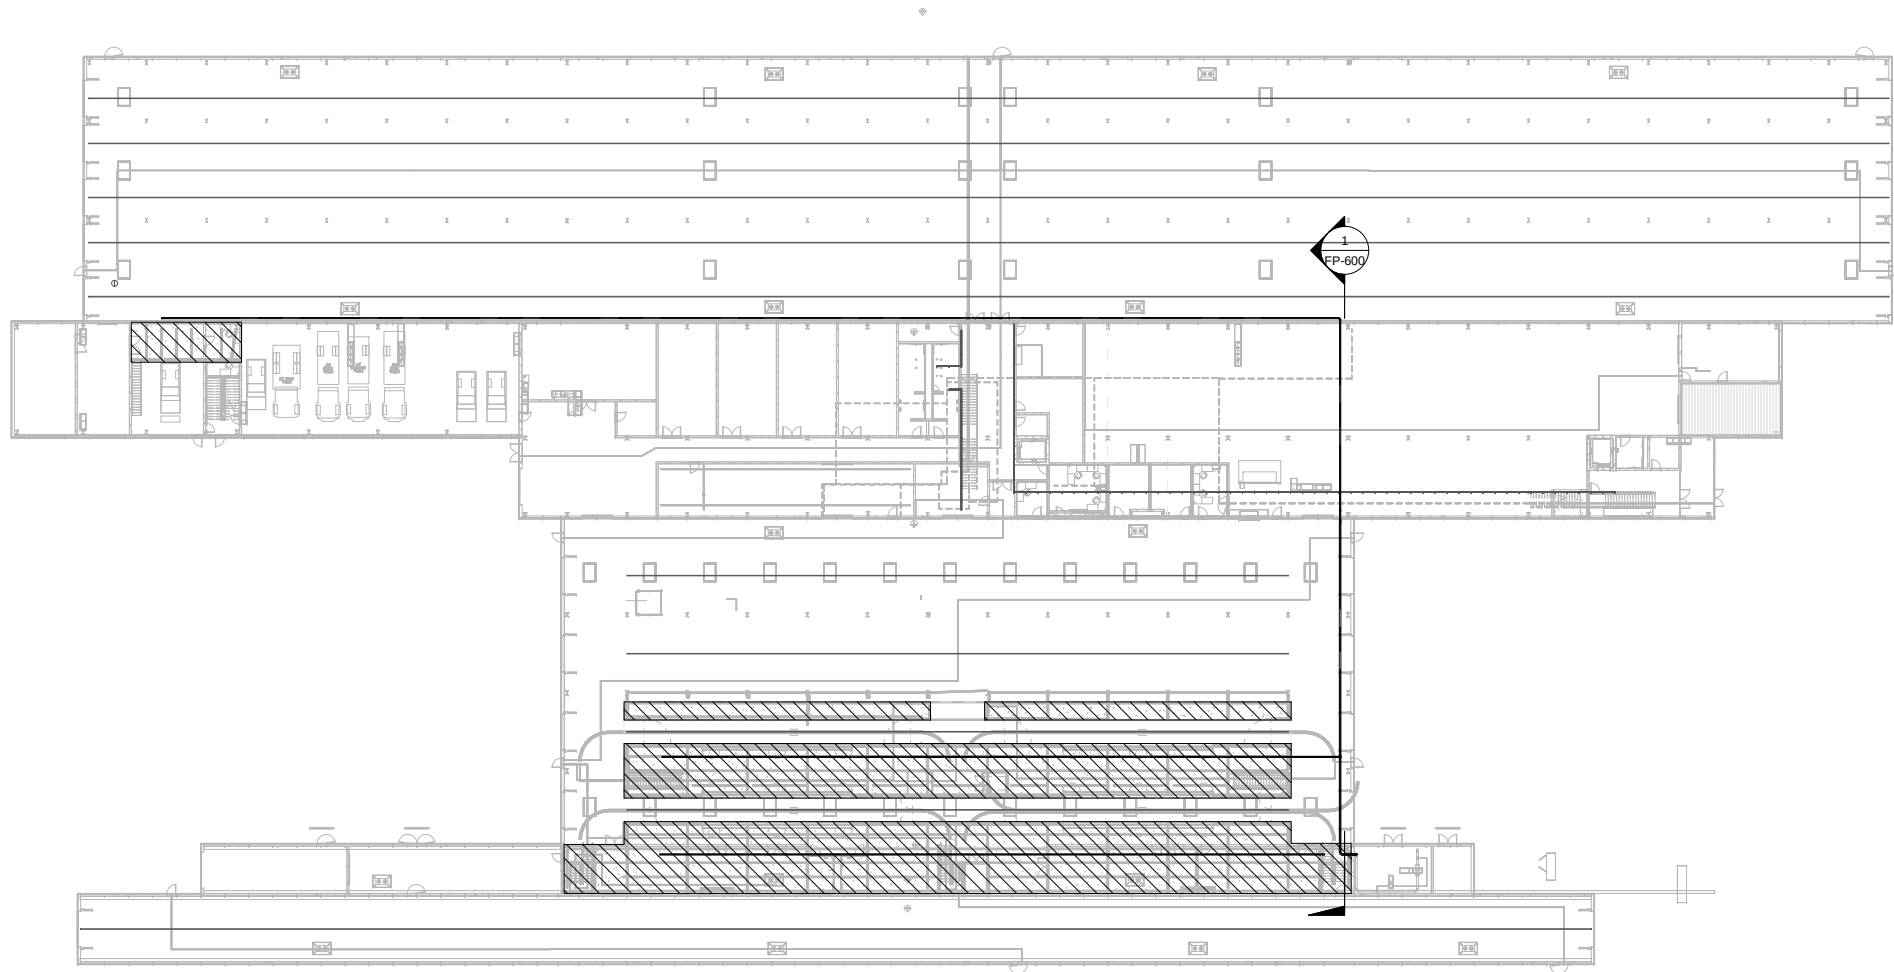


 MEDIUM HAZARD STORAGE


GENERAL NOTES

1. CONTRACTOR SHALL DESIGN/BUILD A COMPLETE SPRINKLER SYSTEM IN ACCORDANCE WITH NFPA 13 AND MINNESOTA BUILDING CODE 2015 WITH ALL REQUIRED FIRE ALARM SYSTEM SUPERVISORY SWITCHES, SENSORS AND FIRE DEPARTMENT CONNECTIONS. THE SYSTEM SHALL PROVIDE COVERAGE FOR THE ENTIRE BUILDING, INCLUDING THE CEILING SPACE AREA, ALL MATERIAL, HANGER COMPONENTS AND INSTALLATION METHODS SHALL BE IN COMPLIANCE WITH NFPA 13. TESTING STATIONS SHALL BE INSTALLED AT THE END OF EACH SPRINKLER RISER, WITH DISCHARGE PIPING INSTALLED THROUGH THE WALLS. THE TEST VALVES SHALL BE INSTALLED AT THE END OF EACH RISER IN THE SUSPENDED CEILING.
2. CONTRACTOR SHALL DETERMINE VOLUME AND PRESSURE OF INCOMING WATER SUPPLY FROM WATER FLOW TEST DATA AND THEN DESIGN THE SYSTEM TO NFPA 13 AND MINNESOTA BUILDING CODE 2015 LIGHT HAZARD AND MODERATE HAZARD REQUIREMENTS.

1 OVERALL MEZZANINE FIRE PROTECTION PLAN
FP-115 SCALE: 1/32" = 1'-0"

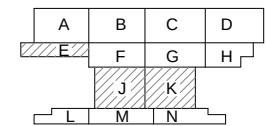

KEY PLAN - SCALE: N.T.S.

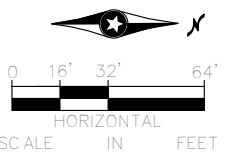

NO	DATE	BY	CHECK	DESIGN	REVISION / SUBMITTAL

AECOM

60% SUBMISSION - 09/28/15




OPERATIONS & MAINTENANCE FACILITY-V2B
FIRE PROTECTION
MEZZANINE LEVEL OVERALL PLAN

DISCIPLINE:
FIRE PROTECTION

SHEET NAME:
OMF-FP-PLN **FP-115**

SHEET
155
OF
263

9/22/2015 11:24:07 AM C:\Users\stevensj\Documents\OMF_FIREPROTECTION_stevensj.rvt

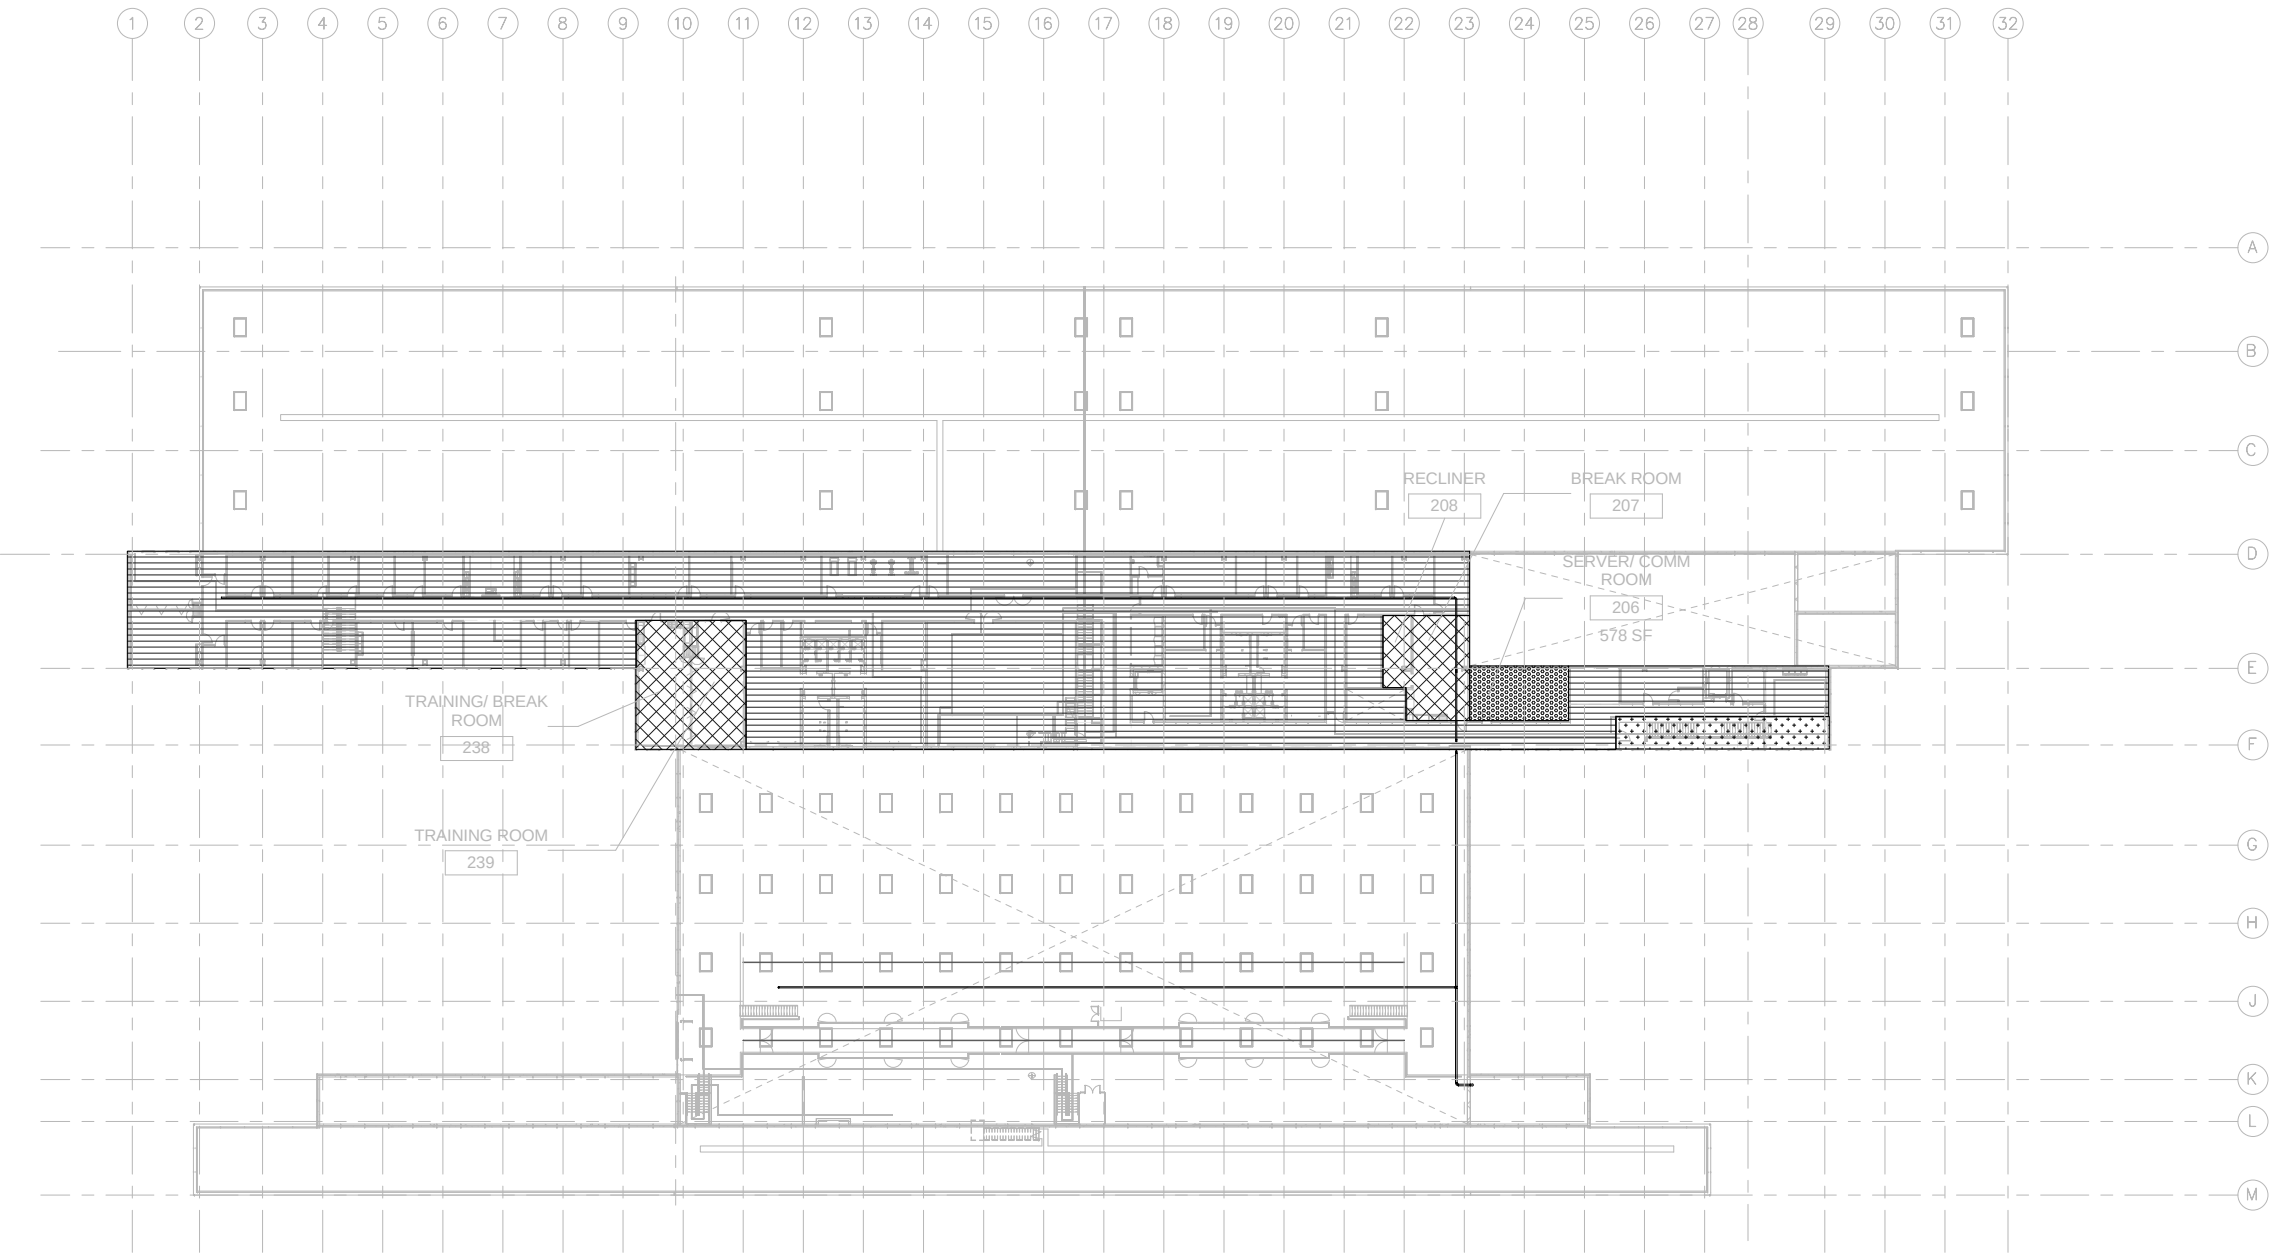


GENERAL NOTES

1. CONTRACTOR SHALL DESIGN/BUILD A COMPLETE SPRINKLER SYSTEM IN ACCORDANCE WITH NFPA 13 AND MINNESOTA BUILDING CODE 2015 WITH ALL REQUIRED FIRE ALARM SYSTEM SUPERVISORY SWITCHES, SENSORS AND FIRE DEPARTMENT CONNECTIONS. THE SYSTEM SHALL PROVIDE COVERAGE FOR THE ENTIRE BUILDING, INCLUDING THE CEILING SPACE AREA, ALL MATERIAL, HANGER COMPONENTS AND INSTALLATION METHODS SHALL BE IN COMPLIANCE WITH NFPA 13. TESTING STATIONS SHALL BE INSTALLED AT THE END OF EACH SPRINKLER RISER, WITH DISCHARGE PIPING INSTALLED THROUGH THE WALLS. THE TEST VALVES SHALL BE INSTALLED AT THE END OF EACH RISER IN THE SUSPENDED CEILING.
2. CONTRACTOR SHALL DETERMINE VOLUME AND PRESSURE OF INCOMING WATER SUPPLY FROM WATER FLOW TEST DATA AND THEN DESIGN THE SYSTEM TO NFPA 13 AND MINNESOTA BUILDING CODE 2015 LIGHT HAZARD AND MODERATE HAZARD REQUIREMENTS.

-  LIGHT HAZARD
-  MODERATE HAZARD STORAGE
-  LIGHT HAZARD DATA CENTER, HYBRID SYSTEM
-  SPECIAL SPACE LIGHT HAZARD

1 LEVEL TWO OVERALL FIRE PROTECTION PLAN
FP-120 SCALE: 1/32" = 1'-0"

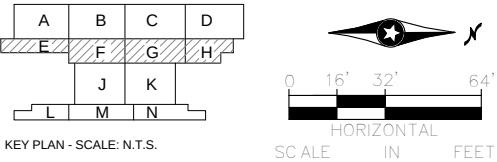

NO	DATE	BY	CHECK	DESIGN	REVISION / SUBMITTAL


60% SUBMISSION - 09/28/15




OPERATIONS & MAINTENANCE FACILITY-V2B
FIRE PROTECTION
LEVEL TWO OVERALL PLAN


DISCIPLINE:
FIRE PROTECTION

SHEET NAME:
OMF-FP-PLN

FP-120

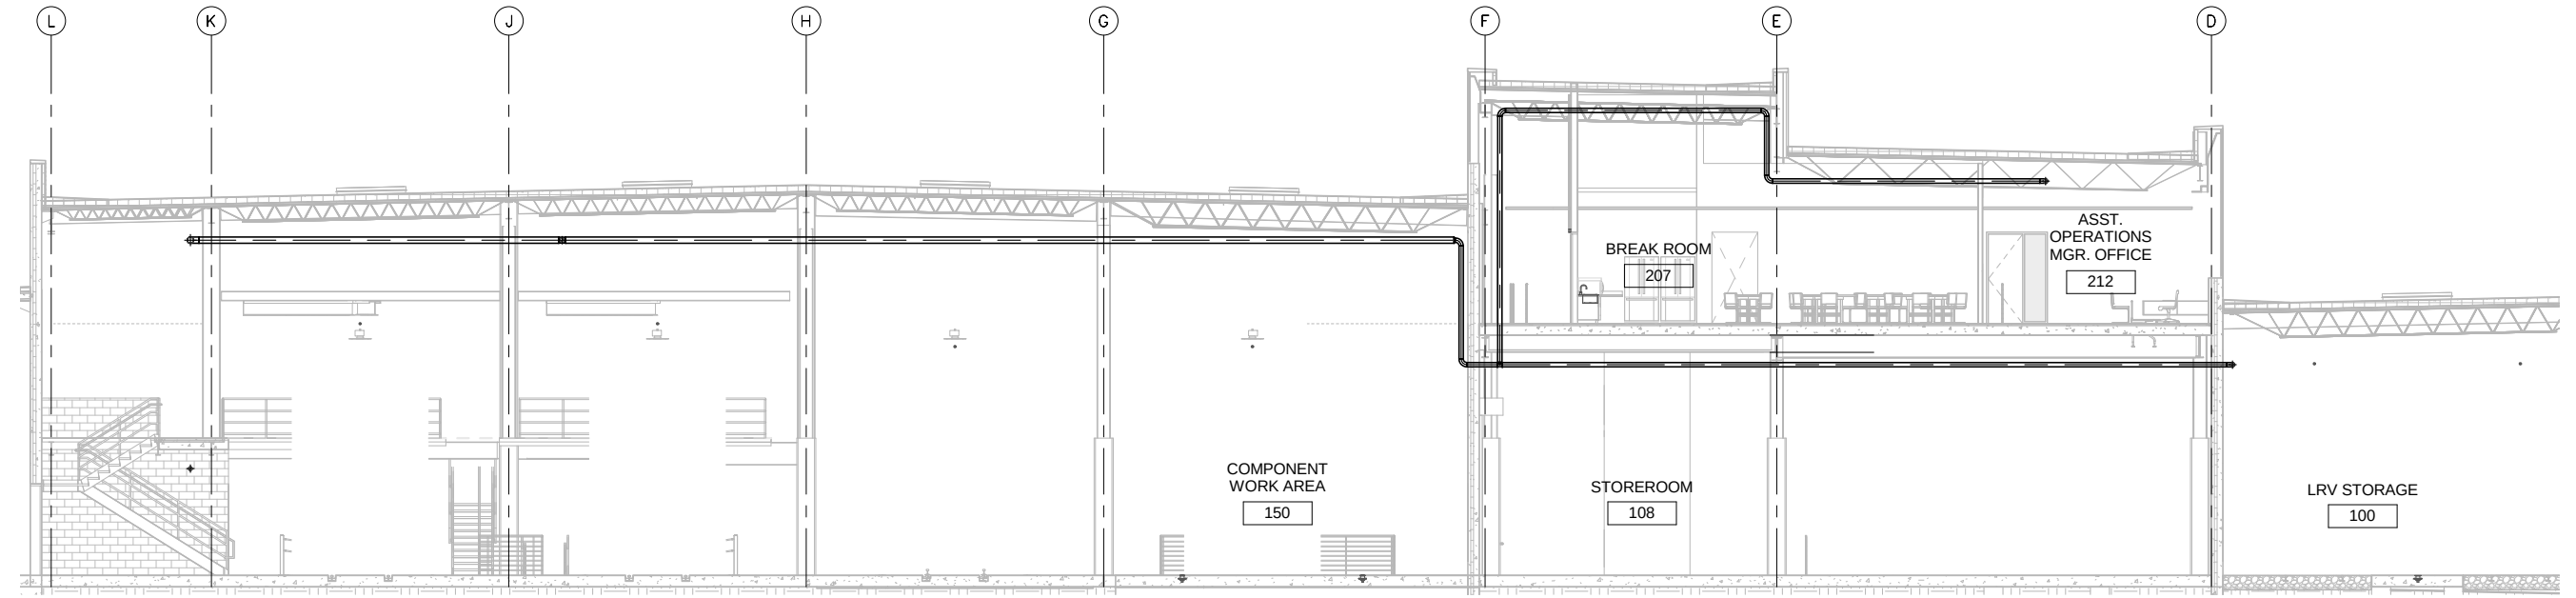

1 FIRE MAIN SECTION
 SCALE: 1/8" = 1'-0"
 REF. SHEET: FP-110 / REF. DETAIL: 1

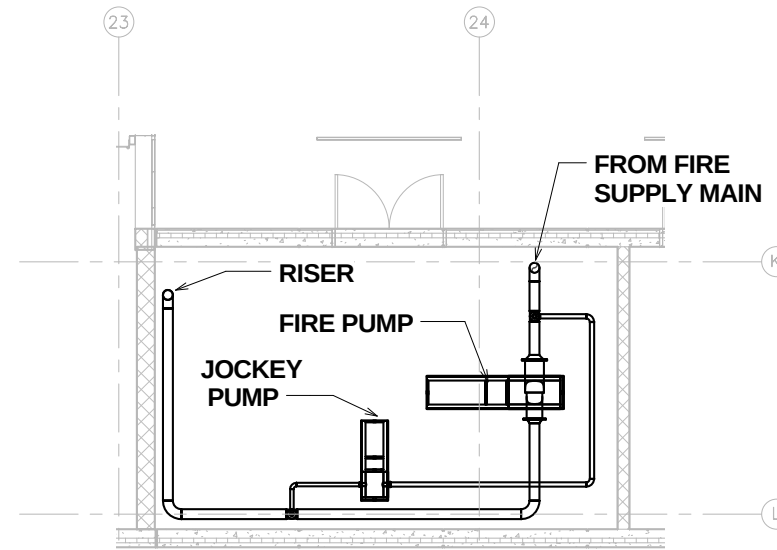

2 FIRE PROTECTION ENLARGED PLAN
 SCALE: 3/16" = 1'-0"
 REF. SHEET: FP-110 / REF. DETAIL: 1



9/22/2015 11:24:09 AM C:\Users\stevensj\Documents\OMF_FIREPROTECTION_stevensj.rvt

NO	DATE	BY	CHECK	DESIGN	REVISION / SUBMITTAL


		OPERATIONS & MAINTENANCE FACILITY-V2B FIRE PROTECTION SECTIONS AND DETAILS		SHEET 157 OF 263
		60% SUBMISSION - 09/28/15		DISCIPLINE: FIRE PROTECTION
		SHEET NAME: OMF-FP-SCT FP-600		

9/22/2015 10:08:27 AM C:\Users\IV-Bege\B\Documents\OMF_ELEC_V-Bege\JB.rvt

ONE LINE OR CONTROL DIAGRAM						PLAN	DESCRIPTION	ONE LINE OR CONTROL DIAGRAM						PLAN	DESCRIPTION	ONE LINE OR CONTROL DIAGRAM						DESCRIPTION	
						CB	LOW VOLTAGE AIR OR MOLDED CASE CIRCUIT BREAKER, 3 POLE UNLESS OTHERWISE NOTED.							—	CONDUCTORS ELECTRICALLY CONNECTED							DAMP	INDICATES THAT ALL ELECTRICAL EQUIPMENT AND MATERIALS INSTALLED WITHIN THE ROOM OR AREA IN WHICH THIS NOTATION APPEARS SHALL BE OF NEMA 12 CONSTRUCTION (OR GASKETED AND SUITABLE FOR USE IN A DAMP LOCATION WHERE NEMA STANDARDS DO NOT APPLY) UNLESS OTHERWISE NOTED.
							COMBINATION MOTOR CIRCUIT PROTECTOR AND MAGNETIC MOTOR STARTER, FULL VOLTAGE NON-REVERSING UNLESS OTHERWISE NOTED: * FVR - FULL VOLTAGE REVERSING RVNR - REDUCED VOLTAGE NON-REVERSING 2S1W - TWO SPEED, ONE WINDING 2S2W - TWO SPEED, TWO WINDING SS - SOLID STATE STARTER							—	PILOT LIGHT, COLOR AS NOTED R - RED G - GREEN B - BLUE W - WHITE A - AMBER							WET	INDICATES THAT ALL ELECTRICAL EQUIPMENT AND MATERIALS INSTALLED WITHIN THE ROOM OR AREA IN WHICH THIS NOTATION APPEARS SHALL BE OF NEMA 4 CONSTRUCTION (OR GASKETED AND SUITABLE FOR USE IN A WET LOCATION WHERE NEMA STANDARDS DO NOT APPLY) UNLESS OTHERWISE NOTED.
							NON-FUSIBLE DISCONNECT SWITCH, 600 VOLT, 3 POLE AMPERE RATING NOTED IF OTHER THAN 30A							—	PILOT LIGHT, PUSH-TO-TEST TYPE, COLOR AS NOTED ABOVE.							CORROSIVE	INDICATES THAT ALL ELECTRICAL EQUIPMENT AND MATERIALS INSTALLED WITHIN THE ROOM OR AREA IN WHICH THIS NOTATION APPEARS SHALL BE OF NEMA 4X CONSTRUCTION (OR CORROSION RESISTANT CONSTRUCTION SUITABLE FOR USE IN A CORROSIVE LOCATION WHERE NEMA STANDARDS DO NOT APPLY) UNLESS OTHERWISE NOTED.
							FUSIBLE DISCONNECT SWITCH, 600 VOLT, 3 POLE, AMPERE RATING AND FUSE SIZE AS NOTED AMPERE RATING NOTED IF OTHER THAN 30A FUSE RATING EXAMPLE 15							—	GROUND OR GROUND ROD							—	FUSE, AMPERE RATING AS NOTED
							MANUAL MOTOR STARTER WITH THERMAL OVERLOAD HEATER "P" INDICATES WITH PILOT LIGHT "2" INDICATES TWO POLE							—	CONTACT, NORMALLY OPEN (NO)							—	CONTACT, NORMALLY CLOSED (NC)
480V TO 120/208V 30 KVA K-*							TRANSFORMER, RATINGS AND CONNECTIONS AS NOTED. UNLESS OTHERWISE NOTED ON THE SINGLE LINE DIAGRAMS ALL DRY TYPE TRANSFORMERS SERVICING ADMINISTRATIVE AND LABORATORY SPACES SHALL HAVE A K FACTOR OF 13. ALL OTHER DRY TYPE TRANSFORMERS SHALL HAVE A K-4 RATING. ISOLATION TRANSFORMERS SHALL HAVE A K-20 RATING							—	CONTROL RELAY COIL, NUMBER AS INDICATED							—	TIME DELAY RELAY RANGE AS NOTED, SETPOINT AS NOTED TDE-TIME DELAY AFTER ENERGIZATION-ON DELAY TDD-TIME DELAY AFTER DE-ENERGIZATION-OFF DELAY
A TO 5							CURRENT TRANSFORMER * QUANTITY A = PRIMARY AMPERES							NOTC-NORMALLY OPEN, TIMED CLOSING WHEN ENERGIZED							NCTO-NORMALLY CLOSED, TIMED OPENING WHEN ENERGIZED		
V TO 120							POTENTIAL TRANSFORMER * QUANTITY V = PRIMARY VOLTAGE							NOTO-NORMALLY OPEN, TIMED OPENING WHEN DE-ENERGIZED							NCTO-NORMALLY CLOSED, TIMED CLOSING WHEN DE-ENERGIZED		
						VFD	VARIABLE FREQUENCY DRIVE								TEMPERATURE SWITCH OR THERMOSTAT							NORMALLY OPEN, CLOSING ON RISING TEMPERATURE	
100A MTS							MANUAL TRANSFER SWITCH NO.1 (MTS-1) "N" INDICATES NORMAL SOURCE "S" INDICATES STANDBY SOURCE 100A INDICATES CONTINUOUS CURRENT RATING								NORMALLY OPEN, CLOSING ON DROPPING TEMPERATURE							NORMALLY OPEN, CLOSING ON RISING TEMPERATURE	
							UNIT HEATER - ELECTRIC HEATING COIL AND FAN								NORMALLY CLOSED, OPENS ON RISING TEMPERATURE							NORMALLY CLOSED, OPENS ON DROPPING TEMPERATURE	
							MOTOR, NUMERAL INDICATES HORSEPOWER							—	SPECIAL CAPACITOR * SC - SURGE CAPACITOR PF - POWER FACTOR CORRECTION CAPACITOR							INDICATES LIMITS OF EQUIPMENT OR WIRING ENCLOSURE	
						—	PUSHBUTTON, MOMENTARY CONTACT, SPRING RETURN, NORMALLY CLOSED								FIELD INSTRUMENT, TAG NO. AS INDICATED LS - LEVEL SWITCH ZS - LIMIT SWITCH SV - SOLENOID VALVE MS - MOTION SENSOR							—	
						—	CONDUCTORS OR CONDUITS CROSSING PATHS BUT NOT CONNECTED							—	PUSHBUTTON STATION								

NO	DATE	BY	CHECK	DESIGN	REVISION / SUBMITTAL	 60% SUBMISSION - 9/28/15		OPERATIONS & MAINTENANCE FACILITY - V2B			SHEET
ELECTRICAL			159								
SYMBOLS 1 OF 2				OF							
DISCIPLINE: ELECTRICAL			SHEET NAME: OMF-ELE-GEN	E002	263						

- GENERAL NOTES:
1. BRANCH CIRCUIT WIRING FOR PARKING LOT LUMINAIRES SHALL BE #8. WIRING SHALL BE RUN IN 1-1/2" PVC CONDUIT.
 2. BRANCH CIRCUIT WIRING FOR OCS POLE TOP LUMINAIRES SHALL BE #6, 1/C 2.4KV MV-90 CABLE. WIRING SHALL BE RUN IN 2" PVC CONDUIT.
 3. ALL SITE LIGHTING BRANCH CIRCUITS SHALL BE ROUTED TO THE LIGHTING CONTROL RELAY CABINET IN ROOM 148.

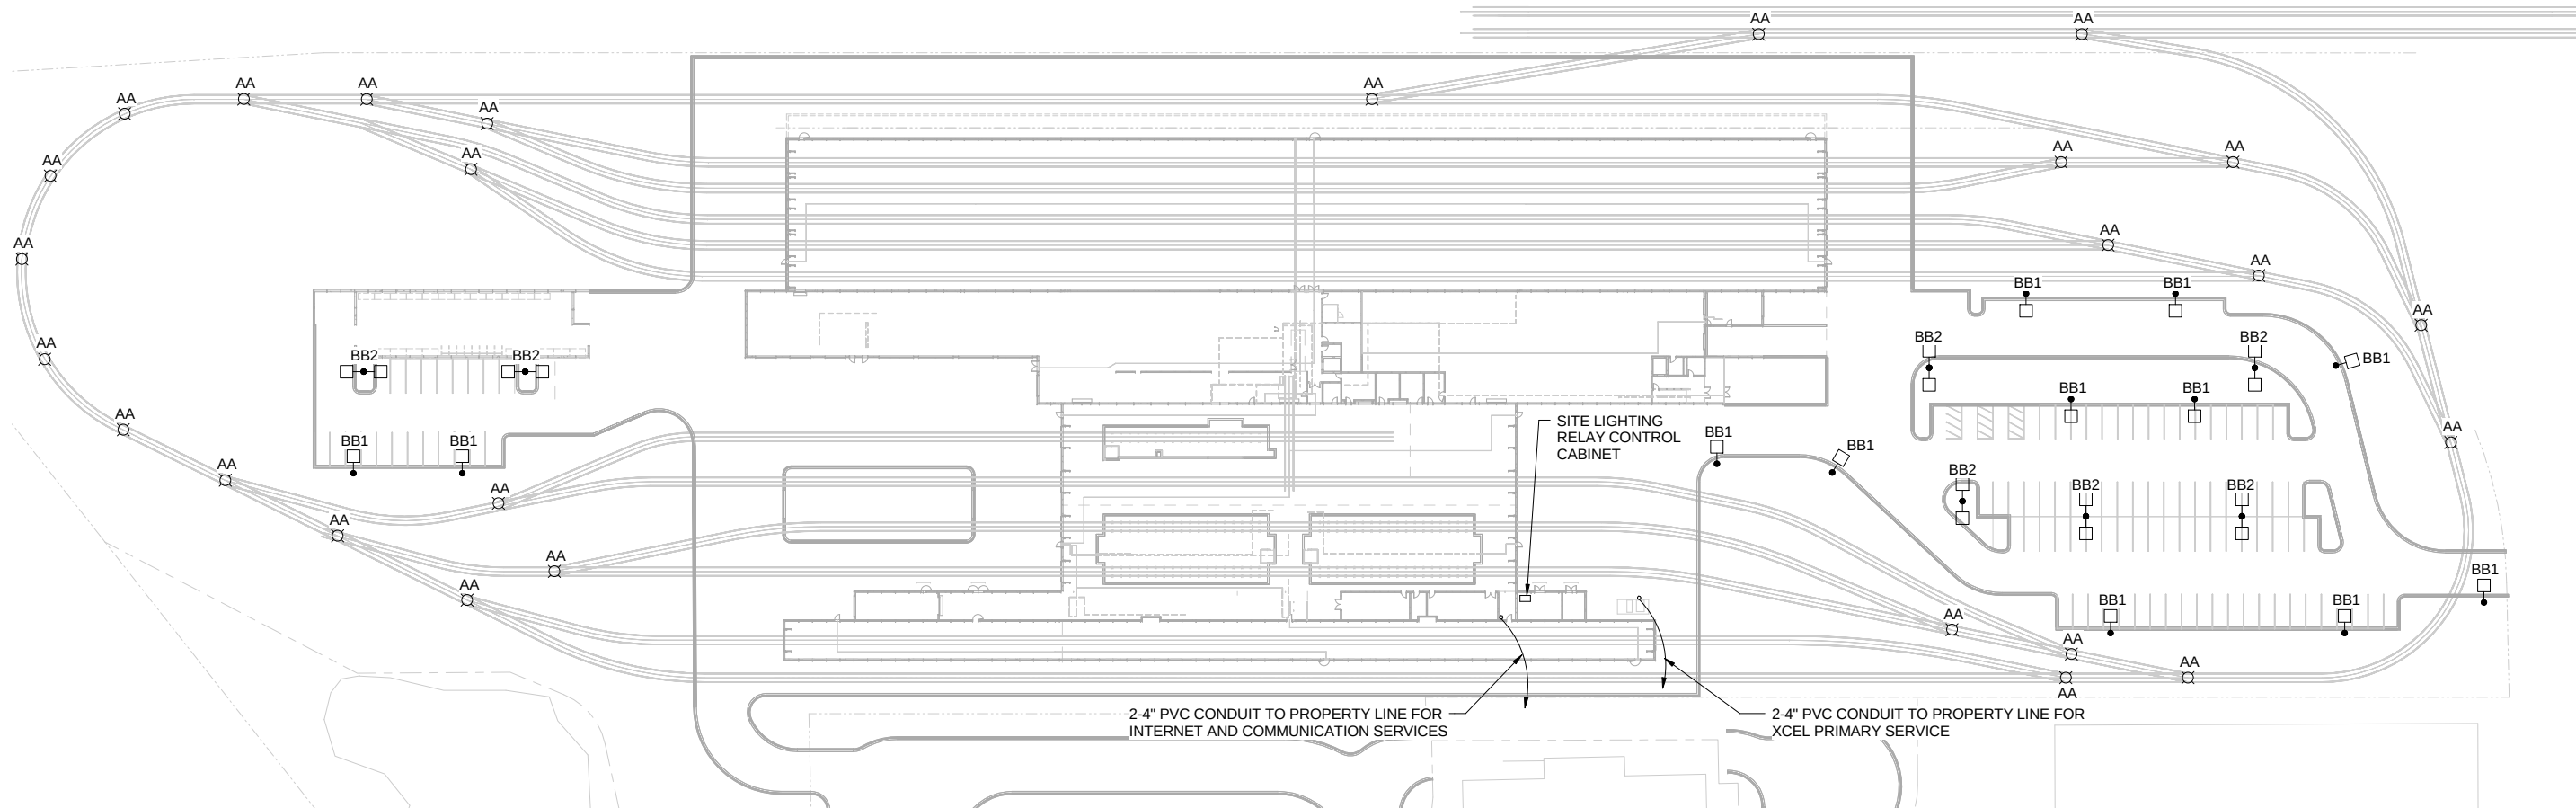

1 SITE LIGHTING
E051 SCALE: 1" = 50'-0"

NO	DATE	BY	CHECK	DESIGN	REVISION / SUBMITTAL

AECOM

MP Consultants
CONSULTING ENGINEERING
MINNEAPOLIS, MINNESOTA

60% SUBMISSION - 9/28/15

**METROPOLITAN COUNCIL**

**SOUTHWEST**

OPERATIONS & MAINTENANCE FACILITY - V2B
ELECTRICAL
SITE LIGHTING PLAN

DISCIPLINE: **ELECTRICAL**


SHEET NAME: **OMF-ELE-SIT**

E051


SHEET
161
OF
263

9/22/2015 10:08:35 AM C:\Users\jv-Beggs\Documents\OMF_ELEC_V-Beggs\B.rvt

- GENERAL NOTES:
1. ALL GENERAL PURPOSE RECEPTACLES AND RECEPTACLE REELS WILL BE FED FROM PANEL ELP-117 UNLESS NOTED OTHERWISE.
 2. SEE INDUSTRIAL EQUIPMENT SCHEDULE ON SHEET E-805 FOR DISCONNECT SWITCHES, SIZES AND WIRING REQUIREMENTS.
 3. SEE MECHANICAL PLAN FOR MOTORS AND LOCATIONS. PROVIDE FEEDERS AND DISCONNECT SWITCH TO EACH MOTOR.

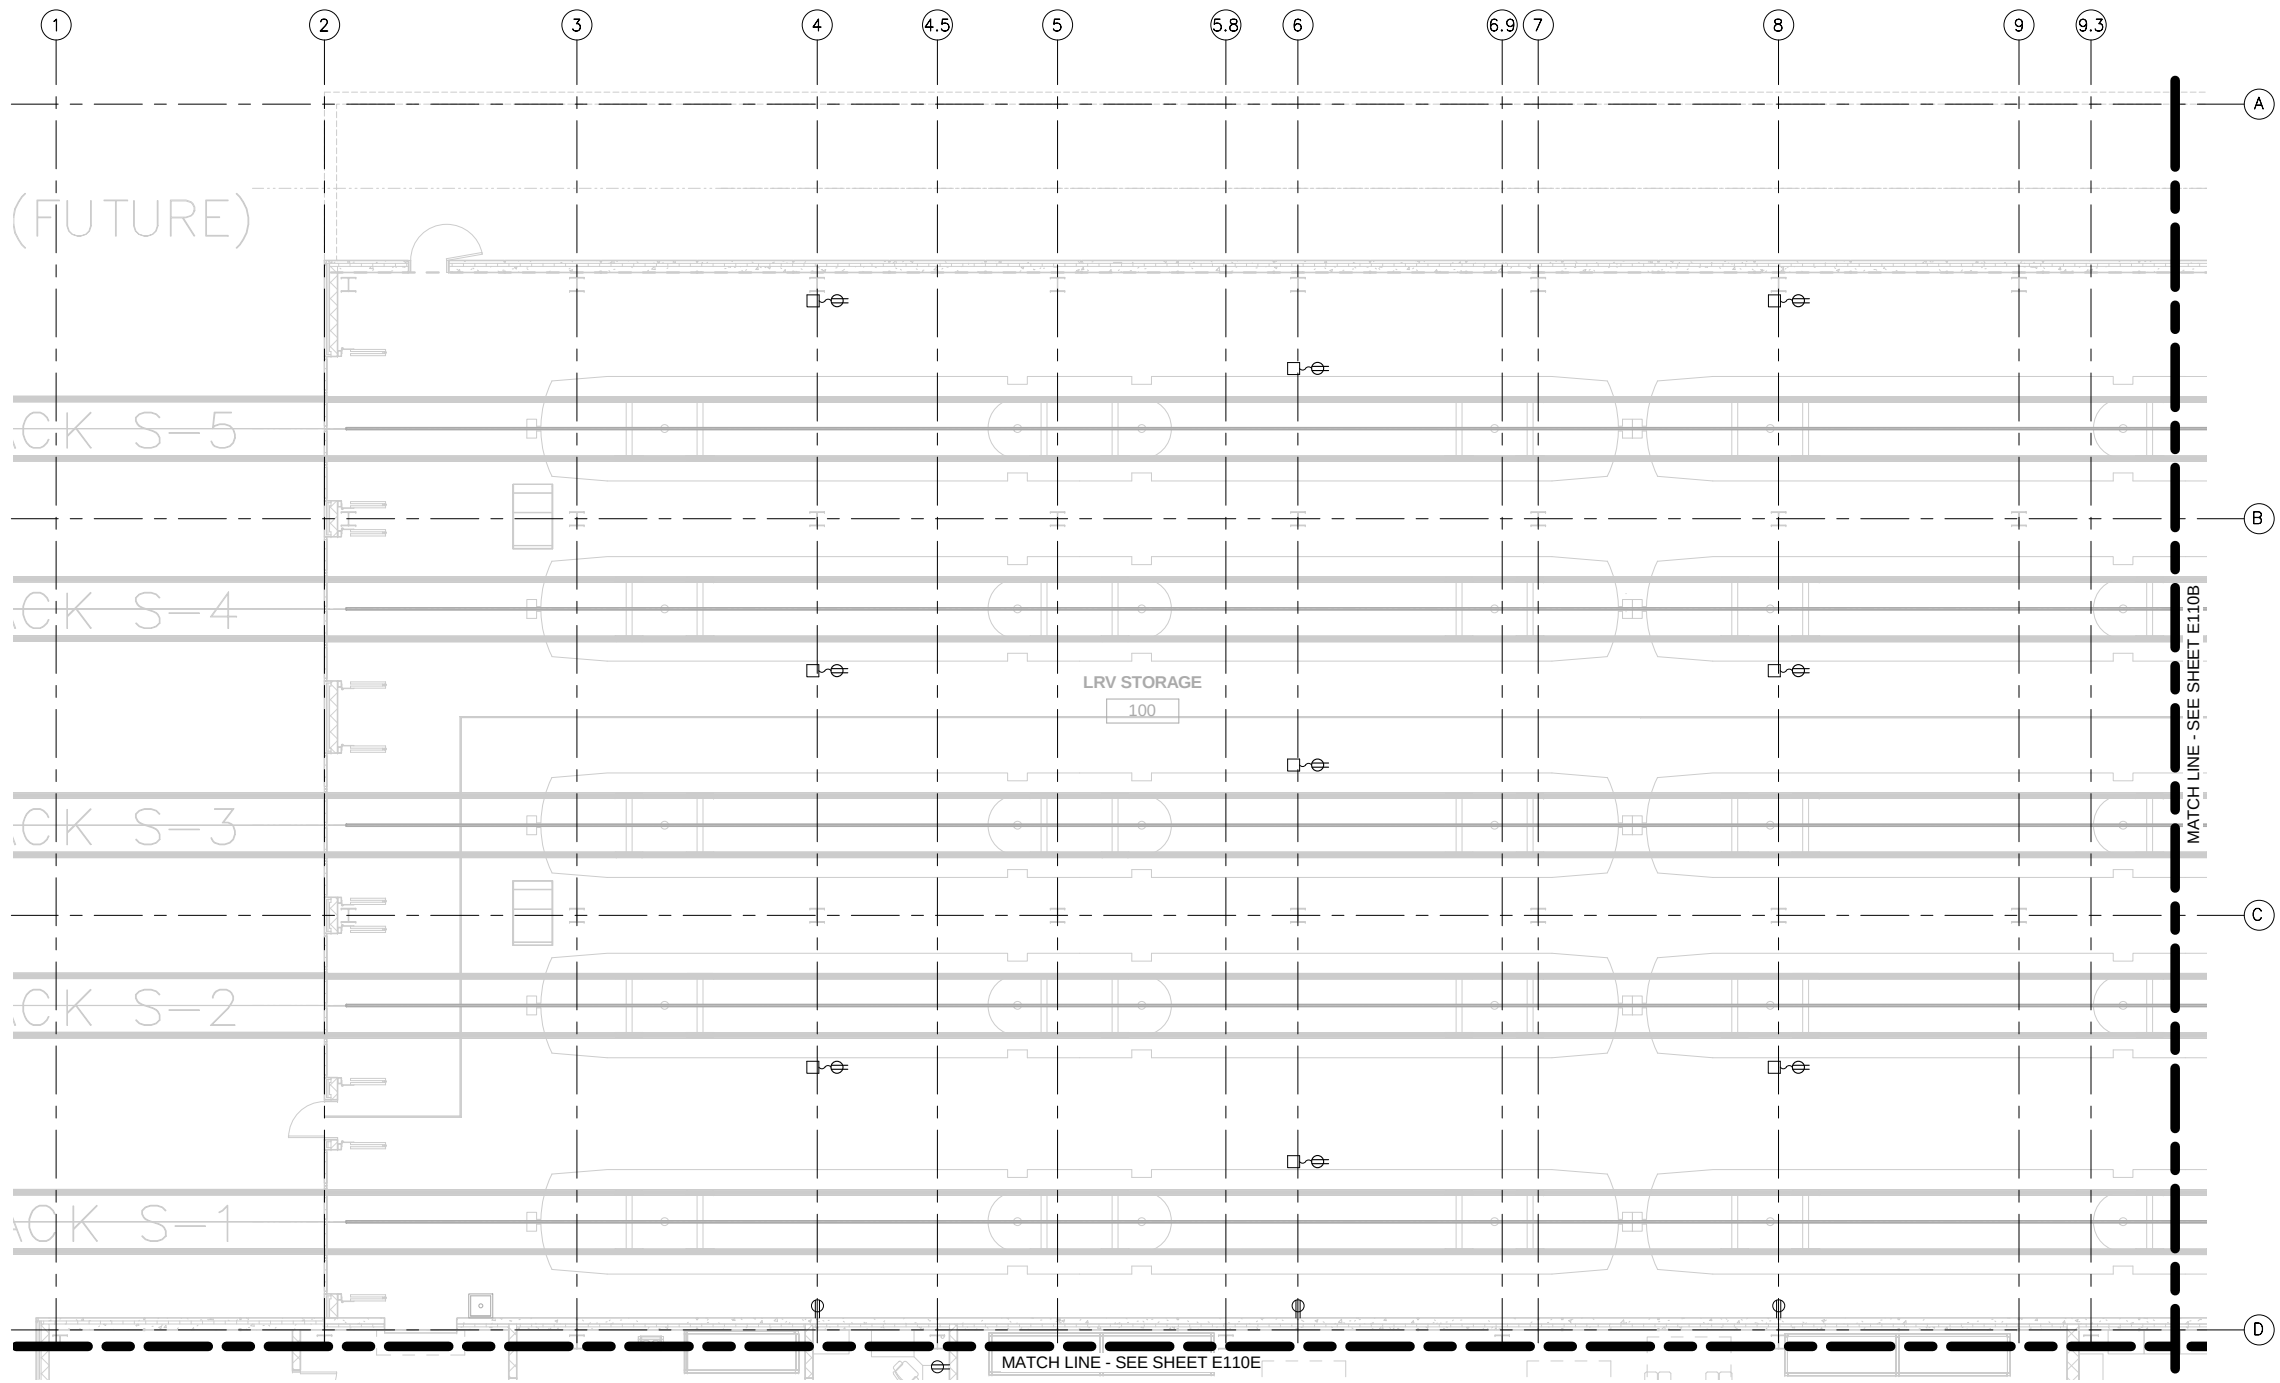

1 POWER PLAN - AREA A
E110A SCALE: 1/8" = 1'-0"

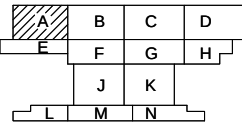

NO	DATE	BY	CHECK	DESIGN	REVISION / SUBMITTAL

AECOM

MP Consultants
CONSULTING ENGINEERING
MINNEAPOLIS • MINNESOTA

SOUTHWEST

60% SUBMISSION - 9/28/15

OPERATIONS & MAINTENANCE FACILITY - V2B
ELECTRICAL
POWER - LEVEL ONE - AREA A

DISCIPLINE: ELECTRICAL

SHEET NAME: OMF-ELE-PLN

E110A

SHEET 162 OF 263

1. ALL GENERAL PURPOSE RECEPTACLES AND RECEPTACLE REELS WILL BE FED FROM PANEL ELP-117 UNLESS NOTED OTHERWISE.
2. SEE INDUSTRIAL EQUIPMENT SCHEDULE ON SHEET E-805 FOR DISCONNECT SWITCHES, SIZES AND WIRING REQUIREMENTS.
3. SEE MECHANICAL PLAN FOR MOTORS AND LOCATIONS. PROVIDE FEEDERS AND DISCONNECT SWITCH TO EACH MOTOR.




SCALE IN FEET

[illegible]

DISCIPLINE:	SHEET NAME:	
ELECTRICAL	OMF-ELE-PLN	E110B


163
OF
263

9/22/2015 10:08:39 AM C:\Users\jv-Begaj\Documents\OMF_ELEC_V-BegajB.rvt

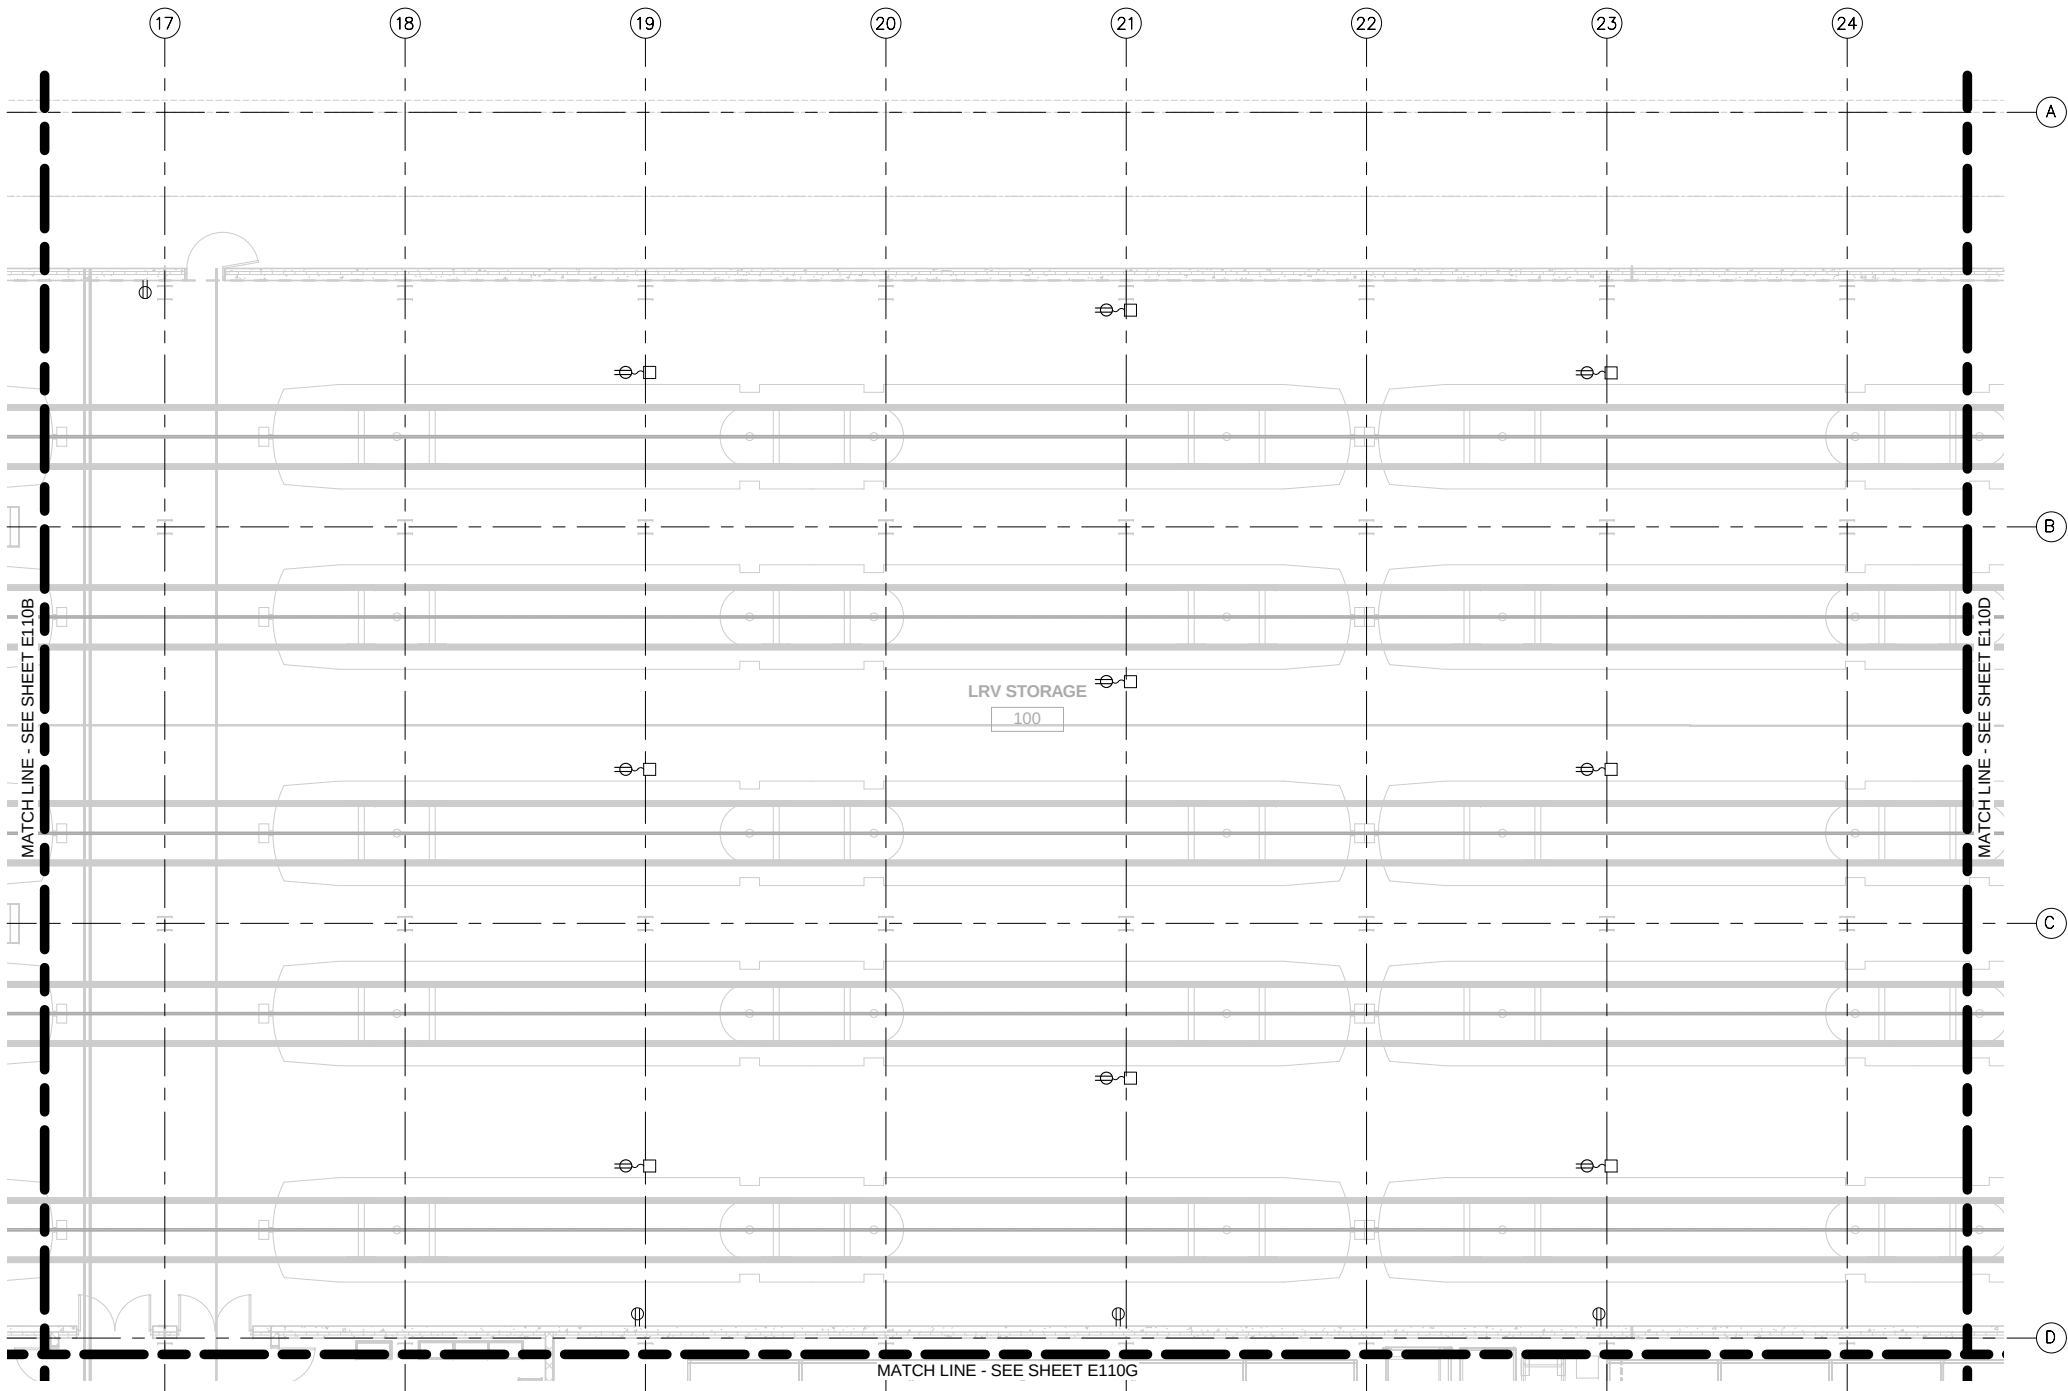

- GENERAL NOTES:
1. ALL GENERAL PURPOSE RECEPTACLES AND RECEPTACLE REELS WILL BE FED FROM PANEL ELP-126 UNLESS NOTED OTHERWISE.
 2. SEE EQUIPMENT SCHEDULE ON SHEET E-805 FOR DISCONNECT SWITCHES, SIZES AND WIRING REQUIREMENTS.
 3. SEE MECHANICAL PLAN FOR MOTORS AND LOCATIONS. PROVIDE FEEDERS AND DISCONNECT SWITCH TO EACH MOTOR

1 POWER PLAN - AREA C
E110C SCALE: 1/8" = 1'-0"

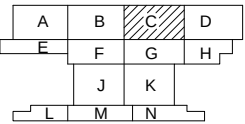

NO	DATE	BY	CHECK	DESIGN	REVISION / SUBMITTAL

AECOM

MP Consultants
CONSULTING ENGINEERING
MINNEAPOLIS, MINNESOTA

60% SUBMISSION - 9/28/15

**METROPOLITAN
COUNCIL**

**SOUTHWEST**

OPERATIONS & MAINTENANCE FACILITY - V2B
ELECTRICAL
POWER - LEVEL ONE - AREA C

DISCIPLINE: ELECTRICAL

SHEET NAME: OMF-ELE-PLN

E110C

SHEET
164
OF
263

1. ALL GENERAL PURPOSE RECEPTACLES AND RECEPTACLE REELS WILL BE FED FROM PANEL ELP-126 UNLESS NOTED OTHERWISE.
2. SEE EQUIPMENT SCHEDULE ON SHEET E-805 FOR DISCONNECT SWITCHES, SIZES AND WIRING REQUIREMENTS.
3. SEE MECHANICAL PLAN FOR MOTORS AND LOCATIONS. PROVIDE FEEDERS AND DISCONNECT SWITCH TO EACH MOTOR



SCALE IN FEET

[illegible]

METROPOLITAN COUNCIL

SOUTHWEST


OPERATIONS & MAINTENANCE FACILITY - V2B^S
ELECTRICAL
POWER - LEVEL ONE - AREA D

E110D


165
OF
263

9/22/2015 10:08:45 AM C:\Users\VBegaj\Documents\OMF_ELEC_V-BegajB.rvt

- GENERAL NOTES:
1. ALL GENERAL PURPOSE RECEPTACLES AND RECEPTACLE REELS WILL BE FED FROM PANEL ELP-117 UNLESS NOTED OTHERWISE.
 2. SEE INDUSTRIAL EQUIPMENT SCHEDULE ON SHEET E-805 FOR DISCONNECT SWITCHES, SIZES AND WIRING REQUIREMENTS.
 3. SEE MECHANICAL PLAN FOR MOTORS AND LOCATIONS. PROVIDE FEEDERS AND DISCONNECT SWITCH TO EACH MOTOR.

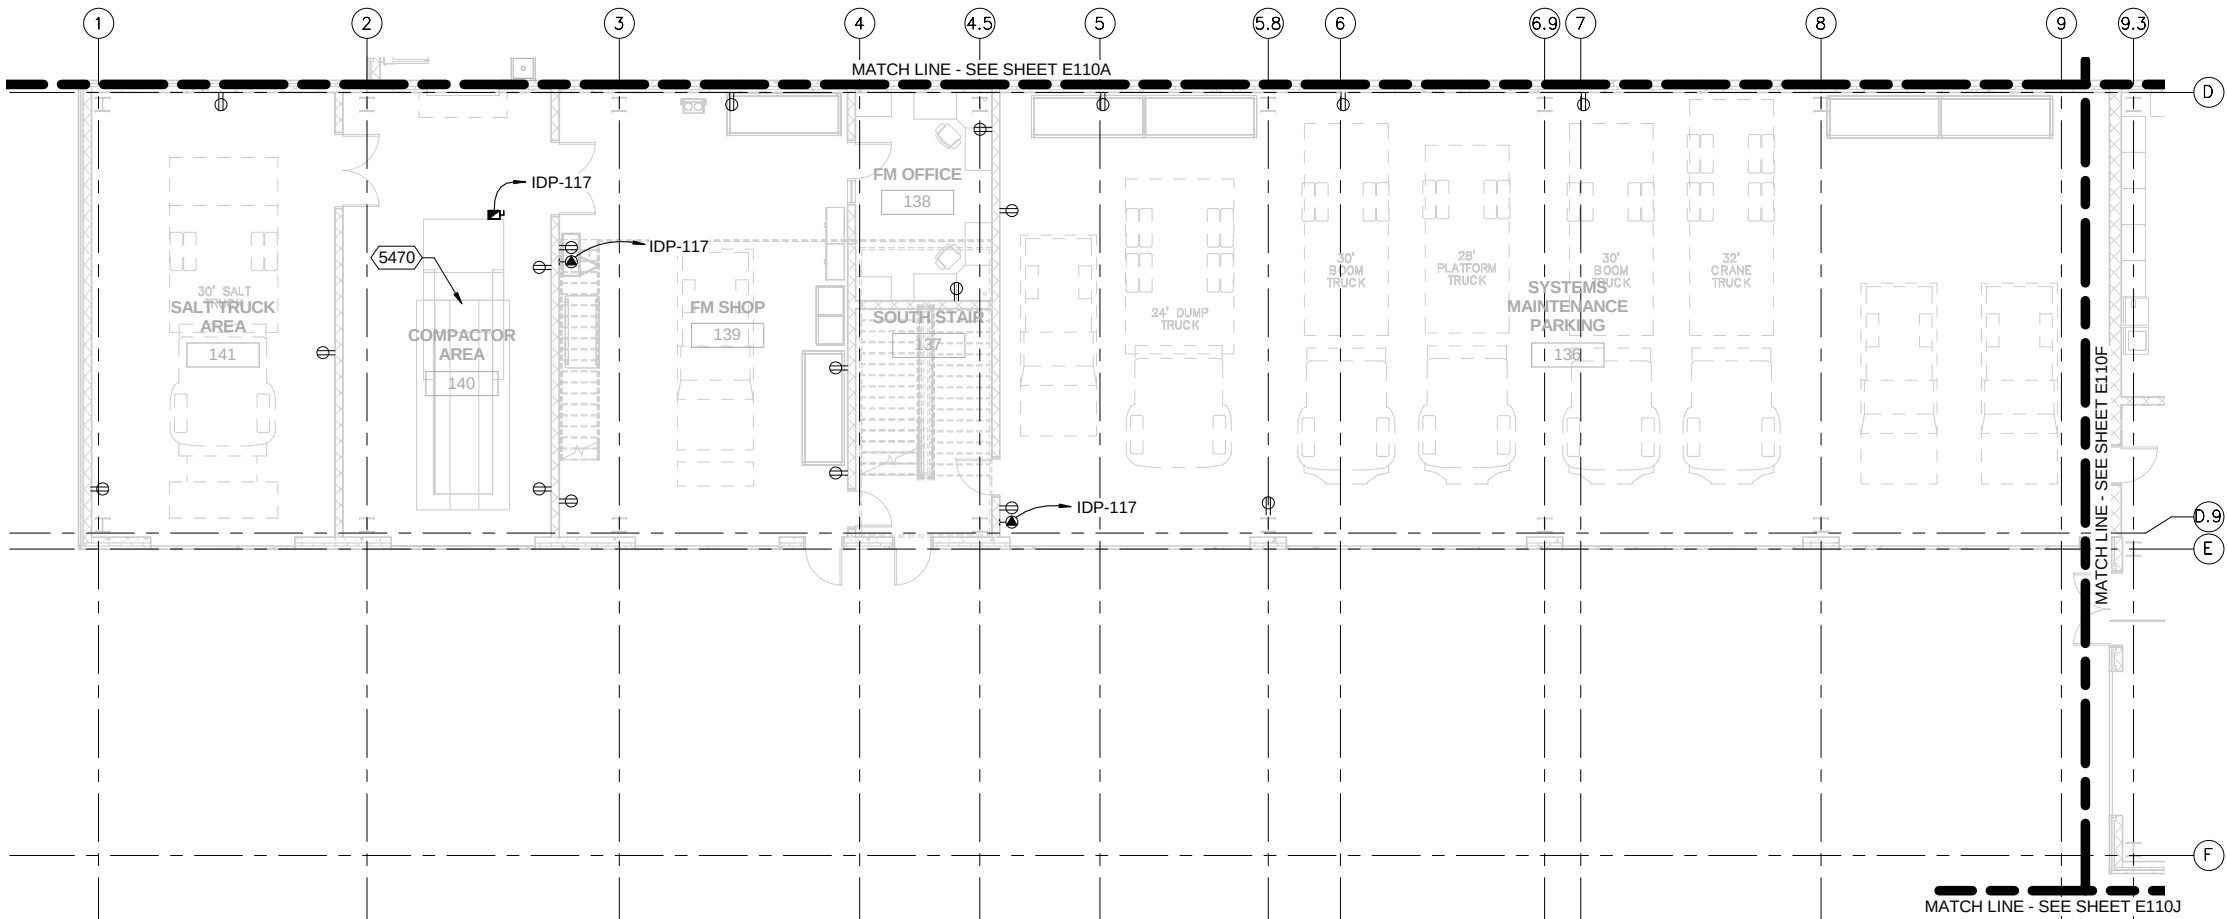

1 POWER PLAN - AREA E
E110E SCALE: 1/8" = 1'-0"

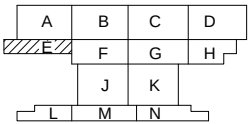

NO	DATE	BY	CHECK	DESIGN	REVISION / SUBMITTAL

 


MP Consultants
CONSULTING ENGINEERING
MINNEAPOLIS • MINNESOTA

60% SUBMISSION - 9/28/15



SOUTHWEST



OPERATIONS & MAINTENANCE FACILITY - V2B
ELECTRICAL
POWER - LEVEL ONE - AREA E

DISCIPLINE: ELECTRICAL

SHEET NAME: OMF-ELE-PLN

E110E

SHEET

 
166

OF

263

1. ALL GENERAL PURPOSE RECEPTACLES AND RECEPTACLE REELS WILL BE FED FROM PANEL ELP-117 UNLESS NOTED OTHERWISE.
2. SEE EQUIPMENT SCHEDULE ON SHEET E-805 FOR DISCONNECT SWITCHES, SIZES AND WIRING REQUIREMENTS.
3. SEE MECHANICAL PLAN FOR MOTORS AND LOCATIONS. PROVIDE FEEDERS AND DISCONNECT SWITCH TO EACH MOTOR

-



SCALE IN FEET

[illegible]


METROPOLITAN COUNCIL

SOUTHWEST

OPERATIONS & MAINTENANCE FACILITY - V2B ELECTRICAL POWER - LEVEL ONE - AREA F			SHEET 167 OF 263
DISCIPLINE: ELECTRICAL	SHEET NAME: OMF-ELE-PLN	E110F	

9/22/2015 10:08:51 AM C:\Users\V-BegeJB\Documents\OMF_ELEC_V-BegeJB.rvt

1. ALL GENERAL PURPOSE RECEPTACLES AND RECEPTACLE REELS WILL BE FED FROM PANEL ELP-126 UNLESS NOTED OTHERWISE.
2. SEE EQUIPMENT SCHEDULE ON SHEET E-805 FOR DISCONNECT SWITCHES, SIZES AND WIRING REQUIREMENTS.
3. SEE MECHANICAL PLAN FOR MOTORS AND LOCATIONS. PROVIDE FEEDERS AND DISCONNECT SWITCH TO EACH MOTOR

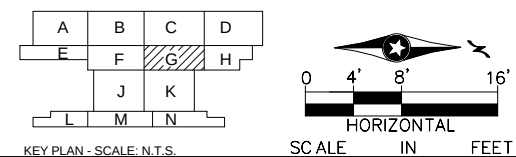[illegible]


METROPOLITAN COUNCIL

SOUTHWEST


DISCIPLINE:	SHEET NAME:	
ELECTRICAL	OMF-ELE-PLN	E110G

168
OF
263

- GENERAL NOTES:
1. ALL GENERAL PURPOSE RECEPTACLES AND RECEPTACLE REELS WILL BE FED FROM PANEL ELP-126 UNLESS NOTED OTHERWISE.
 2. SEE EQUIPMENT SCHEDULE ON SHEET E-805 FOR DISCONNECT SWITCHES, SIZES AND WIRING REQUIREMENTS.
 3. SEE MECHANICAL PLAN FOR MOTORS AND LOCATIONS. PROVIDE FEEDERS AND DISCONNECT SWITCH TO EACH MOTOR

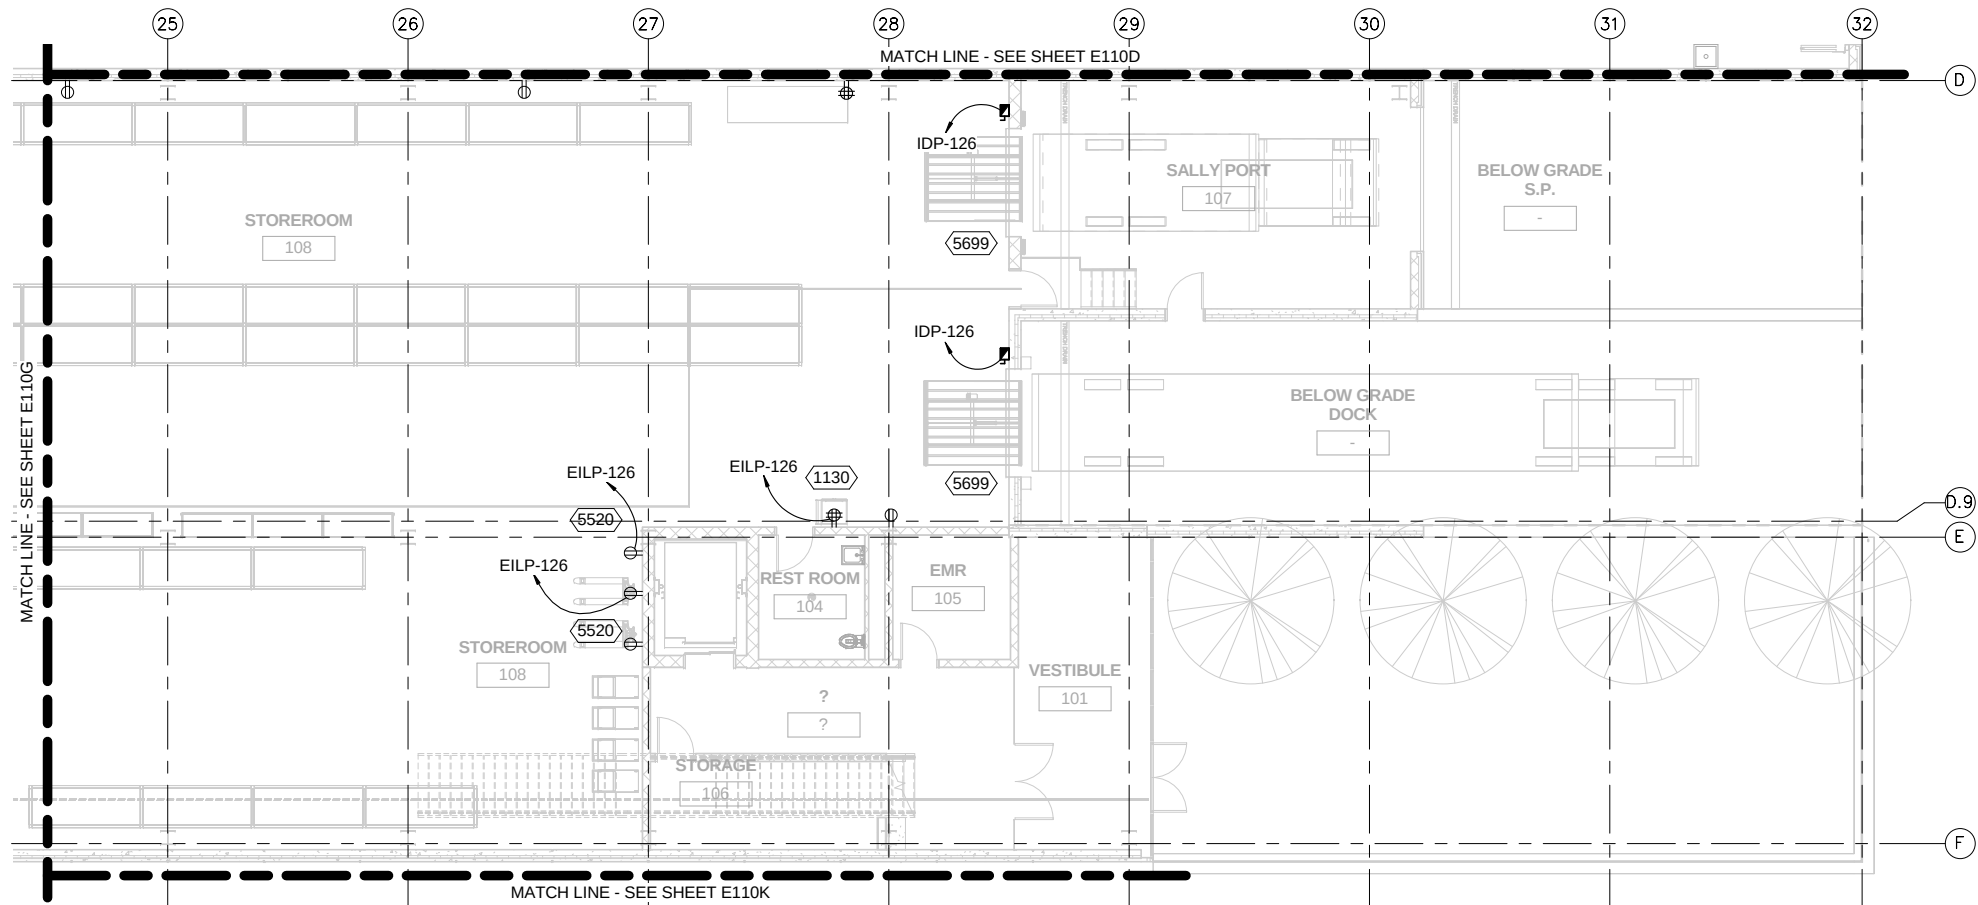

1 POWER PLAN - AREA H
E110H SCALE: 1/8" = 1'-0"

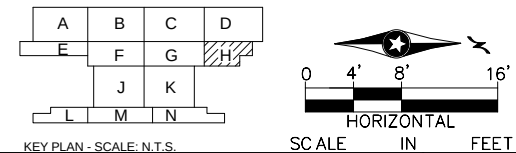

NO	DATE	BY	CHECK	DESIGN	REVISION / SUBMITTAL

AECOM
MP Consultants
CONSULTING ENGINEERING
MINNEAPOLIS, MINNESOTA

METROPOLITAN COUNCIL

SOUTHWEST

60% SUBMISSION - 9/28/15

OPERATIONS & MAINTENANCE FACILITY - V2B
ELECTRICAL
POWER - LEVEL ONE - AREA H

DISCIPLINE: ELECTRICAL

SHEET NAME: OMF-ELE-PLN

E110H

SHEET
169
OF
263


GENERAL NOTES:

1. ALL GENERAL PURPOSE RECEPTACLES AND RECEPTACLE REELS WILL BE FED FROM PANEL ELP-150 UNLESS NOTED OTHERWISE.
2. SEE EQUIPMENT SCHEDULE ON SHEET E-805 FOR DISCONNECT SWITCHES, SIZES AND WIRING REQUIREMENTS.
3. SEE MECHANICAL PLAN FOR MOTORS AND LOCATIONS. PROVIDE FEEDERS AND DISCONNECT SWITCH TO EACH MOTOR


KEYNOTES:



1. SEE FLOOR MOUNTED DISCONNECT DETAIL ON SHEET E-XXX.

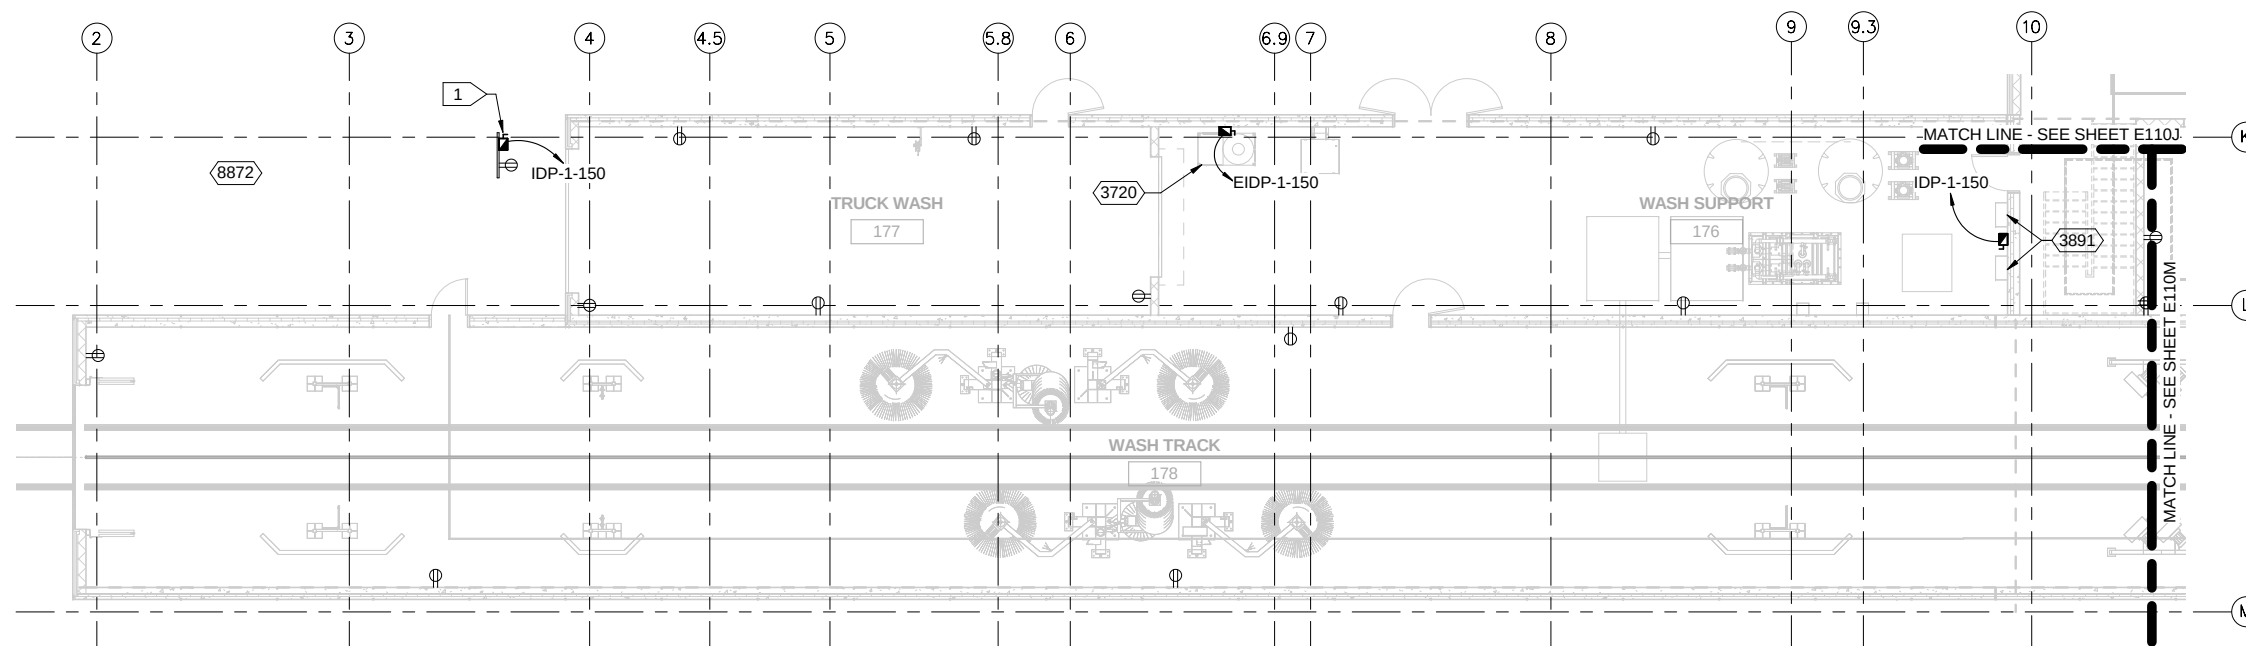

1 POWER PLAN - AREA L
E110L SCALE: 1/8" = 1'-0"

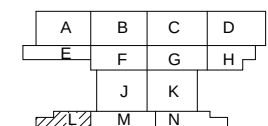

KEY PLAN - SCALE: N.T.S.

SCALE IN FEET

NO	DATE	BY	CHECK	DESIGN	REVISION / SUBMITTAL

AECOM
CONSULTING ENGINEERING
MINNEAPOLIS • MINNESOTA

MP Consultants
MINNEAPOLIS • MINNESOTA

60% SUBMISSION - 9/28/15

**METROPOLITAN COUNCIL**

**SOUTHWEST**

OPERATIONS & MAINTENANCE FACILITY - V2B
ELECTRICAL
POWER - LEVEL ONE - AREA L

DISCIPLINE: **ELECTRICAL**


SHEET NAME: **OMF-ELE-PLN**

E110L

SHEET
172
OF
263

1. ALL GENERAL PURPOSE RECEPTACLES AND RECEPTACLE REELS WILL BE FED FROM PANEL ELP-150 UNLESS NOTED OTHERWISE.
2. SEE EQUIPMENT SCHEDULE ON SHEET E-805 FOR DISCONNECT SWITCHES, SIZES AND WIRING REQUIREMENTS.
3. SEE MECHANICAL PLAN FOR MOTORS AND LOCATIONS. PROVIDE FEEDERS AND DISCONNECT SWITCH TO EACH MOTOR

1. SEE FLOOR MOUNTED DISCONNECT DETAIL ON SHEET E-XXX.
2. SEE SANDING SYSTEM CONTROL WIRING BLOCK DIAGRAM ON SHEET E-XXX FOR WIRING REQUIREMENTS.

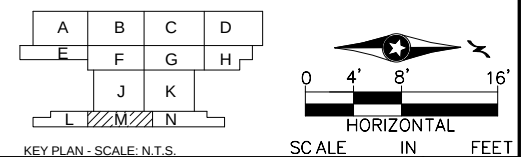[illegible]

METROPOLITAN COUNCIL


SOUTHWEST

DISCIPLINE:	SHEET NAME:	
ELECTRICAL	OMF-ELE-PLN	E110M


173
OF
263

- GENERAL NOTES:
1. ALL GENERAL PURPOSE RECEPTACLES AND RECEPTACLE REELS WILL BE FED FROM PANEL ELP-150 UNLESS NOTED OTHERWISE.
 2. SEE EQUIPMENT SCHEDULE ON SHEET E-805 FOR DISCONNECT SWITCHES, SIZES AND WIRING REQUIREMENTS.
 3. SEE MECHANICAL PLAN FOR MOTORS AND LOCATIONS. PROVIDE FEEDERS AND DISCONNECT SWITCH TO EACH MOTOR

- KEYNOTES:
1. SEE FLOOR MOUNTED DISCONNECT DETAIL ON SHEET E-XXX.
 2. SEE DUCTBANK DETAILS ON SHEET E-506.

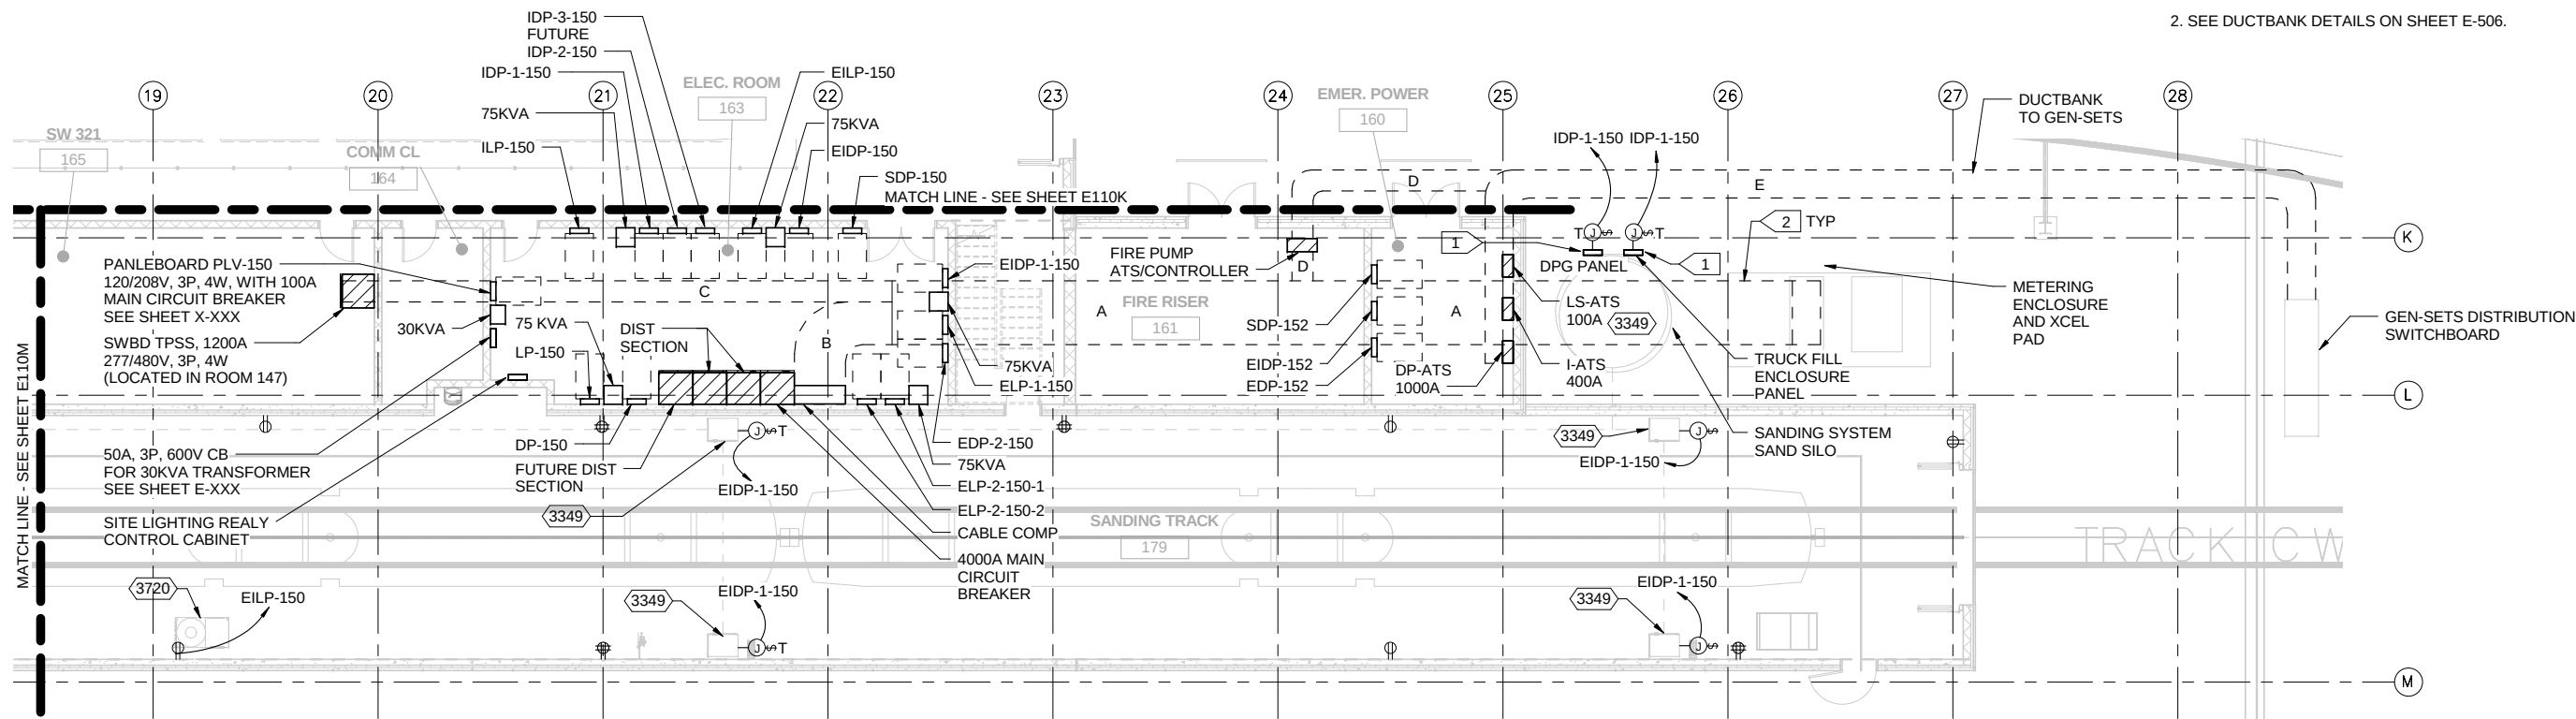

1 POWER PLAN - AREA N
E110N SCALE: 1/8" = 1'-0"

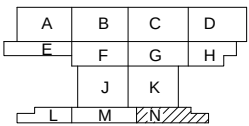

NO	DATE	BY	CHECK	DESIGN	REVISION / SUBMITTAL

AECOM *MP Consultants*
CONSULTING ENGINEERING
MINNEAPOLIS, MINNESOTA










60% SUBMISSION - 9/28/15

OPERATIONS & MAINTENANCE FACILITY - V2B
ELECTRICAL
POWER - LEVEL ONE - AREA N

DISCIPLINE: ELECTRICAL
SHEET NAME: OMF-ELE-PLN
E110N

SHEET
174
OF
263

9/22/2015 10:09:22 AM C:\Users\VBegaj\Documents\OMF_ELEC_V-Begaj\B.rvt

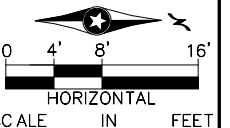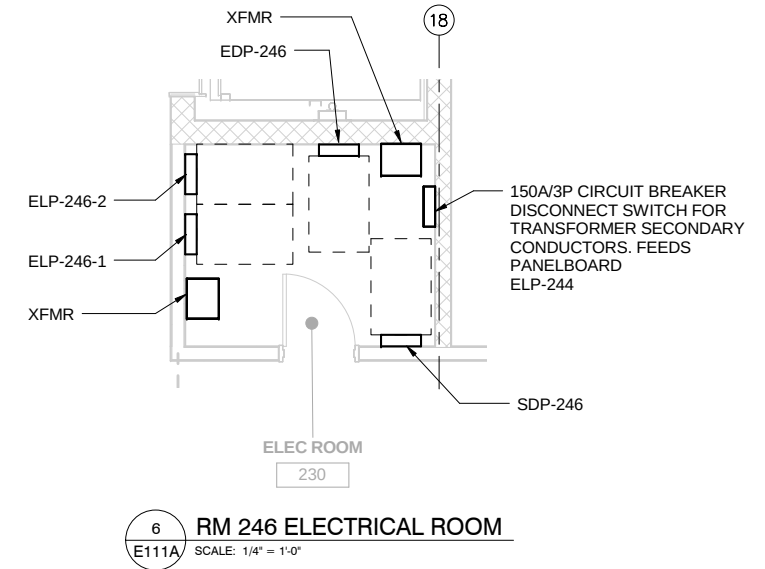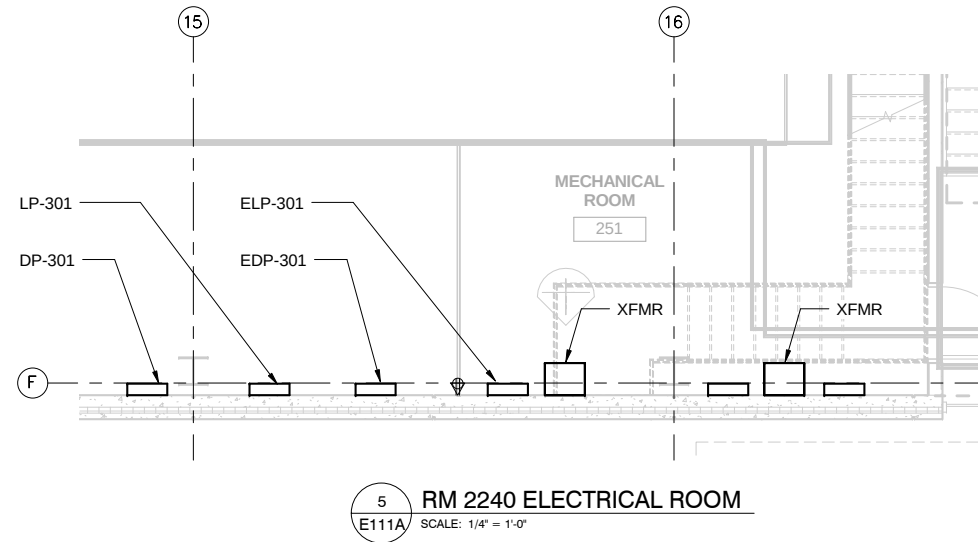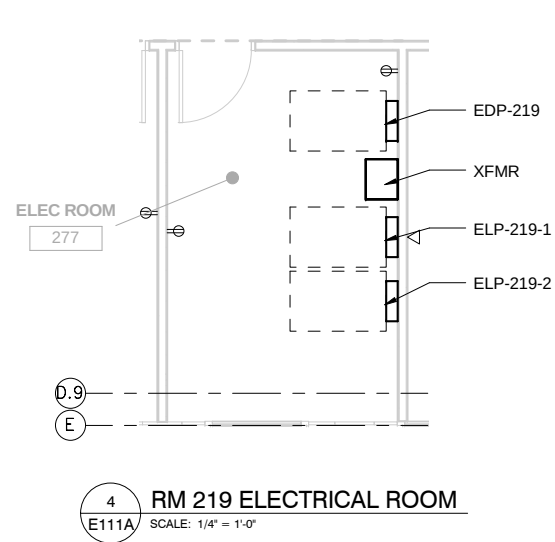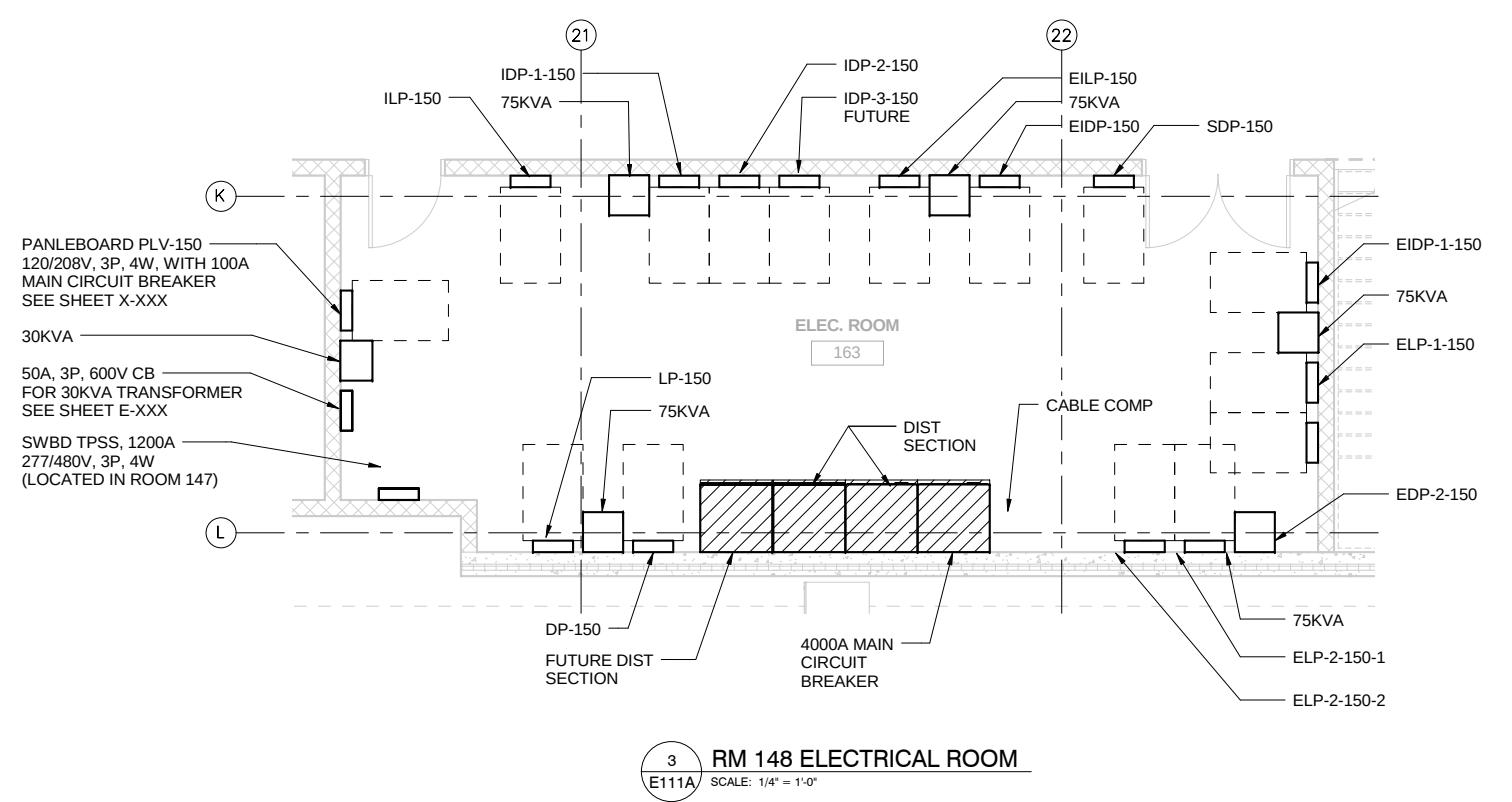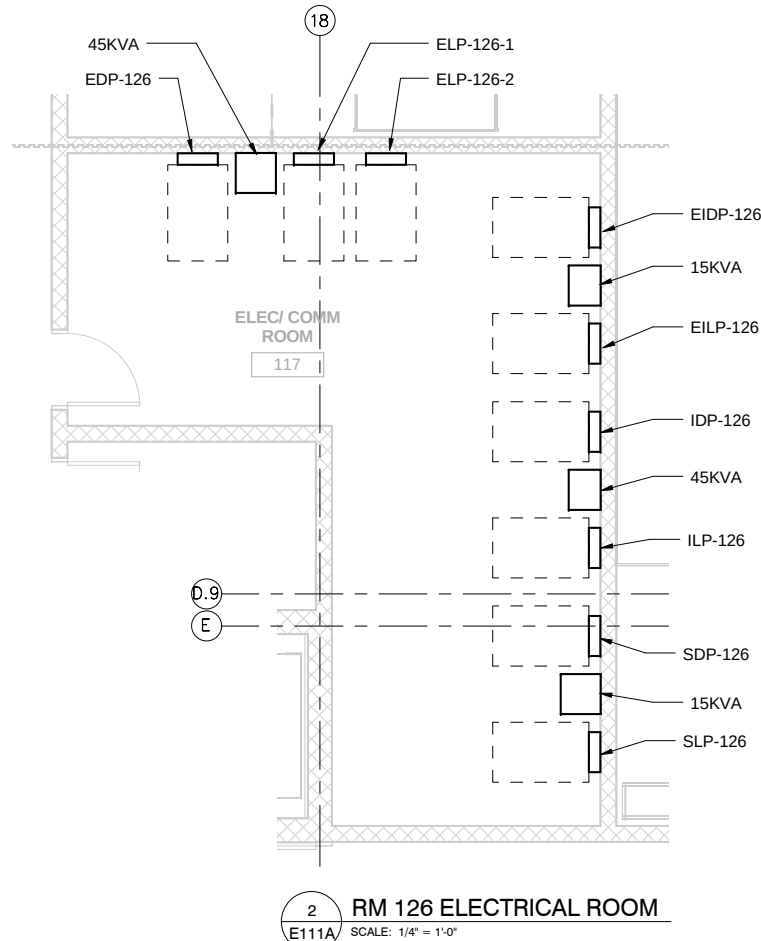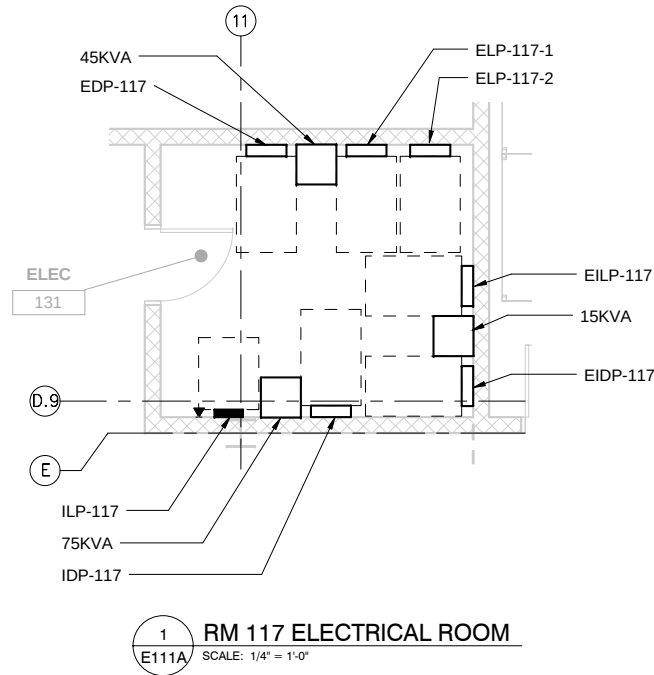

NO	DATE	BY	CHECK	DESIGN	REVISION / SUBMITTAL

AECOM *MP Consultants*
CONSULTING ENGINEERING
MINNEAPOLIS, MINNESOTA




60% SUBMISSION - 9/28/15

OPERATIONS & MAINTENANCE FACILITY - V2B
ELECTRICAL
POWER - ENLARGED PLANS - ELECTRICAL ROOMS

DISCIPLINE: **ELECTRICAL** SHEET NAME: **OMF-ELE-PLN E111A**


SHEET
175
OF
263

9/22/2015 10:09:25 AM C:\Users\jv-Beggs\Documents\OMF_ELEC_V-Beggs\B.rvt

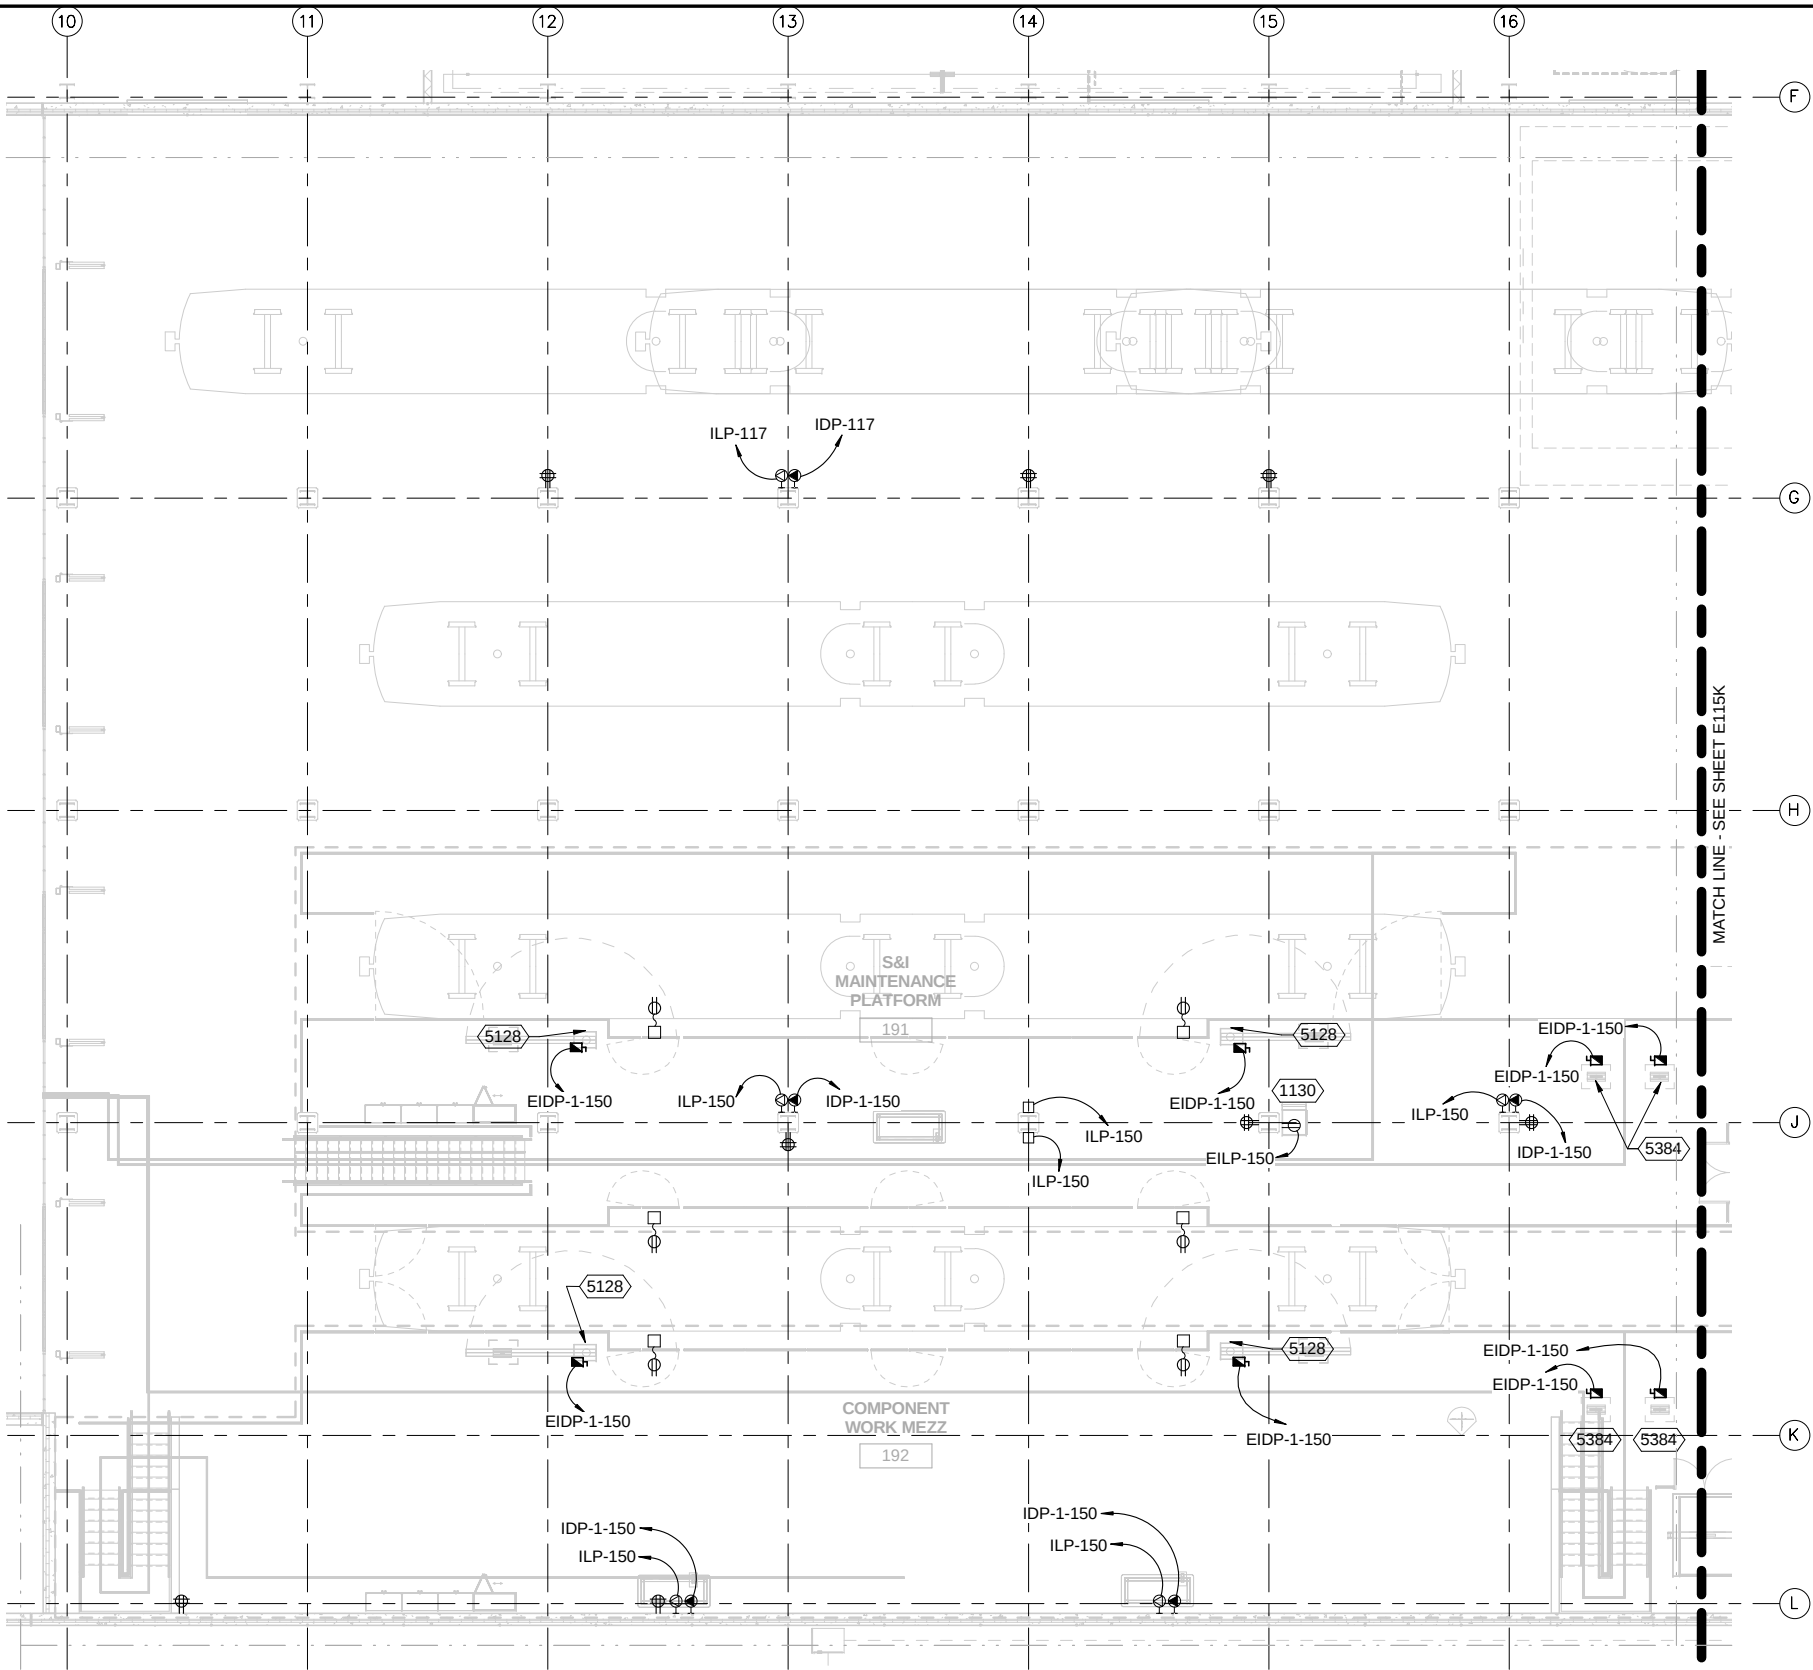

- GENERAL NOTES:**
1. ALL GENERAL PURPOSE RECEPTACLES AND RECEPTACLE REELS FROM GRID F-H WILL BE FED FROM PANEL ELP-117 AND FROM GRID H-K WILL BE FED FROM ELP-1-150 UNLESS NOTED OTHERWISE.
 2. SEE EQUIPMENT SCHEDULE ON SHEET E-805 FOR DISCONNECT SWITCHES, SIZES AND WIRING REQUIREMENTS.
 3. SEE MECHANICAL PLAN FOR MOTORS AND LOCATIONS. PROVIDE FEEDERS AND DISCONNECT SWITCH TO EACH MOTOR.

1 POWER PLAN - AREA J
E115J SCALE: 1/8" = 1'-0"

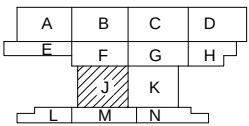

NO	DATE	BY	CHECK	DESIGN	REVISION / SUBMITTAL

AECOM
CONSULTING ENGINEERING
MINNEAPOLIS, MINNESOTA

MP Consultants
CONSULTING ENGINEERING
MINNEAPOLIS, MINNESOTA

60% SUBMISSION - 9/28/15

**METROPOLITAN**
COUNCIL

**SOUTHWEST**


OPERATIONS & MAINTENANCE FACILITY - V2B
ELECTRICAL
POWER - MEZZANINE LEVEL - AREA J

DISCIPLINE: ELECTRICAL

SHEET NAME: OMF-ELE-PLN

E115J

9/22/2015 10:09:29 AM C:\Users\jv-Beggs\Documents\OMF_ELEC_V-Beggs\B.rvt

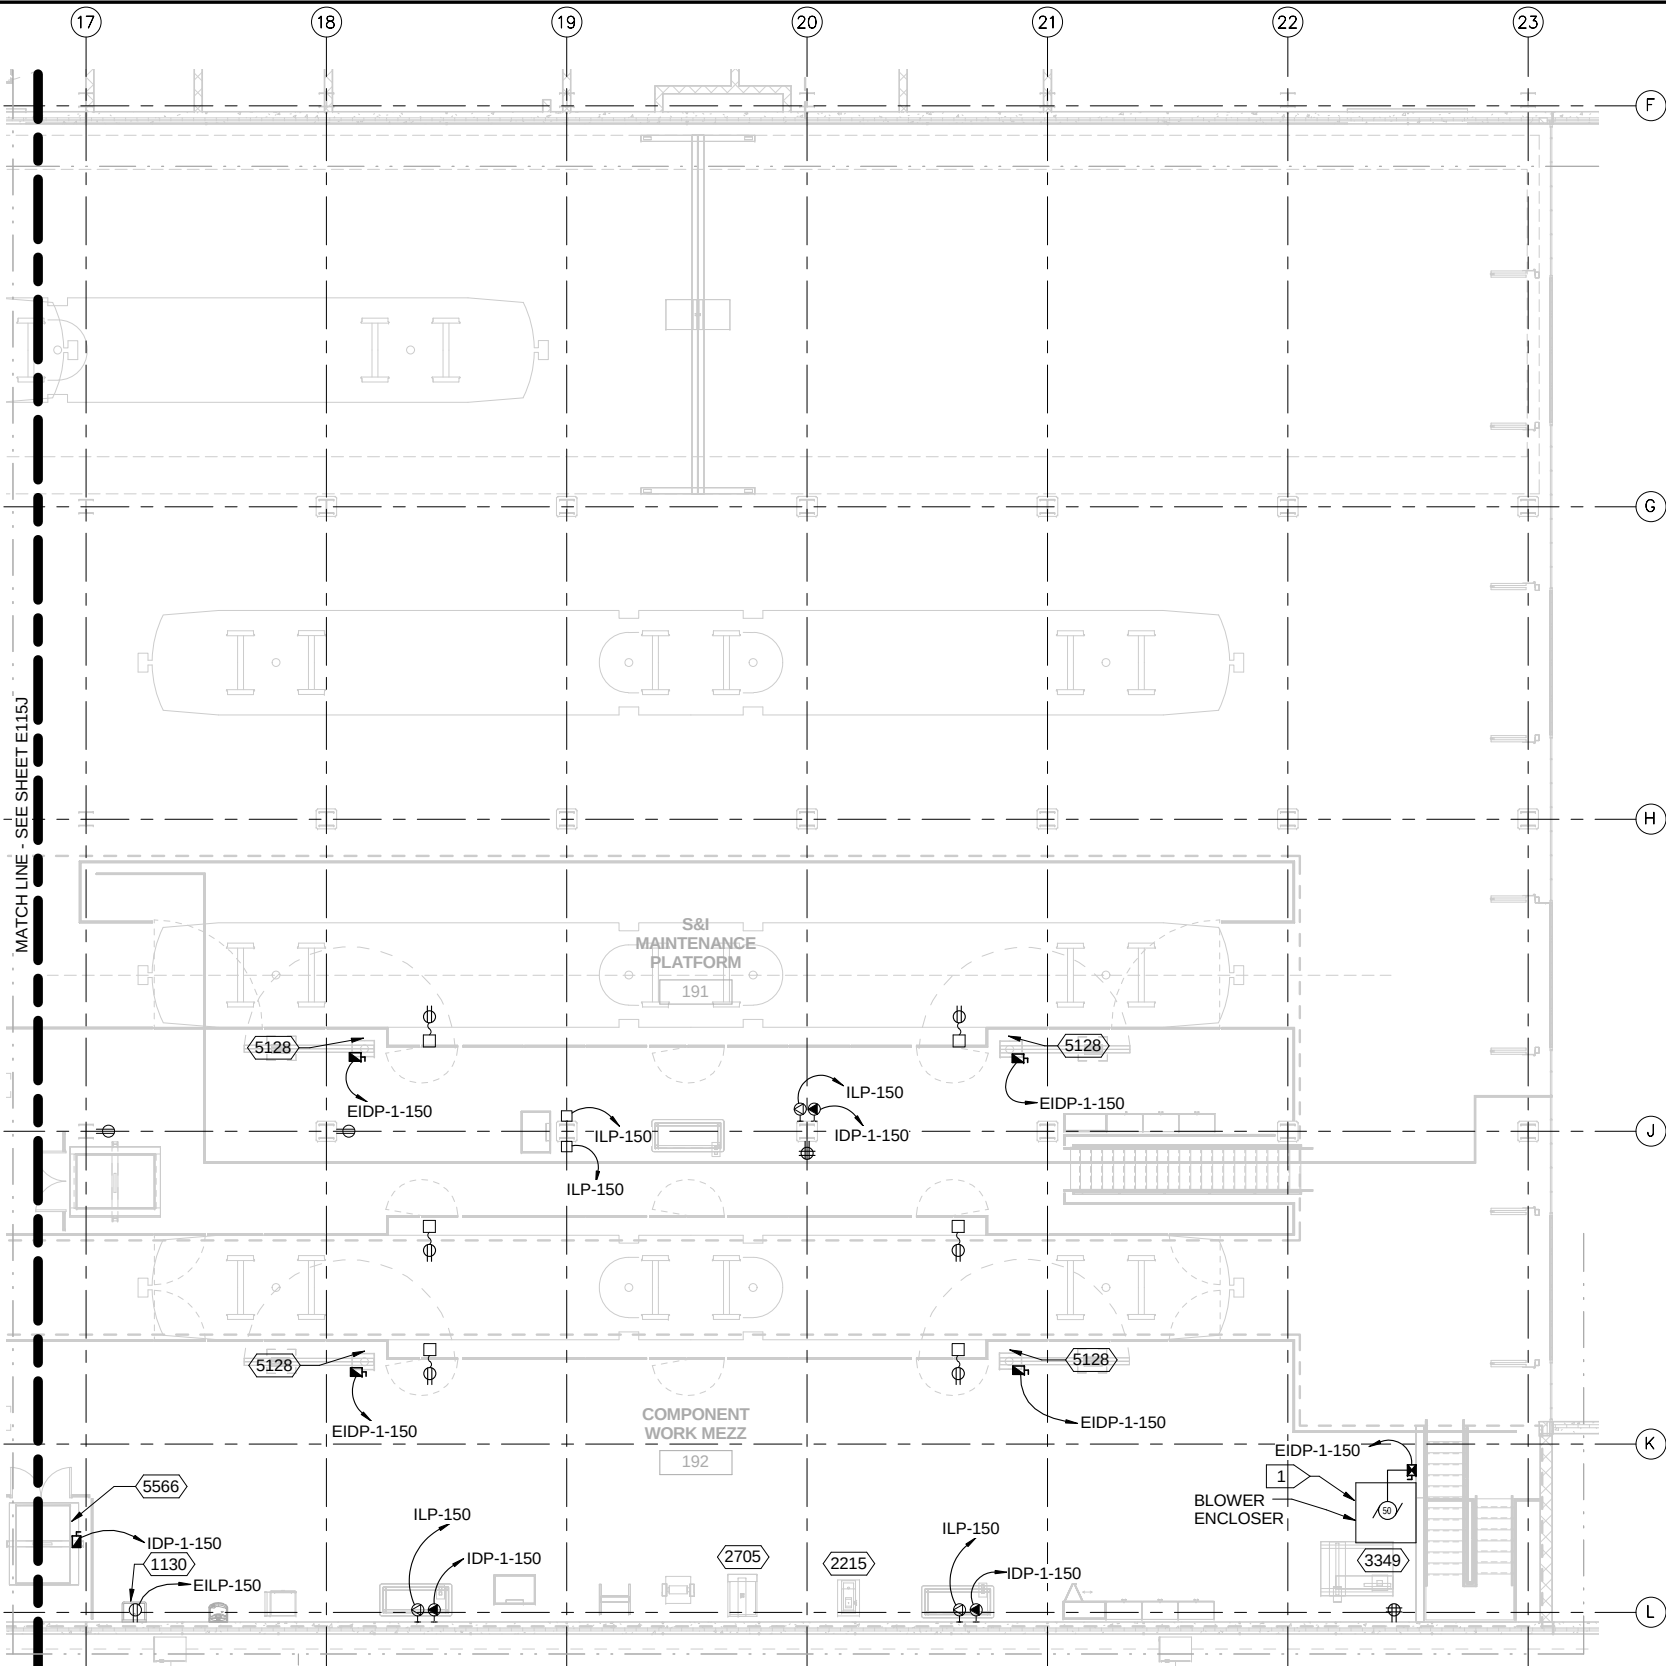

- GENERAL NOTES:**
1. ALL GENERAL PURPOSE RECEPTACLES AND RECEPTACLE REELS WILL BE FED FROM PANEL ELP-150 UNLESS NOTED OTHERWISE.
 2. SEE EQUIPMENT SCHEDULE ON SHEET E-805 FOR DISCONNECT SWITCHES, SIZES AND WIRING REQUIREMENTS.
 3. SEE MECHANICAL PLAN FOR MOTORS AND LOCATIONS. PROVIDE FEEDERS AND DISCONNECT SWITCH TO EACH MOTOR.
- KEYNOTES:**
1. SEE SANDING SYSTEM CONTROL WIRING BLOCK DIAGRAM ON SHEET E-XXX FOR WIRING REQUIREMENTS.

1 POWER PLAN - AREA K
E115K SCALE: 1/8" = 1'-0"

NO	DATE	BY	CHECK	DESIGN	REVISION / SUBMITTAL



MP Consultants
CONSULTING ENGINEERING
MINNEAPOLIS, MINNESOTA



SOUTHWEST

60% SUBMISSION - 9/28/15

OPERATIONS & MAINTENANCE FACILITY - V2B
ELECTRICAL
POWER - MEZZANINE LEVEL - AREA K

DISCIPLINE: ELECTRICAL

SHEET NAME: OMF-ELE-PLN

E115K


SHEET

177


OF

263

9/22/2015 10:09:32 AM C:\Users\jv-Begaj\Documents\OMF_ELEC_V-BegajB.rvt

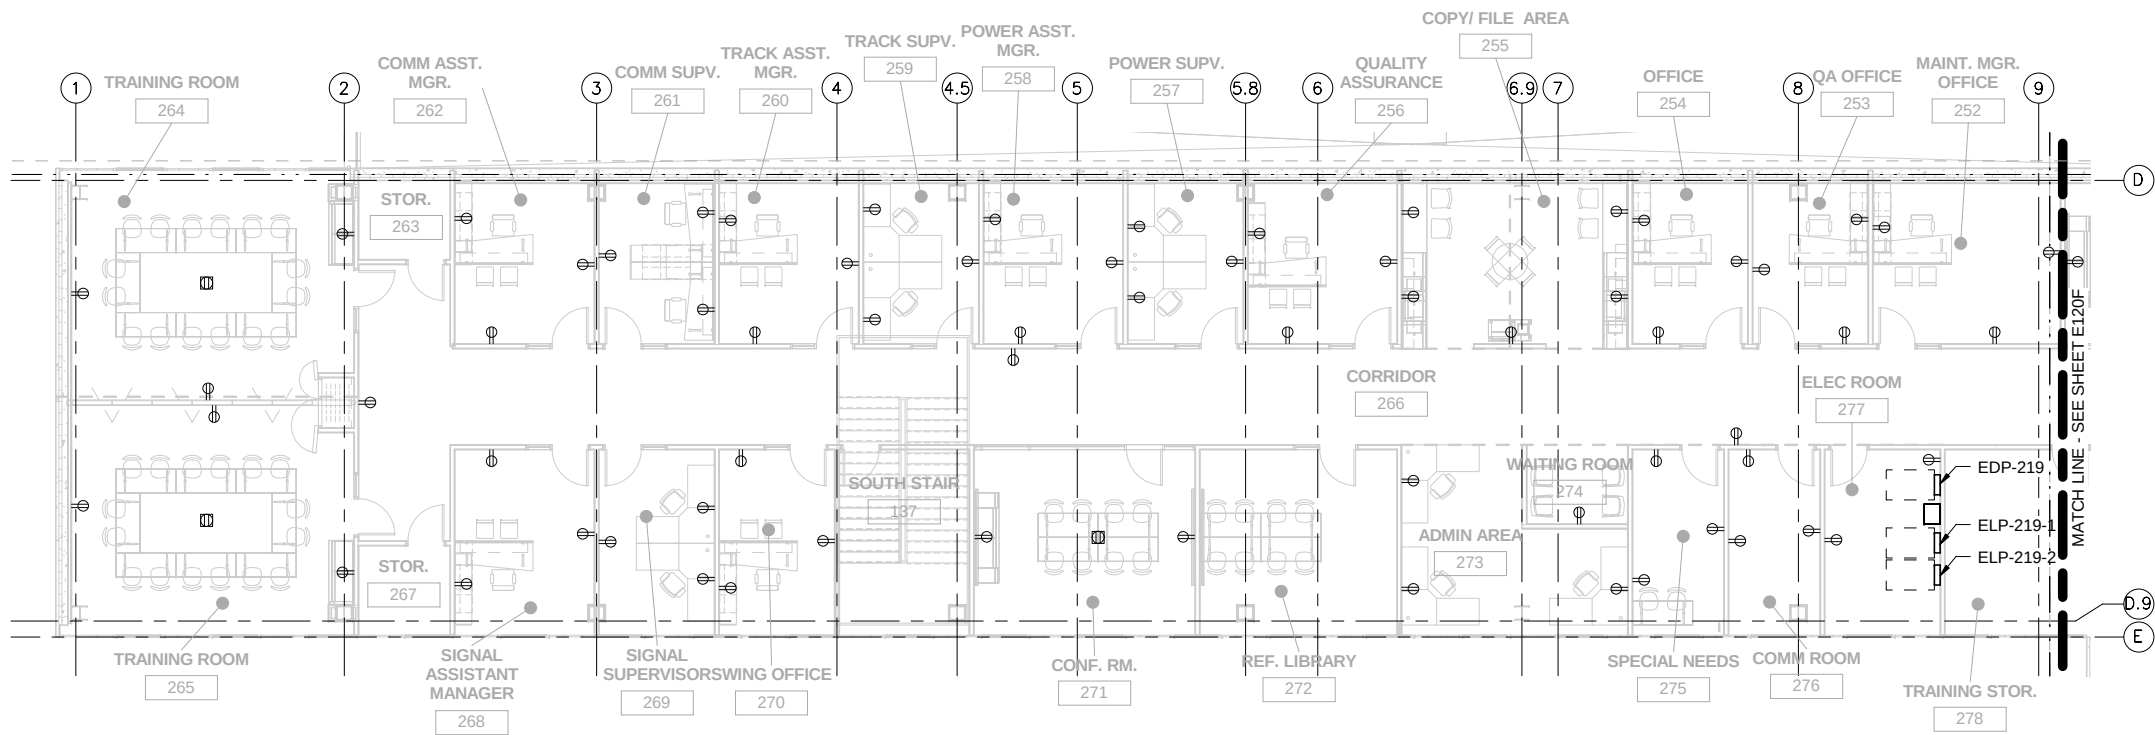

1 POWER PLAN - AREA E
E120E SCALE: 1/8" = 1'-0"

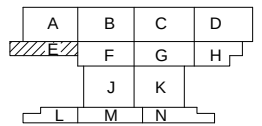

NO	DATE	BY	CHECK	DESIGN	REVISION / SUBMITTAL

AECOM
CONSULTING ENGINEERING
MINNEAPOLIS, MINNESOTA

MP Consultants
CONSULTING ENGINEERING
MINNEAPOLIS, MINNESOTA

60% SUBMISSION - 9/28/15

**METROPOLITAN COUNCIL**

**SOUTHWEST**

OPERATIONS & MAINTENANCE FACILITY - V2B
ELECTRICAL
POWER - LEVEL TWO - AREA E


DISCIPLINE: **ELECTRICAL**

SHEET NAME: **OMF-ELE-PLN**



E120E

SHEET
178
OF
263

9/22/2015 10:09:35 AM C:\Users\jv-Beggs\Documents\OMF_ELEC_V-Beggs\B.rvt

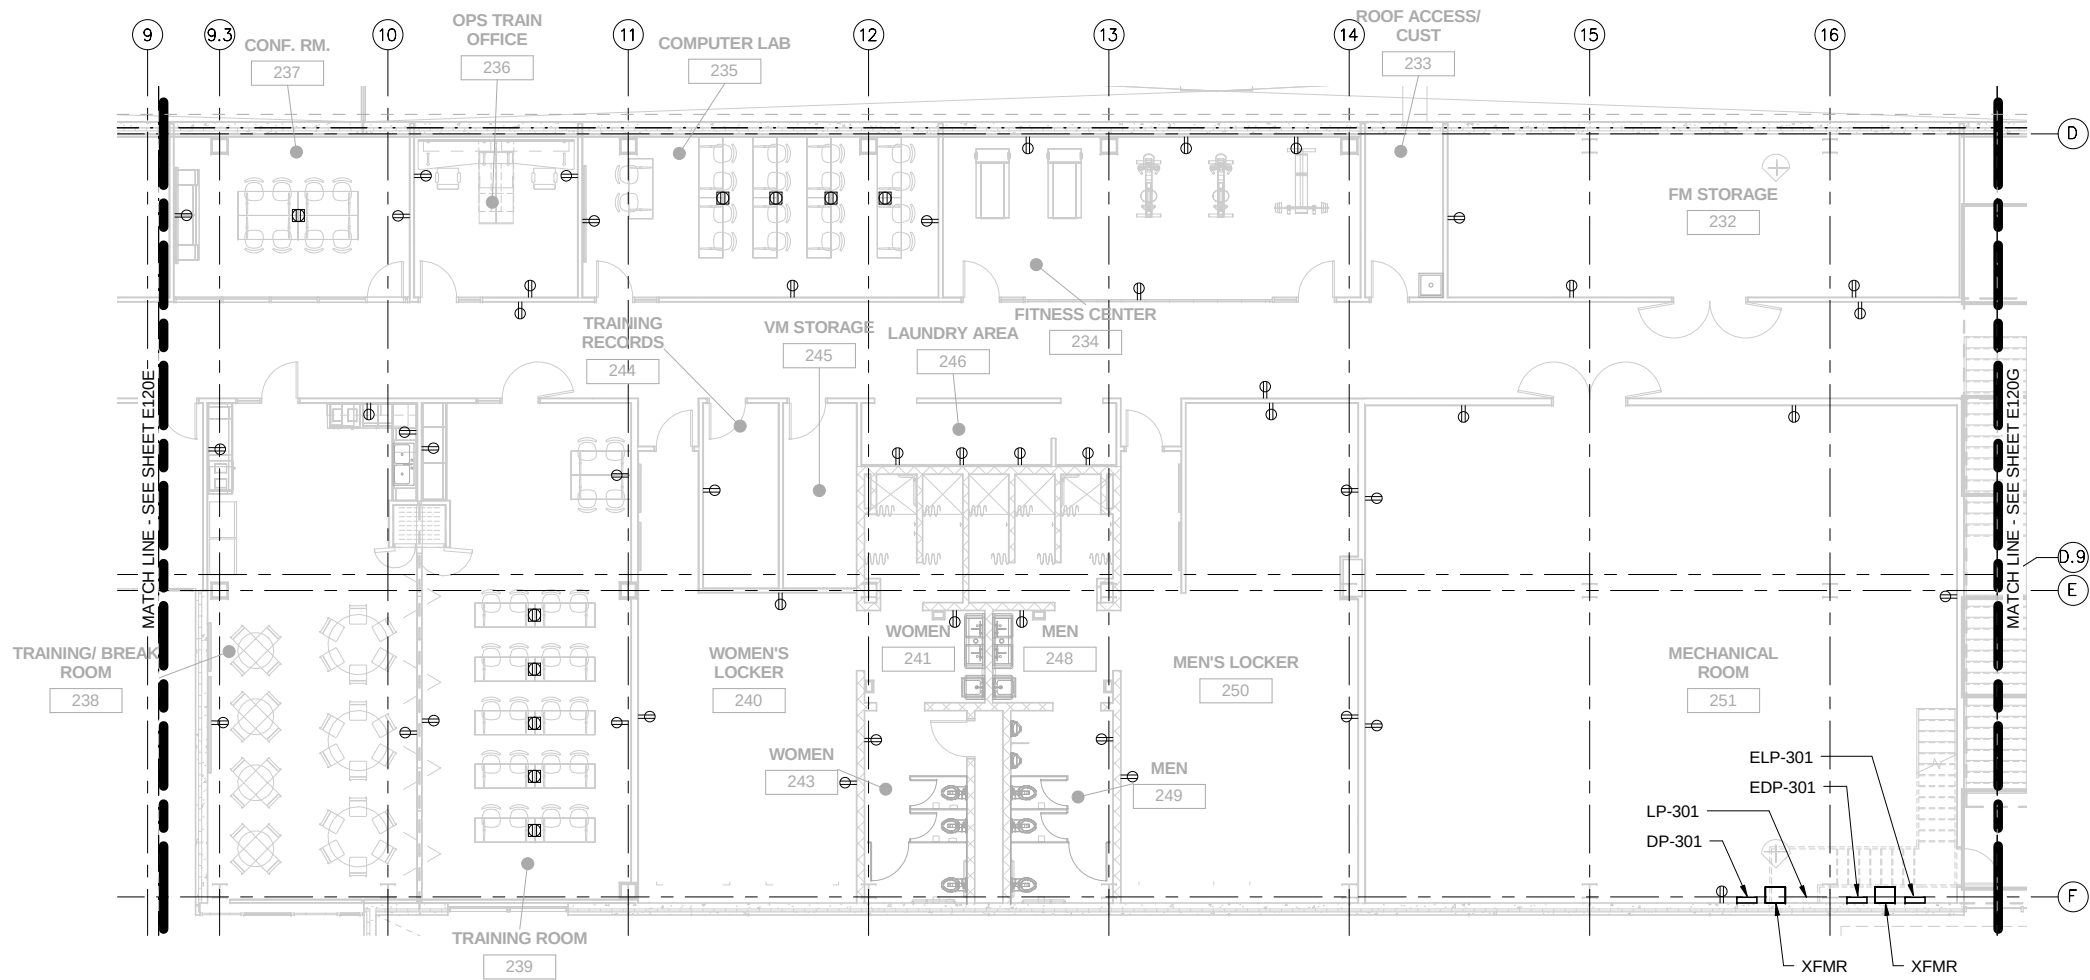

 1 POWER PLAN - AREA F
E120F SCALE: 1/8" = 1'-0"

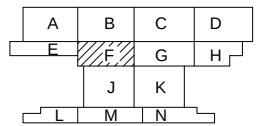

NO	DATE	BY	CHECK	DESIGN	REVISION / SUBMITTAL

AECOM

MP Consultants
CONSULTING ENGINEERING
MINNEAPOLIS, MINNESOTA

60% SUBMISSION - 9/28/15

**METROPOLITAN**
COUNCIL

**SOUTHWEST**

OPERATIONS & MAINTENANCE FACILITY - V2B
ELECTRICAL
POWER - LEVEL TWO - AREA F


DISCIPLINE: ELECTRICAL

SHEET NAME: OMF-ELE-PLN


E120F

SHEET
179
OF
263

9/22/2015 10:09:38 AM C:\Users\jv-Beggs\Documents\OMF_ELEC_V-Beggs\B.rvt

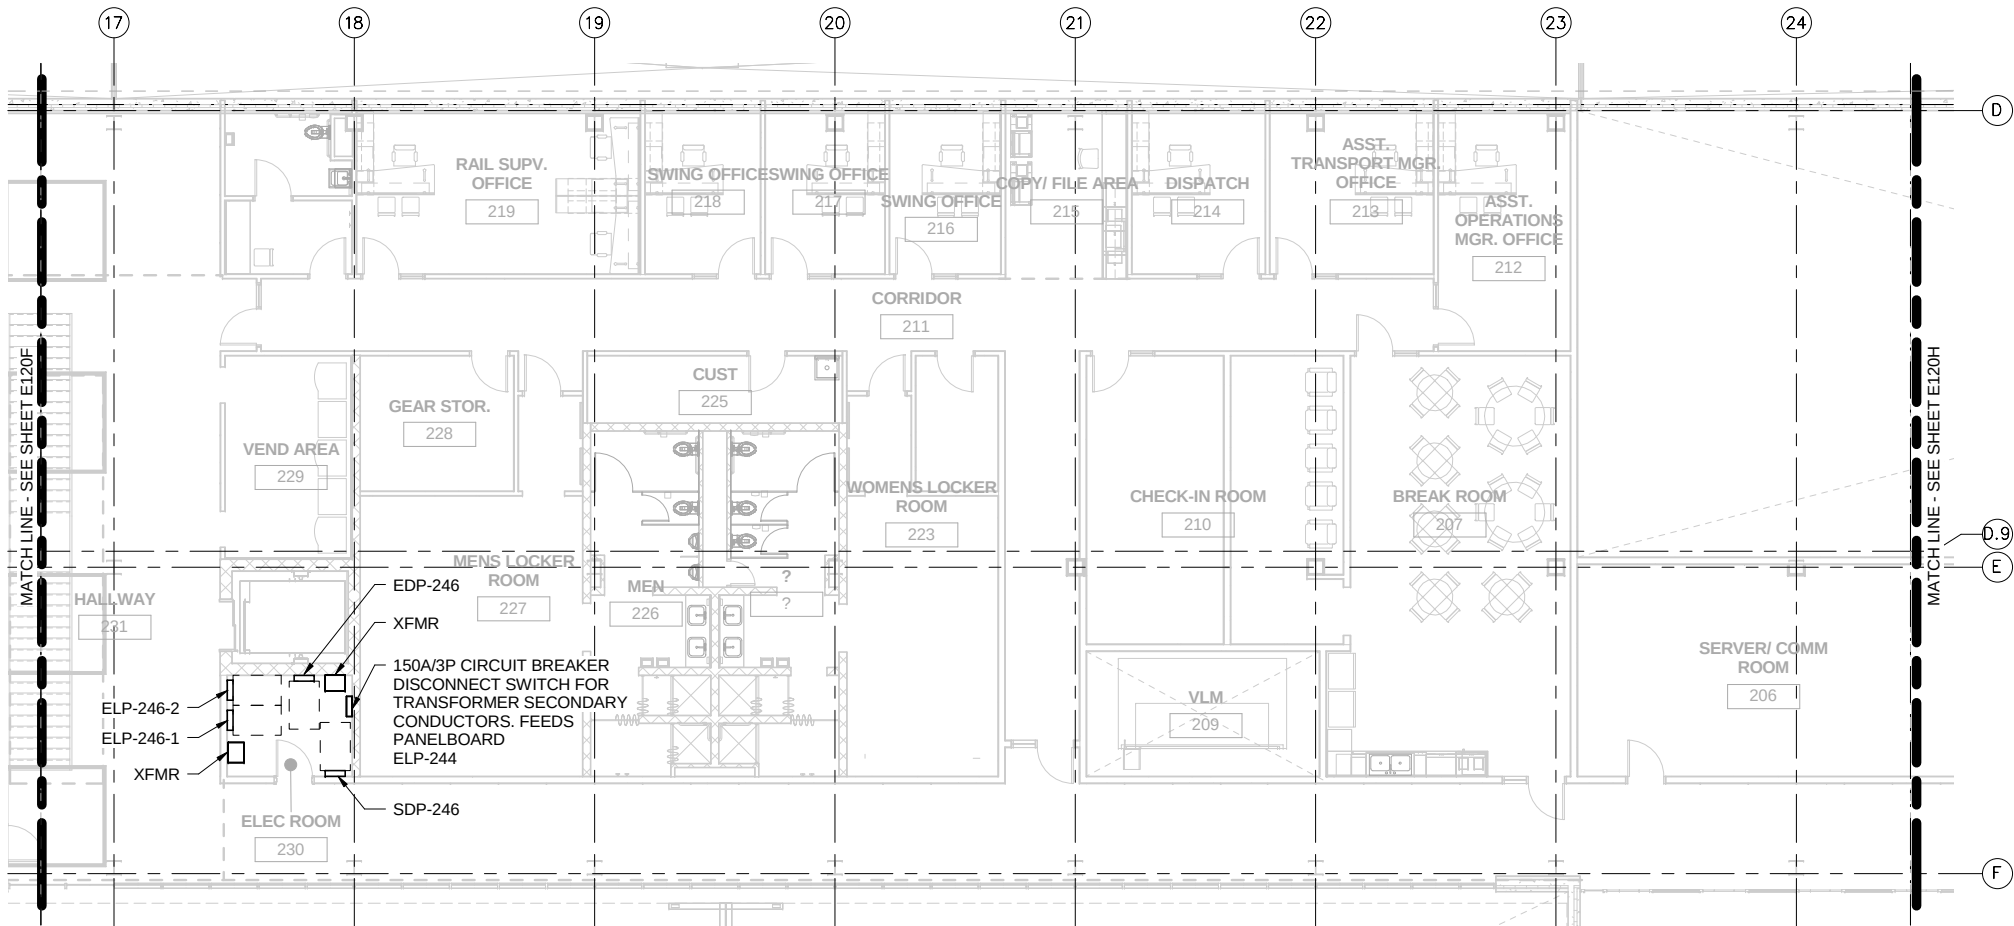


1 POWER PLAN - AREA G
E120G SCALE: 1/8" = 1'-0"

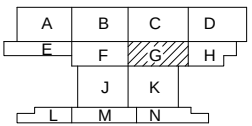


NO	DATE	BY	CHECK	DESIGN	REVISION / SUBMITTAL

 AECOM MP Consultants CONSULTING ENGINEERING MINNEAPOLIS, MINNESOTA	 METROPOLITAN COUNCIL	 SOUTHWEST	OPERATIONS & MAINTENANCE FACILITY - V2B			SHEET 180 OF 263
			ELECTRICAL			
POWER - LEVEL TWO - AREA G			DISCIPLINE: ELECTRICAL	SHEET NAME: OMF-ELE-PLN	E120G	
60% SUBMISSION - 9/28/15						

9/22/2015 10:09:40 AM C:\Users\jV-Begaj\Documents\OMF_ELEC_V-BegajB.rvt

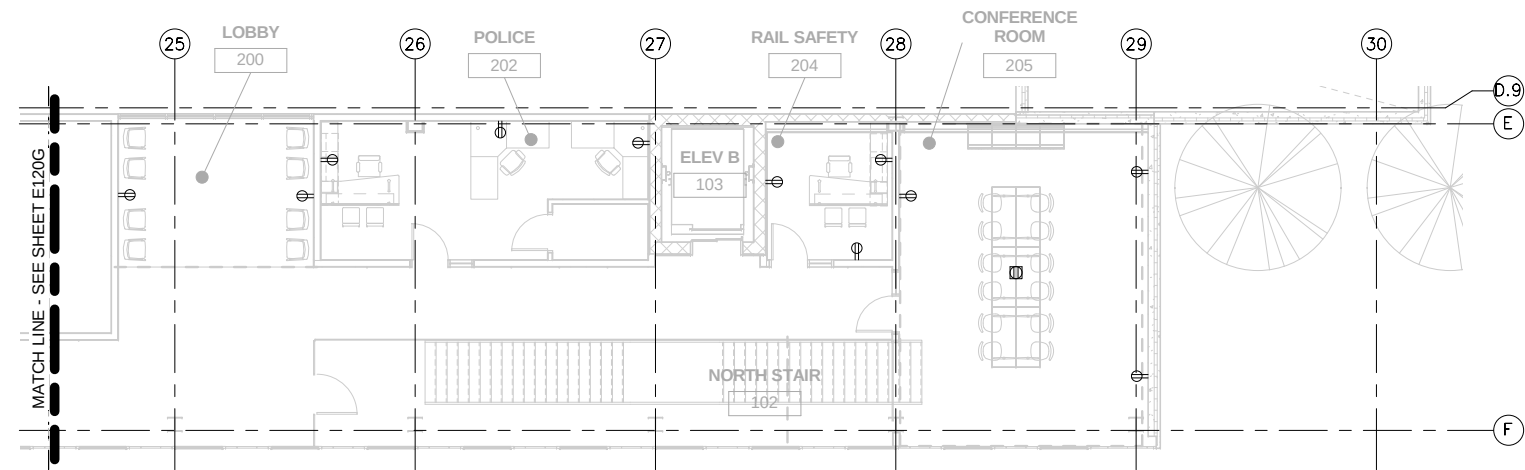

1
E120H POWER PLAN - AREA H
SCALE: 1/8" = 1'-0"

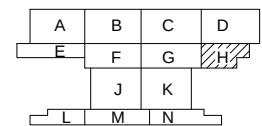

KEY PLAN - SCALE: N.T.S.

SCALE IN FEET

NO	DATE	BY	CHECK	DESIGN	REVISION / SUBMITTAL

AECOM
CONSULTING ENGINEERING
MINNEAPOLIS • MINNESOTA

MP Consultants
CONSULTING ENGINEERING
MINNEAPOLIS • MINNESOTA

60% SUBMISSION - 9/28/15

**METROPOLITAN
COUNCIL**

**SOUTHWEST**


OPERATIONS & MAINTENANCE FACILITY - V2B
ELECTRICAL
POWER - LEVEL TWO - AREA H

DISCIPLINE: **ELECTRICAL**

SHEET NAME: **OMF-ELE-PLN**

E120H

SHEET
181
OF
263

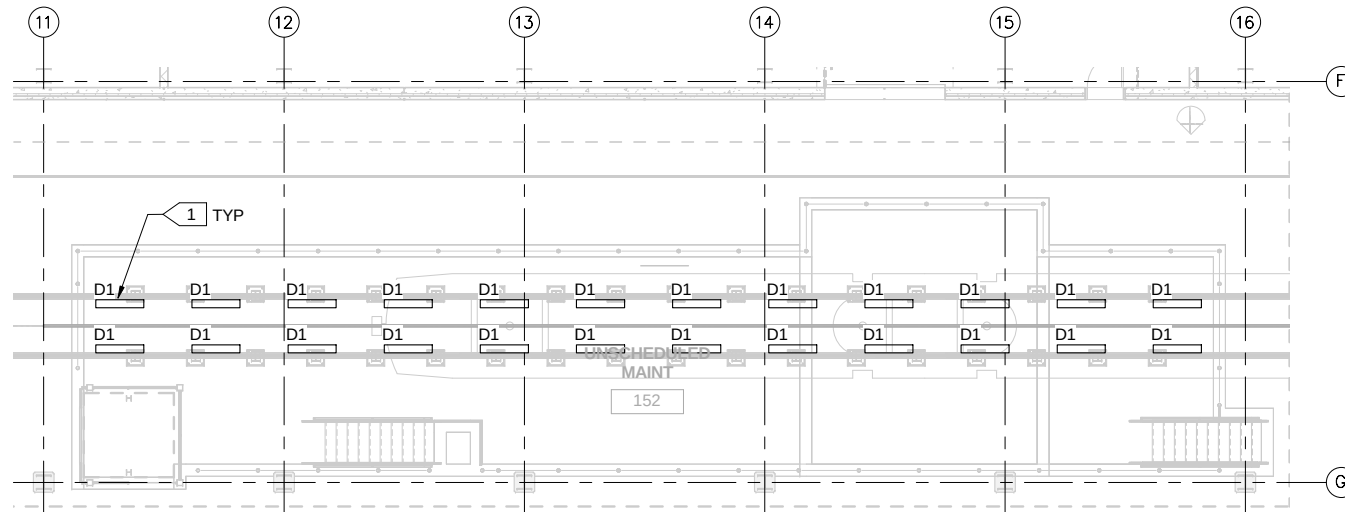


1 PIT LIGHTING
E200A SCALE: 1/8" = 1'-0"

GENERAL NOTE:


1. ALL LUMINAIRES EXCEPT EXIT AND EGRESS LIGHTING SHALL BE FED FROM EDP-117. EXIT AND EGRESS LUMINAIRES SHALL BE FED FROM SDP-126.
2. FOR LUMINAIRE SCHEDULE SEE SHEET E801.

KEYNOTES:


1. SEE MOUNTING DETAIL ON SHEET XXX.

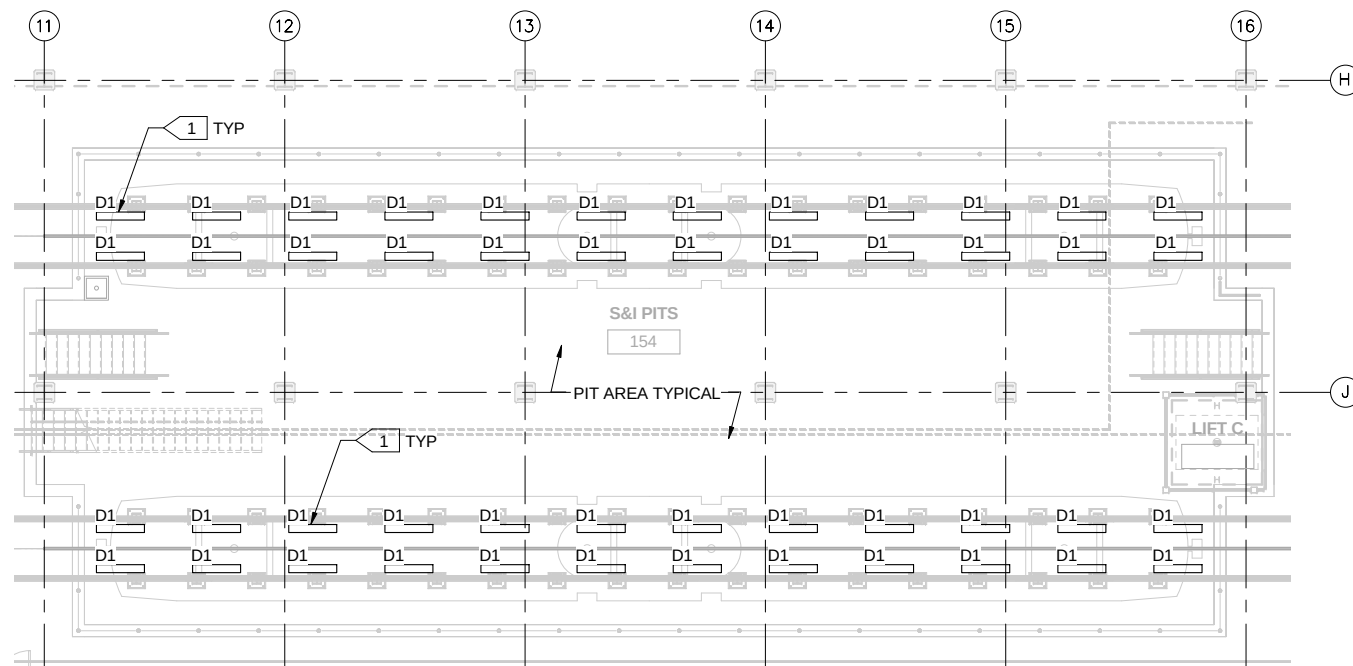

2 PIT LIGHTING
E200A SCALE: 1/8" = 1'-0"

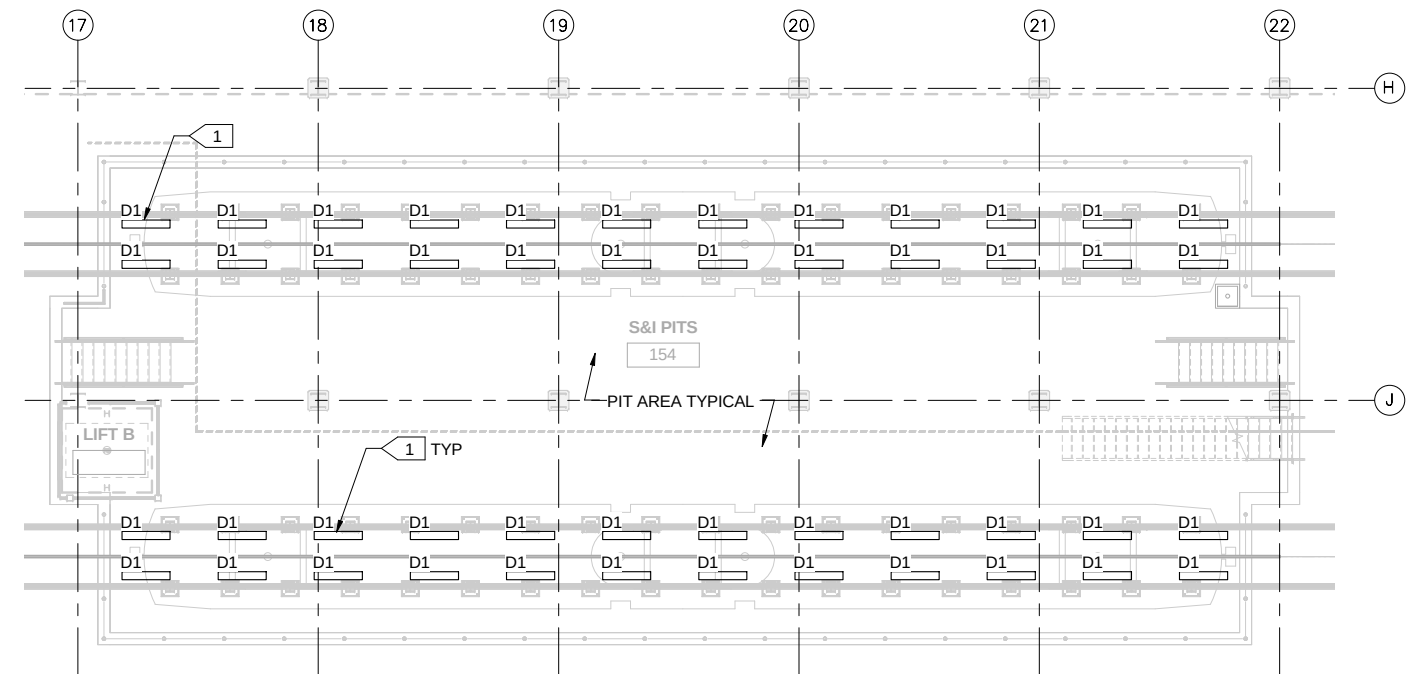

3 PIT LIGHTING
E200A SCALE: 1/8" = 1'-0"

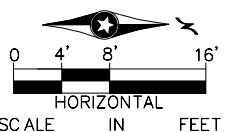

9/22/2015 10:09:47 AM C:\Users\V-Bege\B\Documents\OMF_ELEC_V-Bege\B.rvt

NO	DATE	BY	CHECK	DESIGN	REVISION / SUBMITTAL

			OPERATIONS & MAINTENANCE FACILITY - V2B ELECTRICAL LIGHTING - PIT LEVEL		SHEET 182 OF 263
	60% SUBMISSION - 9/28/15		DISCIPLINE: ELECTRICAL	SHEET NAME: OMF-ELE-PLN	E200A

1. ALL EXIT AND EGRESS LUMINAIRES SHALL BE FED FROM EDP-117.



KEY PLAN - SCALE: N.T.S.

SCALE IN FEET

[illegible]

METROPOLITAN COUNCIL

SOUTHWEST

**OPERATIONS & MAINTENANCE FACILITY - V2B
ELECTRICAL
LIGHTING - LEVEL ONE - AREA A**

DISCIPLINE:

ELECTRICAL


SHEET NAME:

OMF-ELE-PLN


E210A

3	SHEET
	183
	OF
	263

GENERAL NOTE:
1. ALL EXIT AND EGRESS LUMINAIRES
SHALL BE FED FROM EDP-117.

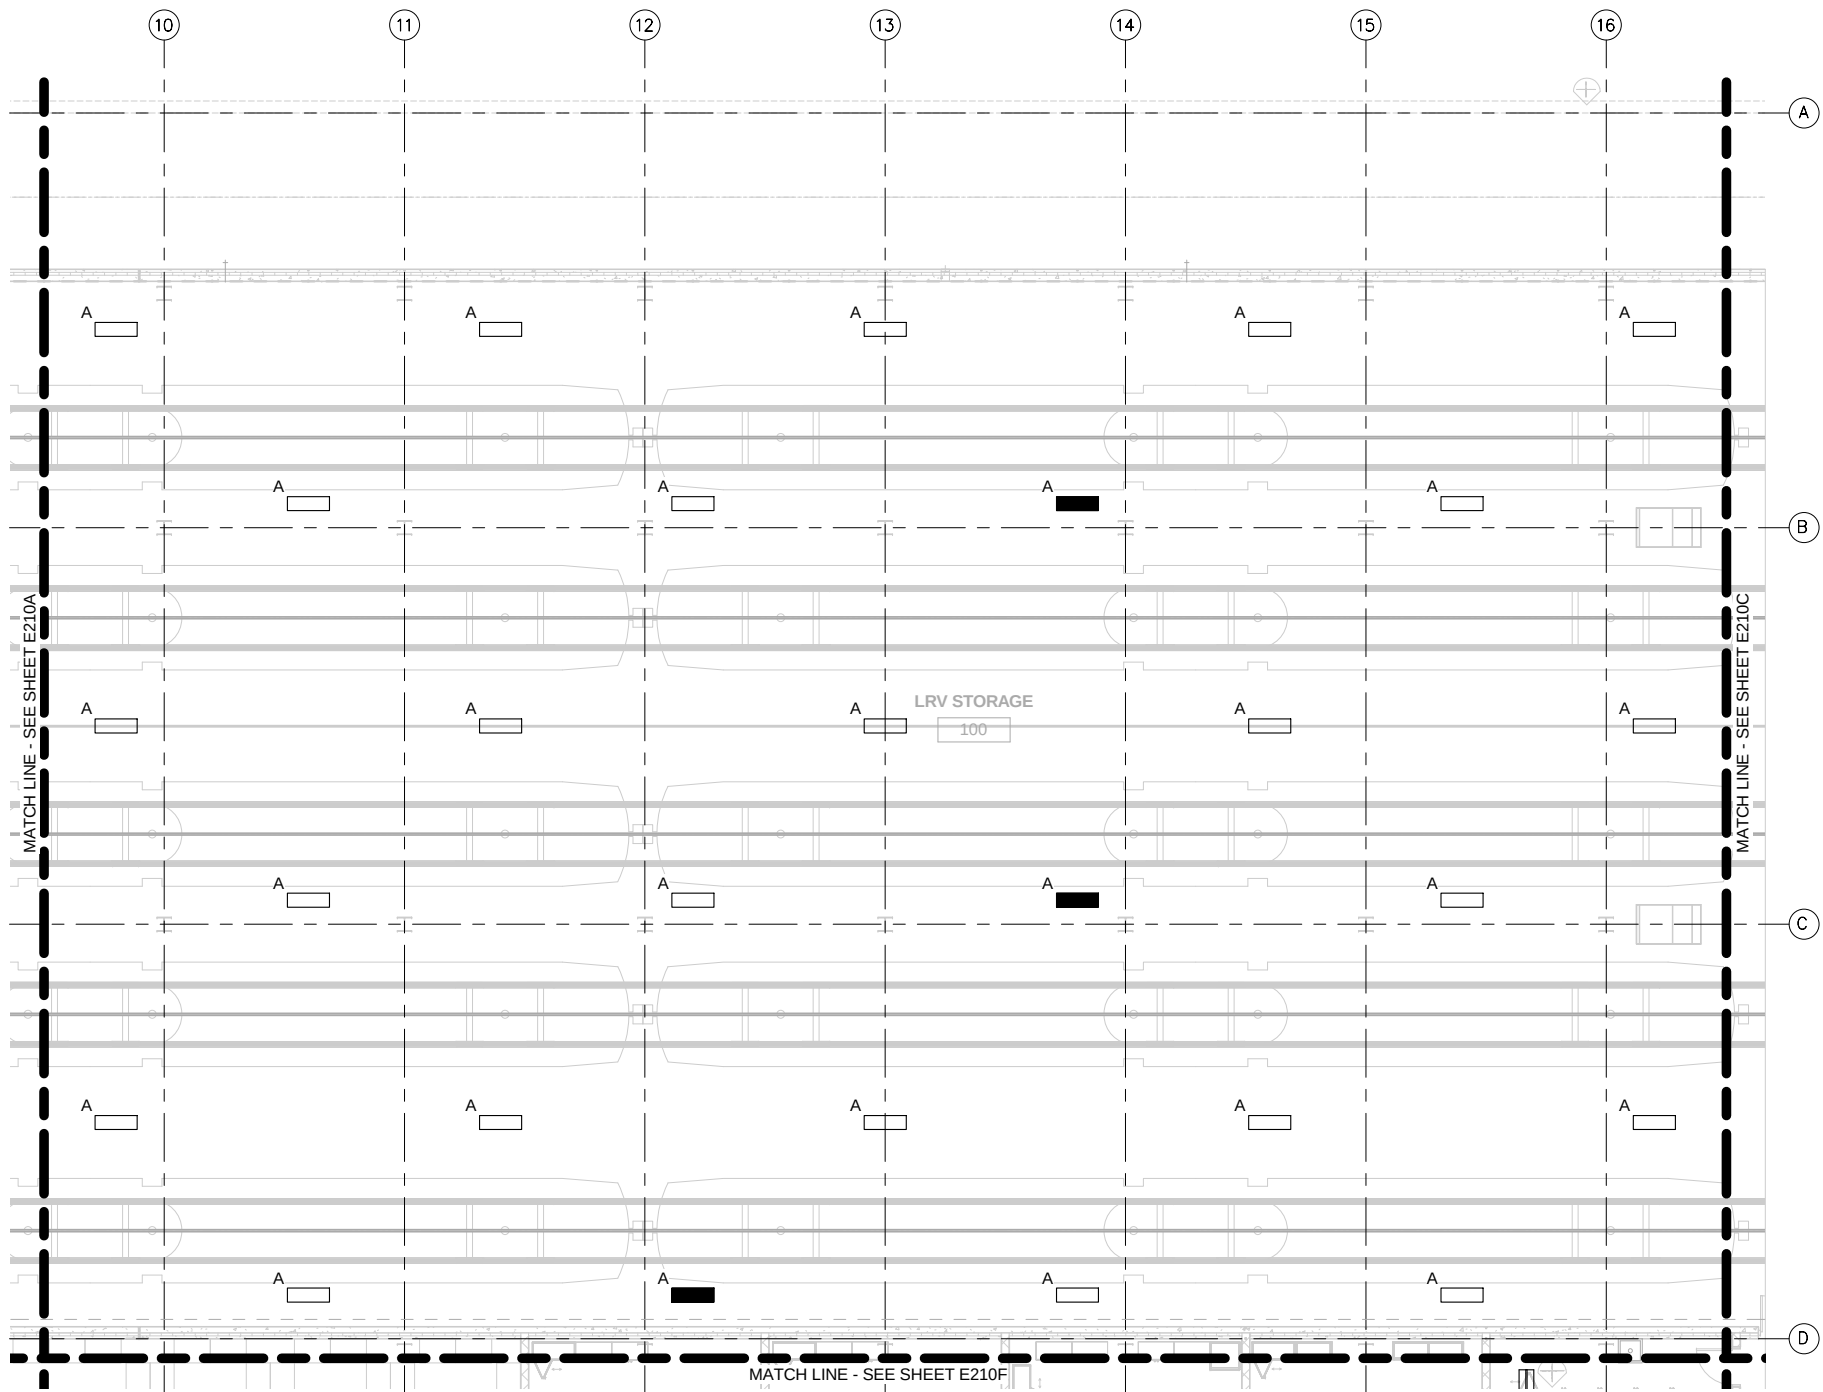

1 LIGHTING PLAN - AREA B
E210B SCALE: 1/8" = 1'-0"

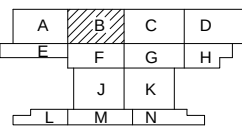

NO	DATE	BY	CHECK	DESIGN	REVISION / SUBMITTAL

AECOM

MP Consultants
CONSULTING ENGINEERING
MINNEAPOLIS, MINNESOTA

**METROPOLITAN COUNCIL**

**SOUTHWEST**

60% SUBMISSION - 9/28/15

OPERATIONS & MAINTENANCE FACILITY - V2B
ELECTRICAL
LIGHTING - LEVEL ONE - AREA B

DISCIPLINE: **ELECTRICAL**

SHEET NAME: **OMF-ELE-PLN E210B**


SHEET

184


OF

263

GENERAL NOTE:
1. ALL EXIT AND EGRESS LUMINAIRES
SHALL BE FED FROM EDP-117.

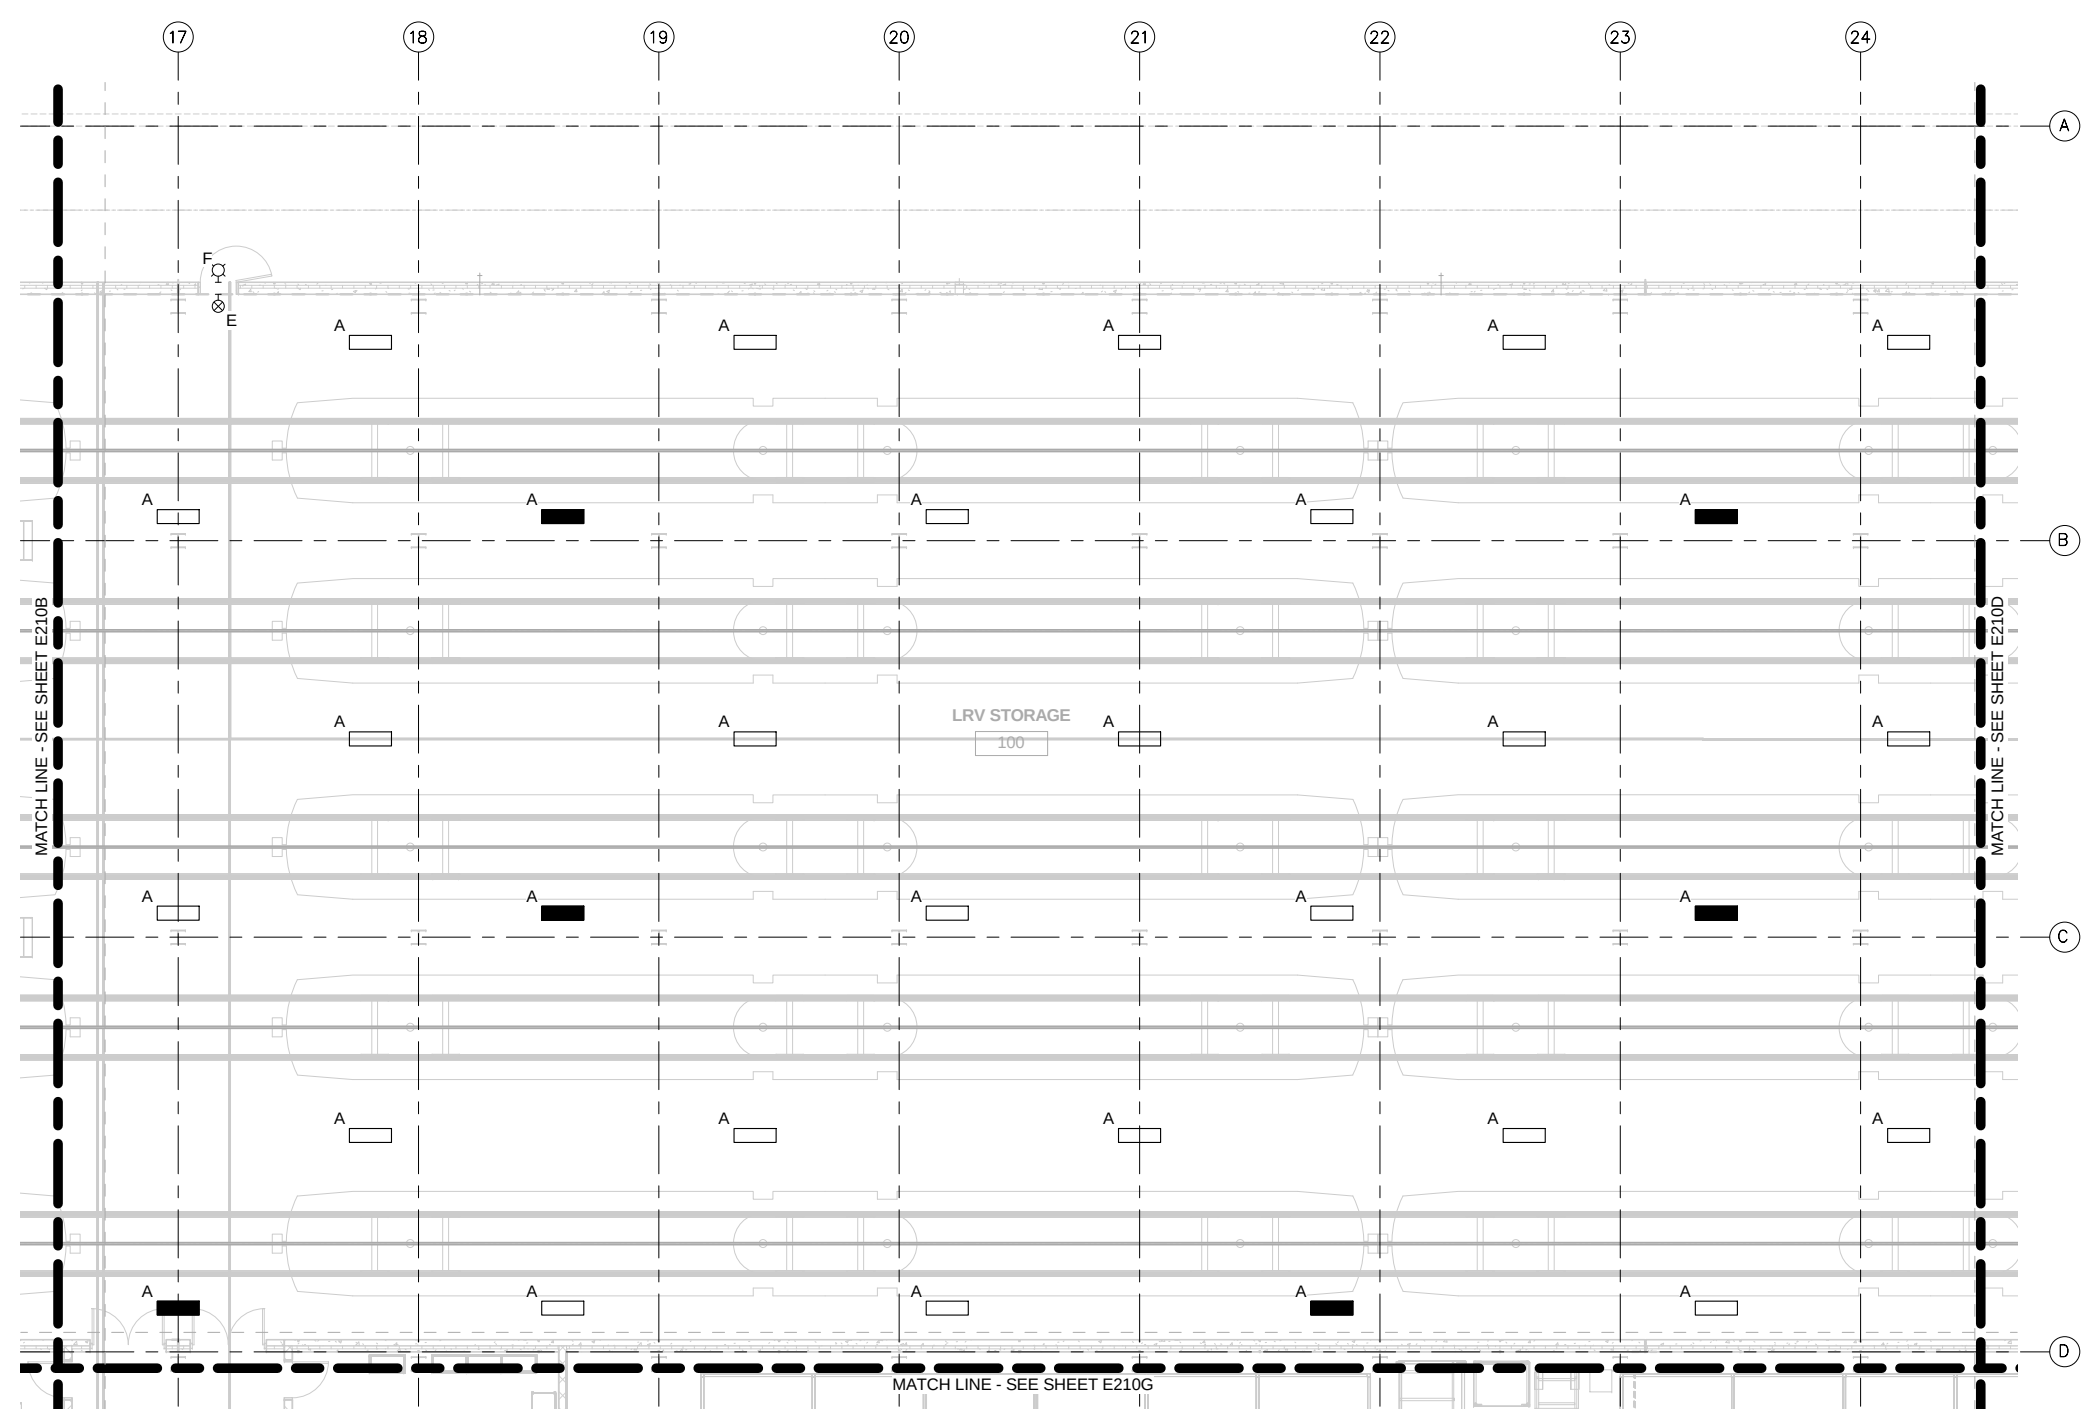

1 LIGHTING PLAN - AREA C
E210C SCALE: 1/8" = 1'-0"

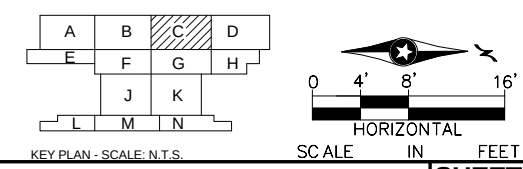

NO	DATE	BY	CHECK	DESIGN	REVISION / SUBMITTAL

AECOM

MP Consultants
CONSULTING ENGINEERING
MINNEAPOLIS, MINNESOTA

METROPOLITAN
COUNCIL

SOUTHWEST

60% SUBMISSION - 9/28/15

OPERATIONS & MAINTENANCE FACILITY - V2B
ELECTRICAL
LIGHTING - LEVEL ONE - AREA C


DISCIPLINE: ELECTRICAL

SHEET NAME: OMF-ELE-PLN

E210C

SHEET
185
OF
263

1. ALL EXIT AND EGRESS LUMINAIRES SHALL BE FED FROM EDP-117.

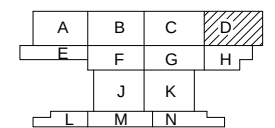[illegible]


METROPOLITAN COUNCIL

SOUTHWEST

DISCIPLINE:	SHEET NAME:	
ELECTRICAL	OMF-ELE-PLN	E210D

186
OF
263

1. ALL EXIT AND EGRESS LUMINAIRES SHALL BE FED FROM EDP-117.

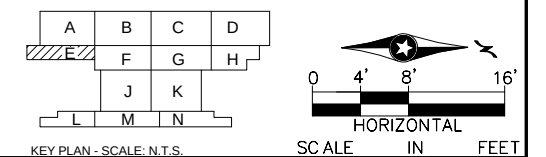
[illegible]

METROPOLITAN COUNCIL


SOUTHWEST

OPERATIONS & MAINTENANCE FACILITY - V2B ELECTRICAL LIGHTING - LEVEL ONE - AREA E			SHEET 187 OF 263
DISCIPLINE: ELECTRICAL	SHEET NAME: OMF-ELE-PLN	E210E	

GENERAL NOTE:
1. ALL EXIT AND EGRESS LUMINAIRES
SHALL BE FED FROM EDP-117.

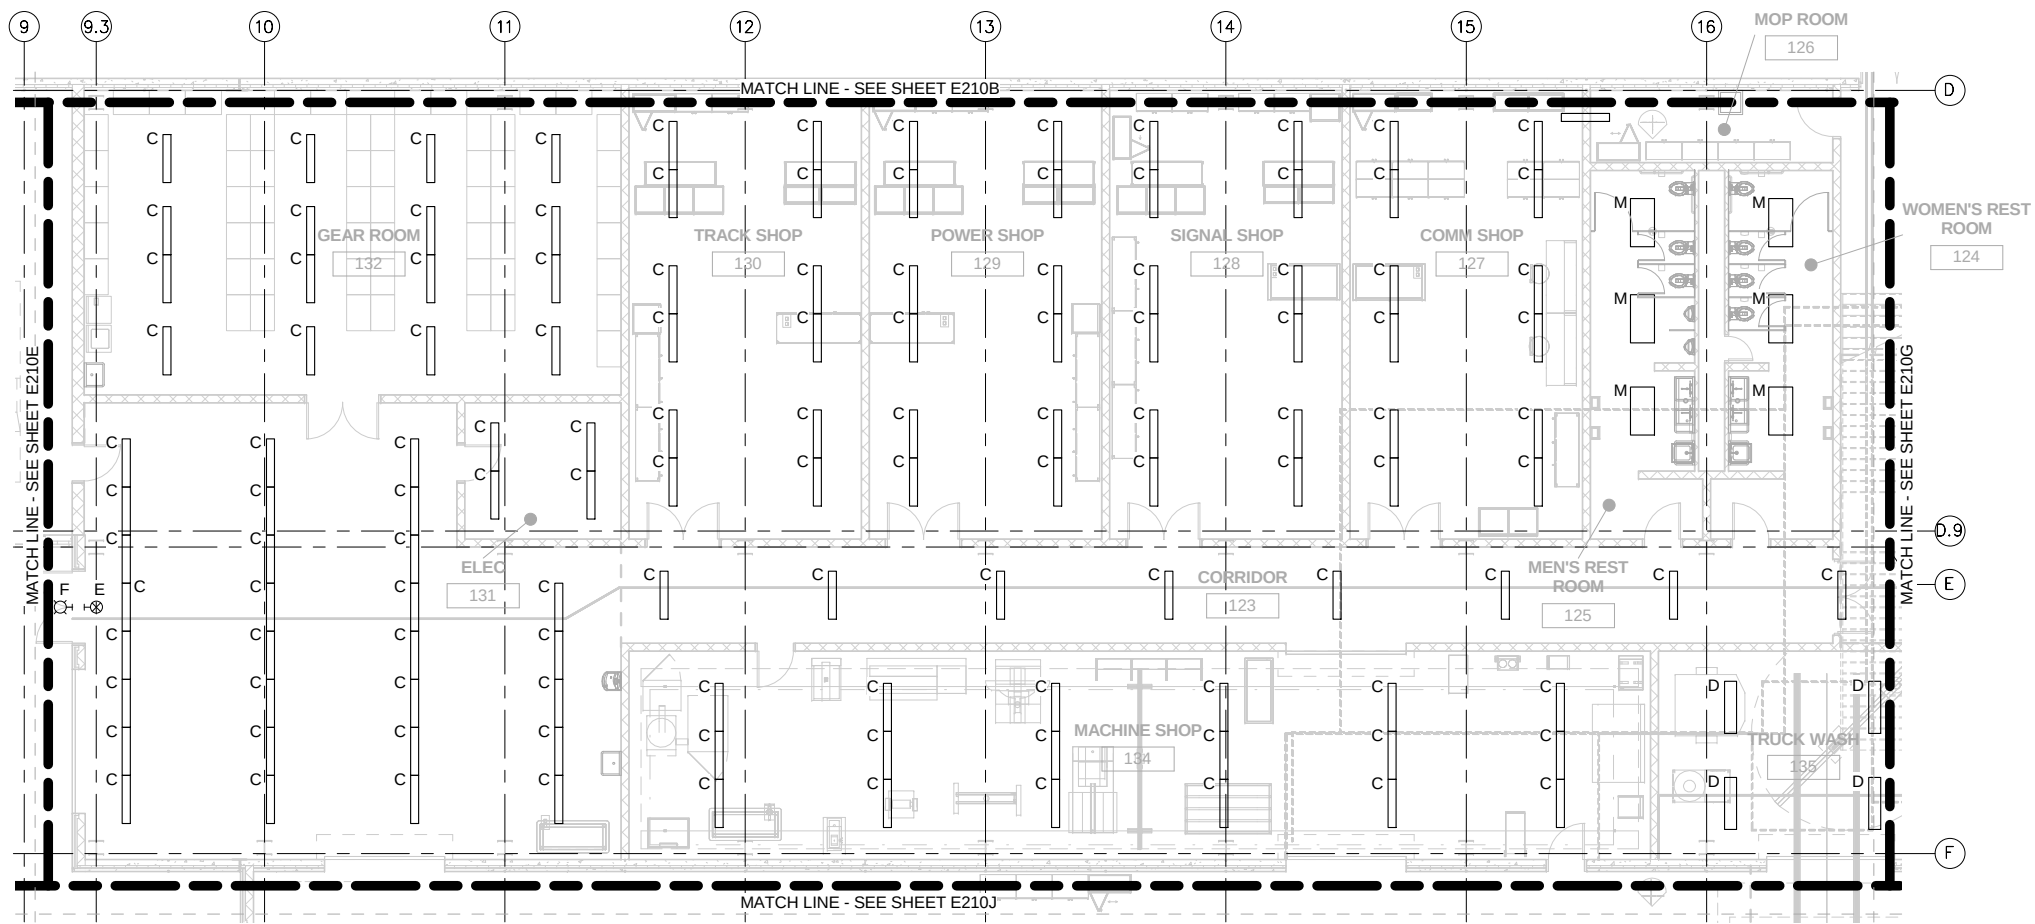

1 LIGHTING PLAN - AREA F
E210F SCALE: 1/8" = 1'-0"

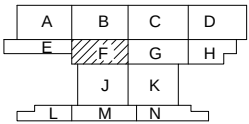

NO	DATE	BY	CHECK	DESIGN	REVISION / SUBMITTAL

AECOM

MP Consultants
CONSULTING ENGINEERING
MINNEAPOLIS, MINNESOTA

60% SUBMISSION - 9/28/15

**METROPOLITAN
COUNCIL**

**SOUTHWEST**

OPERATIONS & MAINTENANCE FACILITY - V2B
ELECTRICAL
LIGHTING - LEVEL ONE - AREA F

DISCIPLINE: ELECTRICAL

SHEET NAME: OMF-ELE-PLN

E210F

SHEET
188
OF
263

1. ALL EXIT AND EGRESS LUMINAIRES SHALL BE FED FROM EDP-117.



SCALE	IN	FEET
-------	----	------

[illegible]


METROPOLITAN COUNCIL

SOUTHWEST


DISCIPLINE:	SHEET NAME:	
ELECTRICAL	OMF-ELE-PLN	E210G

189
OF
263

GENERAL NOTE:
1. ALL EXIT AND EGRESS LUMINAIRES
SHALL BE FED FROM EDP-117.

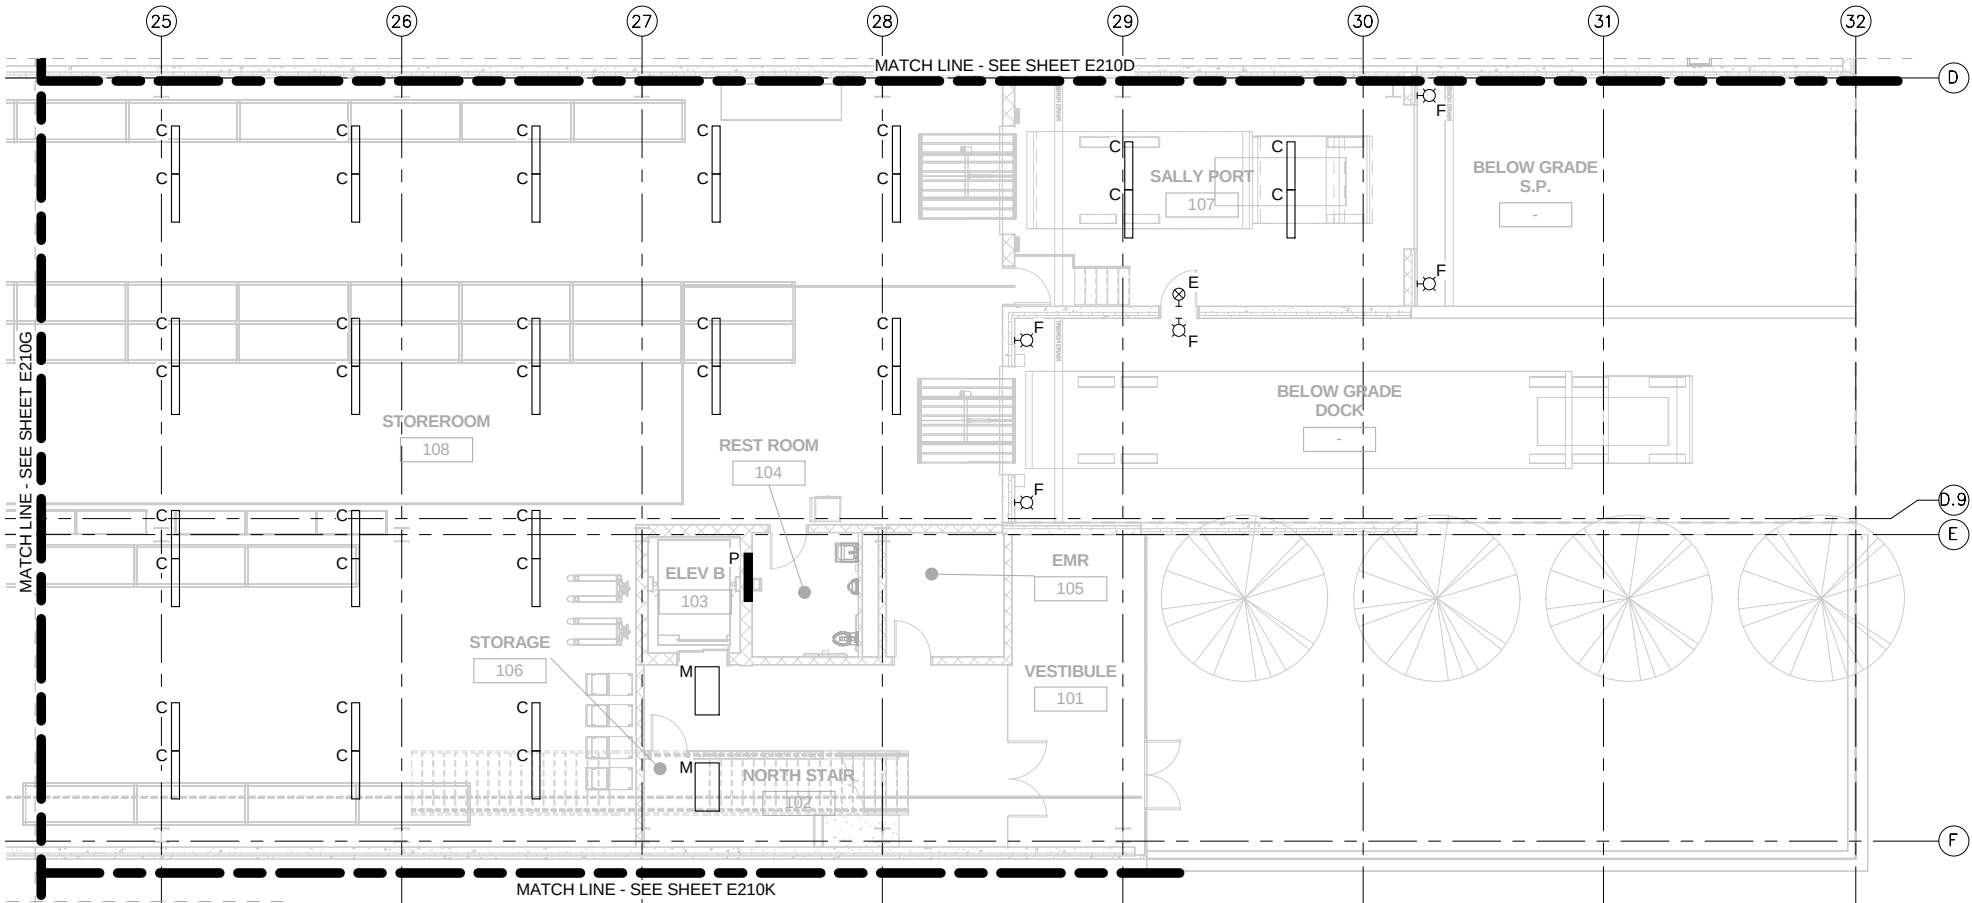

1 LIGHTING PLAN - AREA H
E210H/ SCALE: 1/8" = 1'-0"

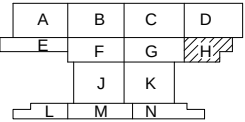

NO	DATE	BY	CHECK	DESIGN	REVISION / SUBMITTAL

AECOM

MP Consultants
CONSULTING ENGINEERING
MINNEAPOLIS, MINNESOTA

60% SUBMISSION - 9/28/15

**METROPOLITAN COUNCIL**

**SOUTHWEST**

OPERATIONS & MAINTENANCE FACILITY - V2B

ELECTRICAL

LIGHTING - LEVEL ONE - AREA H

DISCIPLINE: **ELECTRICAL**

SHEET NAME: **OMF-ELE-PLN**

E210H

SHEET


190

OF


263

9/22/2015 10:10:19 AM C:\Users\V-Bege\B\Documents\OMF_ELEC_V-Bege\B.rvt

GENERAL NOTE:
1. ALL EXIT AND EGRESS LUMINAIRES
SHALL BE FED FROM EDP-117.

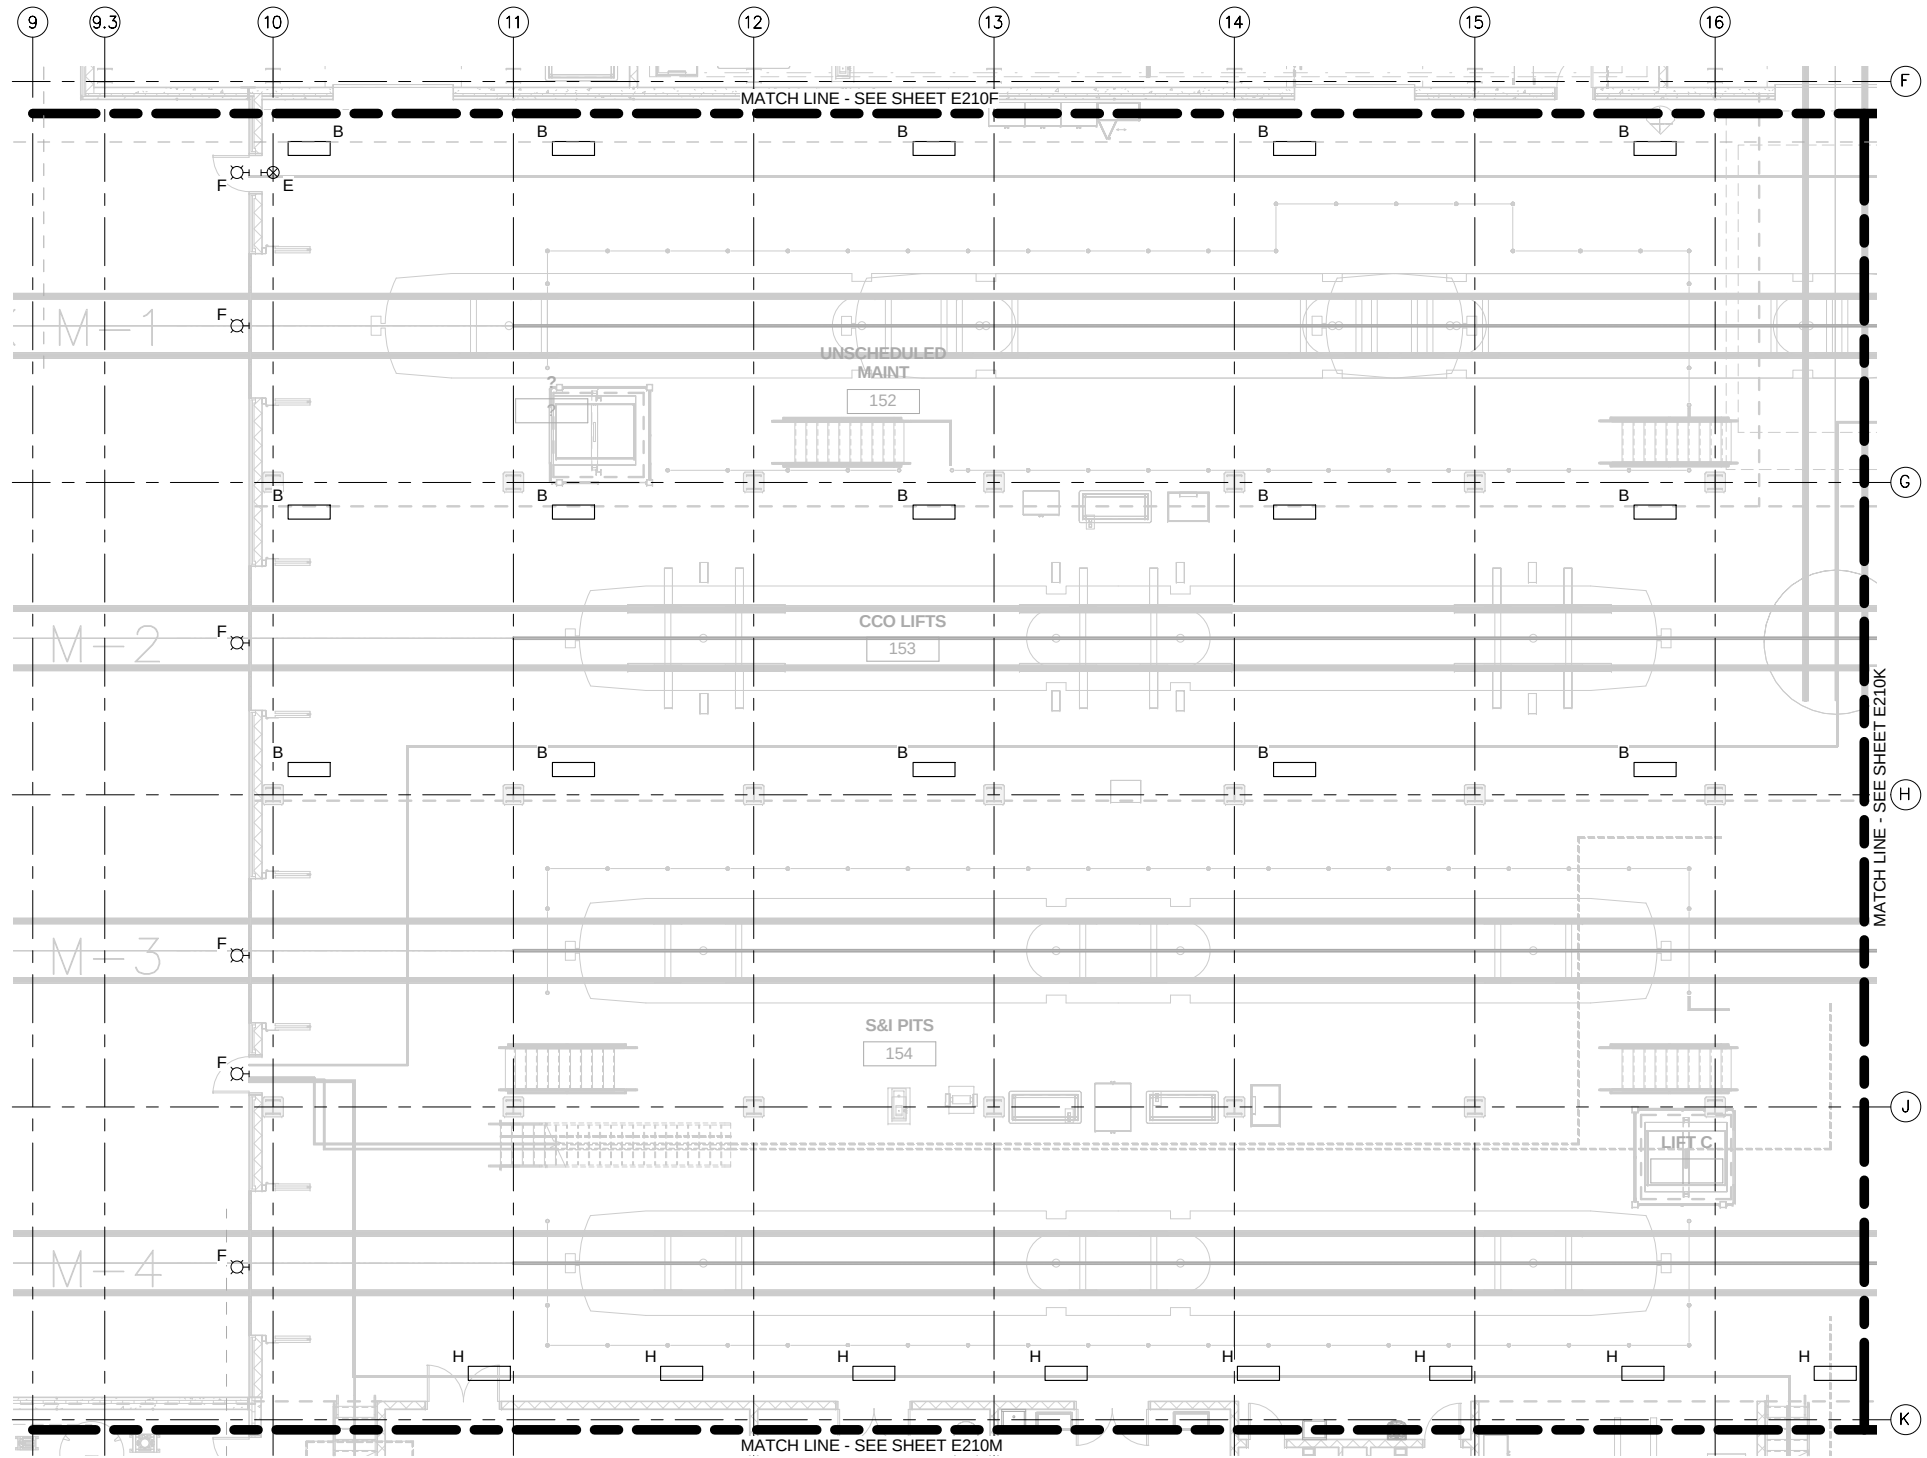

1 LIGHTING PLAN - AREA J
E210J SCALE: 1/8" = 1'-0"

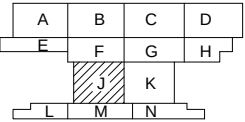


NO	DATE	BY	CHECK	DESIGN	REVISION / SUBMITTAL


 AECOM MP Consultants CONSULTING ENGINEERING MINNEAPOLIS, MINNESOTA	 METROPOLITAN COUNCIL	 SOUTHWEST	OPERATIONS & MAINTENANCE FACILITY - V2B			SHEET 191 OF 263
			ELECTRICAL			
60% SUBMISSION - 9/28/15			LIGHTING - LEVEL ONE - AREA J			
DISCIPLINE: ELECTRICAL			SHEET NAME: OMF-ELE-PLN		E210J	

9/22/2015 10:10:22 AM C:\Users\jv-Beggs\Documents\OMF_ELEC_V-Beggs\B.rvt

GENERAL NOTE:
1. ALL EXIT AND EGRESS LUMINAIRES
SHALL BE FED FROM EDP-117.

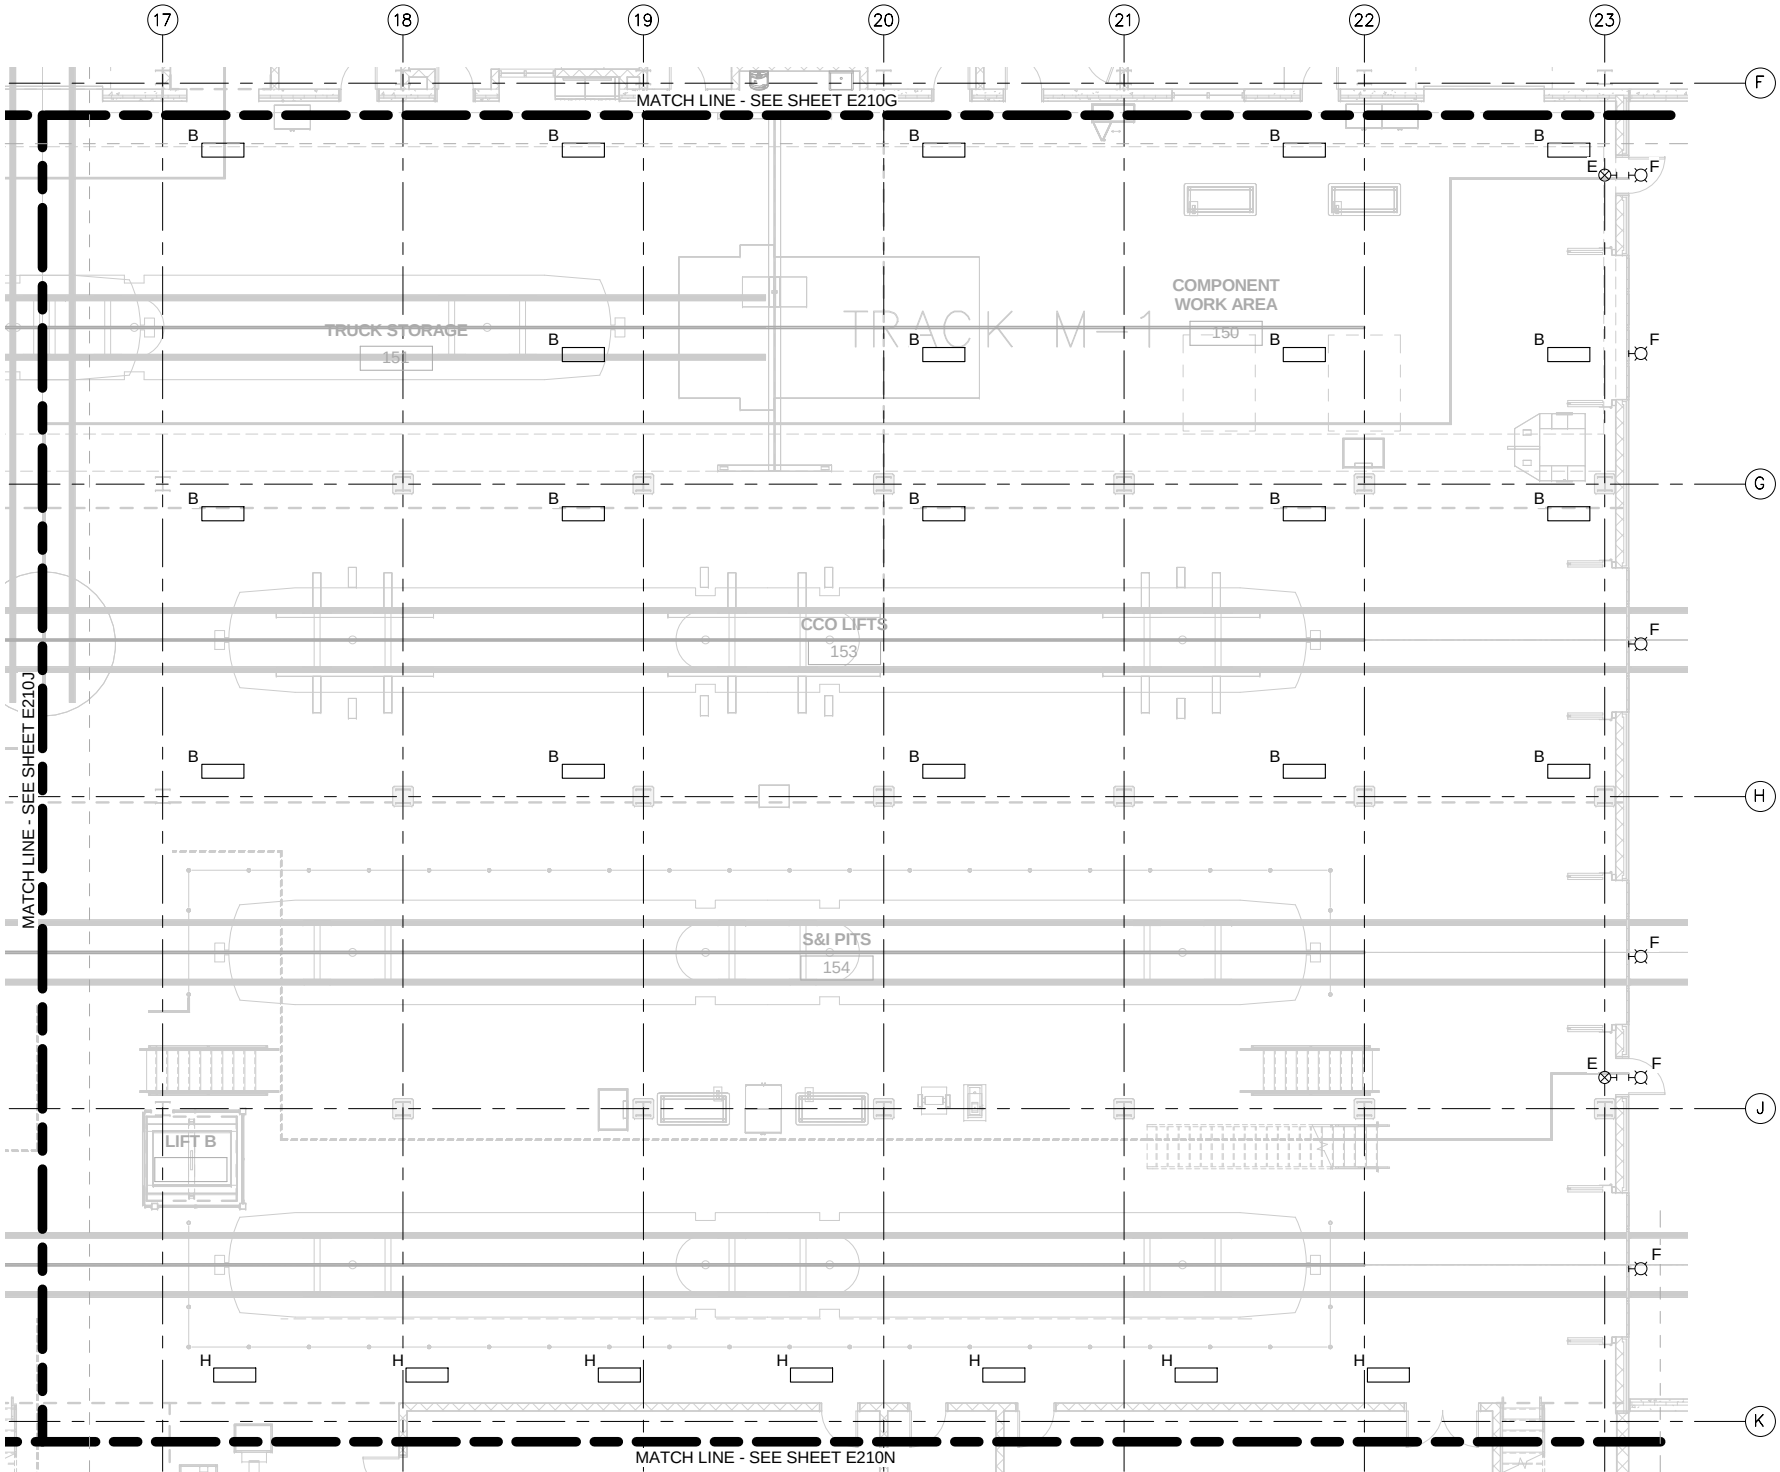

1 LIGHTING PLAN - AREA K
E210K/ SCALE: 1/8" = 1'-0"

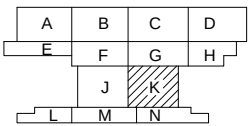

NO	DATE	BY	CHECK	DESIGN	REVISION / SUBMITTAL

AECOM

MP Consultants
CONSULTING ENGINEERING
MINNEAPOLIS, MINNESOTA

60% SUBMISSION - 9/28/15

METROPOLITAN
COUNCIL

SOUTHWEST

OPERATIONS & MAINTENANCE FACILITY - V2B
ELECTRICAL
LIGHTING - LEVEL ONE - AREA K

DISCIPLINE: ELECTRICAL

SHEET NAME: OMF-ELE-PLN

E210K

SHEET
192
OF
263

1. ALL EXIT AND EGRESS LUMINAIRES SHALL BE FED FROM EDP-117.



SCALE	IN	FEET
-------	----	------

[illegible]


METROPOLITAN COUNCIL

SOUTHWEST

E210L

193
OF
263

1. ALL EXIT AND EGRESS LUMINAIRES SHALL BE FED FROM EDP-117.

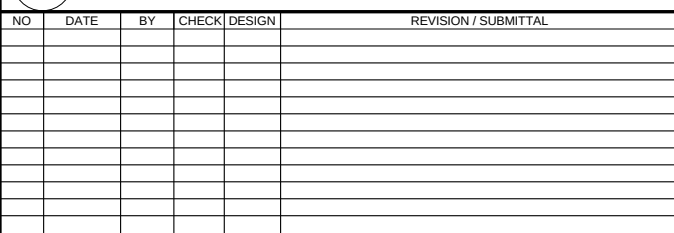

METROPOLITAN COUNCIL

SOUTHWEST

DISCIPLINE:	SHEET NAME:	
ELECTRICAL	OMF-ELE-PLN	E210M

194
OF
263


1. ALL EXIT AND EGRESS LUMINAIRES SHALL BE FED FROM EDP-117.

[illegible]

60% SUBMISSION - 9/28/15




OPERATIONS & MAINTENANCE FACILITY - V2B ELECTRICAL LIGHTING - LEVEL ONE - AREA N		
DISCIPLINE: ELECTRICAL	SHEET NAME: OMF-ELE-PLN	E210N

 

SCALE IN FEET

GENERAL NOTE:
1. ALL EXIT AND EGRESS LUMINAIRES
SHALL BE FED FROM EDP-117.

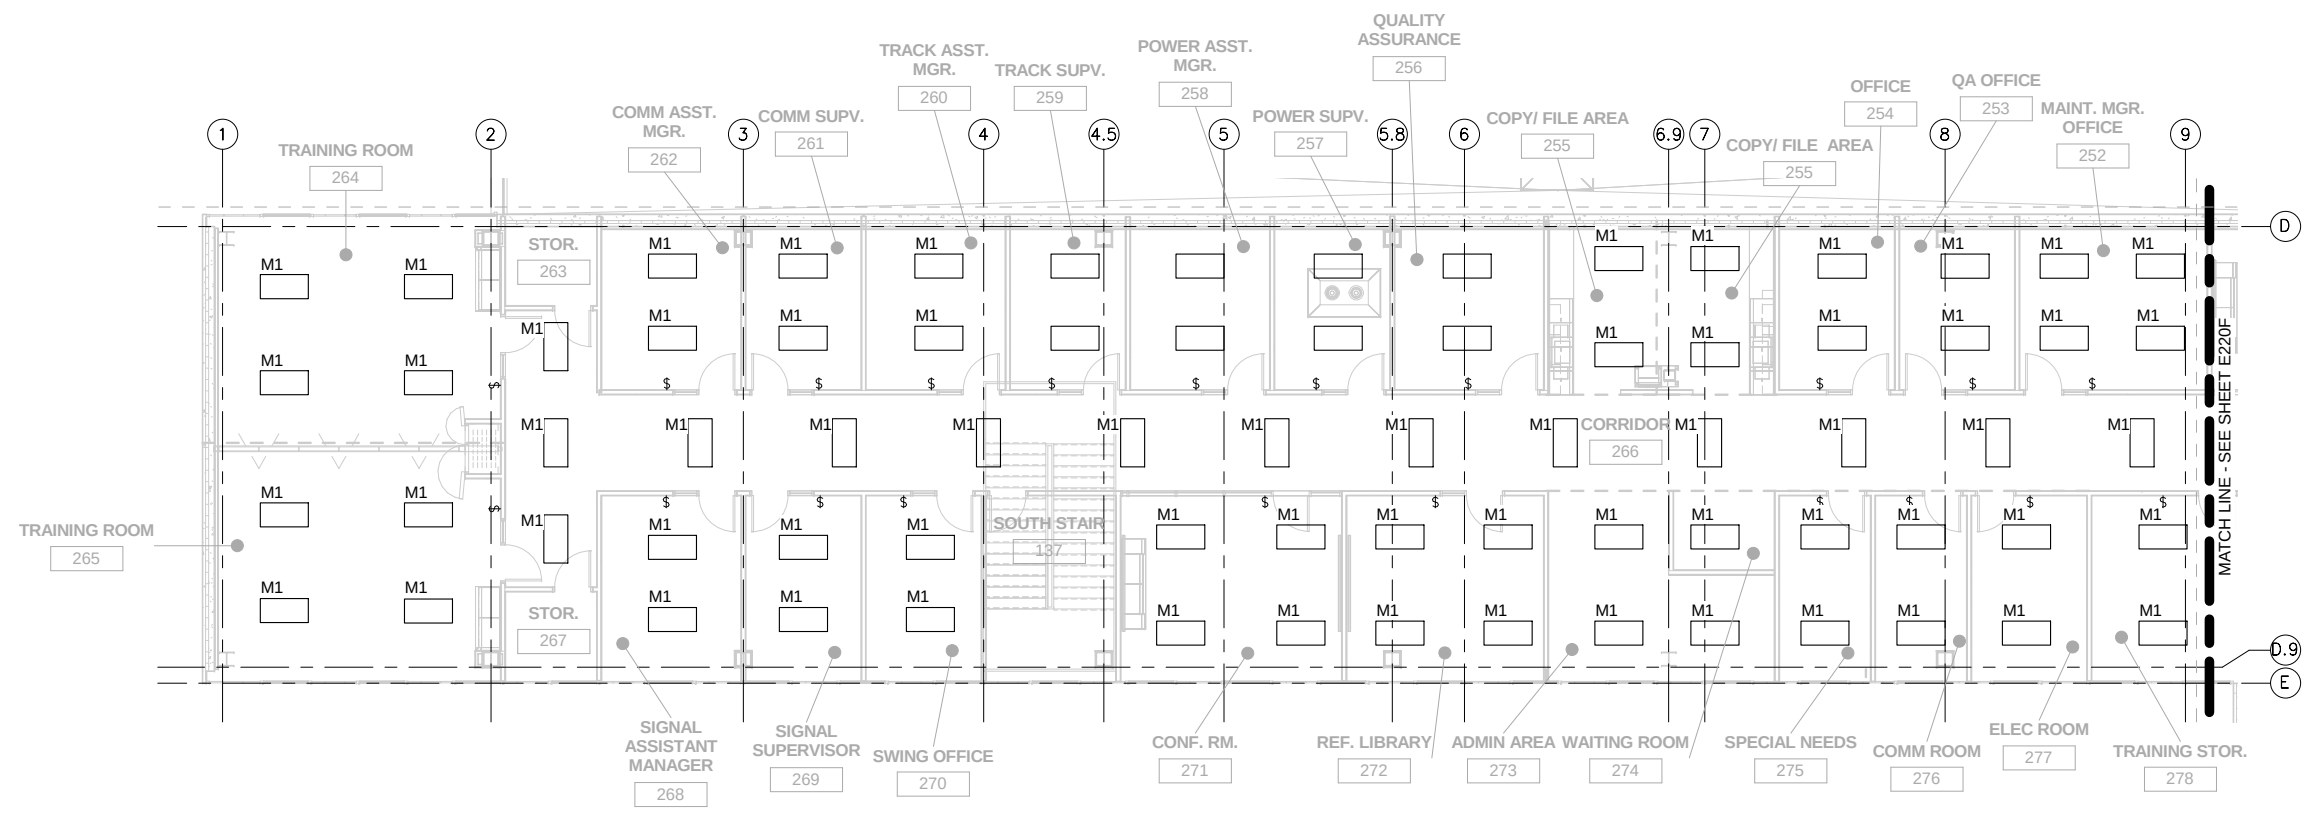

1 LIGHTING PLAN - AREA E
E220E SCALE: 1/8" = 1'-0"

NO	DATE	BY	CHECK	DESIGN	REVISION / SUBMITTAL

AECOM

MP Consultants
CONSULTING ENGINEERING
MINNEAPOLIS, MINNESOTA


60% SUBMISSION - 9/28/15

**METROPOLITAN**
COUNCIL

**SOUTHWEST**

OPERATIONS & MAINTENANCE FACILITY - V2B ELECTRICAL LIGHTING - LEVEL TWO - AREA E			SHEET 196 OF 263
DISCIPLINE: ELECTRICAL	SHEET NAME: OMF-ELE-PLN	E220E	

GENERAL NOTE:
1. ALL EXIT AND EGRESS LUMINAIRES
SHALL BE FED FROM EDP-117.

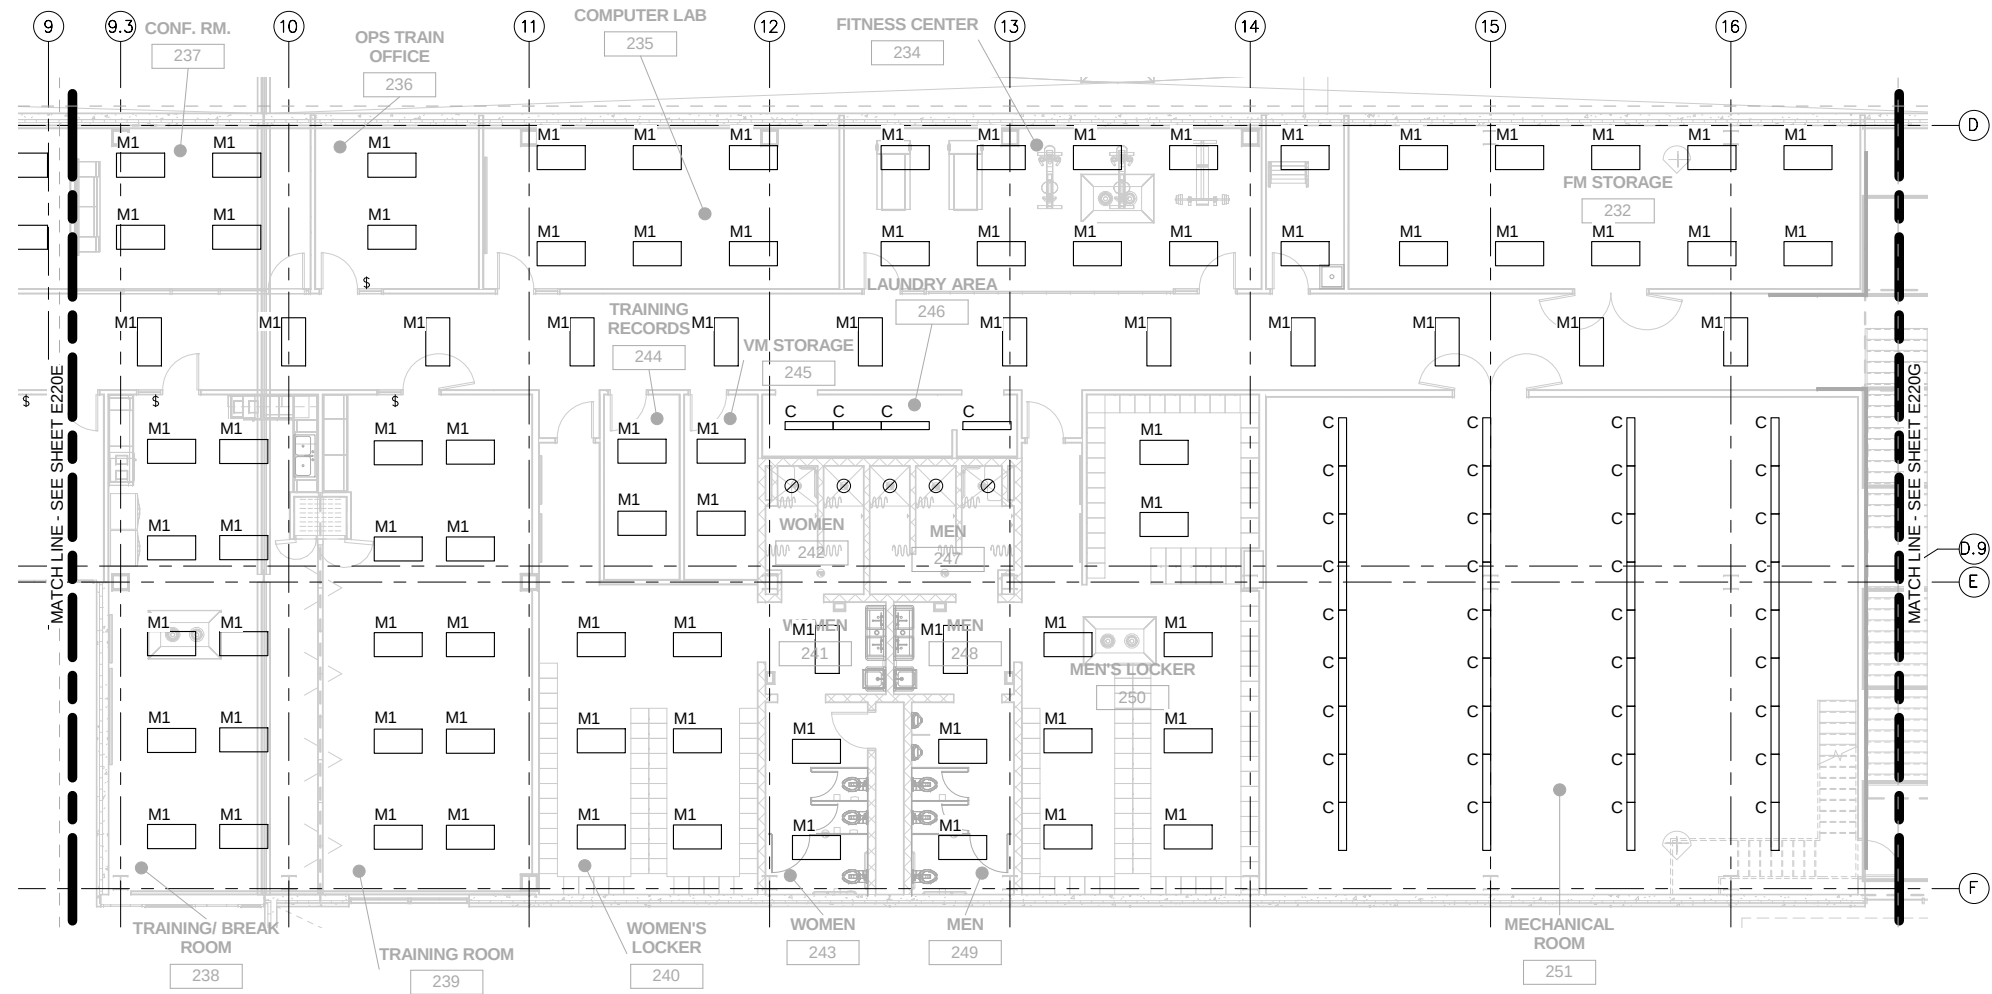

1 LIGHTING PLAN - AREA F
E220F SCALE: 1/8" = 1'-0"

NO	DATE	BY	CHECK	DESIGN	REVISION / SUBMITTAL

AECOM

MP Consultants
CONSULTING ENGINEERING
MINNEAPOLIS, MINNESOTA

**METROPOLITAN COUNCIL**

**SOUTHWEST**

60% SUBMISSION - 9/28/15

OPERATIONS & MAINTENANCE FACILITY - V2B

ELECTRICAL

LIGHTING - LEVEL TWO - AREA F

DISCIPLINE: **ELECTRICAL**

SHEET NAME: **OMF-ELE-PLN**

E220F


SHEET

197


OF

263

GENERAL NOTE:
1. ALL EXIT AND EGRESS LUMINAIRES
SHALL BE FED FROM EDP-117.

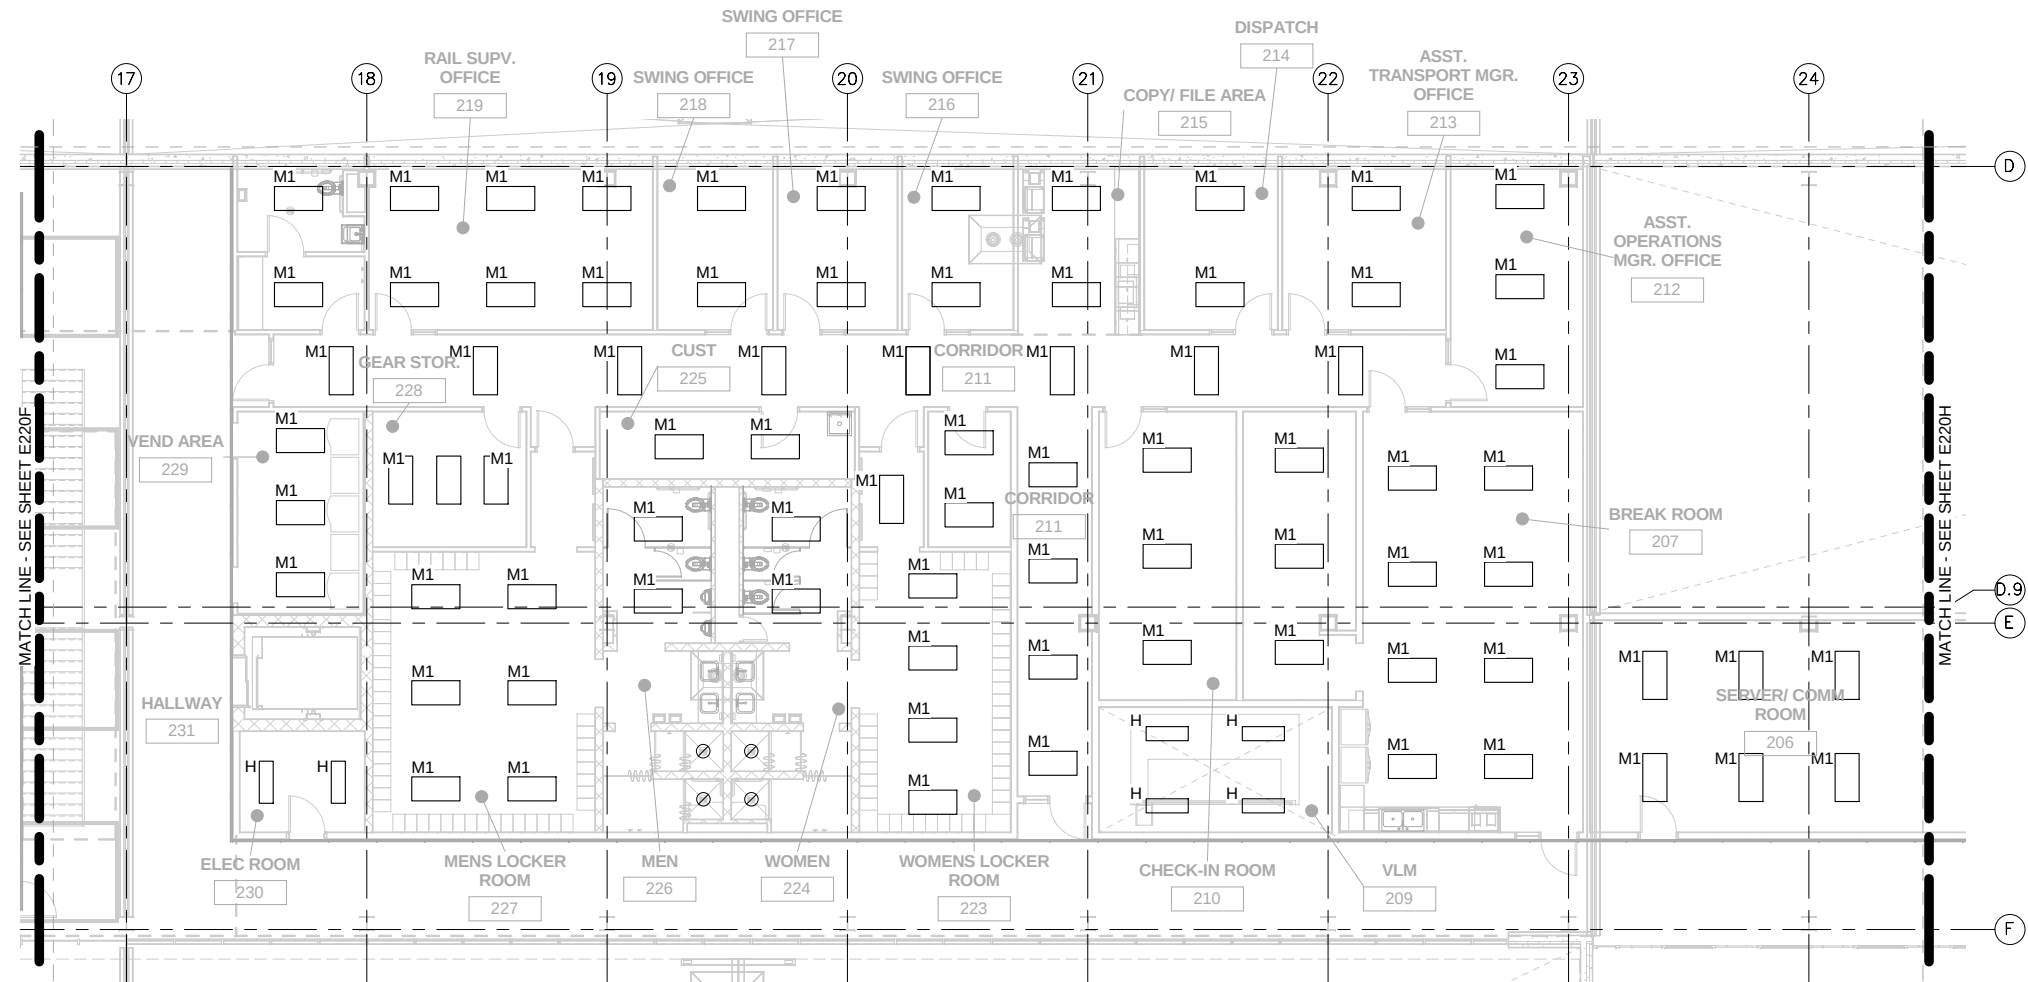

1 LIGHTING PLAN - AREA G
E220G SCALE: 1/8" = 1'-0"

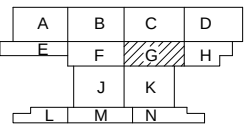

NO	DATE	BY	CHECK	DESIGN	REVISION / SUBMITTAL

AECOM
CONSULTING ENGINEERING
MINNEAPOLIS, MINNESOTA

MP Consultants
CONSULTING ENGINEERING
MINNEAPOLIS, MINNESOTA

60% SUBMISSION - 9/28/15

**METROPOLITAN
COUNCIL**

**SOUTHWEST**

OPERATIONS & MAINTENANCE FACILITY - V2B
ELECTRICAL
LIGHTING - LEVEL TWO - AREA G

DISCIPLINE: **ELECTRICAL**


SHEET NAME: **OMF-ELE-PLN**

E220G


SHEET
198
OF
263

9/22/2015 10:10:42 AM C:\Users\J\B\Documents\OMF_ELEC_V\BegeJB.rvt

GENERAL NOTE:
1. ALL EXIT AND EGRESS LUMINAIRES
SHALL BE FED FROM EDP-117.

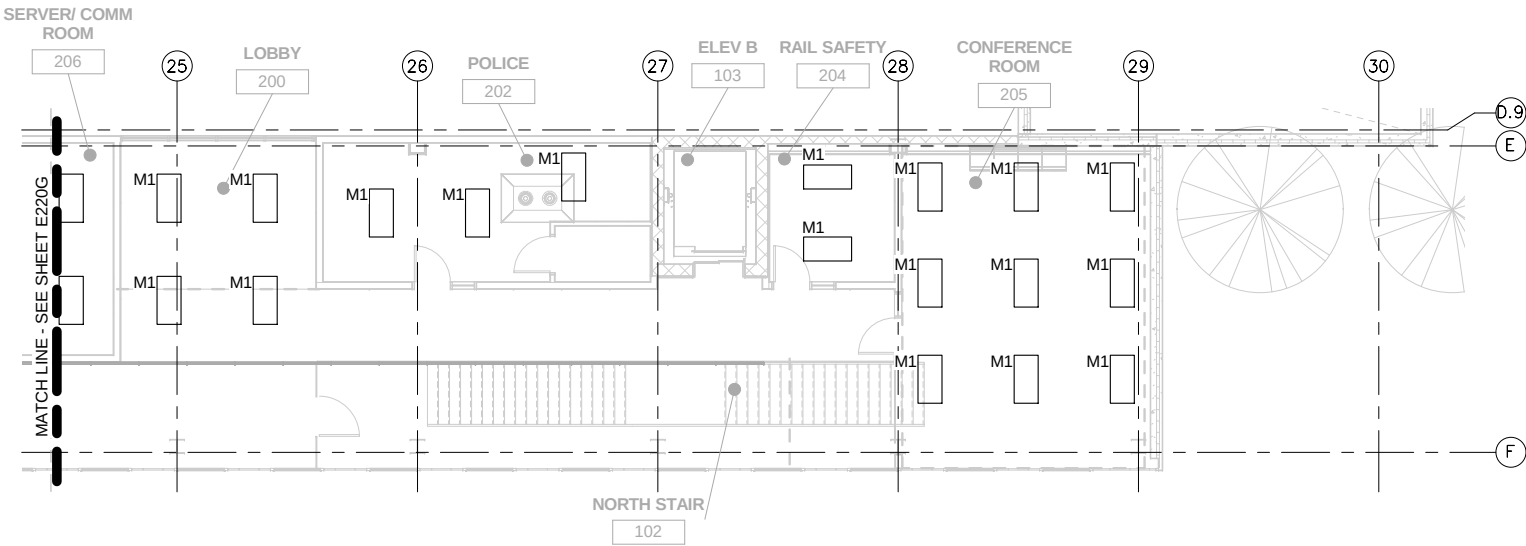

1 LIGHTING PLAN - AREA H
E220H SCALE: 1/8" = 1'-0"

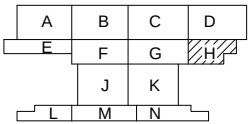

NO	DATE	BY	CHECK	DESIGN	REVISION / SUBMITTAL

AECOM

MP Consultants
CONSULTING ENGINEERING
MINNEAPOLIS • MINNESOTA

60% SUBMISSION - 9/28/15

METROPOLITAN
COUNCIL

SOUTHWEST

OPERATIONS & MAINTENANCE FACILITY - V2B
ELECTRICAL
LIGHTING - LEVEL TWO - AREA H

 
DISCIPLINE: ELECTRICAL

SHEET NAME: OMF-ELE-PLN

E220H


SHEET
199
OF
263

1. CONDUITS NOT SHOWN ON THIS SHEET.
2. RUN AND TERMINATE TWO CAT-6 CABLES TO ALL NETWORK OUTLETS EXCEPT WHERE OTHERWISE NOTED.



SCALE IN FEET

 [illegible]






OPERATIONS & MAINTENANCE FACILITY - V2B ELECTRICAL SYSTEMS - LEVEL ONE - AREA A	S
---	---

DISCIPLINE:	SHEET NAME:	
ELECTRICAL	OMF-ELE-PLN	E310A

200
OF
263

2. RUN AND TERMINATE TWO CAT-6 CABLES TO ALL NETWORK OUTLETS EXCEPT WHERE OTHERWISE NOTED.

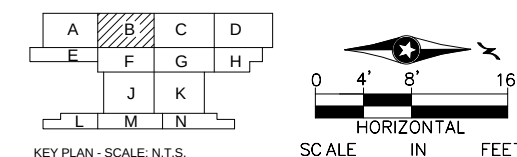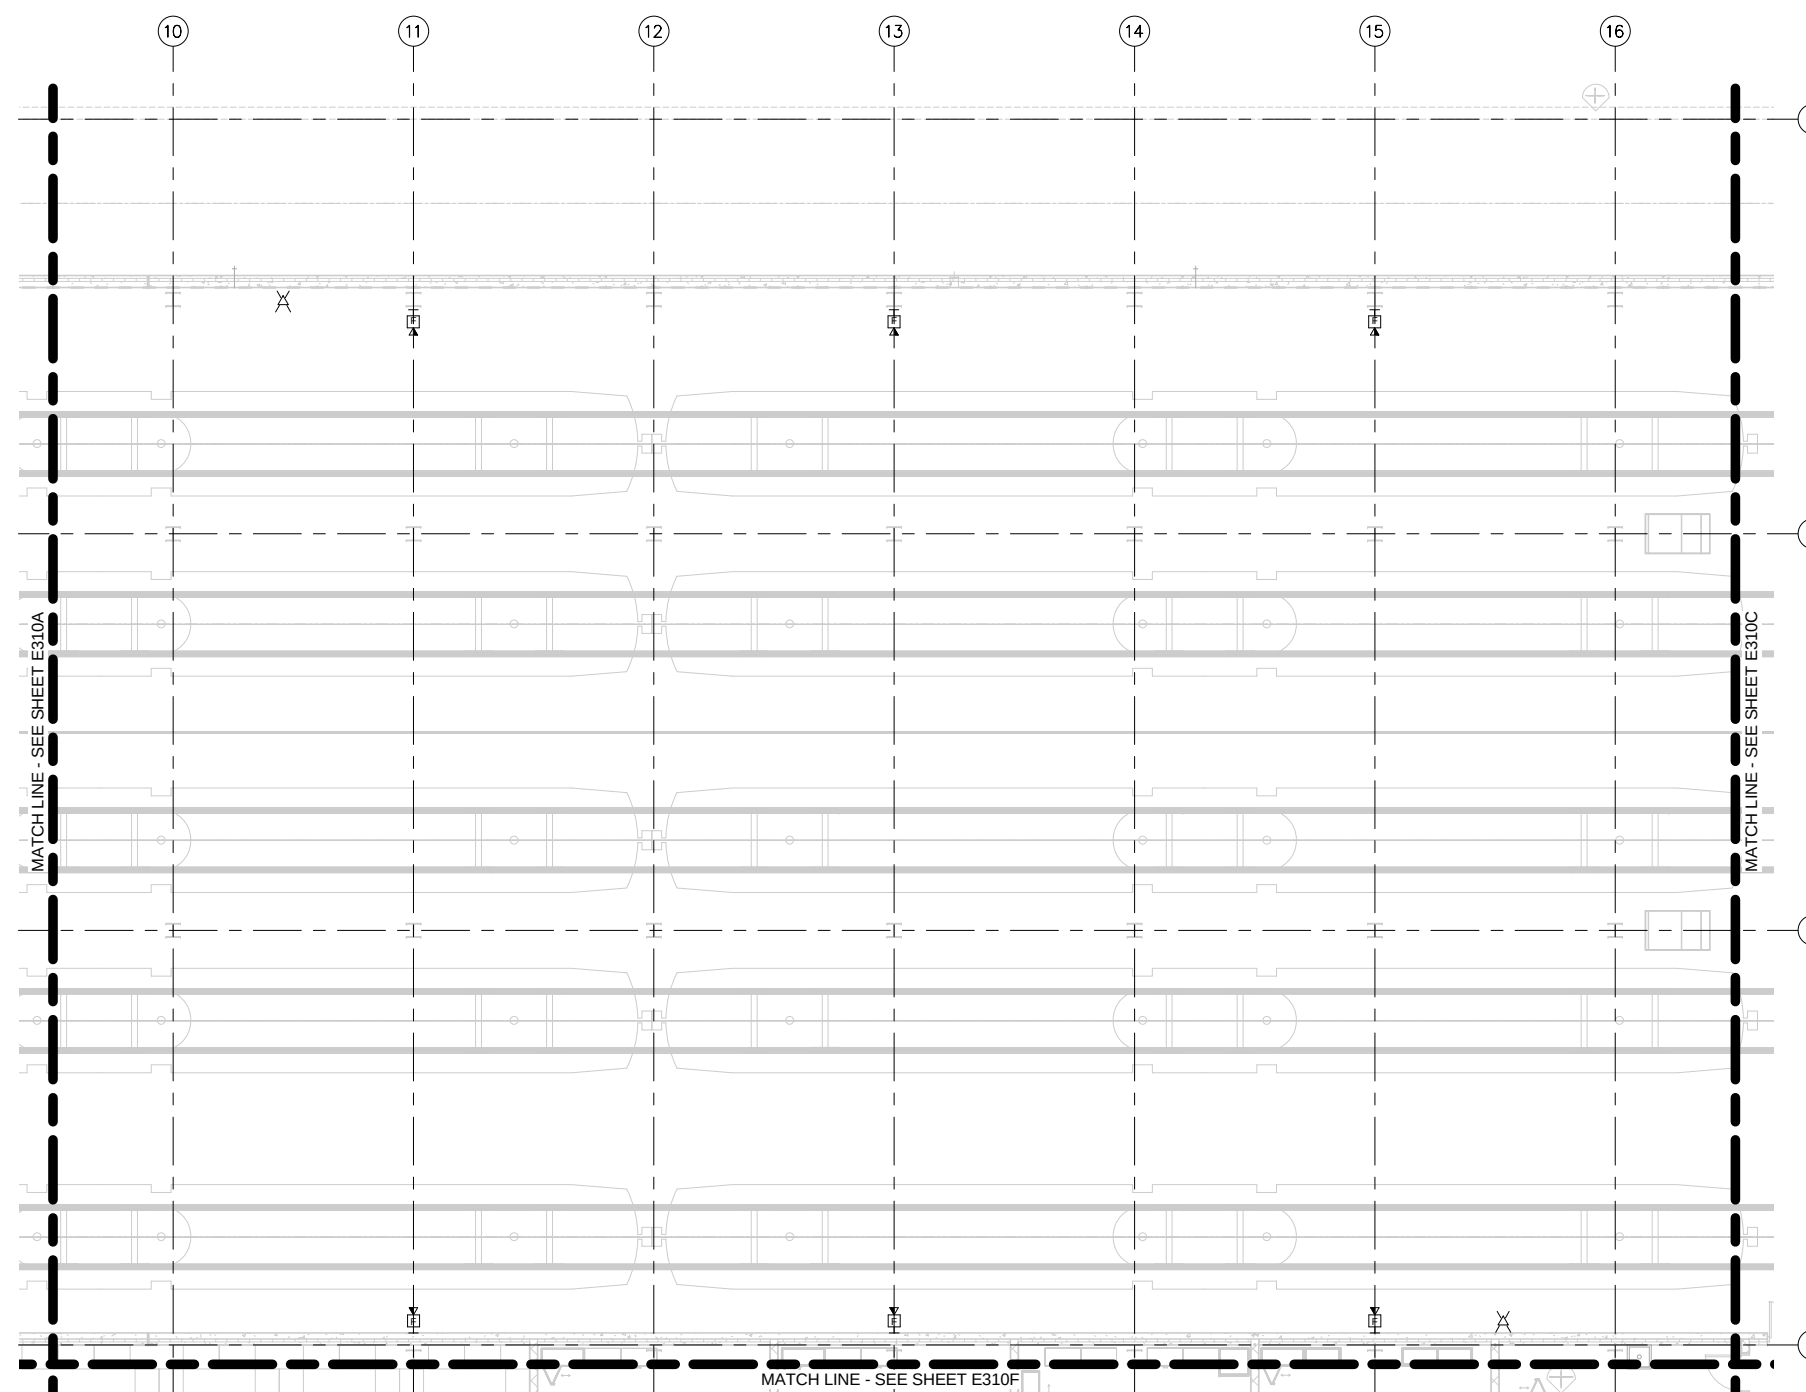

1 SYSTEMS PLAN - AREA B
E310B SCALE: 1/8" = 1'-0"

[illegible]

60% SUBMISSION - 9/28/15



**OPERATIONS & MAINTENANCE FACILITY - V2B
ELECTRICAL
SYSTEMS - LEVEL ONE - AREA B**

DISCIPLINE:

ELECTRICAL

	SHEET NAME:
--	--------------------


OMF-ELE-PLN

E310B


IN	FEET
B	SHEET
	201
	OF
	263

9/22/2015 10:10:49 AM C:\Users\IV-Begaj\Documents\OMF_ELEC_V-BegajB.rvt

- GENERAL NOTES:
1. CONDUITS NOT SHOWN ON THIS SHEET.
 2. RUN AND TERMINATE TWO CAT-6 CABLES TO ALL NETWORK OUTLETS EXCEPT WHERE OTHERWISE NOTED.

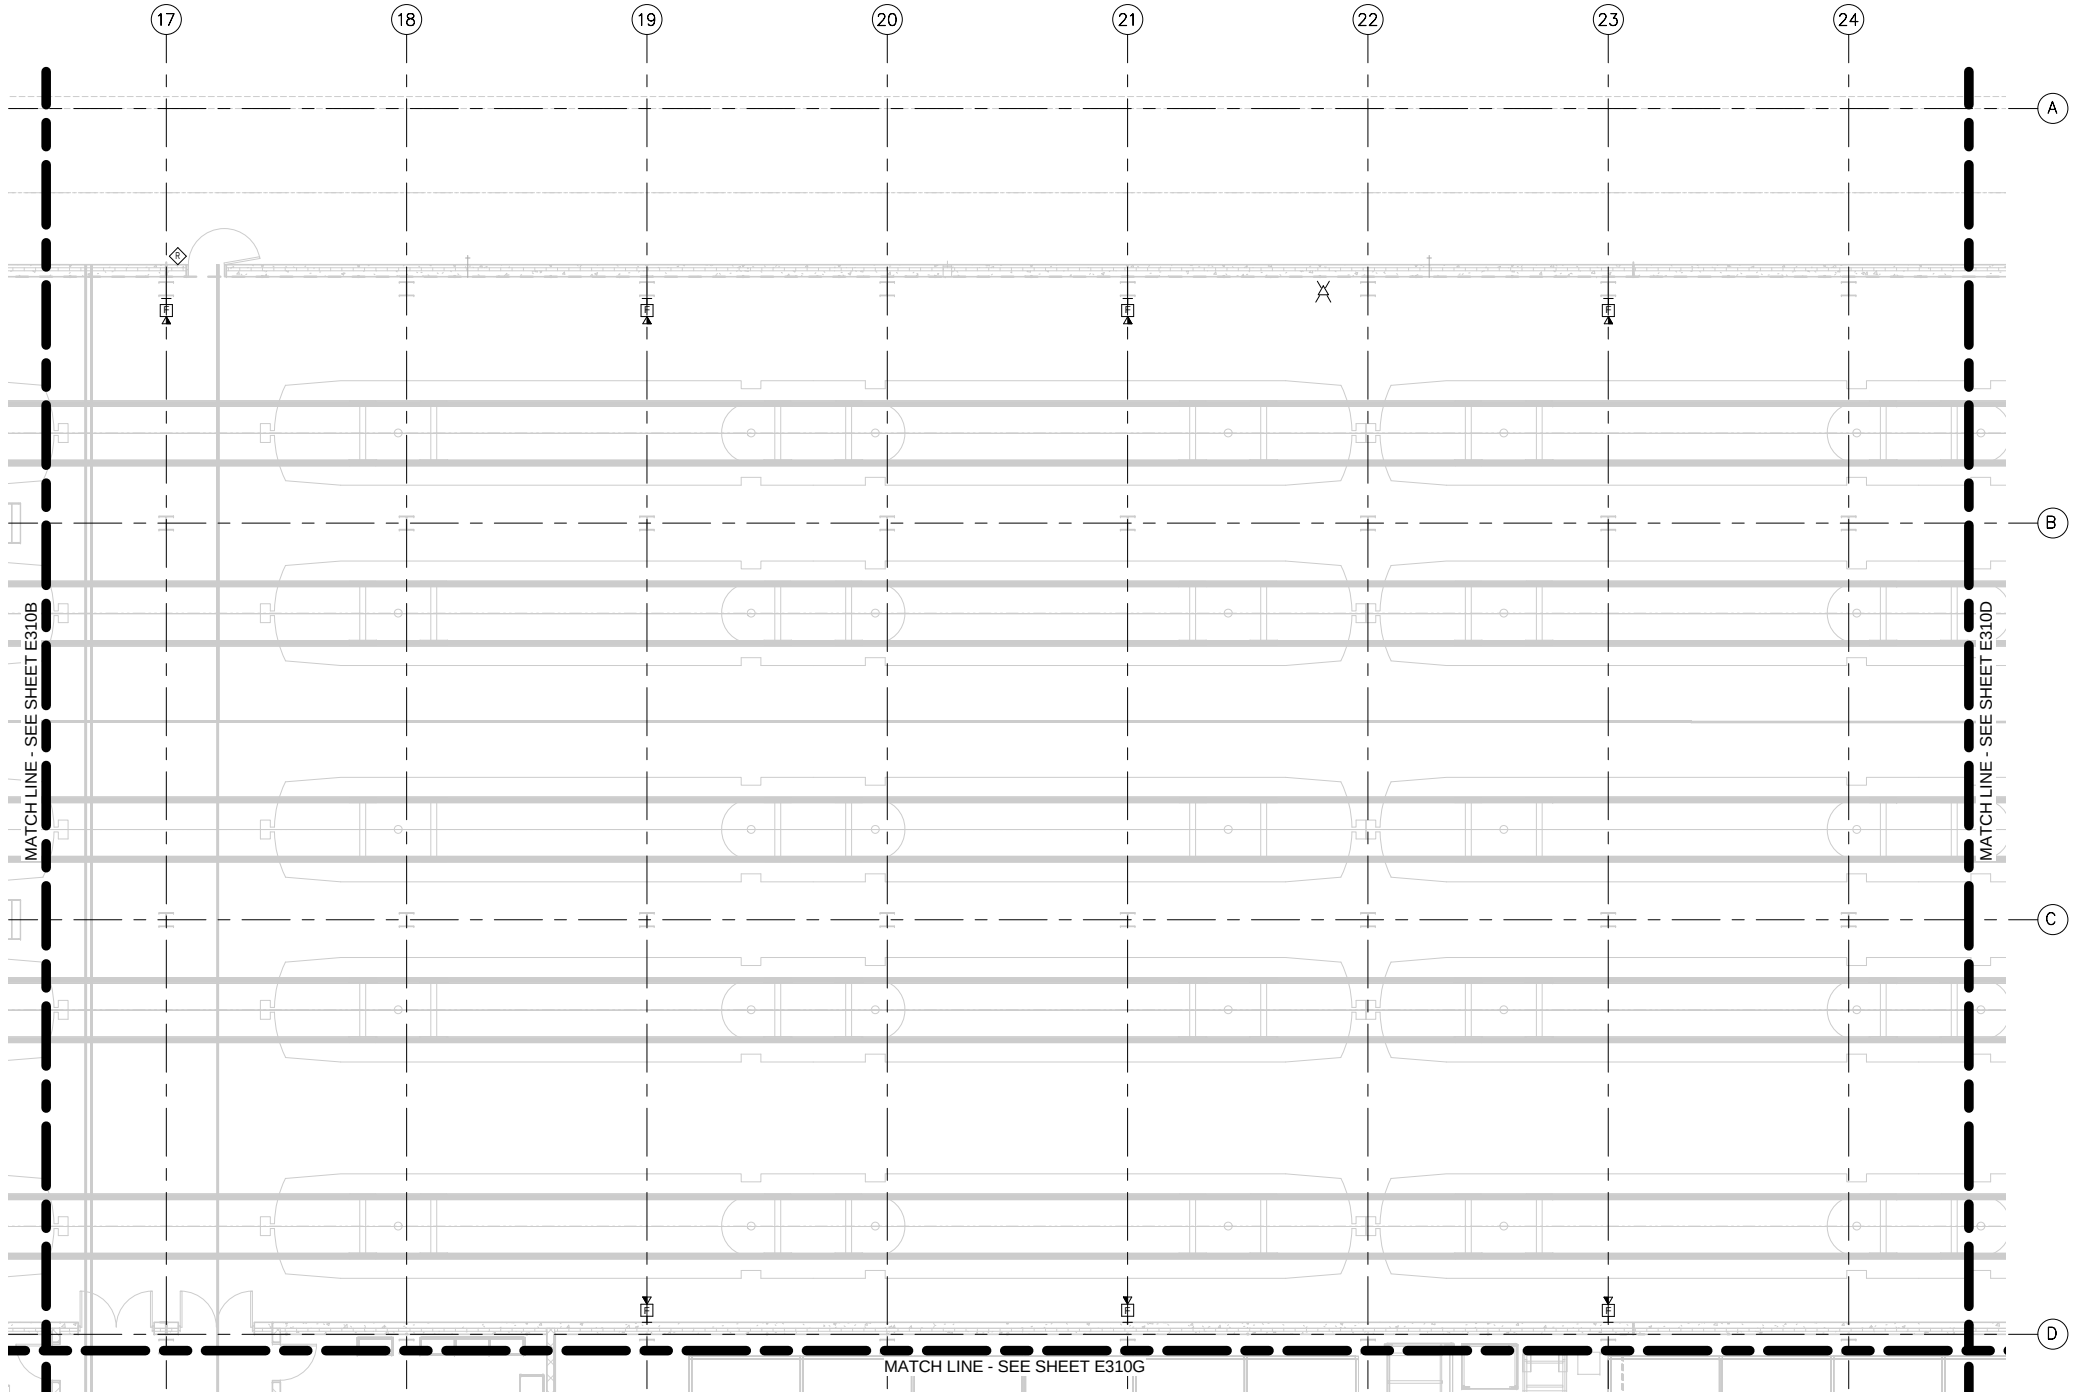

1 SYSTEMS PLAN - AREA C
E310C SCALE: 1/8" = 1'-0"

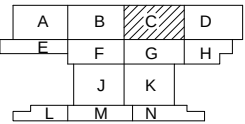

NO	DATE	BY	CHECK	DESIGN	REVISION / SUBMITTAL

 


MP Consultants
CONSULTING ENGINEERING
MINNEAPOLIS, MINNESOTA

60% SUBMISSION - 9/28/15



SOUTHWEST



OPERATIONS & MAINTENANCE FACILITY - V2B
ELECTRICAL
SYSTEMS - LEVEL ONE - AREA C

DISCIPLINE: ELECTRICAL

SHEET NAME: OMF-ELE-PLN

E310C

SHEET


202

OF

263

9/22/2015 10:10:51 AM C:\Users\jv-Begaj\Documents\OMF_ELEC_V-BegajB.rvt


- GENERAL NOTES:
1. CONDUITS NOT SHOWN ON THIS SHEET.
 2. RUN AND TERMINATE TWO CAT-6 CABLES TO ALL NETWORK OUTLETS EXCEPT WHERE OTHERWISE NOTED.

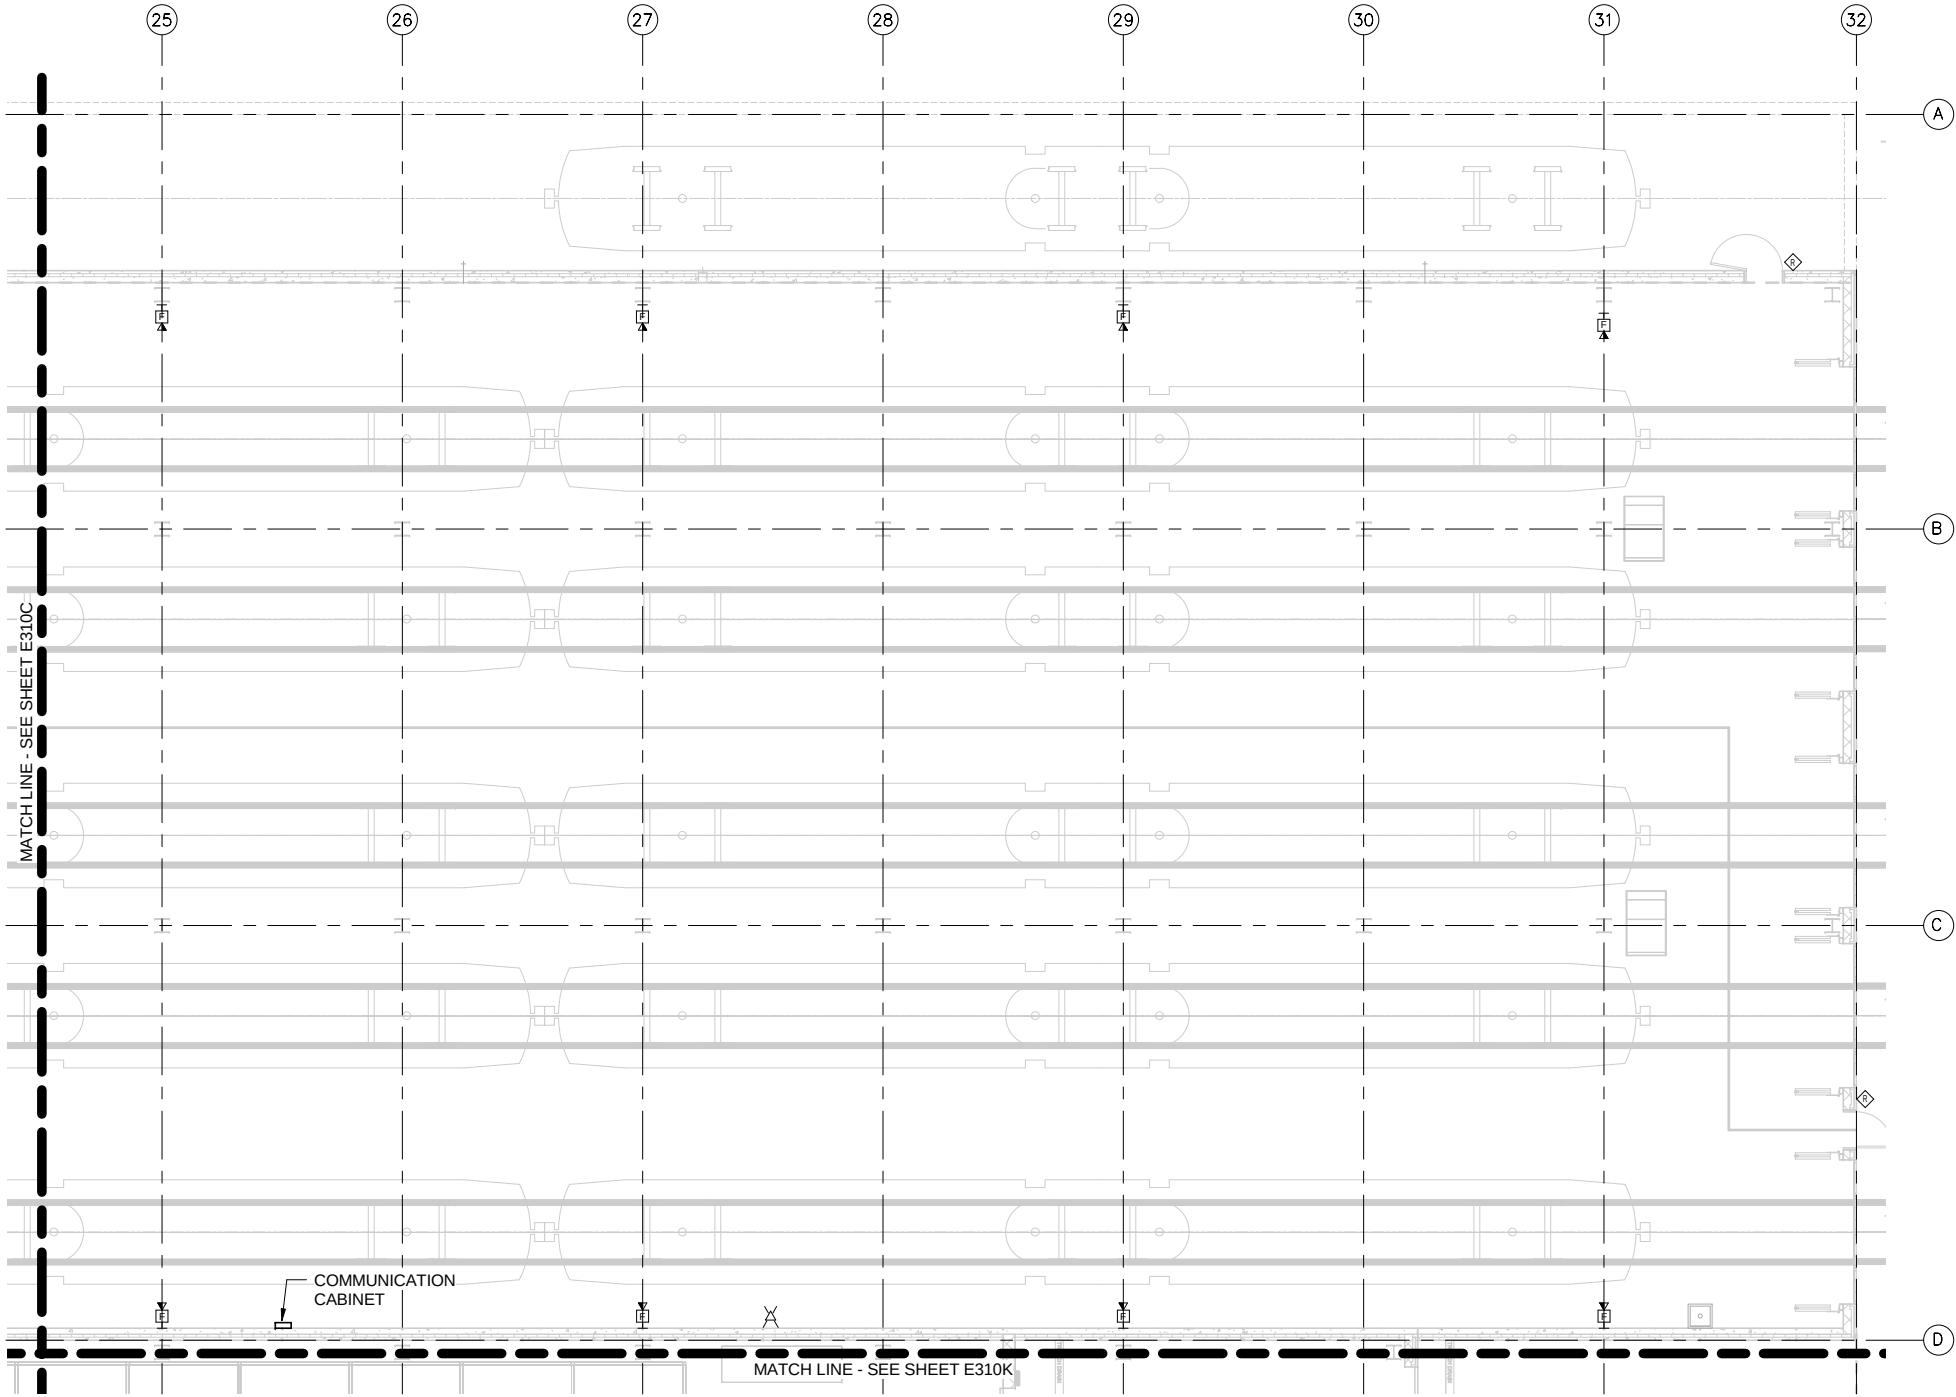

1
E310D

SYSTEMS PLAN - AREA D

SCALE: 1/8" = 1'-0"

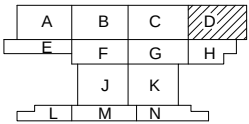

NO	DATE	BY	CHECK	DESIGN	REVISION / SUBMITTAL

AECOM

MP Consultants
CONSULTING ENGINEERING
MINNEAPOLIS • MINNESOTA

60% SUBMISSION - 9/28/15

**METROPOLITAN**
COUNCIL

**SOUTHWEST**

OPERATIONS & MAINTENANCE FACILITY - V2B
ELECTRICAL
SYSTEMS - LEVEL ONE - AREA D


DISCIPLINE: **ELECTRICAL**

SHEET NAME: **OMF-ELE-PLN**


E310D

SHEET
203
OF
263

1. CONDUITS NOT SHOWN ON THIS SHEET.
2. RUN AND TERMINATE TWO CAT-6 CABLES TO ALL NETWORK OUTLETS EXCEPT WHERE OTHERWISE NOTED.

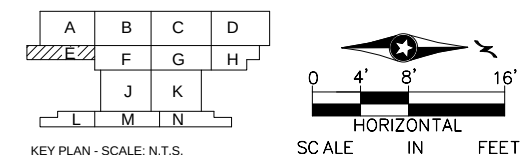
[illegible]

60% SUBMISSION - 9/28/15

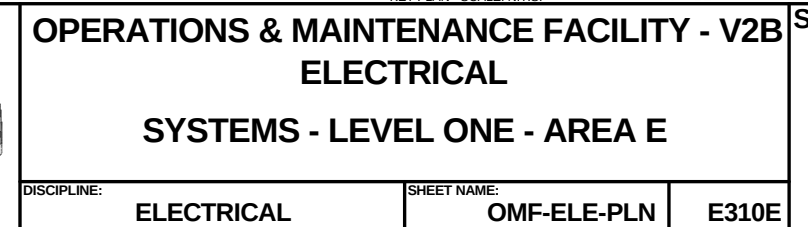

204
OF
263

1. CONDUITS NOT SHOWN ON THIS SHEET.
2. RUN AND TERMINATE TWO CAT-6 CABLES TO ALL NETWORK OUTLETS EXCEPT WHERE OTHERWISE NOTED.

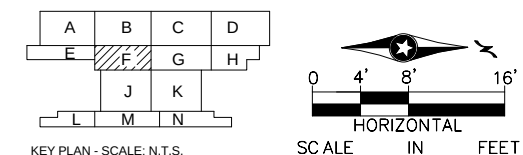[illegible]


METROPOLITAN COUNCIL

SOUTHWEST


OPERATIONS & MAINTENANCE FACILITY - V2B ELECTRICAL SYSTEMS - LEVEL ONE - AREA F		
DISCIPLINE: ELECTRICAL	SHEET NAME: OMF-ELE-PLN	E310F

205
OF
263

- GENERAL NOTES:
1. CONDUITS NOT SHOWN ON THIS SHEET.
 2. RUN AND TERMINATE TWO CAT-6 CABLES TO ALL NETWORK OUTLETS EXCEPT WHERE OTHERWISE NOTED.

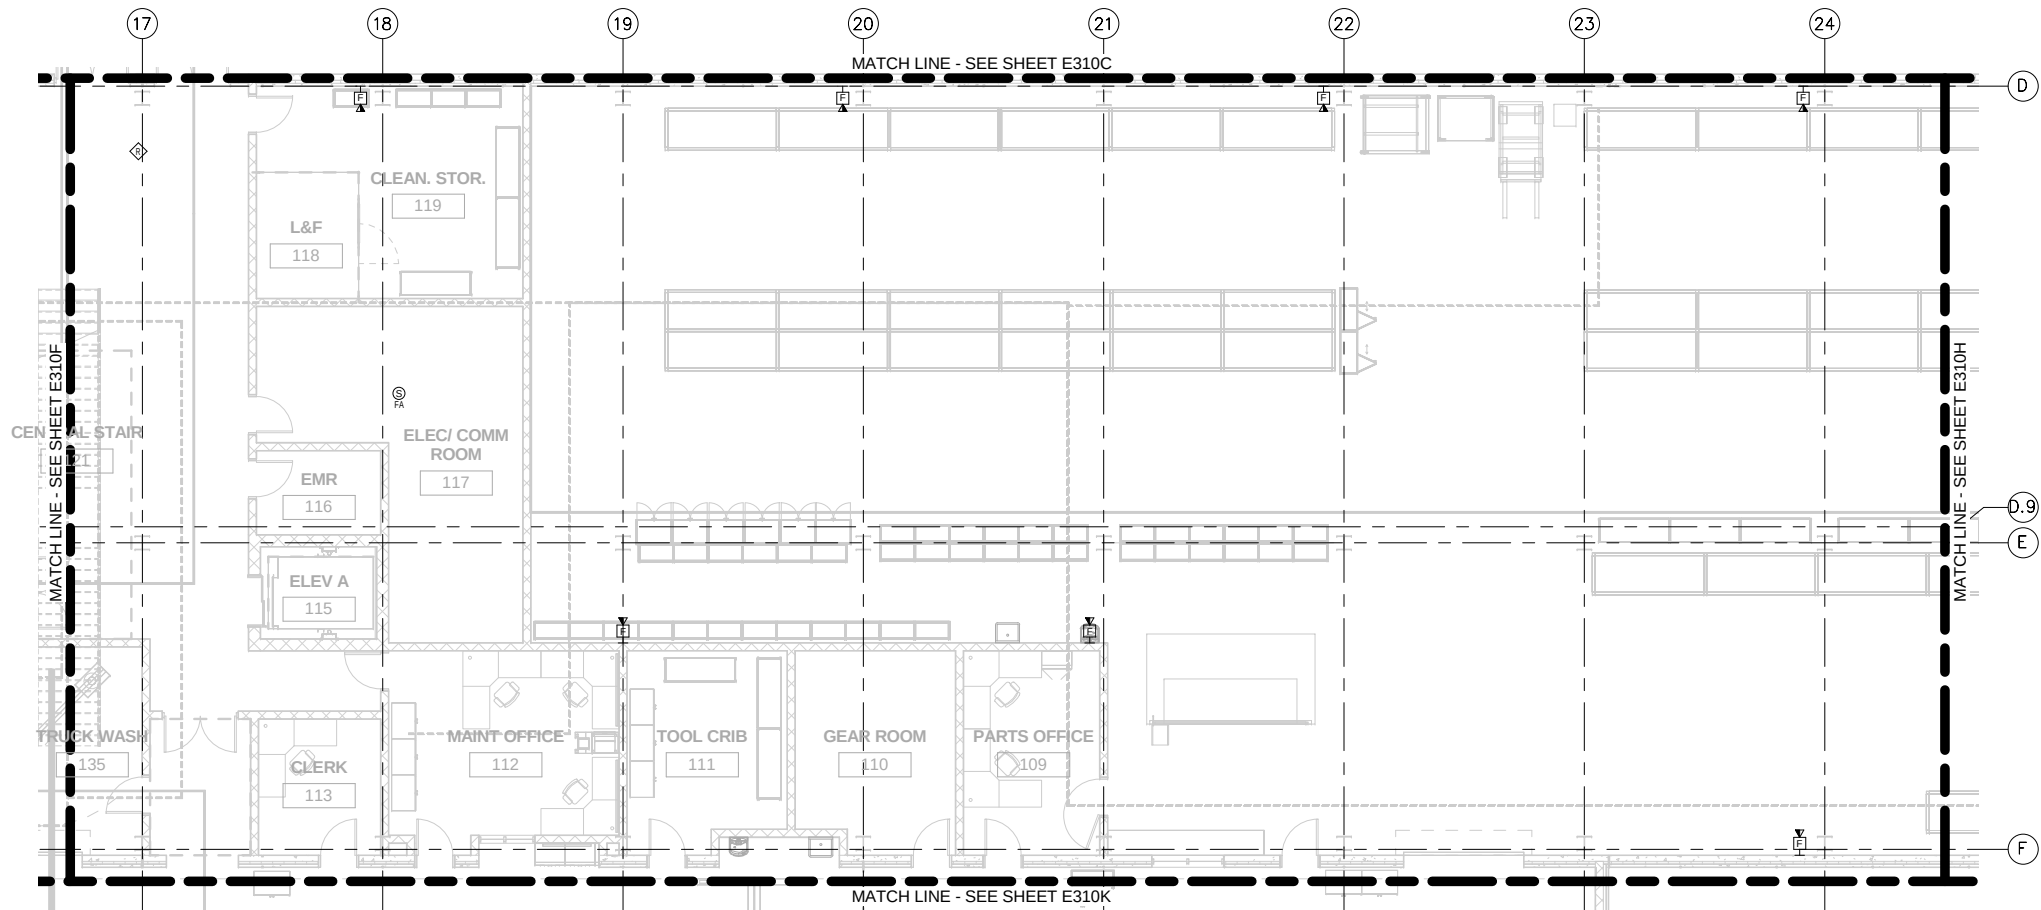

1 SYSTEMS PLAN - AREA G
E310G SCALE: 1/8" = 1'-0"

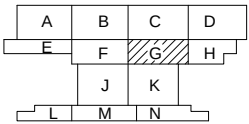

KEY PLAN - SCALE: N.T.S.

SCALE IN FEET

NO	DATE	BY	CHECK	DESIGN	REVISION / SUBMITTAL




60% SUBMISSION - 9/28/15

OPERATIONS & MAINTENANCE FACILITY - V2B
ELECTRICAL
SYSTEMS - LEVEL ONE - AREA G


DISCIPLINE:	SHEET NAME:	
ELECTRICAL	OMF-ELE-PLN	E310G

SHEET
206
OF
263

- GENERAL NOTES:
1. CONDUITS NOT SHOWN ON THIS SHEET.
 2. RUN AND TERMINATE TWO CAT-6 CABLES TO ALL NETWORK OUTLETS EXCEPT WHERE OTHERWISE NOTED.

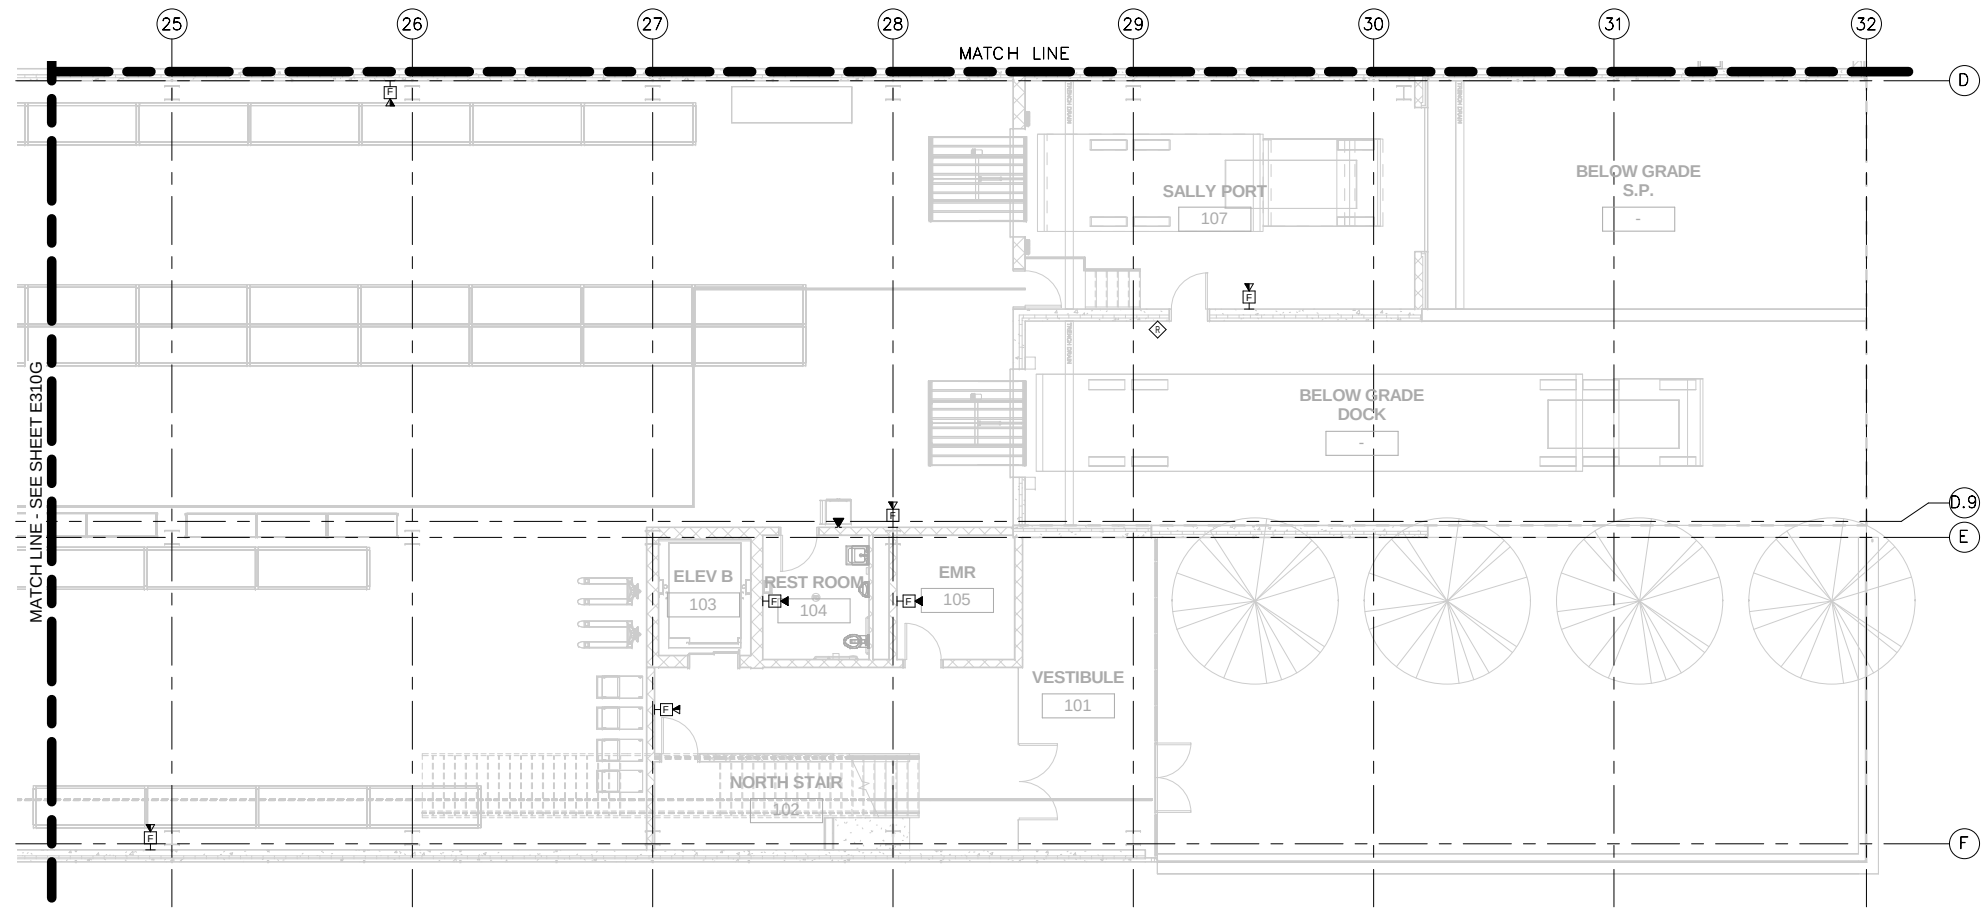

1 SYSTEMS PLAN - AREA H
E310H SCALE: 1/8" = 1'-0"

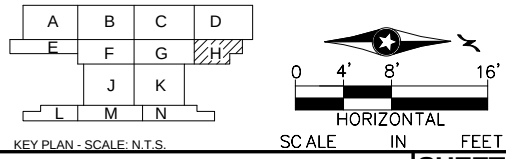

NO	DATE	BY	CHECK	DESIGN	REVISION / SUBMITTAL

 


MP Consultants
CONSULTING ENGINEERING
MINNEAPOLIS, MINNESOTA

60% SUBMISSION - 9/28/15



SOUTHWEST



OPERATIONS & MAINTENANCE FACILITY - V2B
ELECTRICAL

SYSTEMS - LEVEL ONE - AREA H

DISCIPLINE: ELECTRICAL

SHEET NAME: OMF-ELE-PLN

E310H

SHEET

207


OF

263


9/22/2015 10:11:07 AM C:\Users\jv-Begaj\Documents\OMF_ELEC_V-BegajB.rvt

9/22/2015 10:11:10 AM C:\Users\jv-Beggs\Documents\OMF_ELEC_V-Beggs\B.rvt

- GENERAL NOTES:
1. CONDUITS NOT SHOWN ON THIS SHEET.
 2. RUN AND TERMINATE TWO CAT-6 CABLES TO ALL NETWORK OUTLETS EXCEPT WHERE OTHERWISE NOTED.

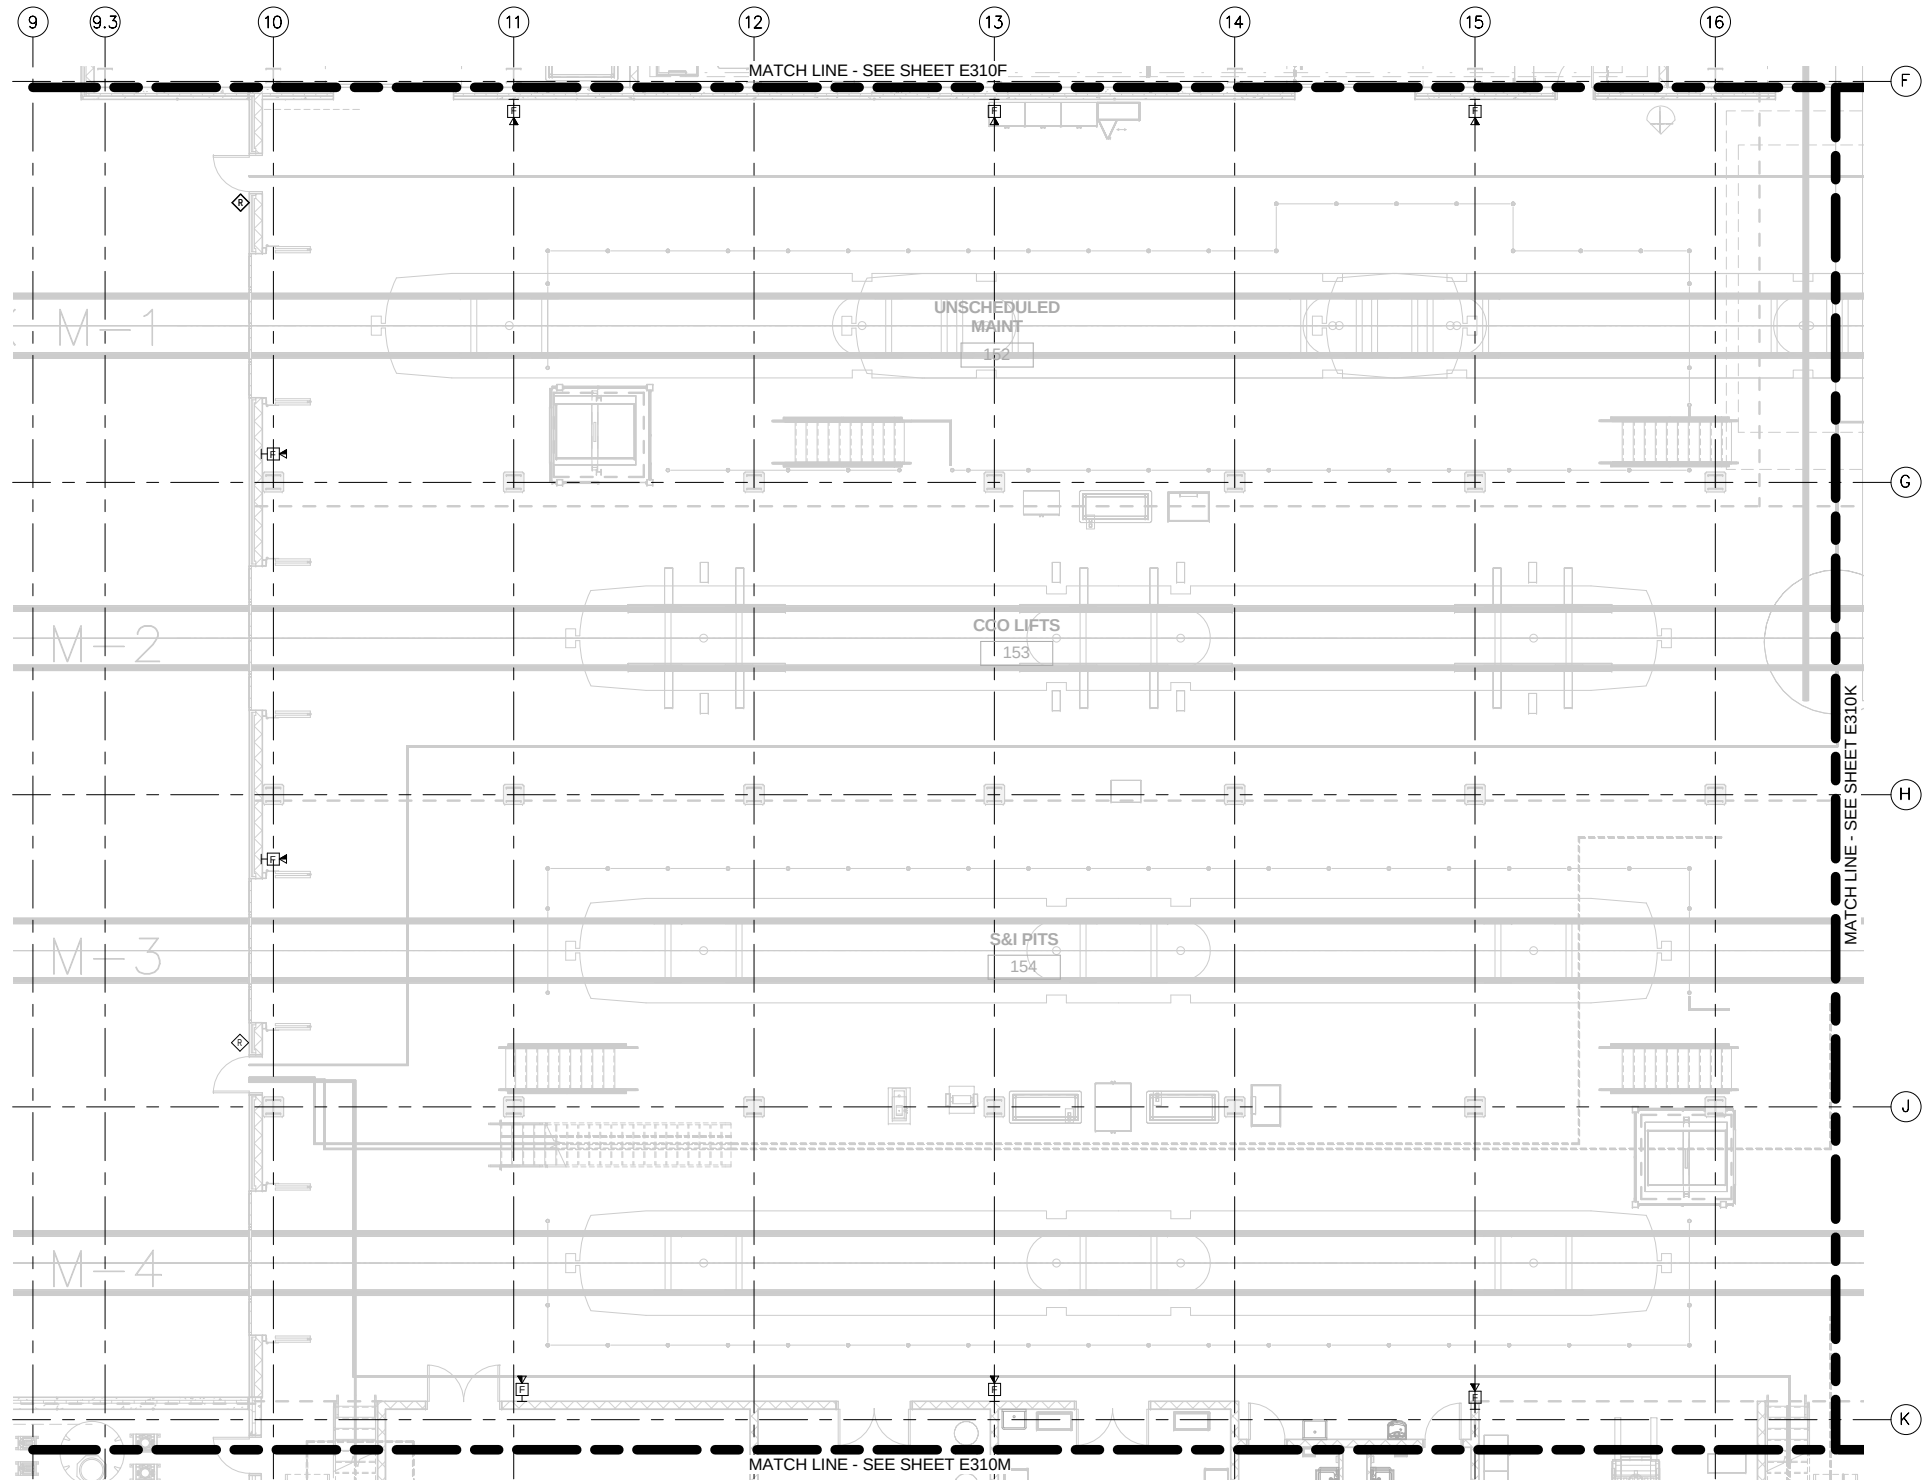

1 SYSTEMS PLAN - AREA J
E310J SCALE: 1/8" = 1'-0"

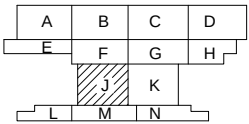

NO	DATE	BY	CHECK	DESIGN	REVISION / SUBMITTAL

AECOM

MP Consultants
CONSULTING ENGINEERING
MINNEAPOLIS, MINNESOTA

60% SUBMISSION - 9/28/15

**METROPOLITAN**
COUNCIL

**SOUTHWEST**

OPERATIONS & MAINTENANCE FACILITY - V2B
ELECTRICAL
SYSTEMS - LEVEL ONE - AREA J

DISCIPLINE: ELECTRICAL


SHEET NAME: OMF-ELE-PLN

E310J


SHEET
208
OF
263

9/22/2015 10:11:13 AM C:\Users\jv-Beggs\Documents\OMF_ELEC_V-Beggs\B.rvt

- GENERAL NOTES:
1. CONDUITS NOT SHOWN ON THIS SHEET.
 2. RUN AND TERMINATE TWO CAT-6 CABLES TO ALL NETWORK OUTLETS EXCEPT WHERE OTHERWISE NOTED.

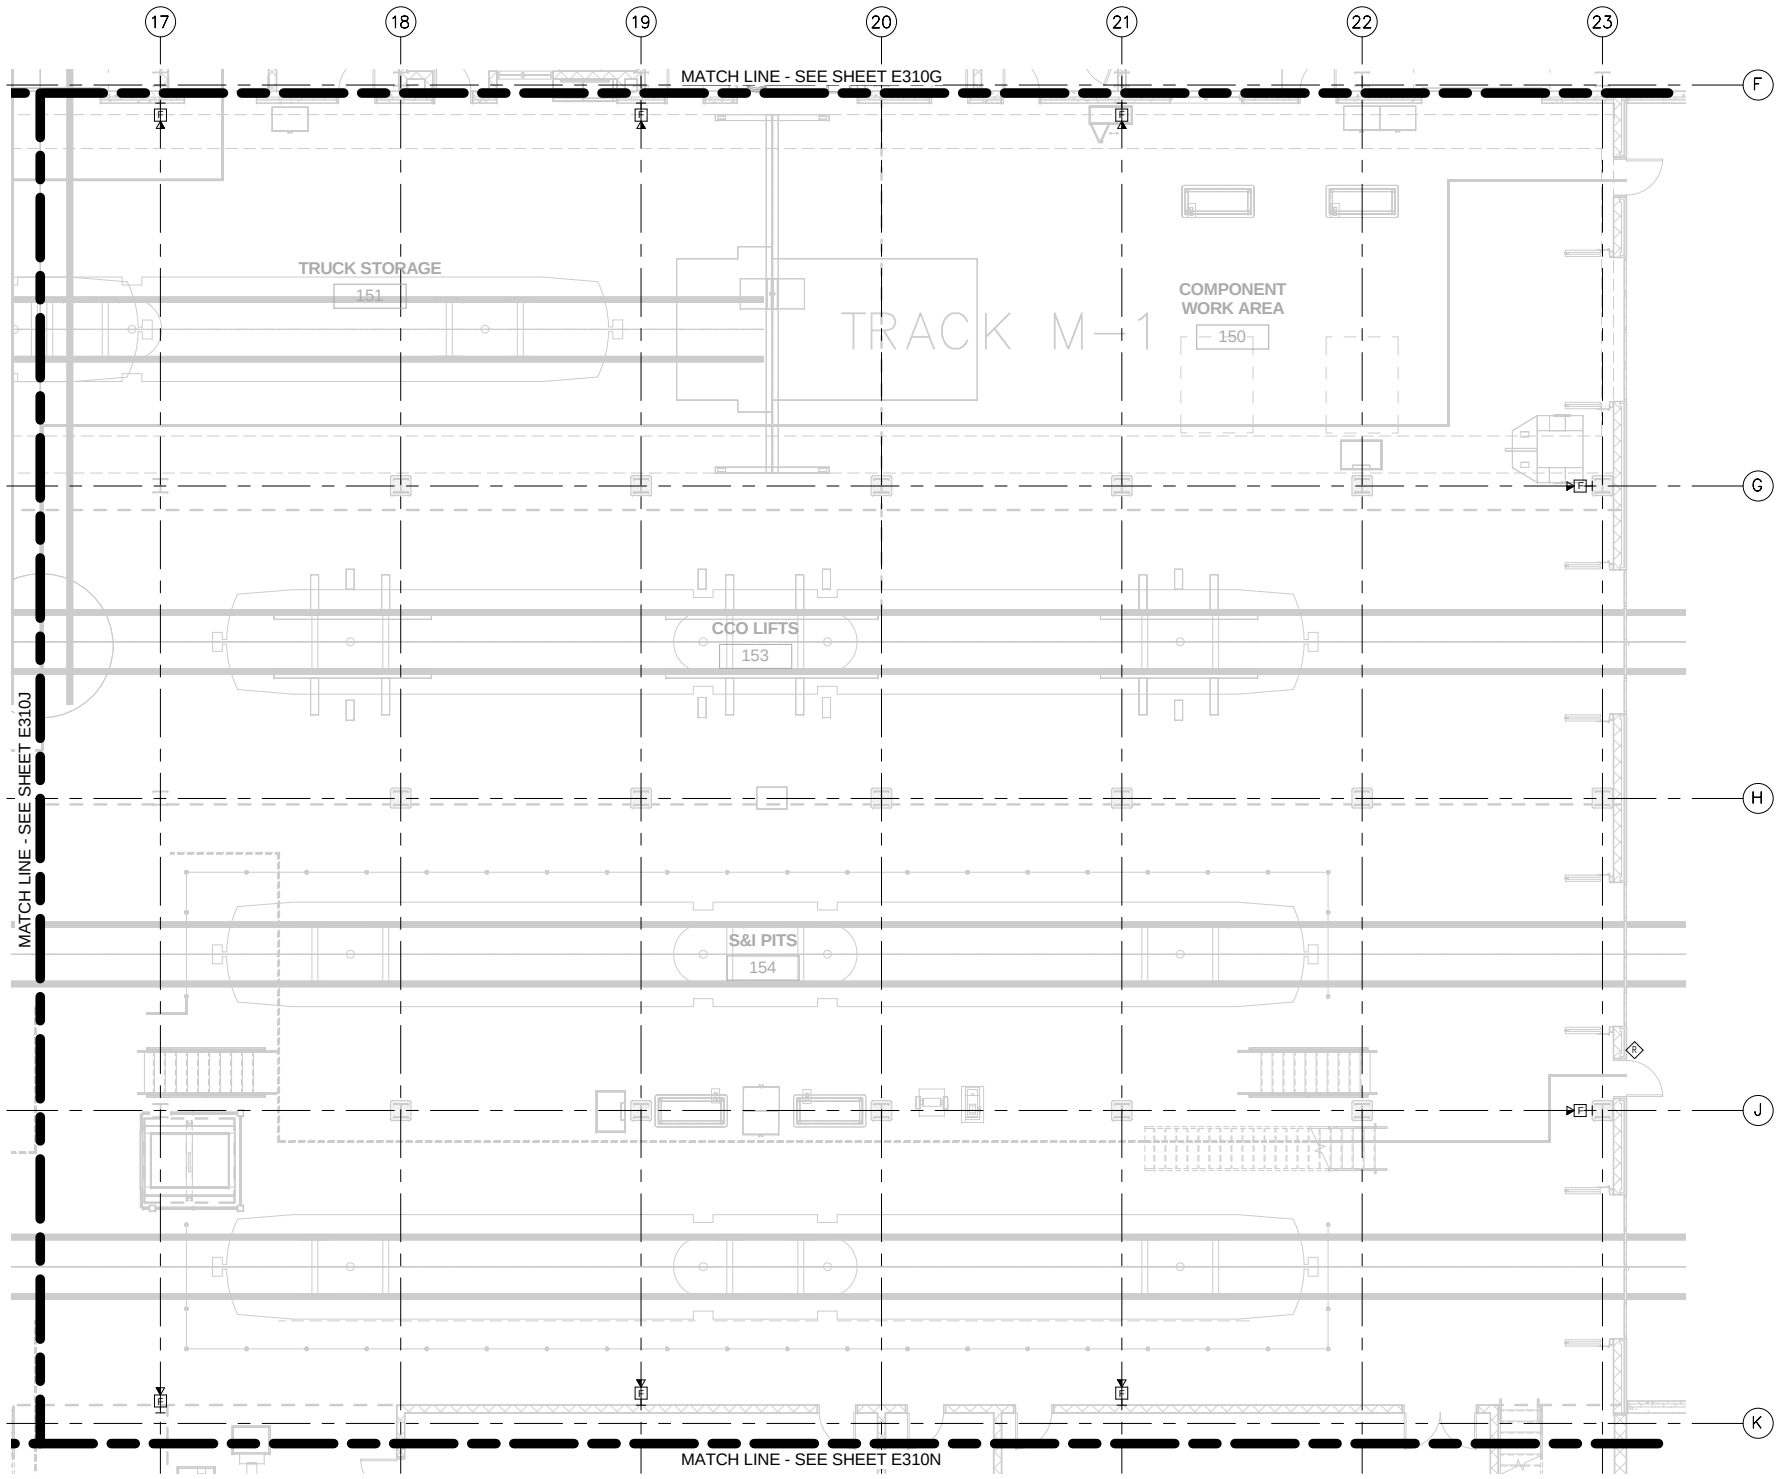


1 SYSTEMS PLAN - AREA K
E310K SCALE: 1/8" = 1'-0"

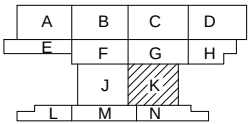

NO	DATE	BY	CHECK	DESIGN	REVISION / SUBMITTAL

 AECOM MP Consultants CONSULTING ENGINEERING MINNEAPOLIS, MINNESOTA	 METROPOLITAN COUNCIL	 SOUTHWEST	OPERATIONS & MAINTENANCE FACILITY - V2B			SHEET 209 OF 263
			ELECTRICAL			
SYSTEMS - LEVEL ONE - AREA K			DISCIPLINE: ELECTRICAL	SHEET NAME: OMF-ELE-PLN	E310K	
60% SUBMISSION - 9/28/15						

- GENERAL NOTES:
1. CONDUITS NOT SHOWN ON THIS SHEET.
 2. RUN AND TERMINATE TWO CAT-6 CABLES TO ALL NETWORK OUTLETS EXCEPT WHERE OTHERWISE NOTED.

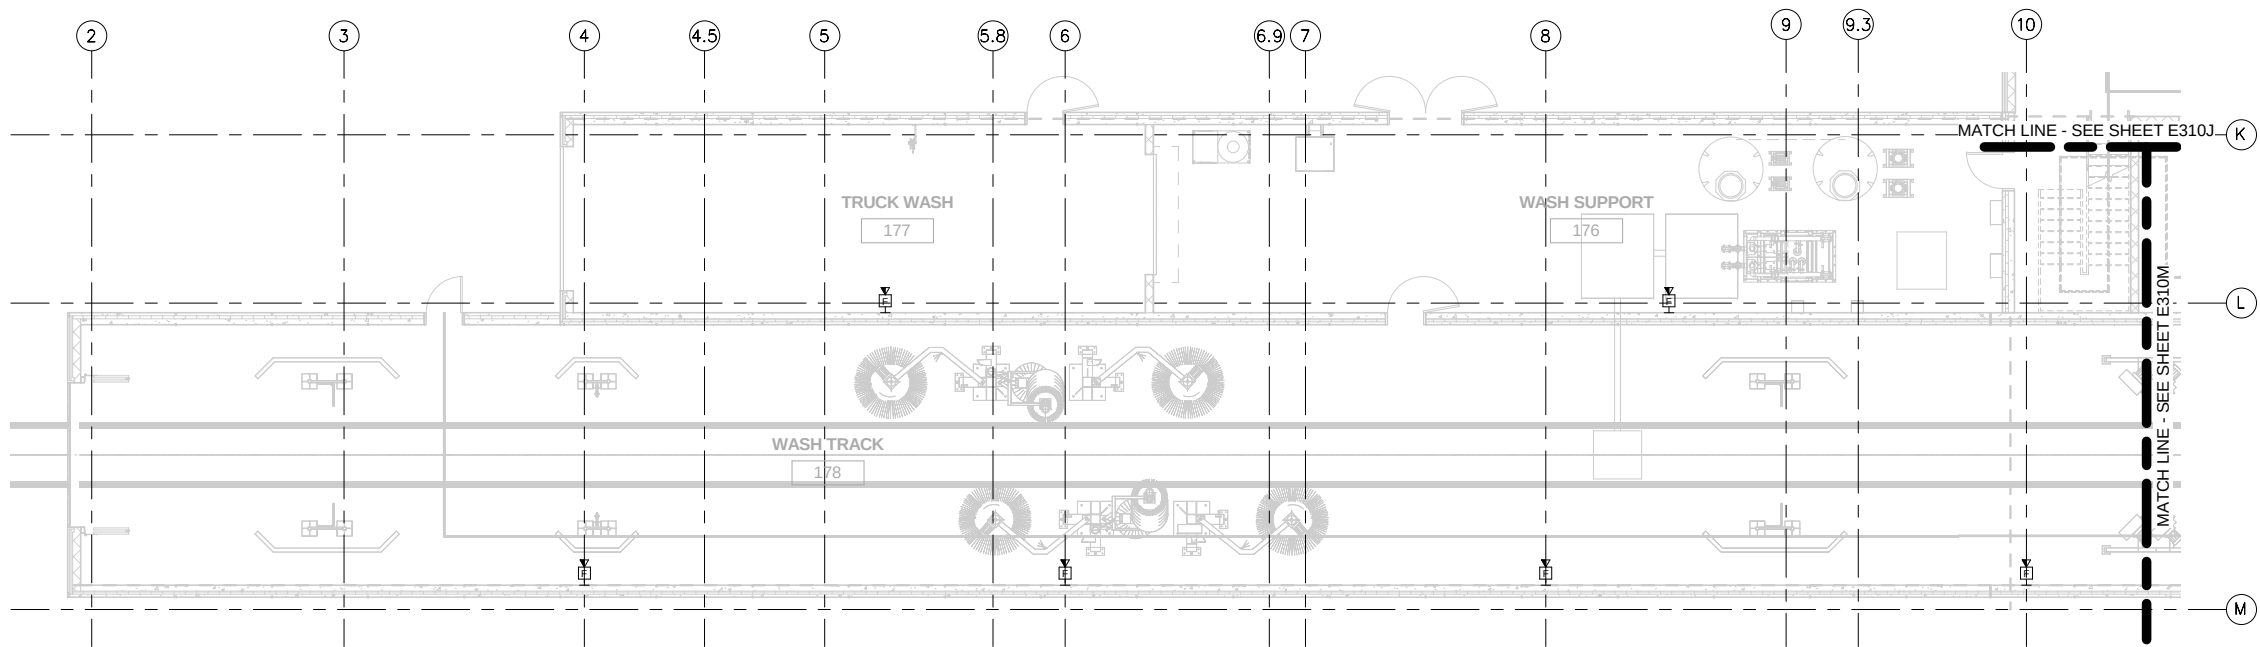

1 SYSTEMS PLAN - AREA L
E310L SCALE: 1/8" = 1'-0"

NO	DATE	BY	CHECK	DESIGN	REVISION / SUBMITTAL

AECOM

MP Consultants
CONSULTING ENGINEERING
MINNEAPOLIS • MINNESOTA

60% SUBMISSION - 9/28/15

**METROPOLITAN COUNCIL**

**SOUTHWEST**


OPERATIONS & MAINTENANCE FACILITY - V2B
ELECTRICAL
SYSTEMS - LEVEL ONE - AREA L

DISCIPLINE: ELECTRICAL


SHEET NAME: OMF-ELE-PLN

E310L


SHEET
210
OF
263

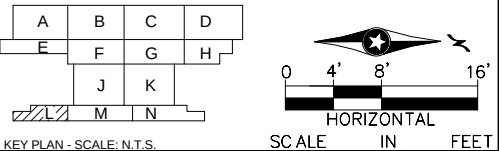

- GENERAL NOTES:
1. CONDUITS NOT SHOWN ON THIS SHEET.
 2. RUN AND TERMINATE TWO CAT-6 CABLES TO ALL NETWORK OUTLETS EXCEPT WHERE OTHERWISE NOTED.

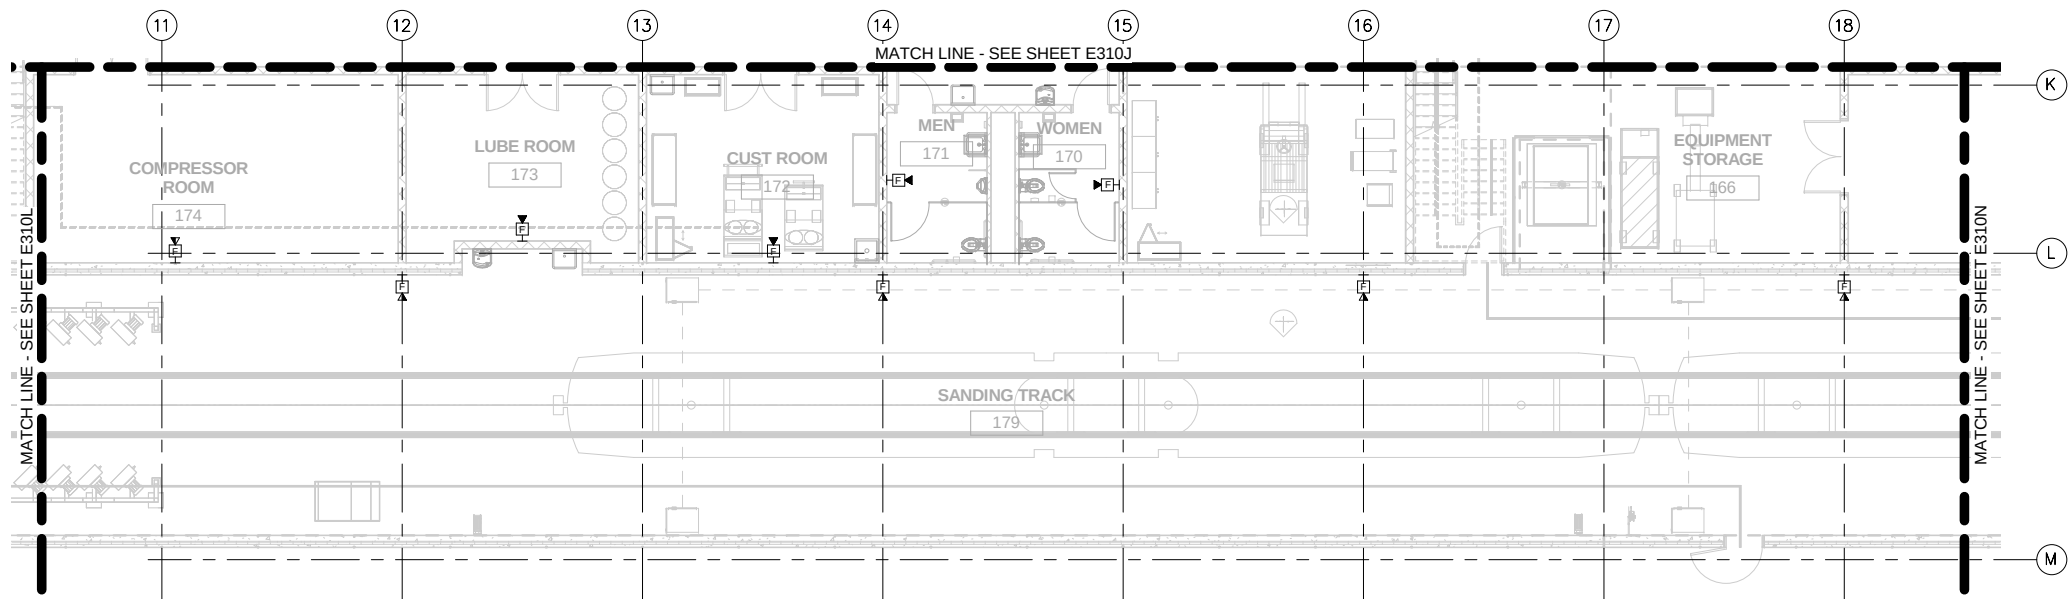

1 SYSTEMS PLAN - AREA M
E310M SCALE: 1/8" = 1'-0"

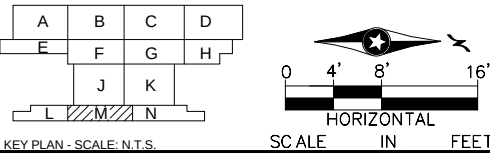


NO	DATE	BY	CHECK	DESIGN	REVISION / SUBMITTAL


		OPERATIONS & MAINTENANCE FACILITY - V2B			SHEET
		ELECTRICAL			
SYSTEMS - LEVEL ONE - AREA M					OF
DISCIPLINE: ELECTRICAL					
SHEET NAME: OMF-ELE-PLN E310M					
60% SUBMISSION - 9/28/15					

9/22/2015 10:11:20 AM C:\Users\V-Bege\B\Documents\OMF_ELEC_V-Bege\B.rvt

- GENERAL NOTES:
1. CONDUITS NOT SHOWN ON THIS SHEET.
 2. RUN AND TERMINATE TWO CAT-6 CABLES TO ALL NETWORK OUTLETS EXCEPT WHERE OTHERWISE NOTED.

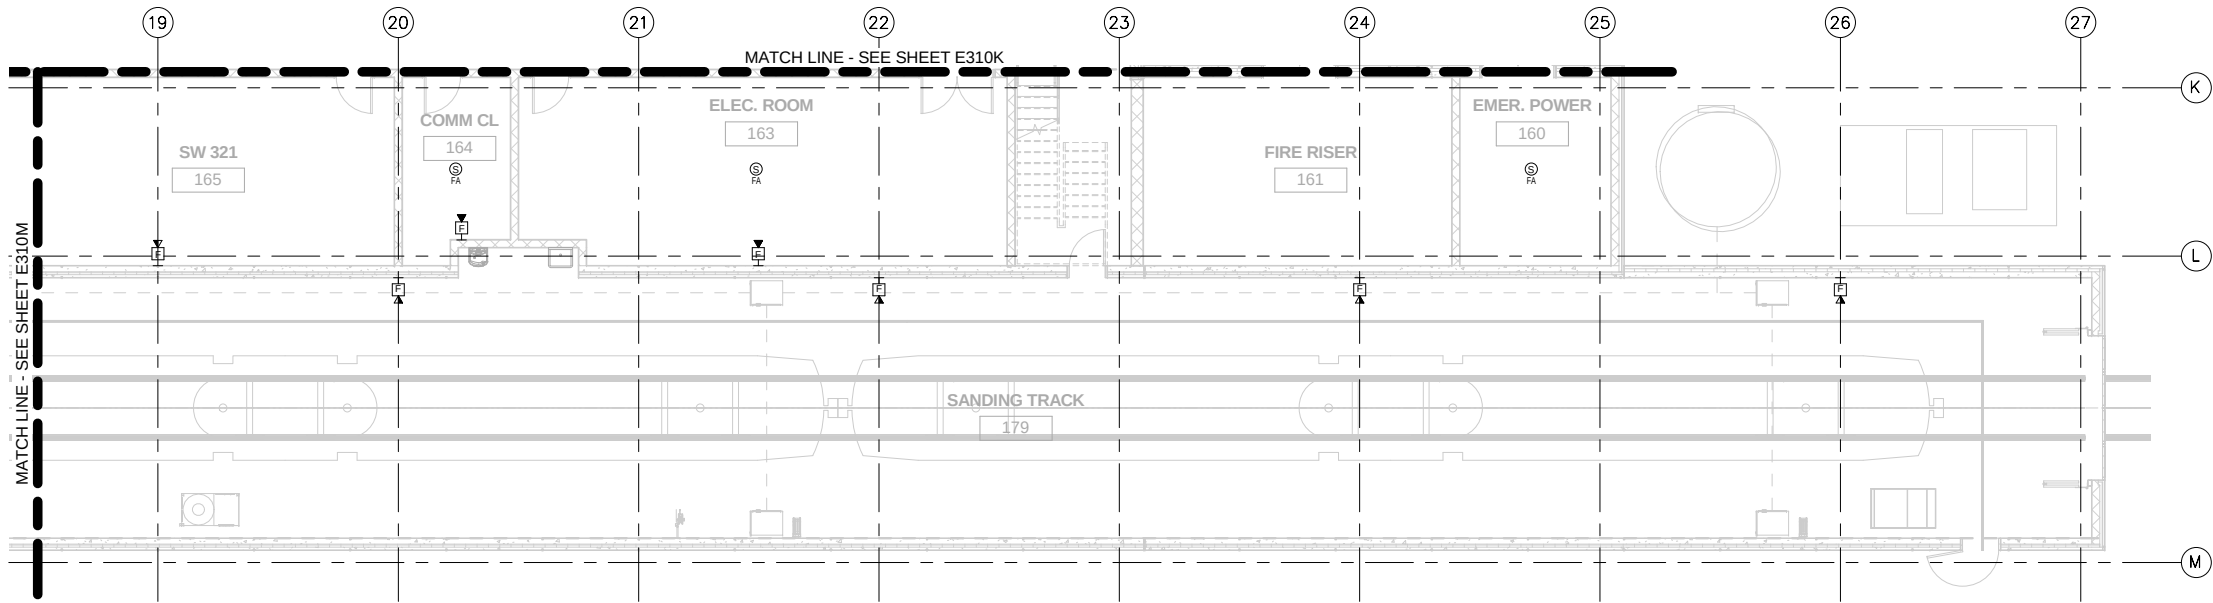

1 SYSTEMS PLAN - AREA N
E310N SCALE: 1/8" = 1'-0"

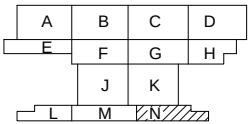

NO	DATE	BY	CHECK	DESIGN	REVISION / SUBMITTAL

AECOM

MP Consultants
CONSULTING ENGINEERING
MINNEAPOLIS • MINNESOTA

60% SUBMISSION - 9/28/15

**METROPOLITAN COUNCIL**

**SOUTHWEST**

OPERATIONS & MAINTENANCE FACILITY - V2B
ELECTRICAL
SYSTEMS - LEVEL ONE - AREA N


DISCIPLINE: ELECTRICAL

SHEET NAME: OMF-ELE-PLN

E310N

SHEET
212
OF
263

1. CONDUITS NOT SHOWN ON THIS SHEET.
2. RUN AND TERMINATE TWO CAT-6 CABLES TO ALL NETWORK OUTLETS EXCEPT WHERE OTHERWISE NOTED.

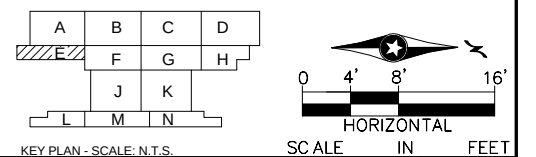
[illegible]

METROPOLITAN COUNCIL


SOUTHWEST

OPERATIONS & MAINTENANCE FACILITY - V2B ELECTRICAL SYSTEMS - LEVEL TWO - AREA E			SHEET 213 OF 263
DISCIPLINE: ELECTRICAL	SHEET NAME: OMF-ELE-PLN	E320E	

- GENERAL NOTES:
1. CONDUITS NOT SHOWN ON THIS SHEET.
 2. RUN AND TERMINATE TWO CAT-6 CABLES TO ALL NETWORK OUTLETS EXCEPT WHERE OTHERWISE NOTED.

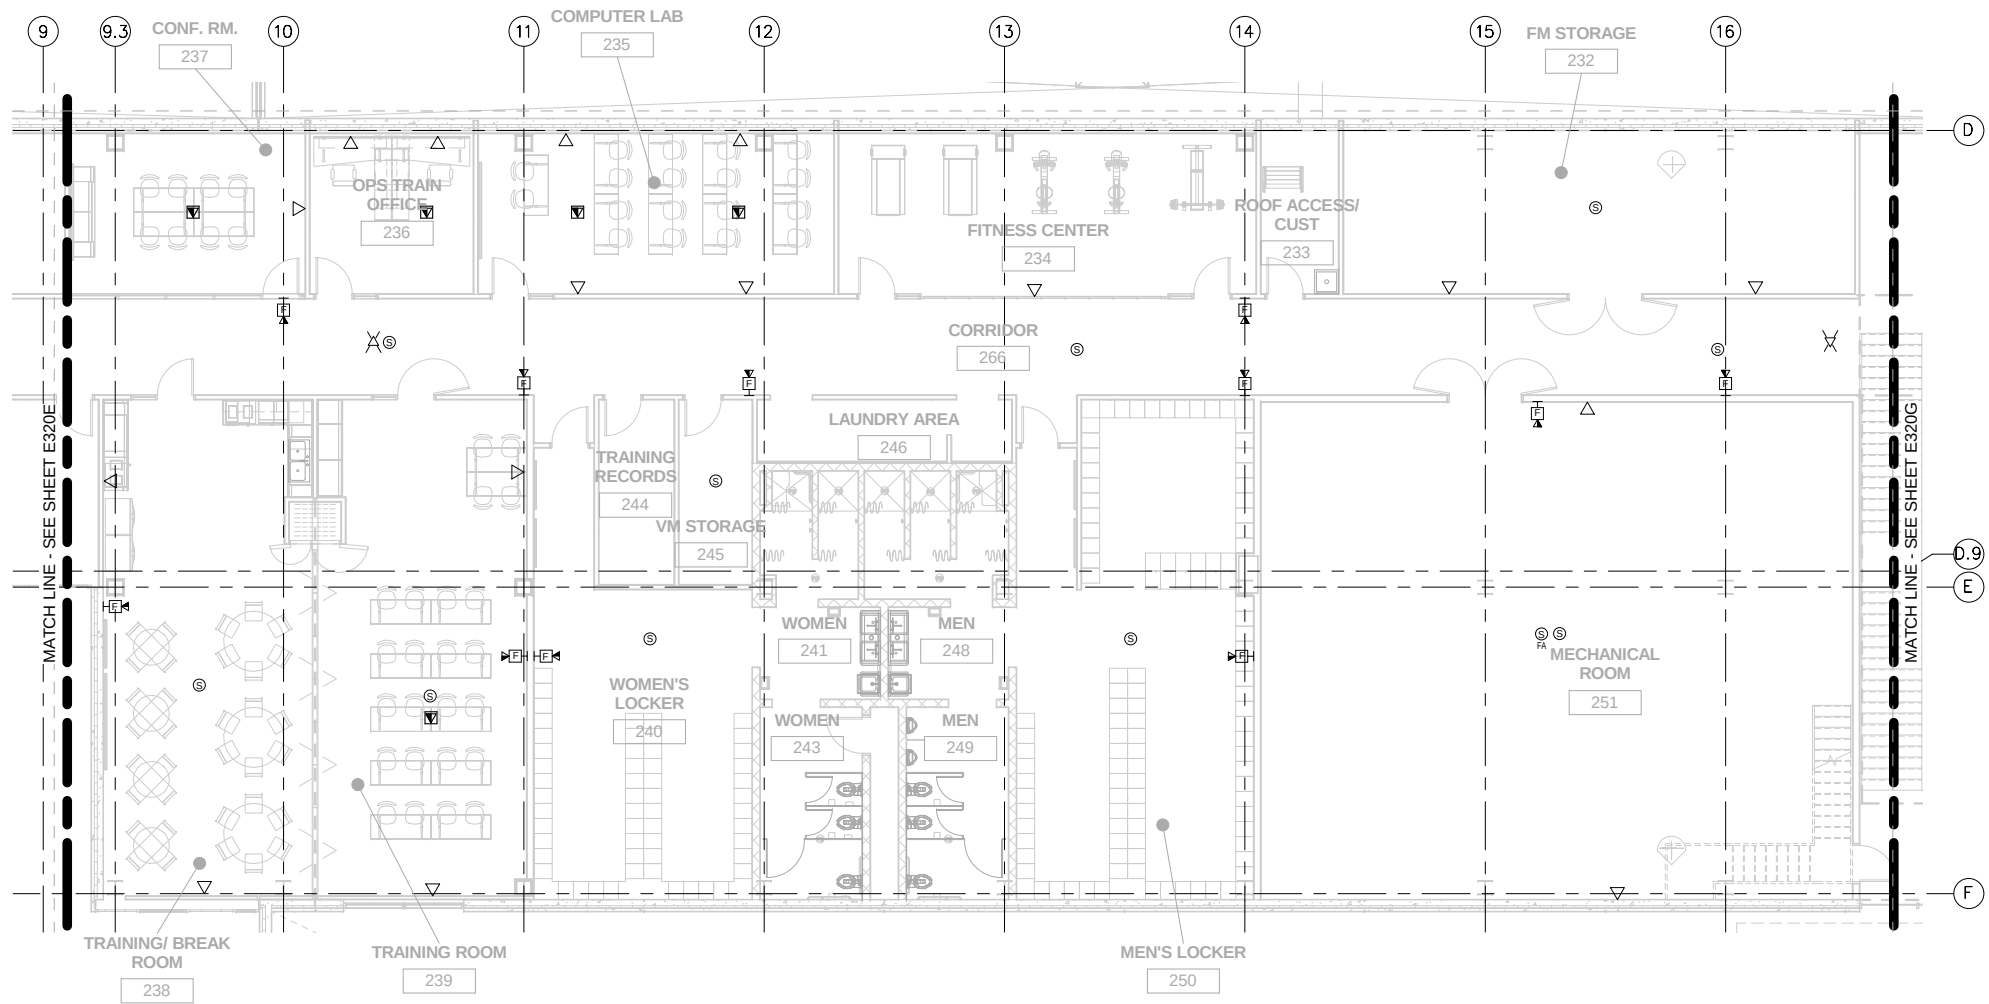

1 SYSTEMS PLAN - AREA F
E320F SCALE: 1/8" = 1'-0"

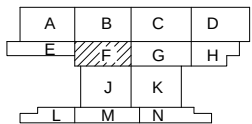

NO	DATE	BY	CHECK	DESIGN	REVISION / SUBMITTAL



60% SUBMISSION - 9/28/15




OPERATIONS & MAINTENANCE FACILITY - V2B
ELECTRICAL

SYSTEMS - LEVEL TWO - AREA F


DISCIPLINE: ELECTRICAL
SHEET NAME: OMF-ELE-PLN
E320F

SHEET
214
OF
263

- GENERAL NOTES:
1. CONDUITS NOT SHOWN ON THIS SHEET.
 2. RUN AND TERMINATE TWO CAT-6 CABLES TO ALL NETWORK OUTLETS EXCEPT WHERE OTHERWISE NOTED.

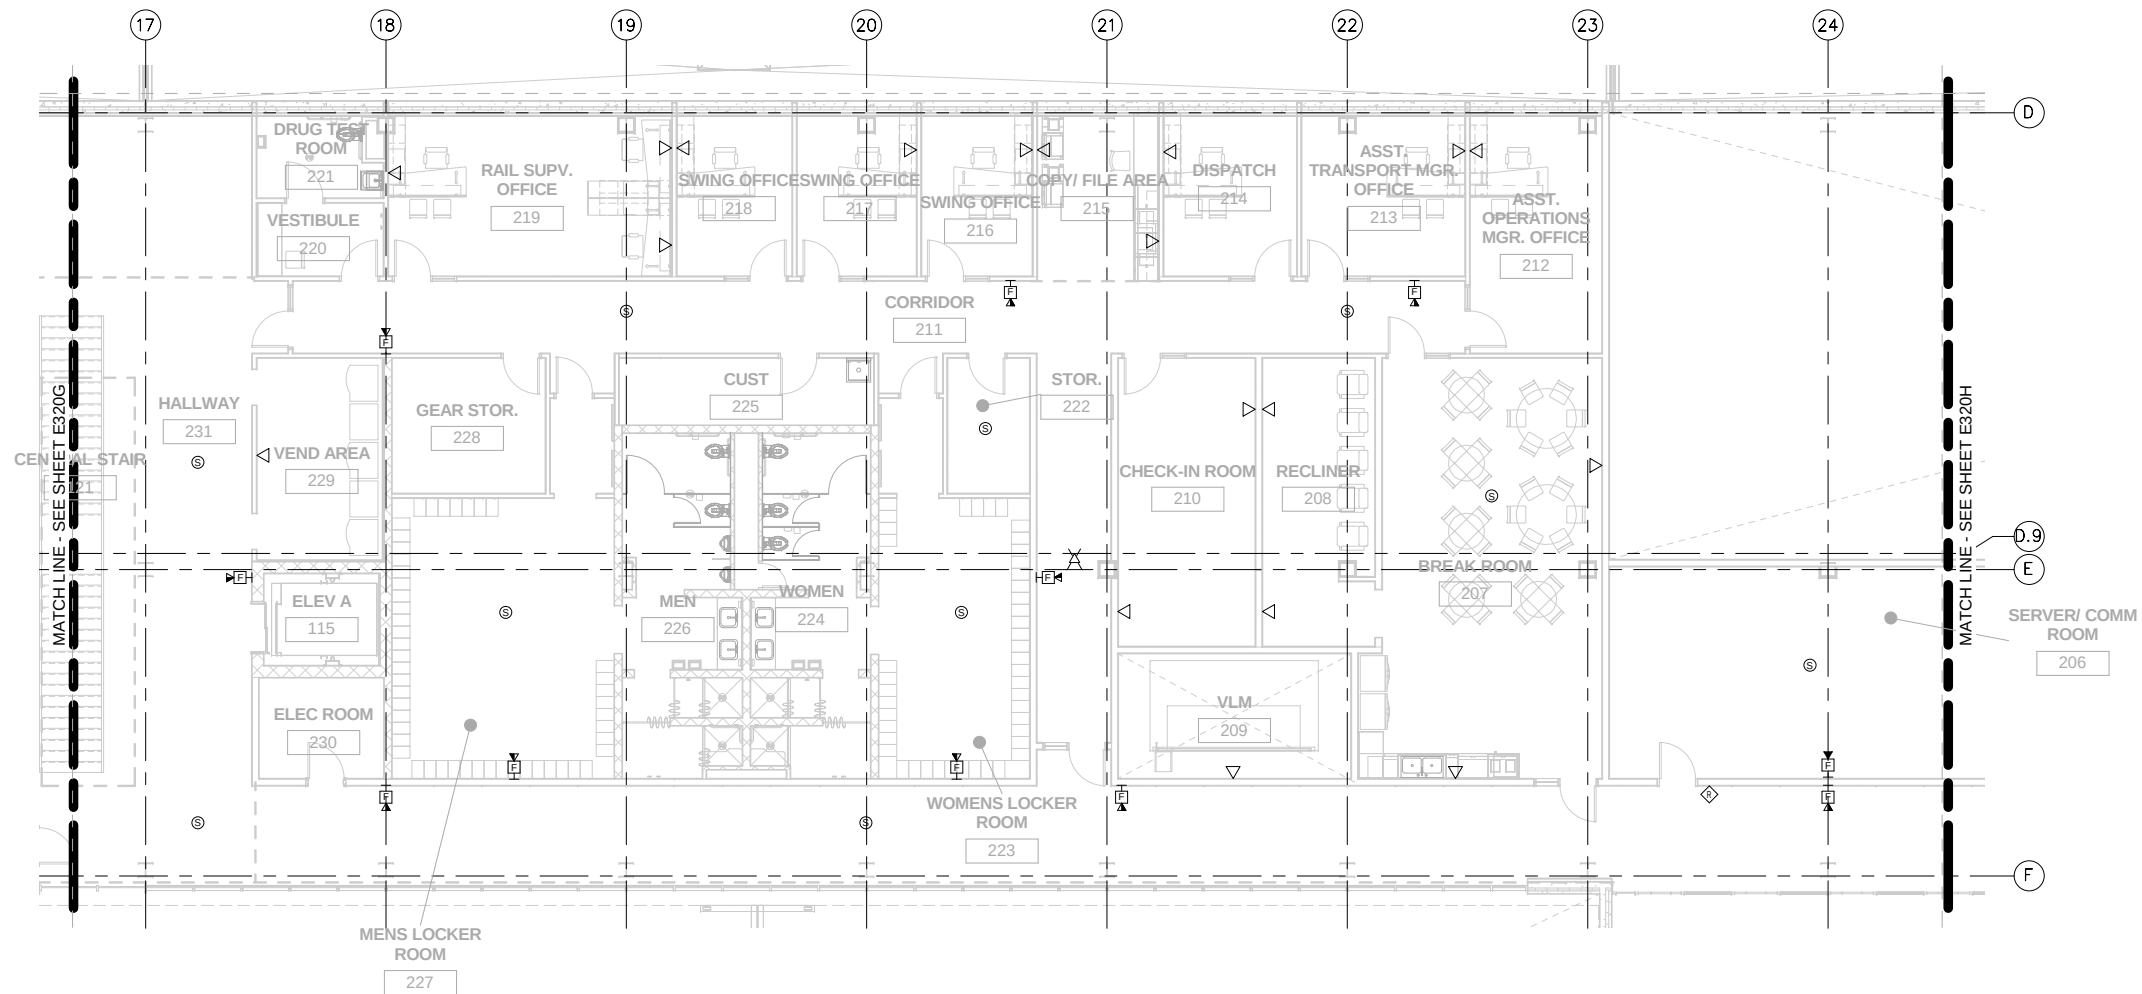

1 SYSTEMS PLAN - AREA G
E320G SCALE: 1/8" = 1'-0"

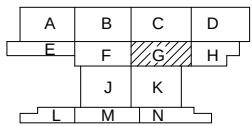

NO	DATE	BY	CHECK	DESIGN	REVISION / SUBMITTAL



60% SUBMISSION - 9/28/15



OPERATIONS & MAINTENANCE FACILITY - V2B
ELECTRICAL
SYSTEMS - LEVEL TWO - AREA G


DISCIPLINE:	SHEET NAME:	
ELECTRICAL	OMF-ELE-PLN	E320G

SHEET
215
OF
263


9/22/2015 10:11:32 AM C:\Users\jv-Begaj\Documents\OMF_ELEC_V-BegajB.rvt

GENERAL NOTES:

1. CONDUITS NOT SHOWN ON THIS SHEET.
2. RUN AND TERMINATE TWO CAT-6 CABLES TO ALL NETWORK OUTLETS EXCEPT WHERE OTHERWISE NOTED.

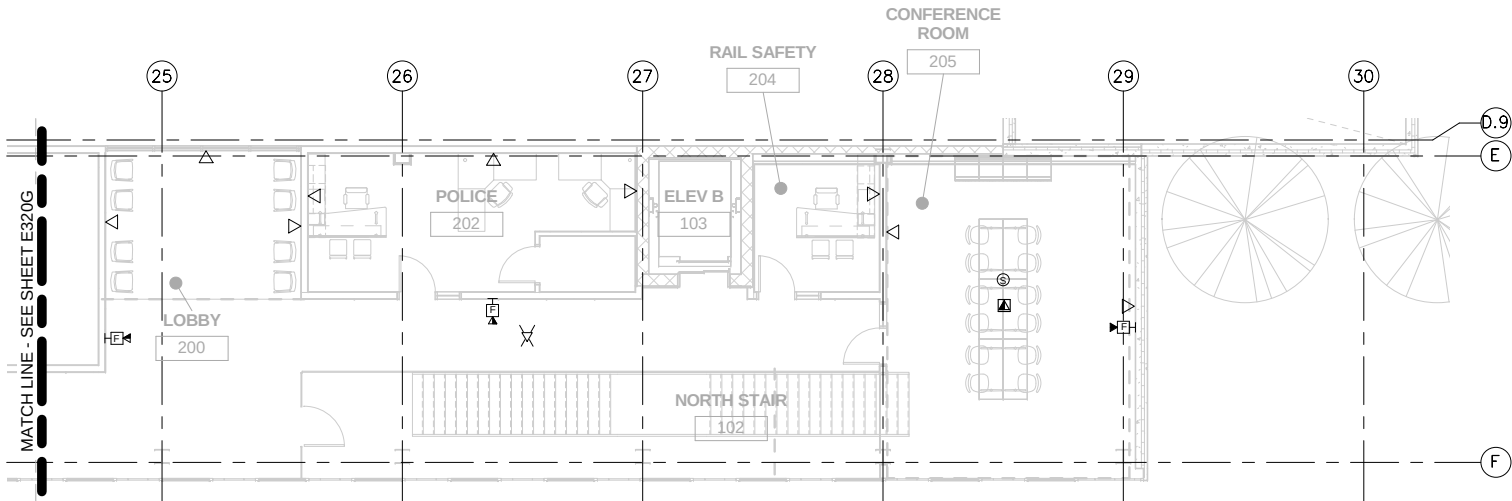

1 SYSTEMS PLAN - AREA H
E320H SCALE: 1/8" = 1'-0"

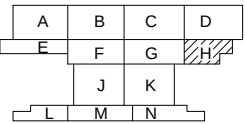

KEY PLAN - SCALE: N.T.S.

SCALE IN FEET

NO	DATE	BY	CHECK	DESIGN	REVISION / SUBMITTAL

AECOM
CONSULTING ENGINEERING
MINNEAPOLIS • MINNESOTA

MP Consultants
MINNEAPOLIS • MINNESOTA

60% SUBMISSION - 9/28/15

**METROPOLITAN**
COUNCIL

**SOUTHWEST**

OPERATIONS & MAINTENANCE FACILITY - V2B
ELECTRICAL
SYSTEMS - LEVEL TWO - AREA H


DISCIPLINE: ELECTRICAL

SHEET NAME: OMF-ELE-PLN

E320H

SHEET
216
OF
263



9/22/2015 10:11:35 AM C:\Users\IV-Bege\B\Documents\OMF_ELEC_V-Bege\B.rvt

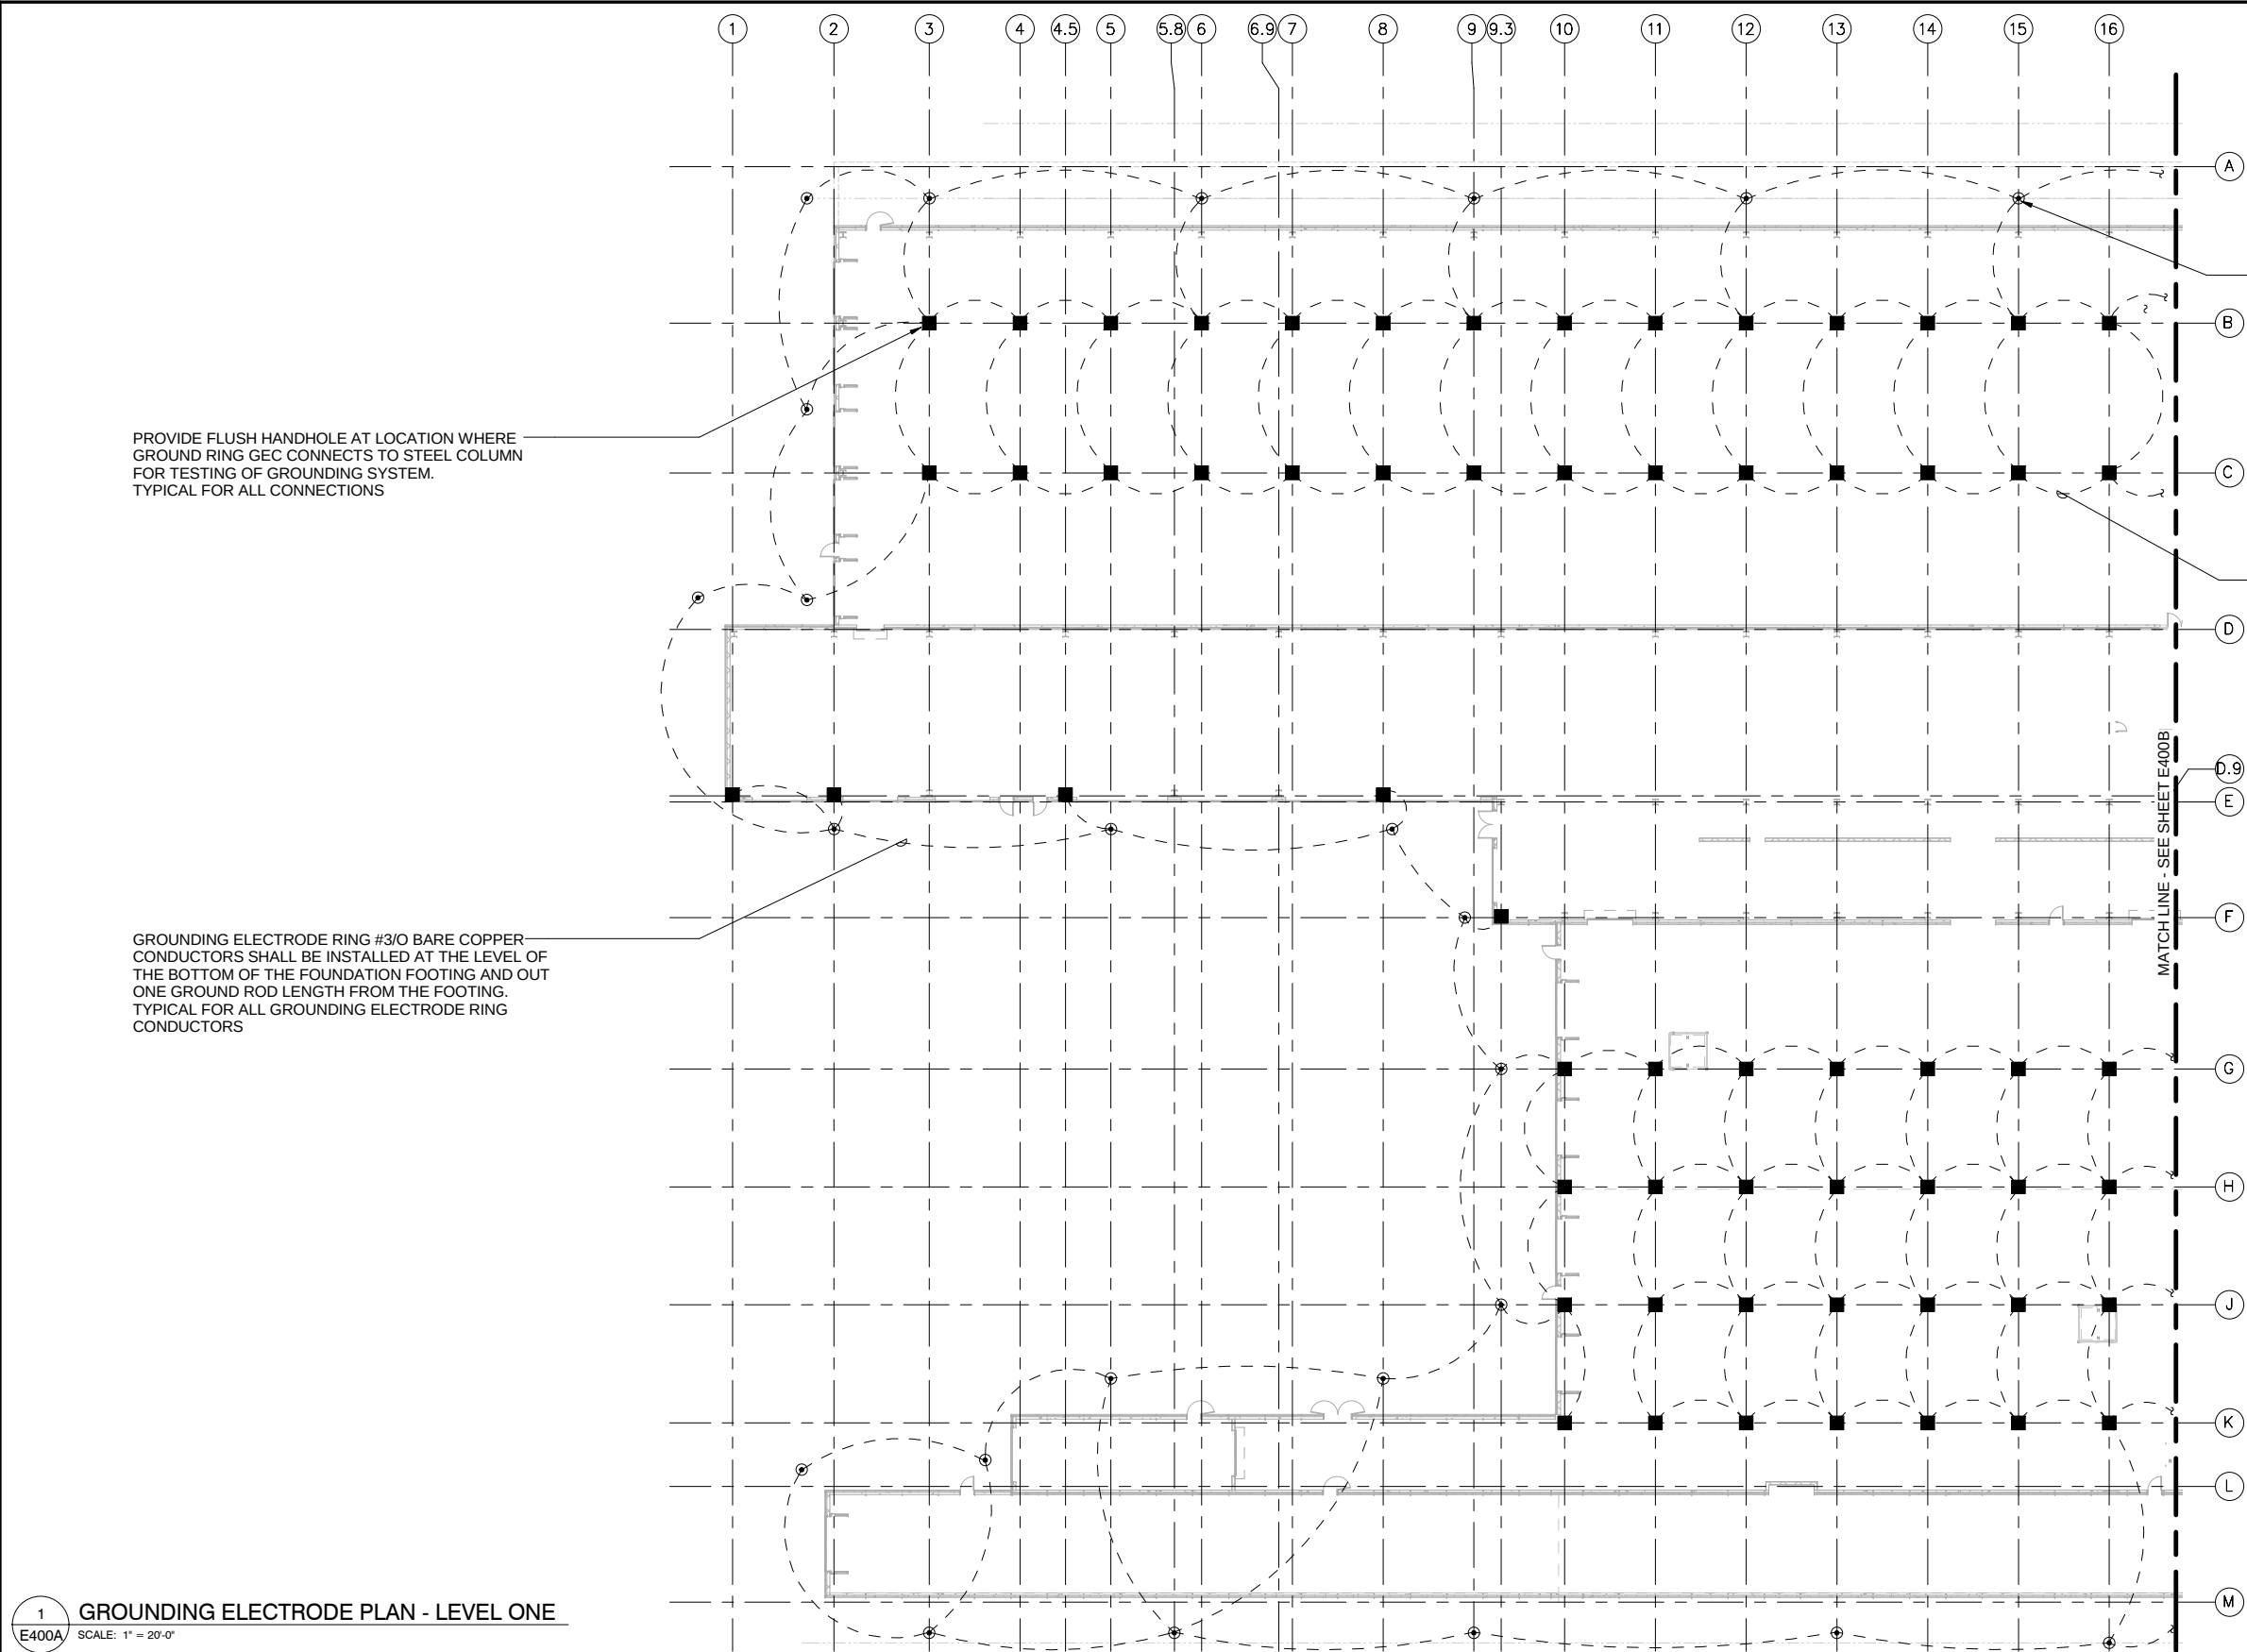

- GENERAL NOTES:**
1. ALL GROUND RODS, RING CONDUCTORS, UFER GROUND AND GEC STUB-UPS TO COLUMNS AND GROUND BUSSES SHALL BE INSTALLED DURING SITE EXCAVATION. INSTALLATION OF GEO-PIERS AND FORMING OF FOOTINGS GECS SHALL BE PROTECTED FROM DAMAGE.
- 40', 3/4" DIAMETER, PRE-MANUFACTURED GROUND ROD WITH COPPER COATING OVER GALVANIZED STEEL. GROUND ROD SHALL BE AUGERED IN WITH MINIMUM DIAMETER HOLE FOR ROD INSTALLATION. FILL VOID WITH GROUND ENHANCING MATERIAL FOR TESTING OF GROUND ROD. ALL EXOTHERMIC WELDS SHALL BE COATED WITH INHERT SILICON COATING TO PREVENT CORROSION OF WELD. TYPICAL FOR ALL GROUND RODS
- #3/0 BARE COPPER GROUNDING ELECTRODE CONDUCTORS SHALL BE INSTALLED IN THE BOTTOM OF THE FORM FOR THE STRUCTURAL FLOOR. GROUNDING ELECTRODE CONDUCTORS SHALL BE EXOTHERMIC WELDED TO THE STEEL COLUMN ABOVE GRADE SO WELD IS VISIBLE. TYPICAL FOR ALL GROUNDING ELECTRODE CONDUCTORS WITHIN BUILDING PARAMETER

1
E400A
SCALE: 1" = 20'-0"

GROUNDING ELECTRODE PLAN - LEVEL ONE

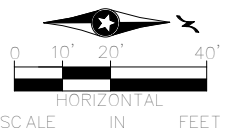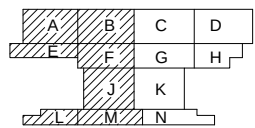

NO	DATE	BY	CHECK	DESIGN	REVISION / SUBMITTAL

AECOM

MP Consultants
CONSULTING ENGINEERING
MINNEAPOLIS, MINNESOTA

60% SUBMISSION - 9/28/15

**METROPOLITAN COUNCIL**

**SOUTHWEST**

OPERATIONS & MAINTENANCE FACILITY - V2B
ELECTRICAL


GROUNDING ELECTRODE PLAN - LEVEL ONE

DISCIPLINE: **ELECTRICAL**

SHEET NAME: **OMF-ELE-PLN**

E400A

9/22/2015 10:11:39 AM C:\Users\IV-Bege\B\Documents\OMF_ELEC_V-Bege\JB.rvt

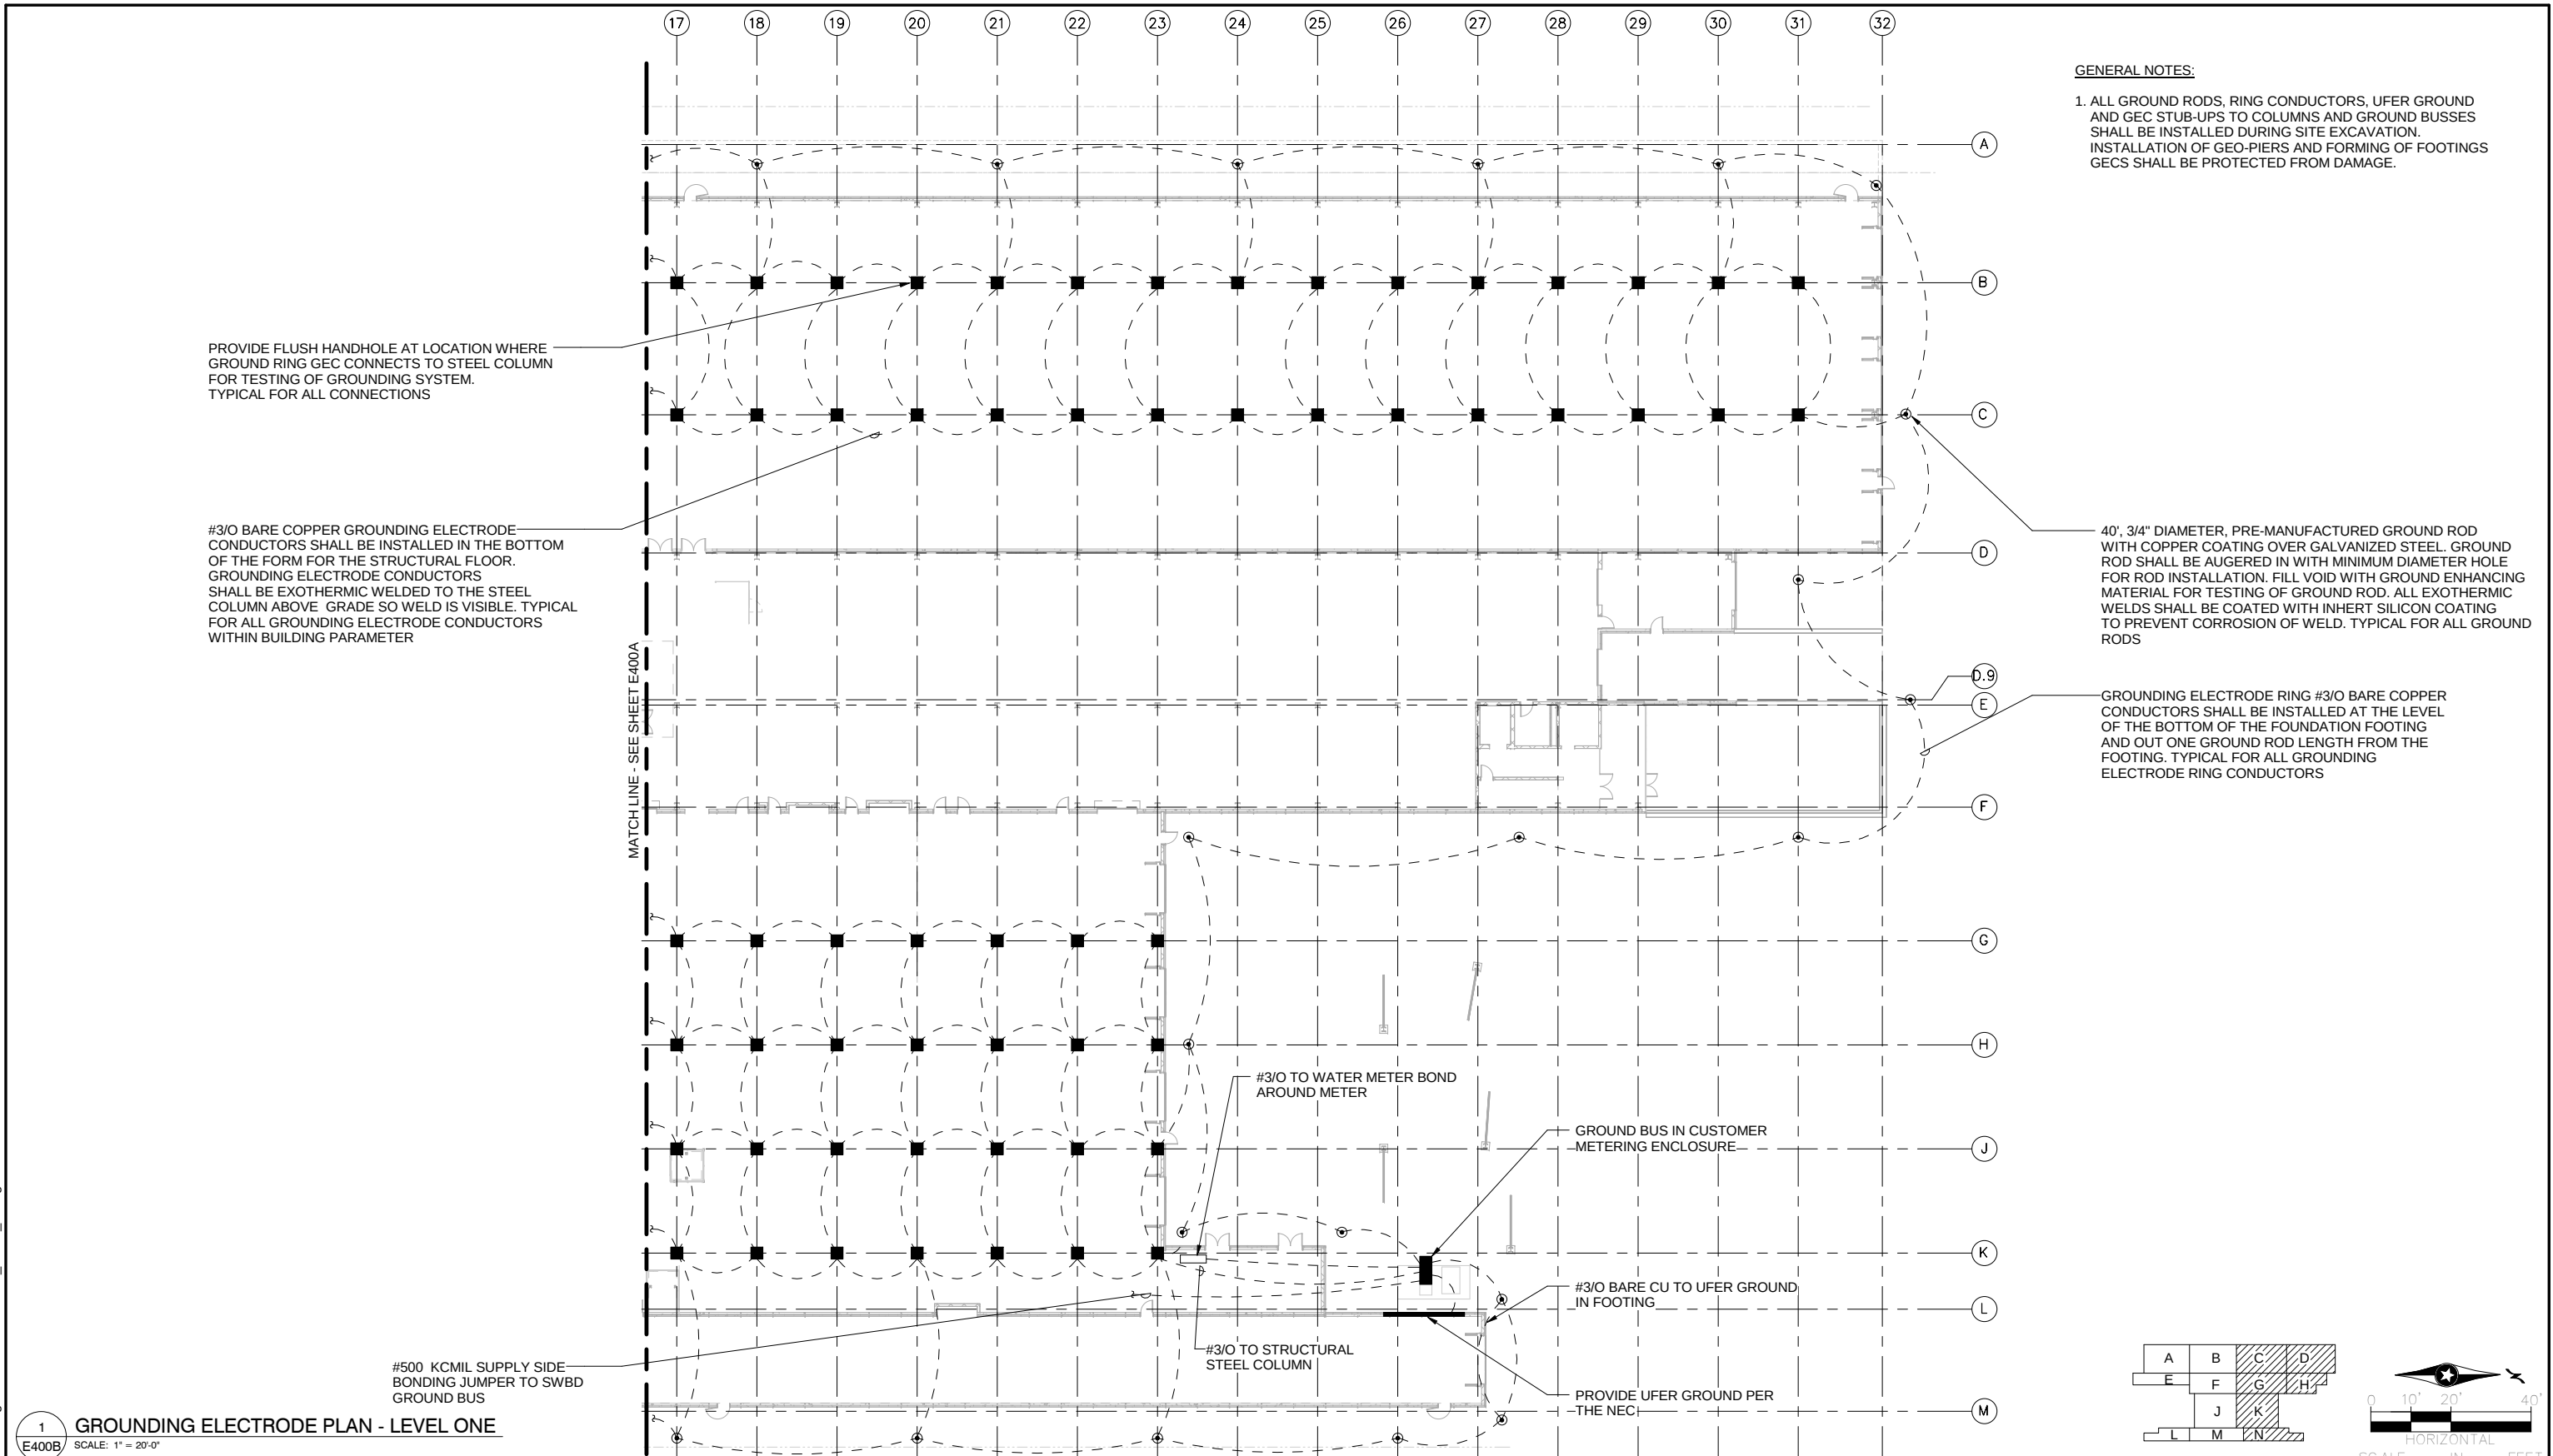

1
E400B
GROUNDING ELECTRODE PLAN - LEVEL ONE
SCALE: 1" = 20'-0"

NO	DATE	BY	CHECK	DESIGN	REVISION / SUBMITTAL

AECOM

MP Consultants
CONSULTING ENGINEERING
MINNEAPOLIS, MINNESOTA

METROPOLITAN
COUNCIL

SOUTHWEST

60% SUBMISSION - 9/28/15

OPERATIONS & MAINTENANCE FACILITY - V2B
ELECTRICAL

GROUNDING ELECTRODE PLAN - LEVEL ONE

DISCIPLINE: ELECTRICAL

SHEET NAME: OMF-ELE-PLN


E400B

SHEET

218

OF

263

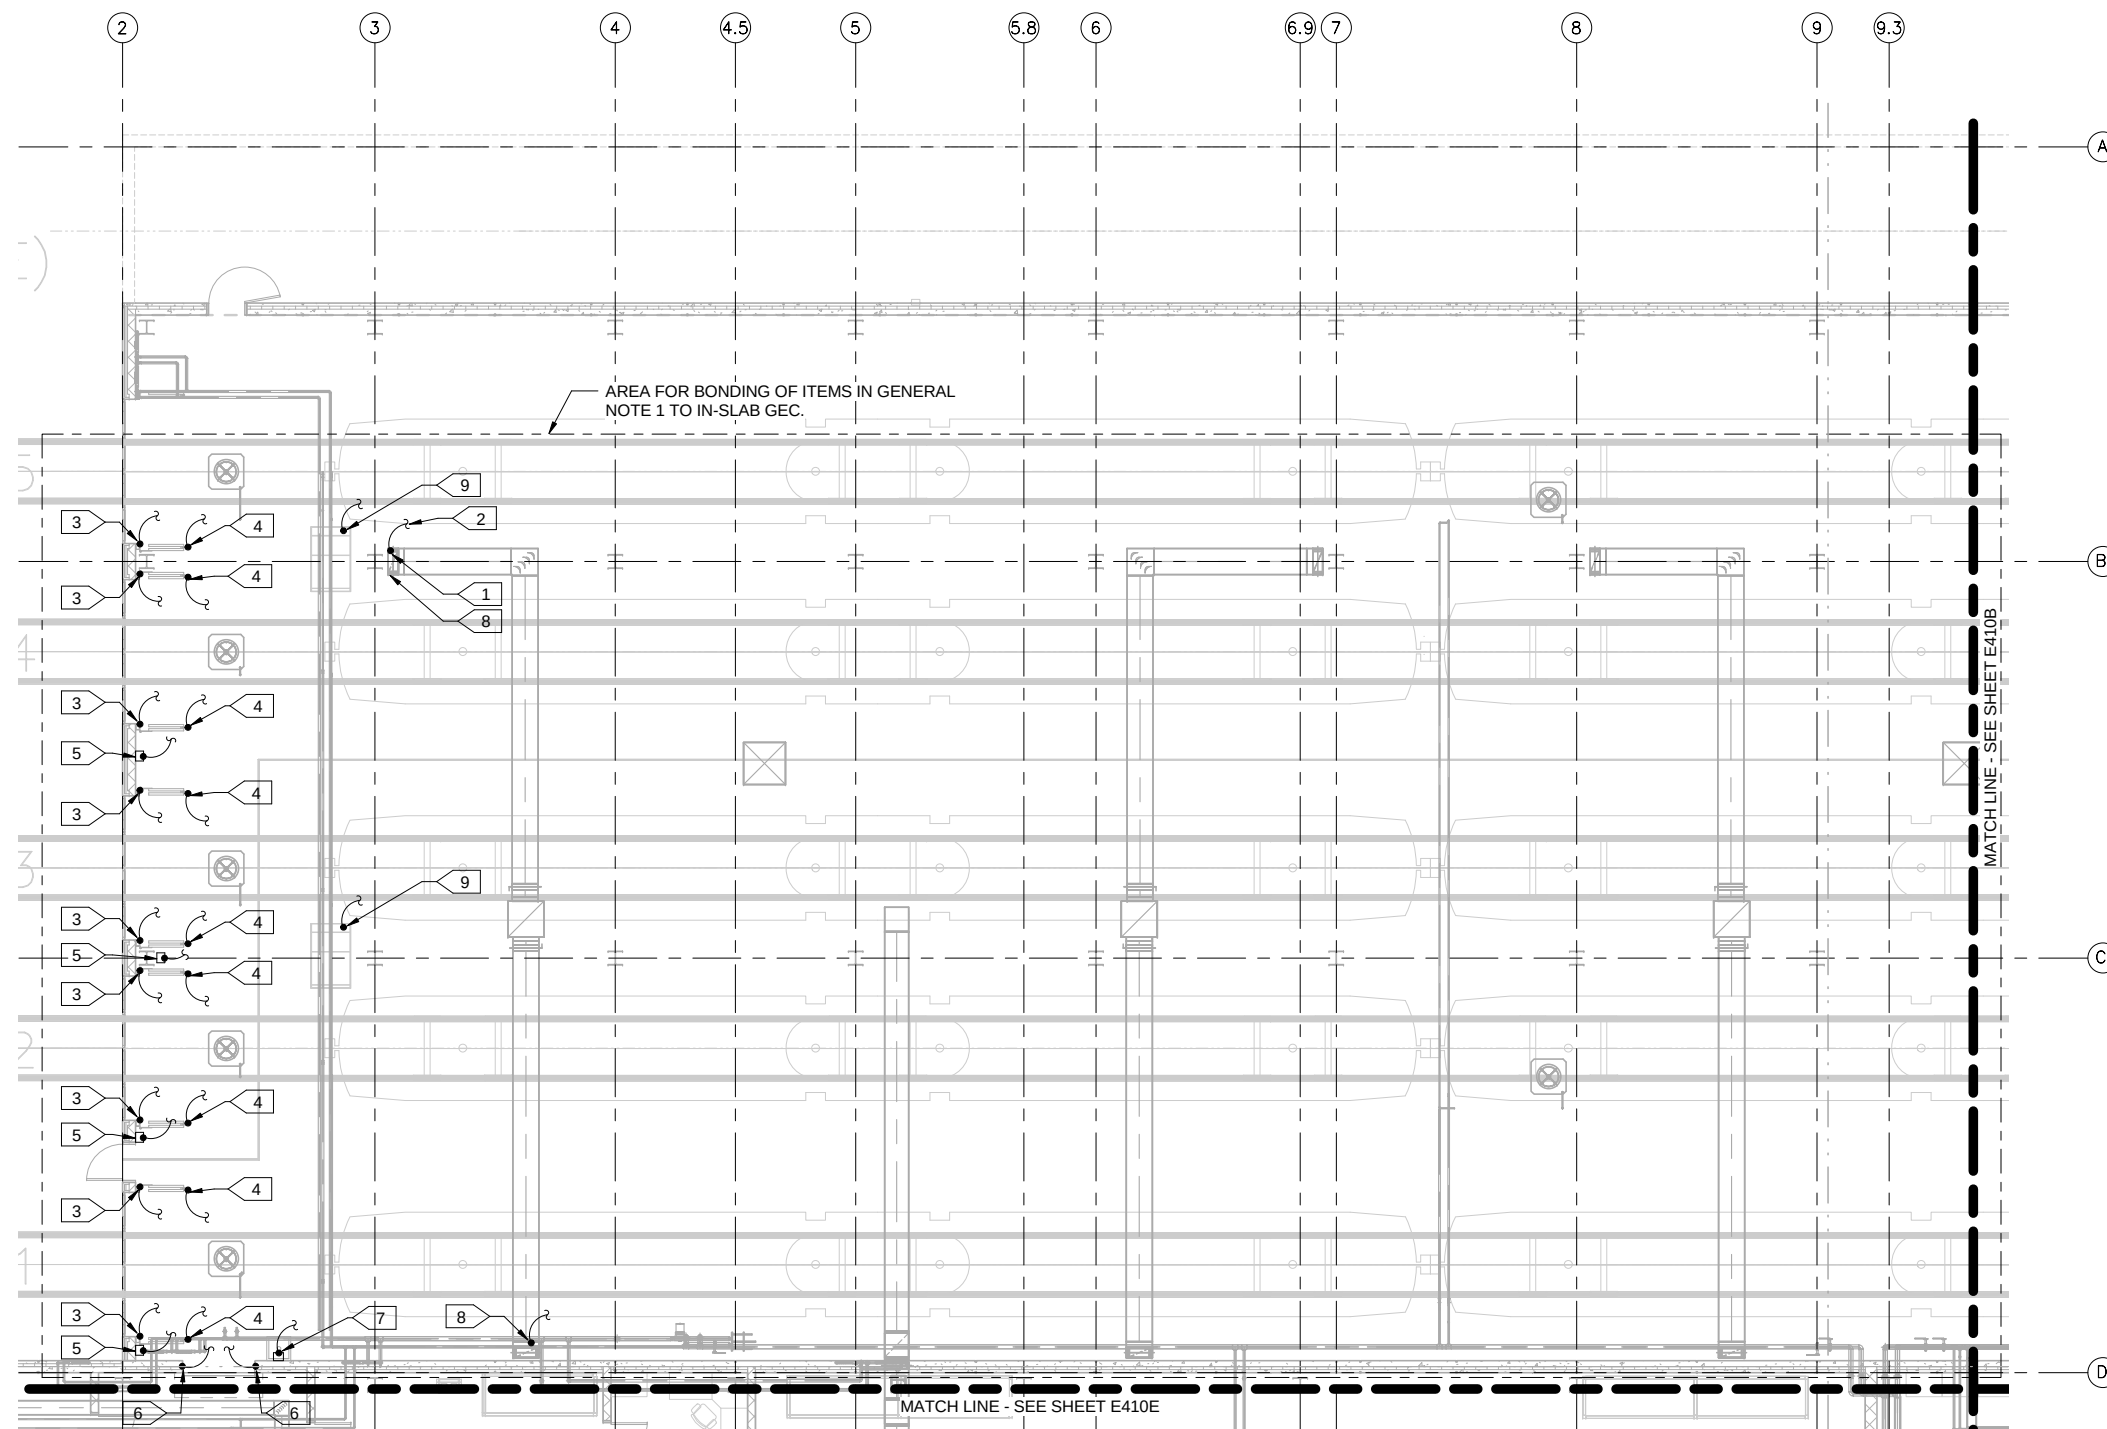

GENERAL NOTES:

1. ALL METALLIC ENCLOSURES, PANELS, PANELBOARDS, CONTROLLERS, PIPING, FIN TUBE RADIATOR COVERS, DUCT WORK, DOOR FRAMES, DOOR SENSORS, RAILINGS, BOLLARDS, WINDOW FRAMES, MECHANICAL AND INDUSTRIAL EQUIPMENT IN AREA INDICATED UP TO 9'-0" ABOVE FINISHED FLOOR SHALL BE BONDED TO NEAREST IN-SLAB GROUNDING ELECTRODE CONDUCTORS (GEC).
2. GEC CONNECTIONS BETWEEN ABOVE MENTIONED ITEMS AND IN-SLAB GROUNDING ELECTRODE CONDUCTORS SHALL BE BARE #2/O CU.
3. SEE GEC CONNECTION DETAILS ON SHEETS XXX.
4. VERIFY LOCATIONS OF ALL ITEMS PRIOR TO ROUGHING IN.
5. ALL GEC'S SHALL BE BELOW GRADE UNTIL READY FOR CONNECTIONS TO METAL OBJECTS.
6. GEC STUB UPS IN CONCRETE SHALL BE IN POCKETS IN CONCRETE UNTIL READY FOR CONNECTION TO METAL OBJECTS. POCKET SHALL BE COVERED TO PROTECT GEC.
7. ALL GEC'S SHALL BE BURIED AT THE END OF THE WORKING DAY SO THAT NO GEC'S SHALL BE LEFT EXPOSED AND SUBJECT TO VANDALISM OR THEFT.

KEYNOTES:

1. GEC CONNECTION TO ITEM NOTED (TYP).
2. GEC CONNECTION TO IN-SLAB GEC (TYP).
3. BI-FOLD DOOR FRAME.
4. PHOTOCELL SENSOR FOR BI-FOLD DOOR.
5. CONTROLLER(S) FOR BI-FOLD DOORS.
6. DOOR FRAME.
7. COPPER WATER LINE.
8. RETURN AIR DUCT AT FLOOR.
9. HOPPER

1 SAFETY GROUNDING SYSTEM - AREA A
E410A SCALE: 1/8" = 1'-0"

[illegible]

60% SUBMISSION - 9/28/15



OPERATIONS & MAINTENANCE FACILITY - V2B
ELECTRICAL
SAFETY GROUNDING SYSTEM - LEVEL ONE -
AREA A

DISCIPLINE:

ELECTRICAL

SHEET NAME:

NAME: **OMF-ELE-PLN**


E410A

SHEET


219

OF

263

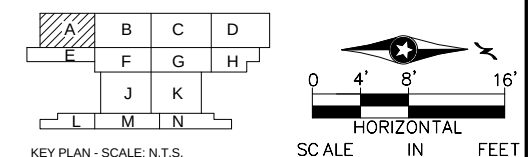

9/22/2015 10:11:47 AM C:\Users\jv-Begaj\Documents\OMF_ELEC_V-BegajB.rvt

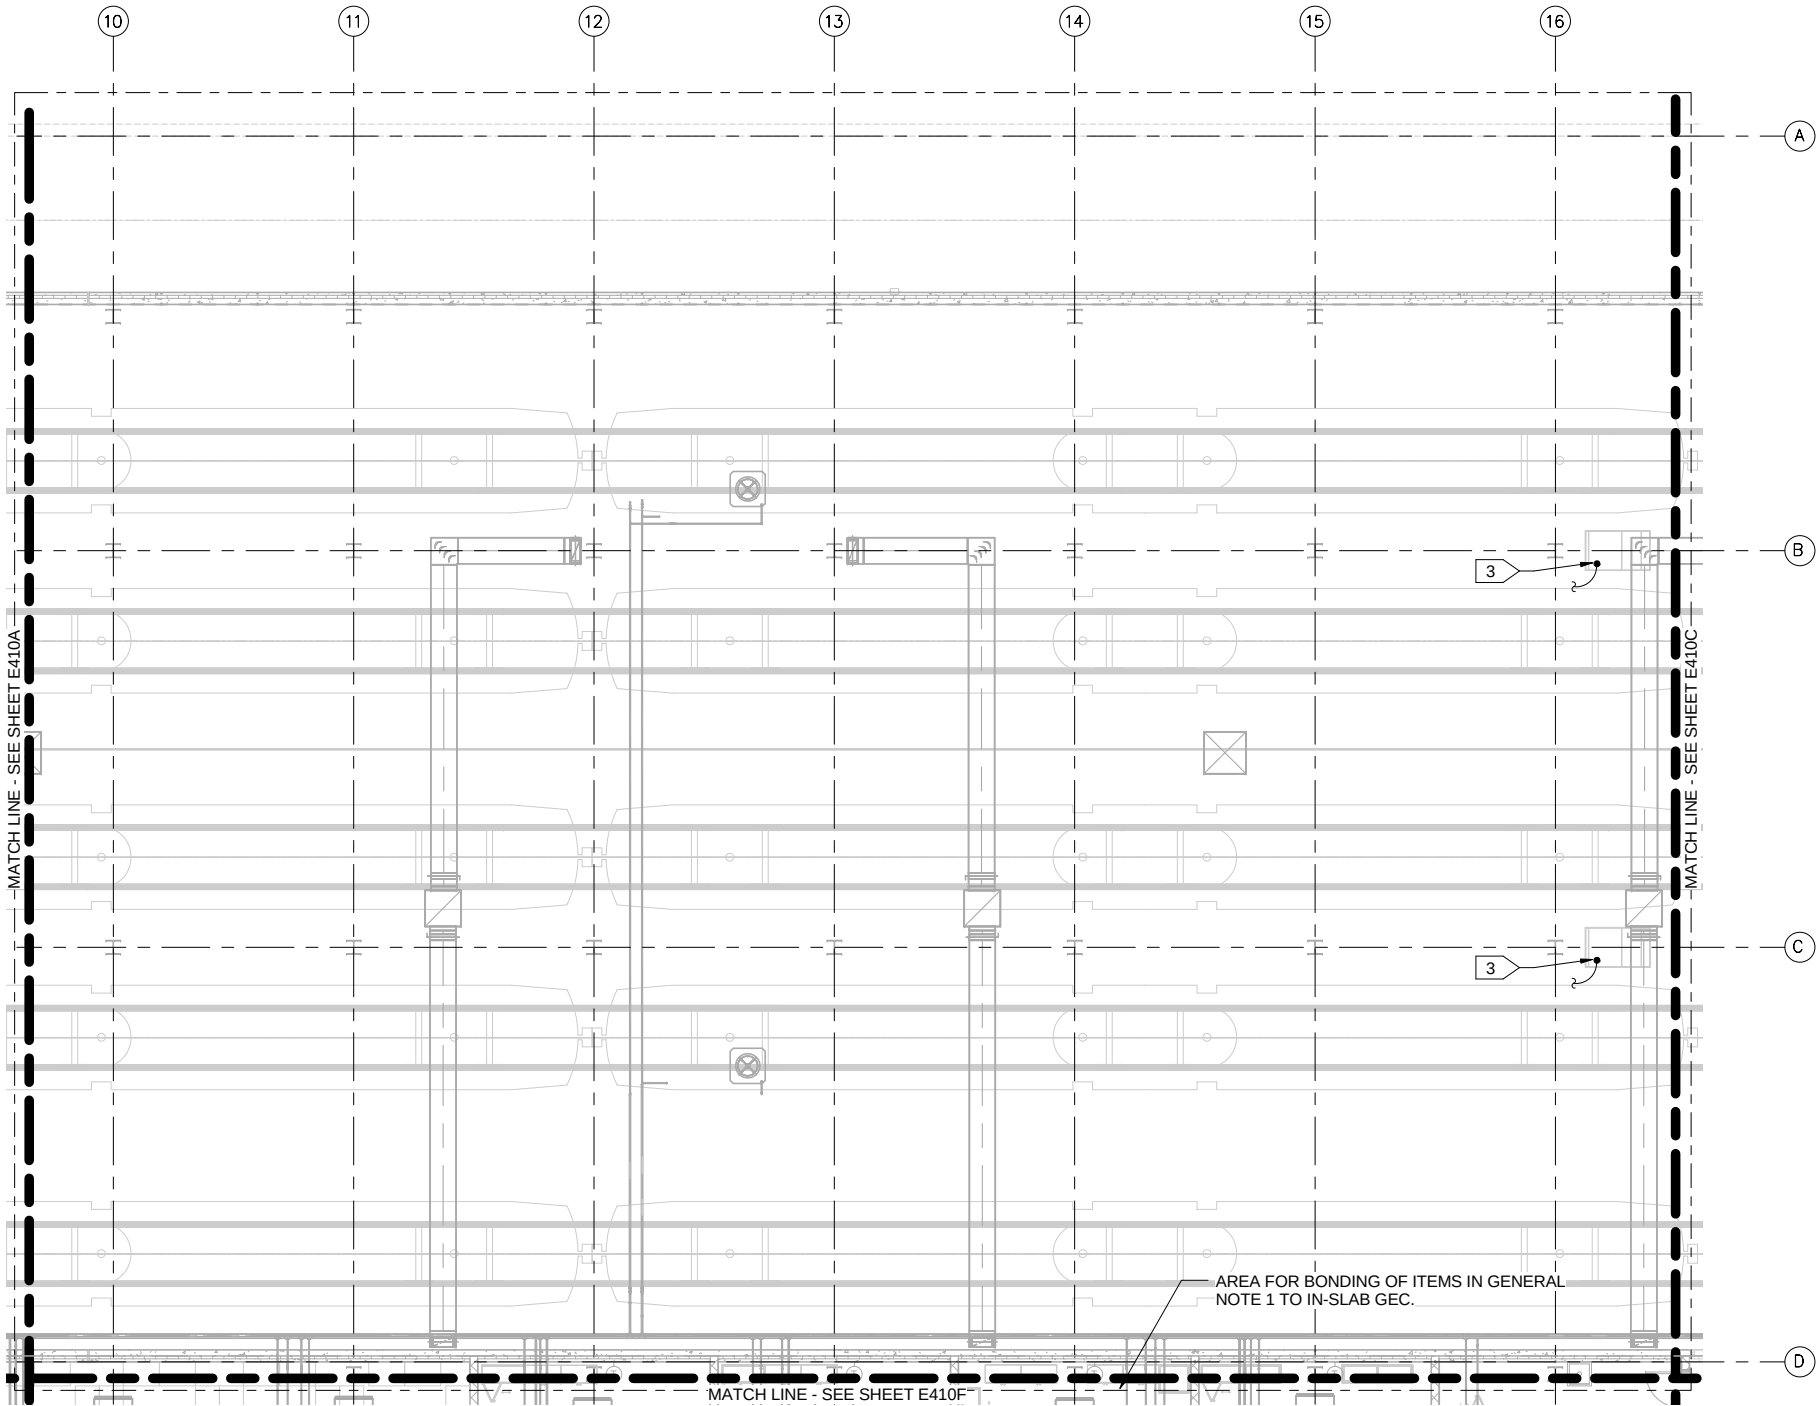

GENERAL NOTES:

1. ALL METALLIC ENCLOSURES, PANELS PANELBOARDS, CONTROLLERS, PIPING, FIN TUBE RADIATOR COVERS, DUCT WORK, DOOR FRAMES, DOOR SENSORS, RAILINGS, BOLLARDS, WINDOW FRAMES, MECHANICAL AND INDUSTRIAL EQUIPMENT IN AREA INDICATED UP TO 9'-0" ABOVE FINISHED FLOOR SHALL BE BONDED TO NEAREST IN-SLAB GROUNDING ELECTRODE CONDUCTORS (GEC).
2. GEC CONNECTIONS BETWEEN ABOVE MENTIONED ITEMS AND IN-SLAB GROUNDING ELECTRODE CONDUCTORS SHALL BE BARE #2/O CU.
3. SEE GEC CONNECTION DETAILS ON SHEETS XXX.
4. VERIFY LOCATIONS OF ALL ITEMS PRIOR TO ROUGHING IN.
5. ALL GEC'S SHALL BE BELOW GRADE UNTIL READY FOR CONNECTIONS TO METAL OBJECTS.
6. GEC STUB UPS IN CONCRETE SHALL BE IN POCKETS IN CONCRETE UNTIL READY FOR CONNECTION TO METAL OBJECTS. POCKET SHALL BE COVERED TO PROTECT GEC.
7. ALL GEC'S SHALL BE BURIED AT THE END OF THE WORKING DAY SO THAT NO GEC'S SHALL BE LEFT EXPOSED AND SUBJECT TO VANDALISM OR THEFT.

KEYNOTES:



1. GEC CONNECTION TO ITEM NOTED (TYP).
2. GEC CONNECTION TO IN-SLAB GEC (TYP).
3. HOPPER.

1 SAFETY GROUNDING SYSTEM - AREA B
E410B SCALE: 1/8" = 1'-0"

NO	DATE	BY	CHECK	DESIGN	REVISION / SUBMITTAL

AECOM

MP Consultants
CONSULTING ENGINEERING
MINNEAPOLIS, MINNESOTA

60% SUBMISSION - 9/28/15

**METROPOLITAN COUNCIL**

**SOUTHWEST**


OPERATIONS & MAINTENANCE FACILITY - V2B
ELECTRICAL
SAFETY GROUNDING SYSTEM - LEVEL ONE - AREA B

DISCIPLINE: **ELECTRICAL**

SHEET NAME: **OMF-ELE-PLN**

E410B


SHEET
220
OF
263

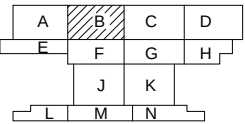

KEY PLAN - SCALE: N.T.S.



SCALE IN FEET
HORIZONTAL

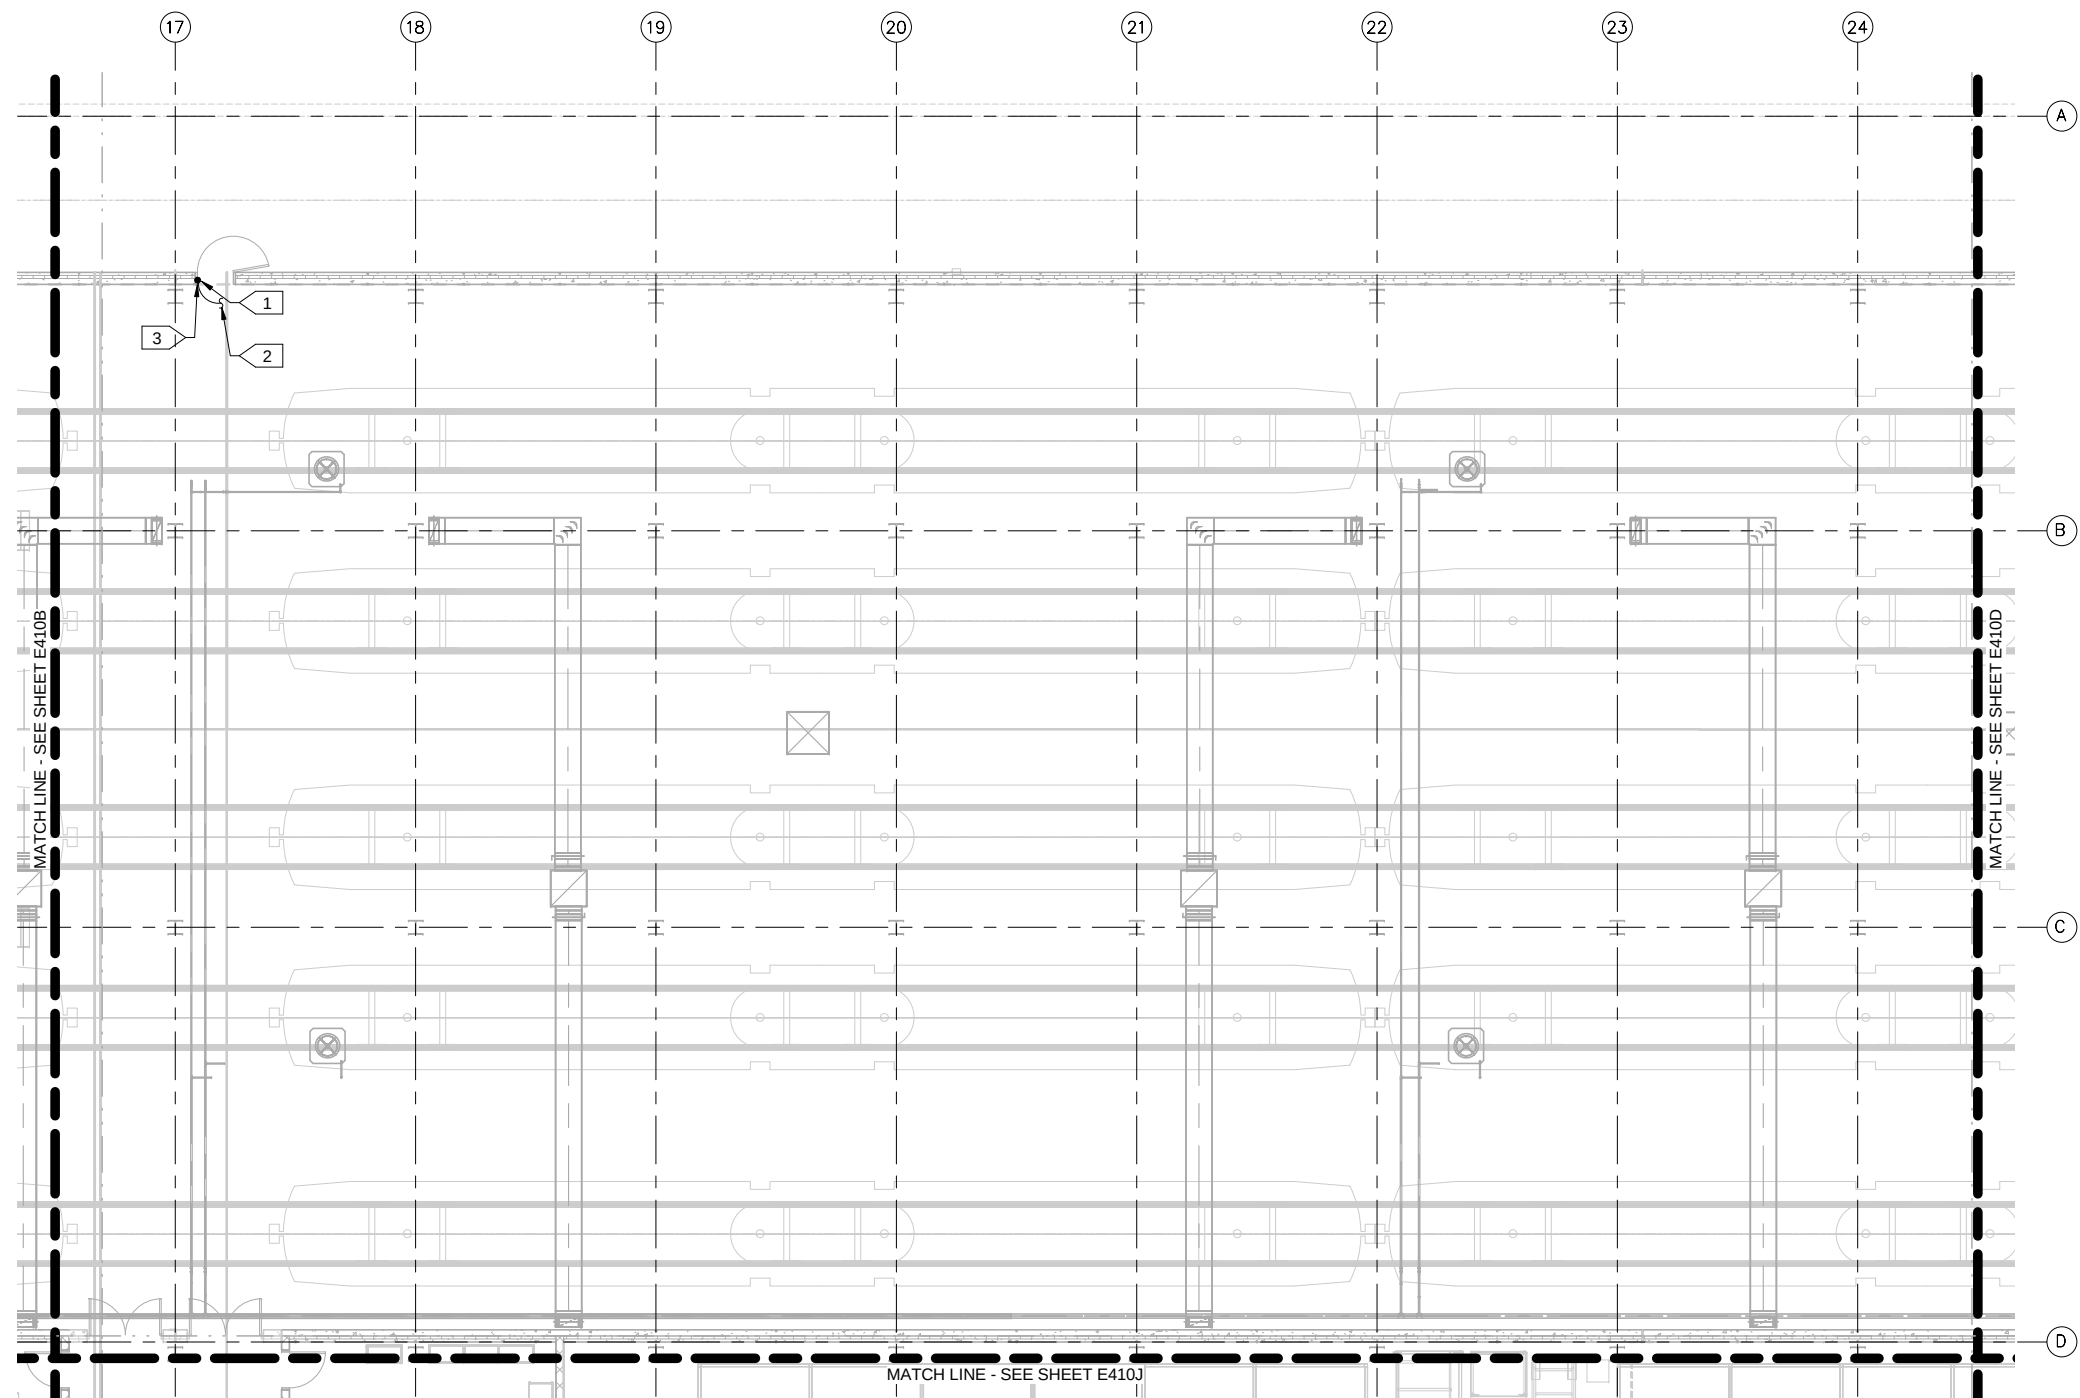

GENERAL NOTES:

1. ALL METALLIC ENCLOSURES, PANELS PANELBOARDS, CONTROLLERS, PIPING, FIN TUBE RADIATOR COVERS, DUCT WORK, DOOR FRAMES, DOOR SENSORS, RAILINGS, BOLLARDS, WINDOW FRAMES, MECHANICAL AND INDUSTRIAL EQUIPMENT IN AREA INDICATED UP TO 9'-0" ABOVE FINISHED FLOOR SHALL BE BONDED TO NEAREST IN-SLAB GROUNDING ELECTRODE CONDUCTORS (GEC).
2. GEC CONNECTIONS BETWEEN ABOVE MENTIONED ITEMS AND IN-SLAB GROUNDING ELECTRODE CONDUCTORS SHALL BE BARE #2/O CU.
3. SEE GEC CONNECTION DETAILS ON SHEETS XXX.
4. VERIFY LOCATIONS OF ALL ITEMS PRIOR TO ROUGHING IN.
5. ALL GEC'S SHALL BE BELOW GRADE UNTIL READY FOR CONNECTIONS TO METAL OBJECTS.
6. GEC STUB UPS IN CONCRETE SHALL BE IN POCKETS IN CONCRETE UNTIL READY FOR CONNECTION TO METAL OBJECTS. POCKET SHALL BE COVERED TO PROTECT GEC.
7. ALL GEC'S SHALL BE BURIED AT THE END OF THE WORKING DAY SO THAT NO GEC'S SHALL BE LEFT EXPOSED AND SUBJECT TO VANDALISM OR THEFT.

KEYNOTES:

1. GEC CONNECTION TO ITEM NOTED (TYP).
2. GEC CONNECTION TO IN-SLAB GEC (TYP).
3. DOOR FRAME.

1 SAFETY GROUNDING SYSTEM - AREA C
E410C SCALE: 1/8" = 1'-0"

E410C SCALE: 1/8" = 1'-0"

[illegible]

AECOM *MP Consultants*
CONSULTING ENGINEERING
MINNEAPOLIS • MINNESOTA

M-P CONSULTANTS

CONSULTING ENGINEERING
MINNEAPOLIS • MINNESOTA

60% SUBMISSION - 9/28/15



SOUTHWEST

**OPERATIONS & MAINTENANCE FACILITY - V2B
ELECTRICAL
SAFETY GROUNDING SYSTEM - LEVEL ONE -
AREA C**

ELECTRICAL

SAFETY GROUNDING SYSTEM - LEVEL ONE - AREA C

DISCIPLINE:

ELECTRICAL

SHEET NAME:

OMF-ELE-PLN


E410C

SHEET

221

OF

263

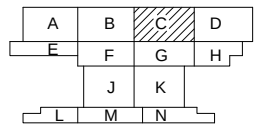


KEY PLAN - SCALE: N.T.S.



SCALE IN FEET

SCALE IN FEET

9/22/2015 10:11:55 AM C:\Users\jv-Beggs\Documents\OMF_ELEC_V-Beggs\B.rvt

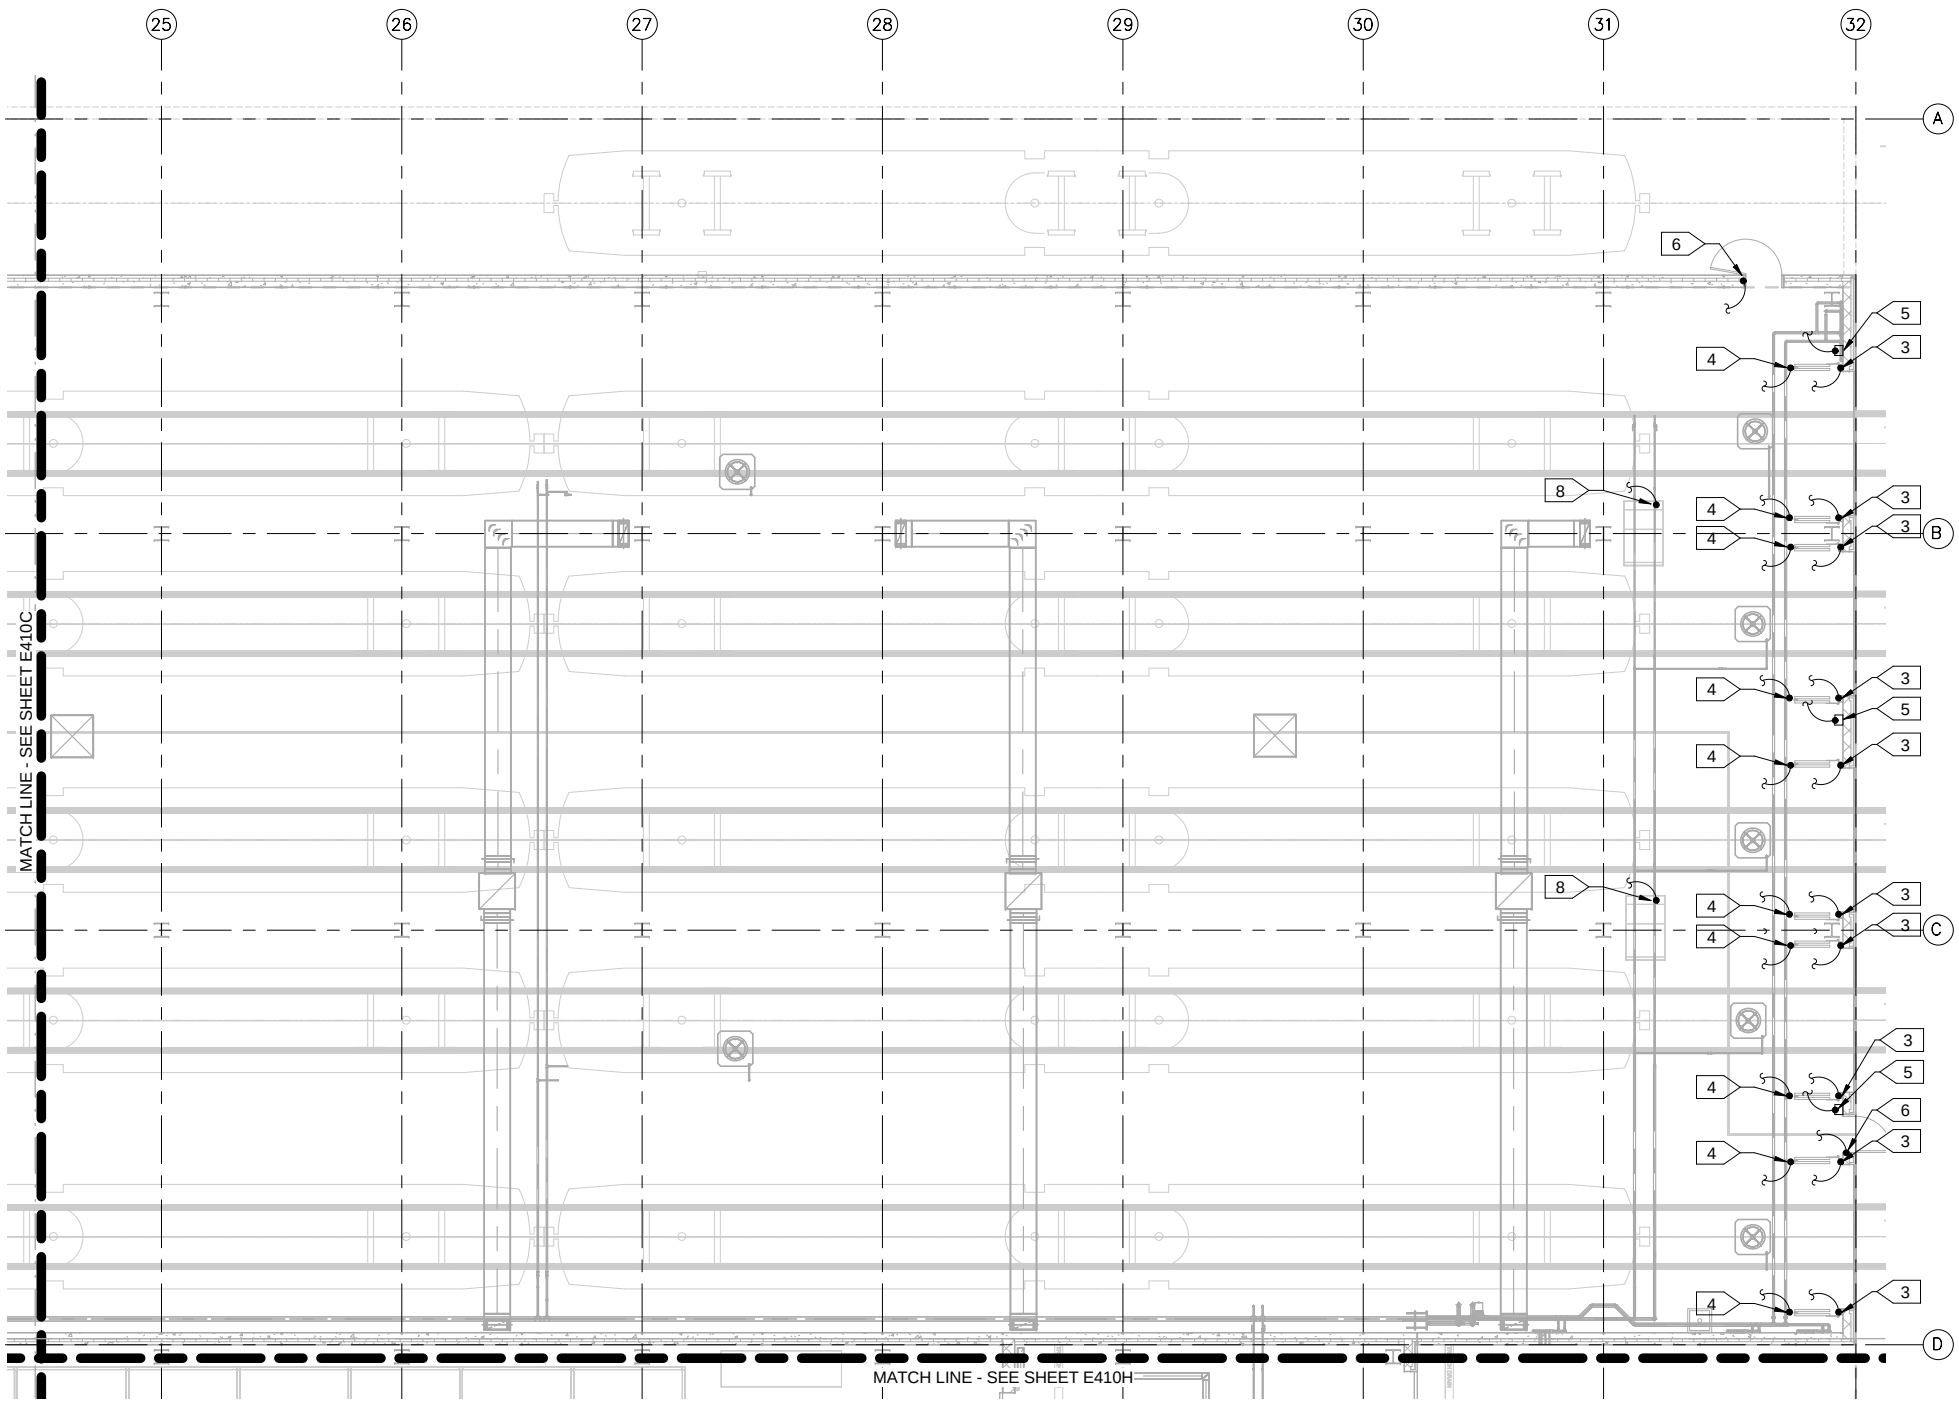

- GENERAL NOTES:**
1. ALL METALLIC ENCLOSURES, PANELS PANELBOARDS, CONTROLLERS, PIPING, FIN TUBE RADIATOR COVERS, DUCT WORK, DOOR FRAMES, DOOR SENSORS, RAILINGS, BOLLARDS, WINDOW FRAMES, MECHANICAL AND INDUSTRIAL EQUIPMENT IN AREA INDICATED UP TO 9'-0" ABOVE FINISHED FLOOR SHALL BE BONDED TO NEAREST IN-SLAB GROUNDING ELECTRODE CONDUCTORS (GEC).
 2. GEC CONNECTIONS BETWEEN ABOVE MENTIONED ITEMS AND IN-SLAB GROUNDING ELECTRODE CONDUCTORS SHALL BE BARE #2/O CU.
 3. SEE GEC CONNECTION DETAILS ON SHEETS XXX.
 4. VERIFY LOCATIONS OF ALL ITEMS PRIOR TO ROUGHING IN.
 5. ALL GEC'S SHALL BE BELOW GRADE UNTIL READY FOR CONNECTIONS TO METAL OBJECTS.
 6. GEC STUB UPS IN CONCRETE SHALL BE IN POCKETS IN CONCRETE UNTIL READY FOR CONNECTION TO METAL OBJECTS. POCKET SHALL BE COVERED TO PROTECT GEC.
 7. ALL GEC'S SHALL BE BURIED AT THE END OF THE WORKING DAY SO THAT NO GEC'S SHALL BE LEFT EXPOSED AND SUBJECT TO VANDALISM OR THEFT.

- KEYNOTES:**
- 
1. GEC CONNECTION TO ITEM NOTED (TYP).
 2. GEC CONNECTION TO IN-SLAB GEC (TYP).
 3. BI-FOLD DOOR FRAME.
 4. PHOTOCELL SENSOR FOR BI-FOLD DOOR.
 5. CONTROLLER(S) FOR BI-FOLD DOORS.
 6. DOOR FRAME.
 7. HOPPER

1
E410D SAFETY GROUNDING SYSTEM - AREA D
SCALE: 1/8" = 1'-0"

NO	DATE	BY	CHECK	DESIGN	REVISION / SUBMITTAL


AECOM *MP Consultants*
CONSULTING ENGINEERING
MINNEAPOLIS, MINNESOTA

60% SUBMISSION - 9/28/15



OPERATIONS & MAINTENANCE FACILITY - V2B
ELECTRICAL
SAFETY GROUNDING SYSTEM - LEVEL ONE - AREA D

DISCIPLINE: **ELECTRICAL** SHEET NAME: **OMF-ELE-PLN E410D**

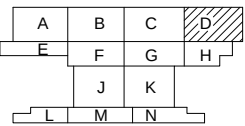


KEY PLAN - SCALE: N.T.S.



SCALE IN FEET

SHEET
222
OF
263

9/22/2015 10:11:59 AM C:\Users\IV-Bege\B\Documents\OMF_ELEC_V-Bege\B.rvt

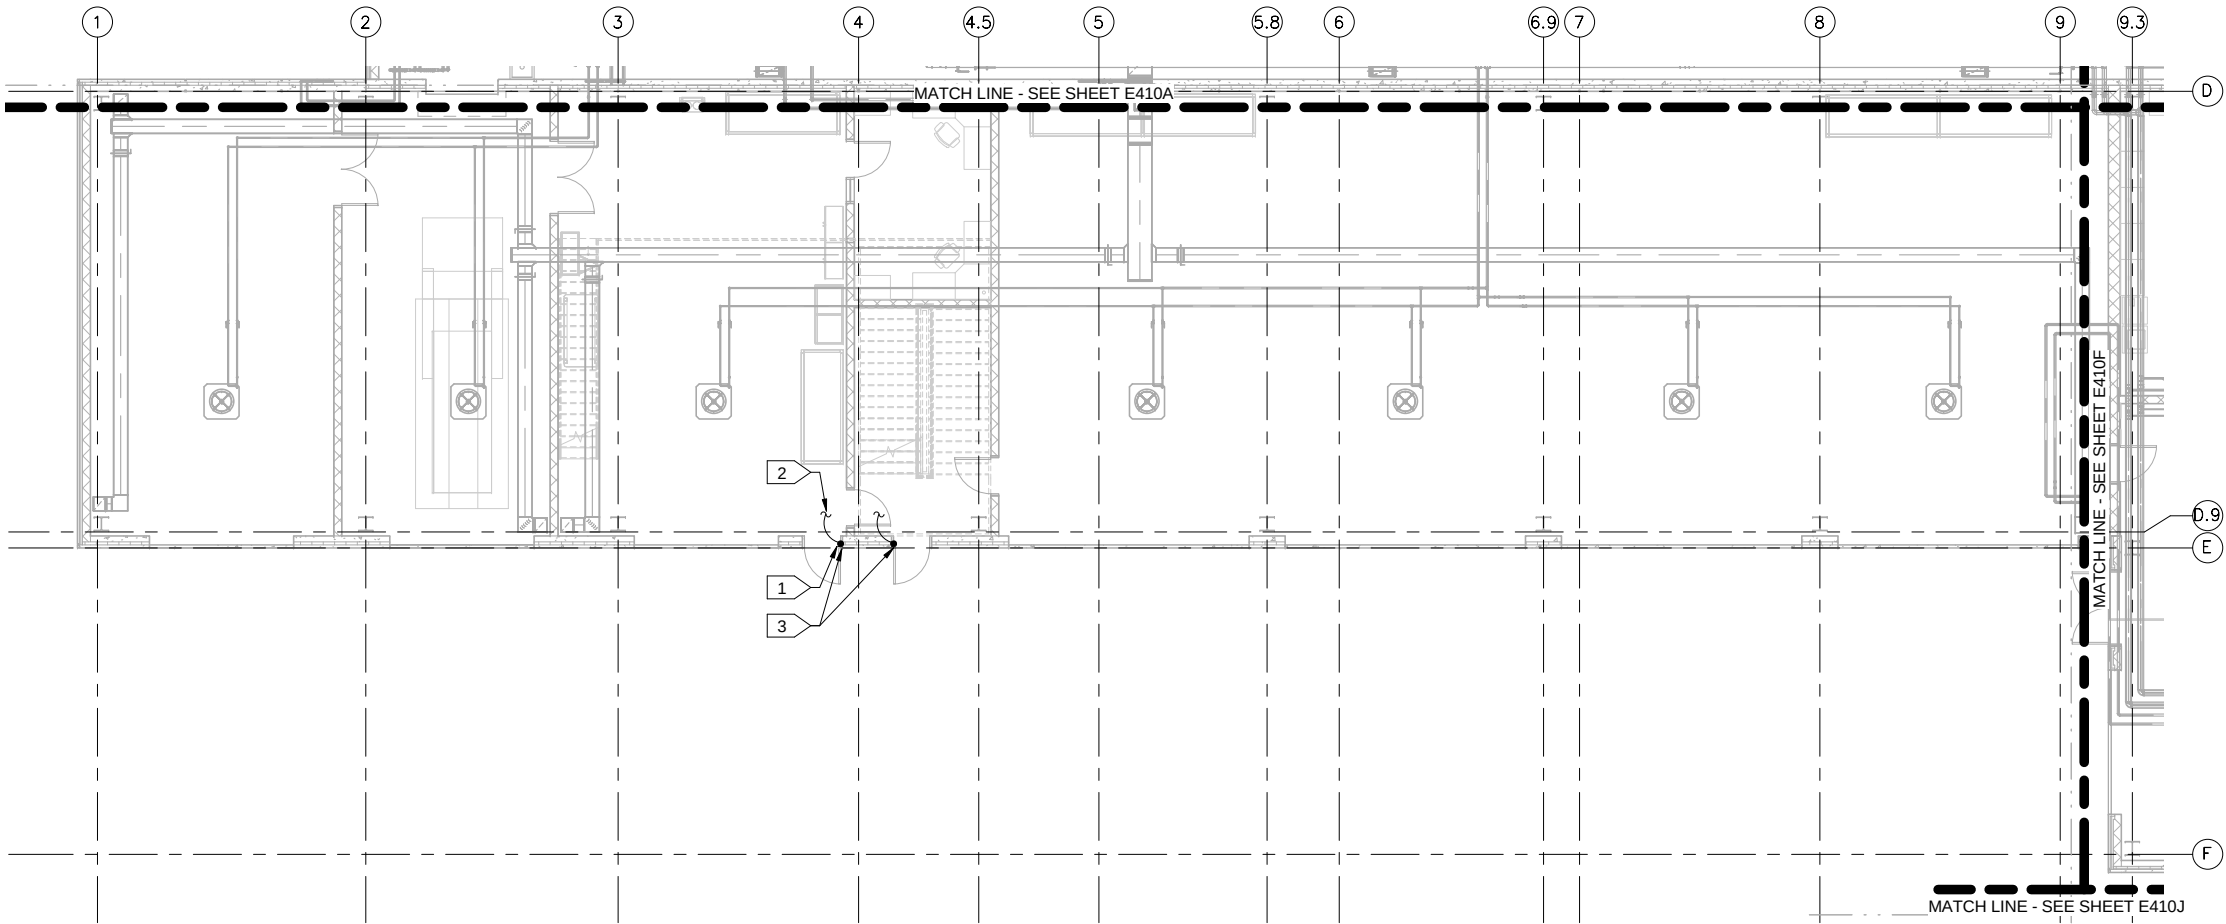

GENERAL NOTES:

1. ALL METALLIC ENCLOSURES, PANELS PANELBOARDS, CONTROLLERS, PIPING, FIN TUBE RADIATOR COVERS, DUCT WORK, DOOR FRAMES, DOOR SENSORS, RAILINGS, BOLLARDS, WINDOW FRAMES, MECHANICAL AND INDUSTRIAL EQUIPMENT IN AREA INDICATED UP TO 9'-0" ABOVE FINISHED FLOOR SHALL BE BONDED TO NEAREST IN-SLAB GROUNDING ELECTRODE CONDUCTORS (GEC).
2. GEC CONNECTIONS BETWEEN ABOVE MENTIONED ITEMS AND IN-SLAB GROUNDING ELECTRODE CONDUCTORS SHALL BE BARE #2/O CU.
3. SEE GEC CONNECTION DETAILS ON SHEETS XXX.
4. VERIFY LOCATIONS OF ALL ITEMS PRIOR TO ROUGHING IN.
5. ALL GEC'S SHALL BE BELOW GRADE UNTIL READY FOR CONNECTIONS TO METAL OBJECTS.
6. GEC STUB UPS IN CONCRETE SHALL BE IN POCKETS IN CONCRETE UNTIL READY FOR CONNECTION TO METAL OBJECTS. POCKET SHALL BE COVERED TO PROTECT GEC.
7. ALL GEC'S SHALL BE BURIED AT THE END OF THE WORKING DAY SO THAT NO GEC'S SHALL BE LEFT EXPOSED AND SUBJECT TO VANDALISM OR THEFT.

KEYNOTES:

1. GEC CONNECTION TO ITEM NOTED (TYP).
2. GEC CONNECTION TO IN-SLAB GEC (TYP).
3. DOOR FRAME.

1 SAFETY GROUNDING SYSTEM - AREA E
E410E SCALE: 1/8" = 1'-0"

NO	DATE	BY	CHECK	DESIGN	REVISION / SUBMITTAL

AECOM *MP Consultants*
CONSULTING ENGINEERING
MINNEAPOLIS, MINNESOTA

60% SUBMISSION - 9/28/15



OPERATIONS & MAINTENANCE FACILITY - V2B
ELECTRICAL
SAFETY GROUNDING SYSTEM - LEVEL ONE -
AREA E

DISCIPLINE:

ELECTRICAL

SHEET NAME:

OMF-ELE-PLN


E410E

SHEET

223

OF

263

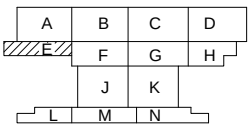


KEY PLAN - SCALE: N.T.S.



SCALE IN FEET

9/22/2015 10:12:06 AM C:\Users\jv-Beggs\Documents\OMF_ELEC_V-Beggs\B.rvt

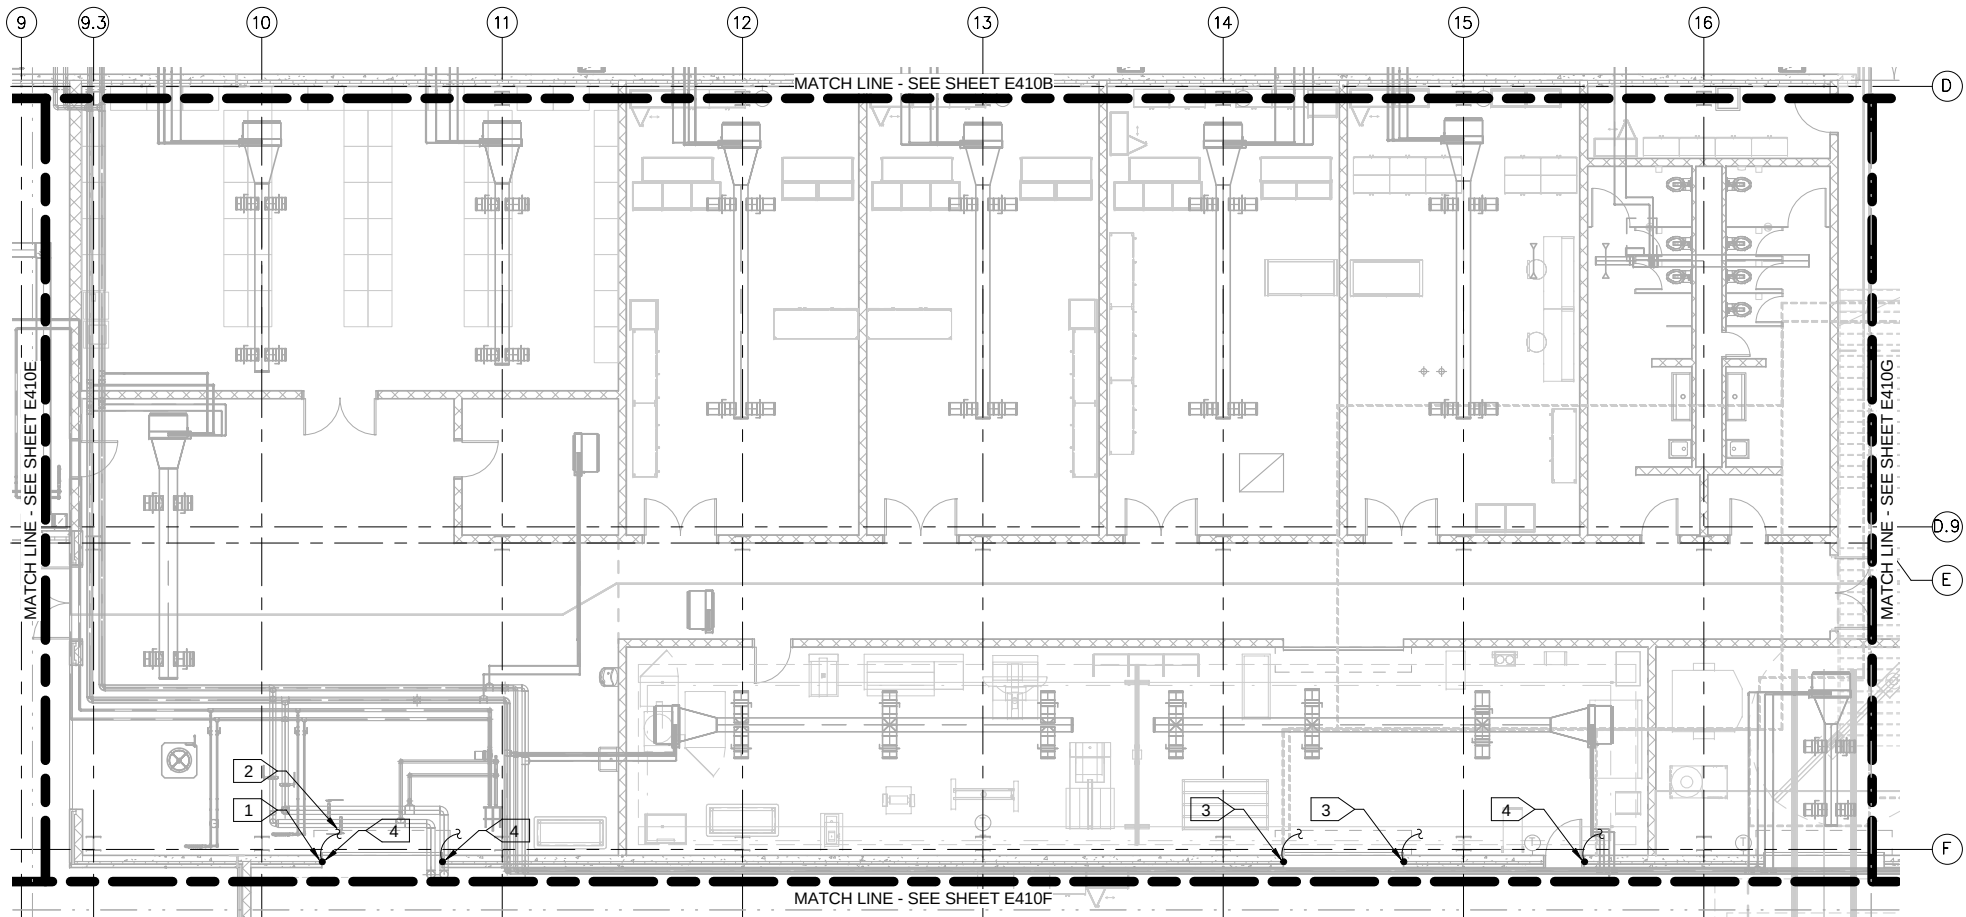

GENERAL NOTES:

1. ALL METALLIC ENCLOSURES, PANELS PANELBOARDS, CONTROLLERS, PIPING, FIN TUBE RADIATOR COVERS, DUCT WORK, DOOR FRAMES, DOOR SENSORS, RAILINGS, BOLLARDS, WINDOW FRAMES, MECHANICAL AND INDUSTRIAL EQUIPMENT IN AREA INDICATED UP TO 9'-0" ABOVE FINISHED FLOOR SHALL BE BONDED TO NEAREST IN-SLAB GROUNDING ELECTRODE CONDUCTORS (GEC).
2. GEC CONNECTIONS BETWEEN ABOVE MENTIONED ITEMS AND IN-SLAB GROUNDING ELECTRODE CONDUCTORS SHALL BE BARE #2/O CU.
3. SEE GEC CONNECTION DETAILS ON SHEETS XXX.
4. VERIFY LOCATIONS OF ALL ITEMS PRIOR TO ROUGHING IN.
5. ALL GEC'S SHALL BE BELOW GRADE UNTIL READY FOR CONNECTIONS TO METAL OBJECTS.
6. GEC STUB UPS IN CONCRETE SHALL BE IN POCKETS IN CONCRETE UNTIL READY FOR CONNECTION TO METAL OBJECTS. POCKET SHALL BE COVERED TO PROTECT GEC.
7. ALL GEC'S SHALL BE BURIED AT THE END OF THE WORKING DAY SO THAT NO GEC'S SHALL BE LEFT EXPOSED AND SUBJECT TO VANDALISM OR THEFT.

KEYNOTES:

1. GEC CONNECTION TO ITEM NOTED (TYP).
2. GEC CONNECTION TO IN-SLAB GEC (TYP).
3. OVERHEAD DOOR FRAME.
4. DOOR FRAME.

1 SAFETY GROUNDING SYSTEM - AREA F
E410F SCALE: 1/8" = 1'-0"

NO	DATE	BY	CHECK	DESIGN	REVISION / SUBMITTAL

AECOM *MP Consultants*
CONSULTING ENGINEERING
MINNEAPOLIS, MINNESOTA

60% SUBMISSION - 9/28/15




OPERATIONS & MAINTENANCE FACILITY - V2B
ELECTRICAL
SAFETY GROUNDING SYSTEM - LEVEL ONE - AREA F

DISCIPLINE: **ELECTRICAL** SHEET NAME: **OMF-ELE-PLN E410F**

SHEET
224
OF
263

9/22/2015 10:12:13 AM C:\Users\VBegaj\Documents\OMF_ELEC_V-BegajB.rvt

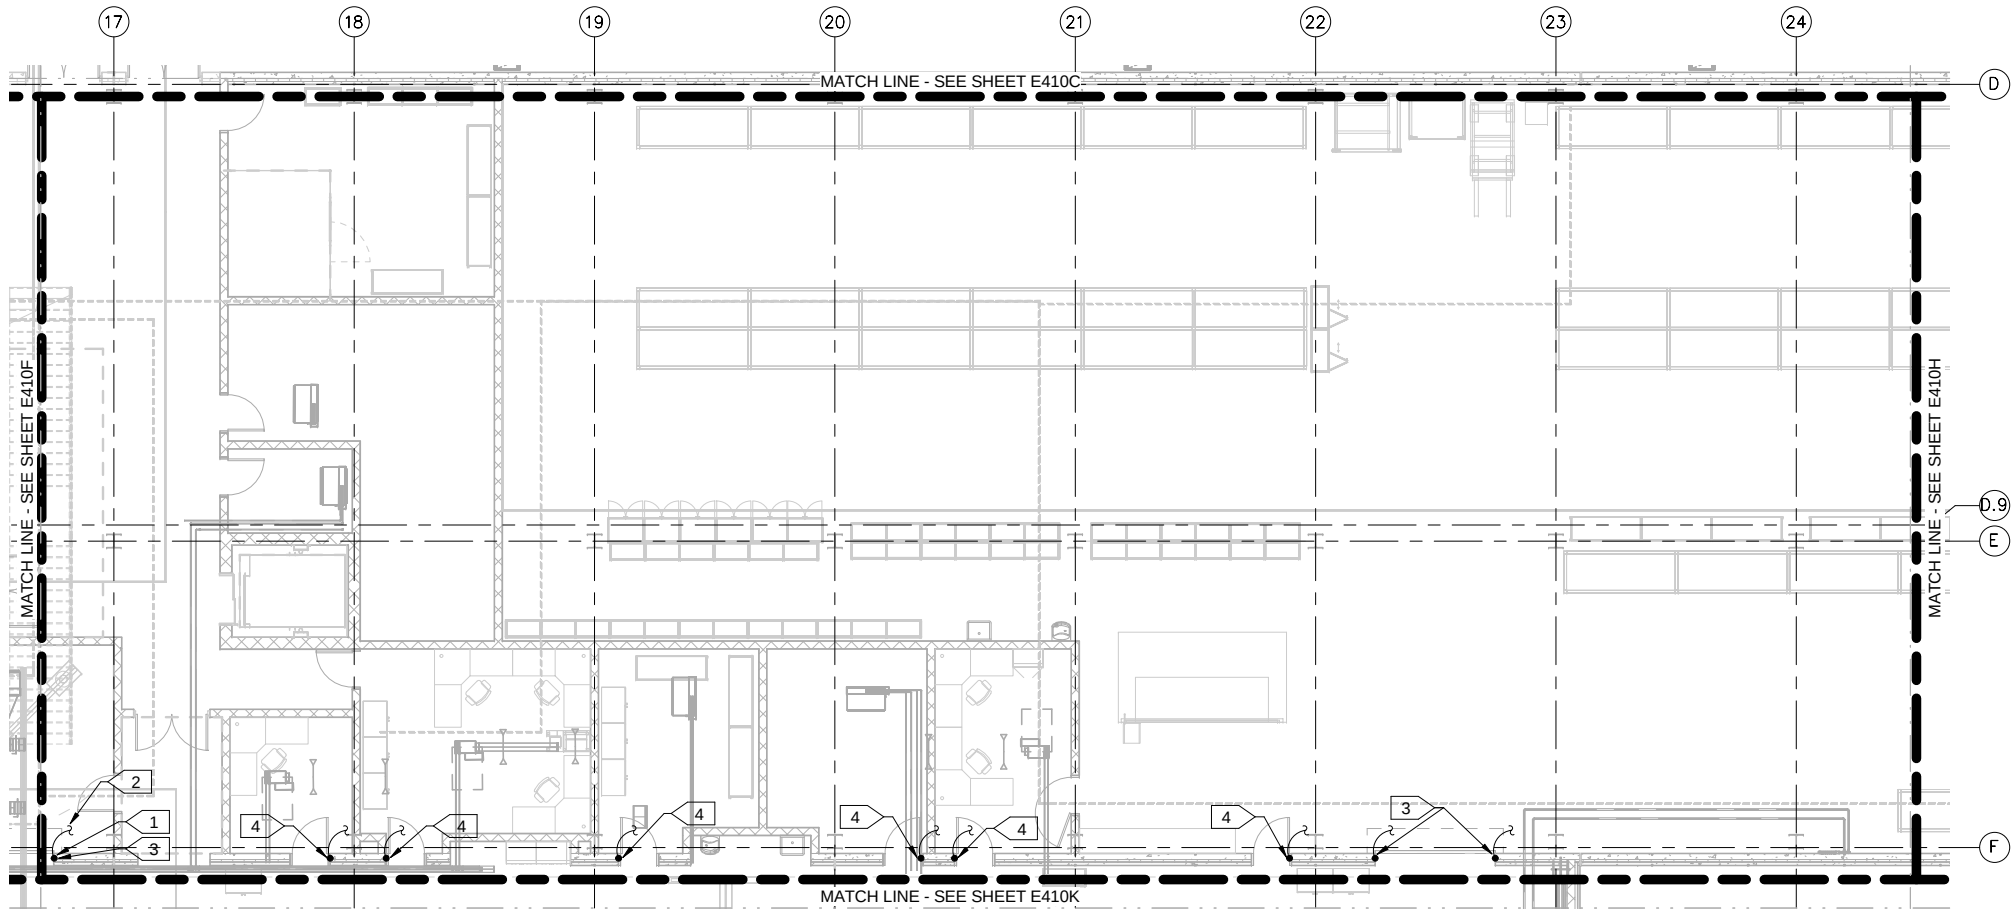

GENERAL NOTES:

1. ALL METALLIC ENCLOSURES, PANELS PANELBOARDS, CONTROLLERS, PIPING, FIN TUBE RADIATOR COVERS, DUCT WORK, DOOR FRAMES, DOOR SENSORS, RAILINGS, BOLLARDS, WINDOW FRAMES, MECHANICAL AND INDUSTRIAL EQUIPMENT IN AREA INDICATED UP TO 9'-0" ABOVE FINISHED FLOOR SHALL BE BONDED TO NEAREST IN-SLAB GROUNDING ELECTRODE CONDUCTORS (GEC).
2. GEC CONNECTIONS BETWEEN ABOVE MENTIONED ITEMS AND IN-SLAB GROUNDING ELECTRODE CONDUCTORS SHALL BE BARE #2/0 CU.
3. SEE GEC CONNECTION DETAILS ON SHEETS XXX.
4. VERIFY LOCATIONS OF ALL ITEMS PRIOR TO ROUGHING IN.
5. ALL GEC'S SHALL BE BELOW GRADE UNTIL READY FOR CONNECTIONS TO METAL OBJECTS.
6. GEC STUB UPS IN CONCRETE SHALL BE IN POCKETS IN CONCRETE UNTIL READY FOR CONNECTION TO METAL OBJECTS. POCKET SHALL BE COVERED TO PROTECT GEC.
7. ALL GEC'S SHALL BE BURIED AT THE END OF THE WORKING DAY SO THAT NO GEC'S SHALL BE LEFT EXPOSED AND SUBJECT TO VANDALISM OR THEFT.

KEYNOTES:



1. GEC CONNECTION TO ITEM NOTED (TYP).
2. GEC CONNECTION TO IN-SLAB GEC (TYP).
3. OVERHEAD DOOR FRAME.
4. DOOR FRAME.

1 SAFETY GROUNDING SYSTEM - AREA G
E410G SCALE: 1/8" = 1'-0"

NO	DATE	BY	CHECK	DESIGN	REVISION / SUBMITTAL




60% SUBMISSION - 9/28/15



OPERATIONS & MAINTENANCE FACILITY - V2B
ELECTRICAL
SAFETY GROUNDING SYSTEM - LEVEL ONE -
AREA G

DISCIPLINE:	SHEET NAME:	
ELECTRICAL	OMF-ELE-PLN	E410G

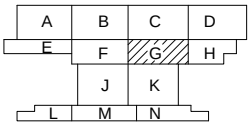

KEY PLAN - SCALE: N.T.S.



SCALE IN FEET

SHEET
225
OF
263


SHEET NOT USED FOR 60% SUBMISSION

KEY PLAN - SCALE: N.T.S.

SCALE IN FEET


[illegible]

9/22/2015 10:12:14 AM C:\Users\V-BegeJB\Documents\OMF_ELEC_V-BegeJB.rvt

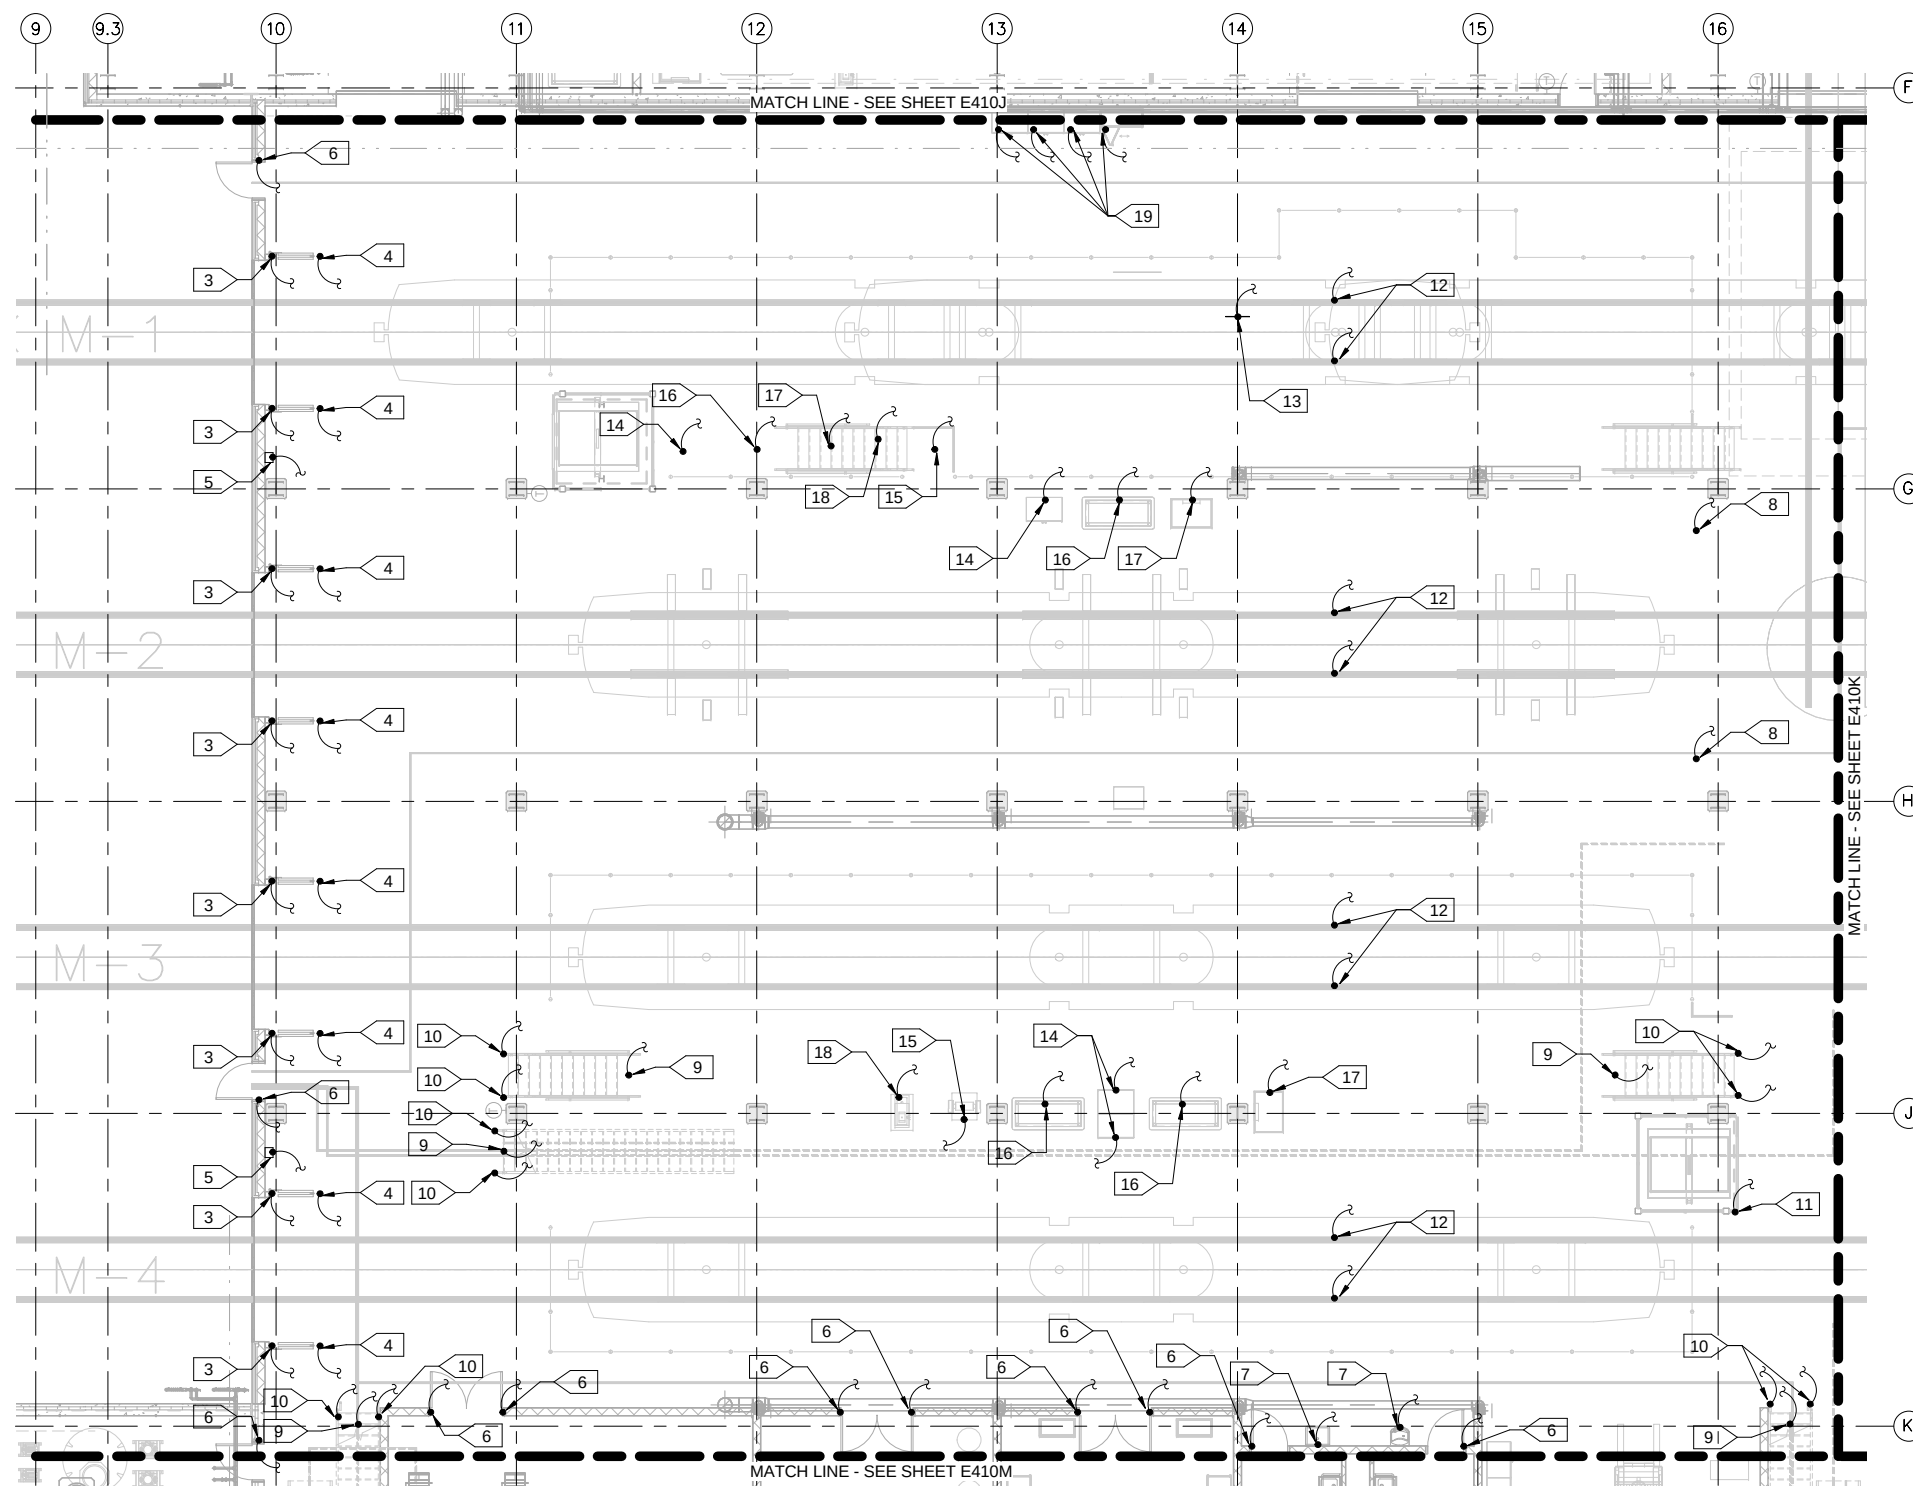

263

9/22/2015 10:12:28 AM C:\Users\jv-Beggs\Documents\OMF_ELEC_V-Beggs\B.rvt

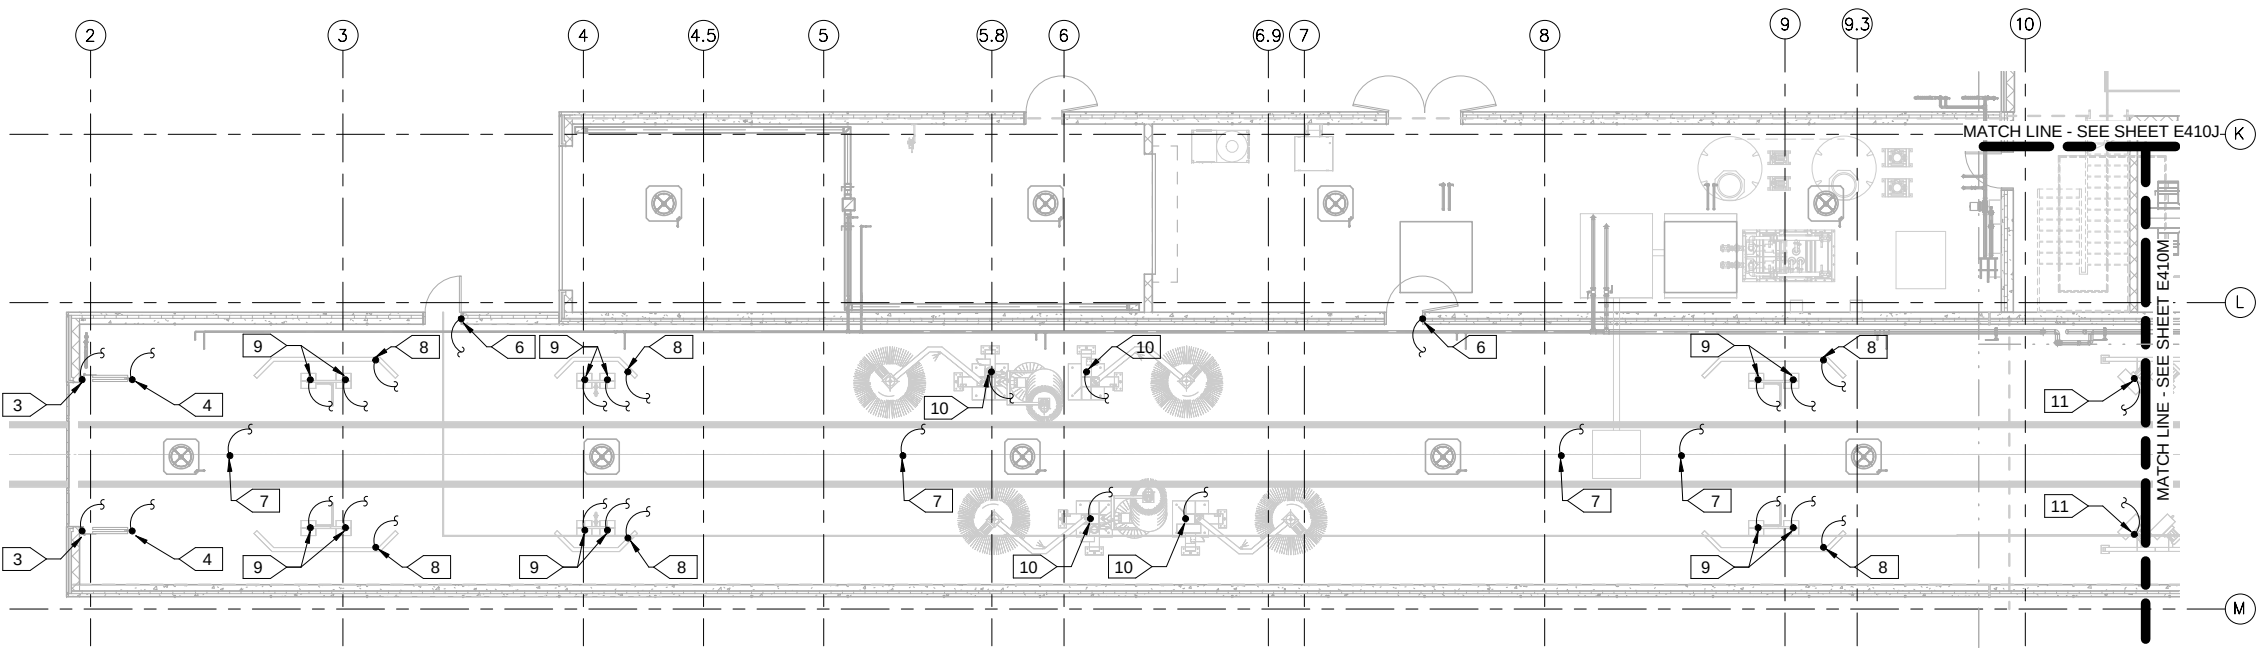

GENERAL NOTES:

1. ALL METALLIC ENCLOSURES, PANELS PANELBOARDS, CONTROLLERS, PIPING, FIN TUBE RADIATOR COVERS, DUCT WORK, DOOR FRAMES, DOOR SENSORS, RAILINGS, BOLLARDS, WINDOW FRAMES, MECHANICAL AND INDUSTRIAL EQUIPMENT IN AREA INDICATED UP TO 9'-0" ABOVE FINISHED FLOOR SHALL BE BONDED TO NEAREST IN-SLAB GROUNDING ELECTRODE CONDUCTORS (GEC).
2. GEC CONNECTIONS BETWEEN ABOVE MENTIONED ITEMS AND IN-SLAB GROUNDING ELECTRODE CONDUCTORS SHALL BE BARE #2/O CU.
3. SEE GEC CONNECTION DETAILS ON SHEETS XXX.
4. VERIFY LOCATIONS OF ALL ITEMS PRIOR TO ROUGHING IN.
5. ALL GEC'S SHALL BE BELOW GRADE UNTIL READY FOR CONNECTIONS TO METAL OBJECTS.
6. GEC STUB UPS IN CONCRETE SHALL BE IN POCKETS IN CONCRETE UNTIL READY FOR CONNECTION TO METAL OBJECTS. POCKET SHALL BE COVERED TO PROTECT GEC.
7. ALL GEC'S SHALL BE BURIED AT THE END OF THE WORKING DAY SO THAT NO GEC'S SHALL BE LEFT EXPOSED AND SUBJECT TO VANDALISM OR THEFT.

KEYNOTES:

1. GEC CONNECTION TO ITEM NOTED (TYP).
2. GEC CONNECTION TO IN-SLAB GEC (TYP).
3. BI-FOLD DOOR FRAME.
4. PHOTOCCELL SENSOR FOR BI-FOLD DOOR.
5. CONTROLLER(S) FOR BI-FOLD DOORS.
6. DOOR FRAME.
7. TRENCH DRAIN COVER.
8. CAR WASH WATER SHIELD.
9. CAR WASH BRUSHES.
10. CAR WASH DRYERS.

1 SAFETY GROUNDING SYSTEM - AREA L
E410L SCALE: 1/8" = 1'-0"

NO	DATE	BY	CHECK	DESIGN	REVISION / SUBMITTAL

AECOM *MP Consultants*
CONSULTING ENGINEERING
MINNEAPOLIS, MINNESOTA


60% SUBMISSION - 9/28/15




OPERATIONS & MAINTENANCE FACILITY - V2B
ELECTRICAL
SAFETY GROUNDING SYSTEM - LEVEL ONE - AREA L

DISCIPLINE: **ELECTRICAL** SHEET NAME: **OMF-ELE-PLN E410L**

SHEET
229
OF
263

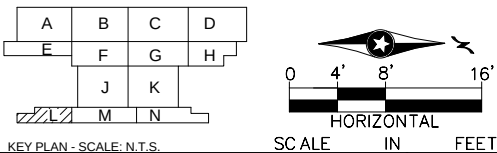

9/22/2015 10:12:32 AM C:\Users\jv-Beggs\Documents\OMF_ELEC_V-Beggs\B.rvt

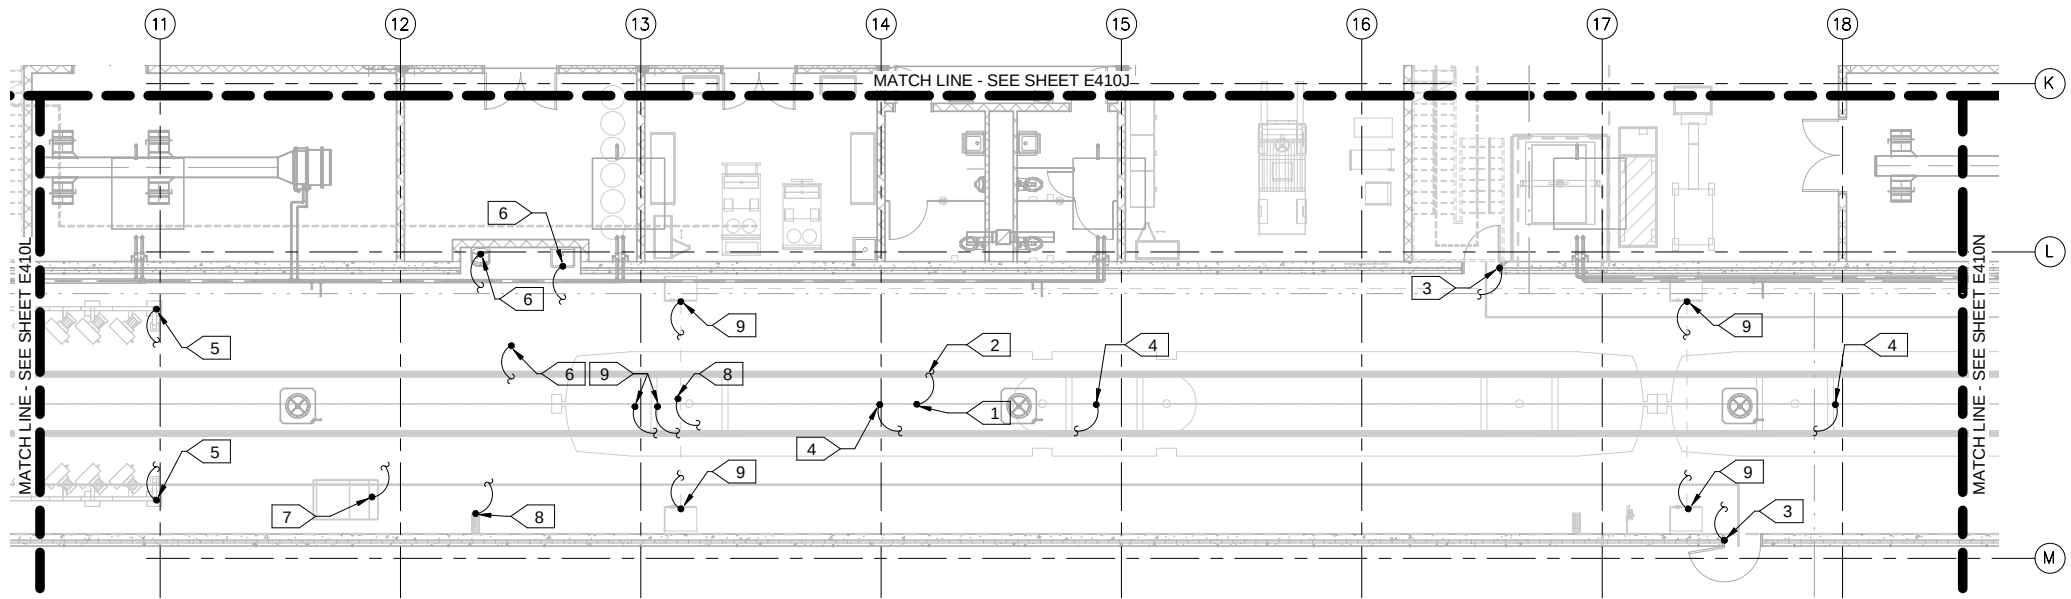

- GENERAL NOTES:**
1. ALL METALLIC ENCLOSURES, PANELS PANELBOARDS, CONTROLLERS, PIPING, FIN TUBE RADIATOR COVERS, DUCT WORK, DOOR FRAMES, DOOR SENSORS, RAILINGS, BOLLARDS, WINDOW FRAMES, MECHANICAL AND INDUSTRIAL EQUIPMENT IN AREA INDICATED UP TO 9'-0" ABOVE FINISHED FLOOR SHALL BE BONDED TO NEAREST IN-SLAB GROUNDING ELECTRODE CONDUCTORS (GEC).
 2. GEC CONNECTIONS BETWEEN ABOVE MENTIONED ITEMS AND IN-SLAB GROUNDING ELECTRODE CONDUCTORS SHALL BE BARE #2/0 CU.
 3. SEE GEC CONNECTION DETAILS ON SHEETS XXX.
 4. VERIFY LOCATIONS OF ALL ITEMS PRIOR TO ROUGHING IN.
 5. ALL GEC'S SHALL BE BELOW GRADE UNTIL READY FOR CONNECTIONS TO METAL OBJECTS.
 6. GEC STUB UPS IN CONCRETE SHALL BE IN POCKETS IN CONCRETE UNTIL READY FOR CONNECTION TO METAL OBJECTS. POCKET SHALL BE COVERED TO PROTECT GEC.
 7. ALL GEC'S SHALL BE BURIED AT THE END OF THE WORKING DAY SO THAT NO GEC'S SHALL BE LEFT EXPOSED AND SUBJECT TO VANDALISM OR THEFT.

- KEYNOTES:**
- 1. GEC CONNECTION TO ITEM NOTED (TYP).
 - 2. GEC CONNECTION TO IN-SLAB GEC (TYP).
 - 3. BI-FOLD DOOR FRAME.
 - 4. TRENCH DRAIN COVER.
 - 5. CAR WASH DRYERS.
 - 6. COPPER PIPING.
 - 7. HOPPER.
 - 8. REEL.
 - 9. SAND DISPENSER.

1
E410M SAFETY GROUNDING SYSTEM - AREA M
SCALE: 1/8" = 1'-0"

NO	DATE	BY	CHECK	DESIGN	REVISION / SUBMITTAL

AECOM

MP Consultants
CONSULTING ENGINEERING
MINNEAPOLIS, MINNESOTA

60% SUBMISSION - 9/28/15

**METROPOLITAN COUNCIL**

**SOUTHWEST**


OPERATIONS & MAINTENANCE FACILITY - V2B
ELECTRICAL
SAFETY GROUNDING SYSTEM - LEVEL ONE - AREA M

DISCIPLINE: **ELECTRICAL**


SHEET NAME: **OMF-ELE-PLN**

E410M

SHEET
230
OF
263

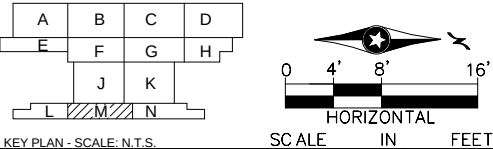

9/22/2015 10:12:36 AM C:\Users\jv-Begaj\Documents\OMF_ELEC_V-Begaj\B.rvt

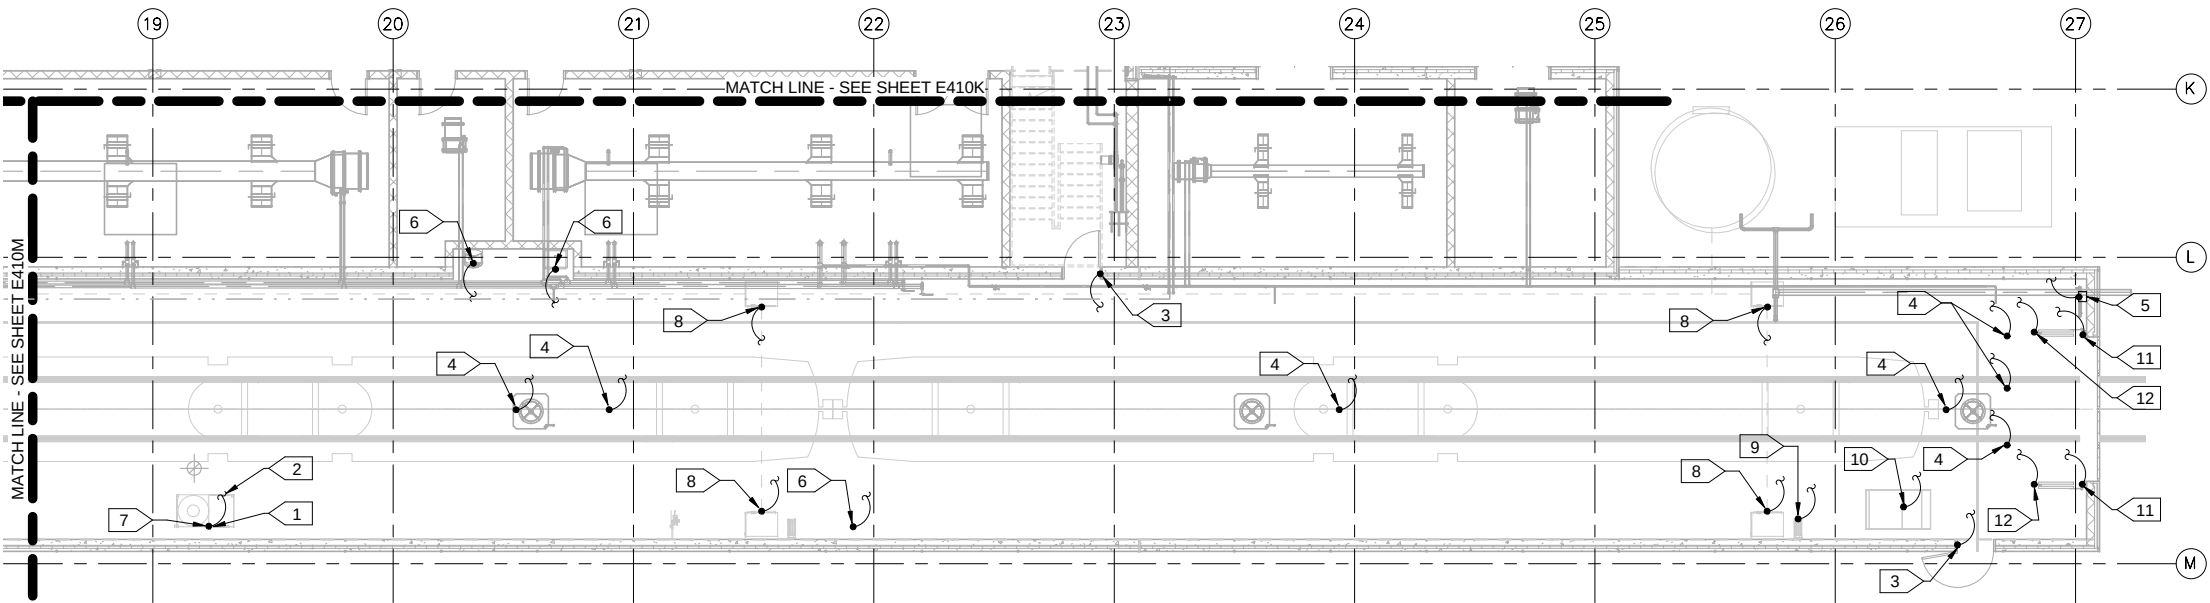

- GENERAL NOTES:**
1. ALL METALLIC ENCLOSURES, PANELS PANELBOARDS, CONTROLLERS, PIPING, FIN TUBE RADIATOR COVERS, DUCT WORK, DOOR FRAMES, DOOR SENSORS, RAILINGS, BOLLARDS, WINDOW FRAMES, MECHANICAL AND INDUSTRIAL EQUIPMENT IN AREA INDICATED UP TO 9'-0" ABOVE FINISHED FLOOR SHALL BE BONDED TO NEAREST IN-SLAB GROUNDING ELECTRODE CONDUCTORS (GEC).
 2. GEC CONNECTIONS BETWEEN ABOVE MENTIONED ITEMS AND IN-SLAB GROUNDING ELECTRODE CONDUCTORS SHALL BE BARE #2/O CU.
 3. SEE GEC CONNECTION DETAILS ON SHEETS XXX.
 4. VERIFY LOCATIONS OF ALL ITEMS PRIOR TO ROUGHING IN.
 5. ALL GEC'S SHALL BE BELOW GRADE UNTIL READY FOR CONNECTIONS TO METAL OBJECTS.
 6. GEC STUB UPS IN CONCRETE SHALL BE IN POCKETS IN CONCRETE UNTIL READY FOR CONNECTION TO METAL OBJECTS. POCKET SHALL BE COVERED TO PROTECT GEC.
 7. ALL GEC'S SHALL BE BURIED AT THE END OF THE WORKING DAY SO THAT NO GEC'S SHALL BE LEFT EXPOSED AND SUBJECT TO VANDALISM OR THEFT.

- KEYNOTES:**
1. GEC CONNECTION TO ITEM NOTED (TYP).
 2. GEC CONNECTION TO IN-SLAB GEC (TYP).
 3. BI-FOLD DOOR FRAME.
 4. TRENCH DRAIN COVER.
 5. BI-FOLD DOOR CONTROLLER.
 6. COPPER PIPING.
 7. PRESSURE WASHER.
 8. SAND DISPENSER.
 9. REEL.
 10. HOPPER.
 11. BI-FOLD CAR WASH BRUSHES.
 12. BI-FOLD DOOR PHOTOCELL.

1 SAFETY GROUNDING SYSTEM - AREA N
E410N/ SCALE: 1/8" = 1'-0"

NO	DATE	BY	CHECK	DESIGN	REVISION / SUBMITTAL




60% SUBMISSION - 9/28/15




OPERATIONS & MAINTENANCE FACILITY - V2B
ELECTRICAL
SAFETY GROUNDING SYSTEM - LEVEL ONE - AREA N

DISCIPLINE:	SHEET NAME:	
ELECTRICAL	OMF-ELE-PLN	E410N

SHEET
231
OF
263

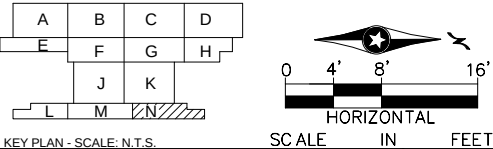

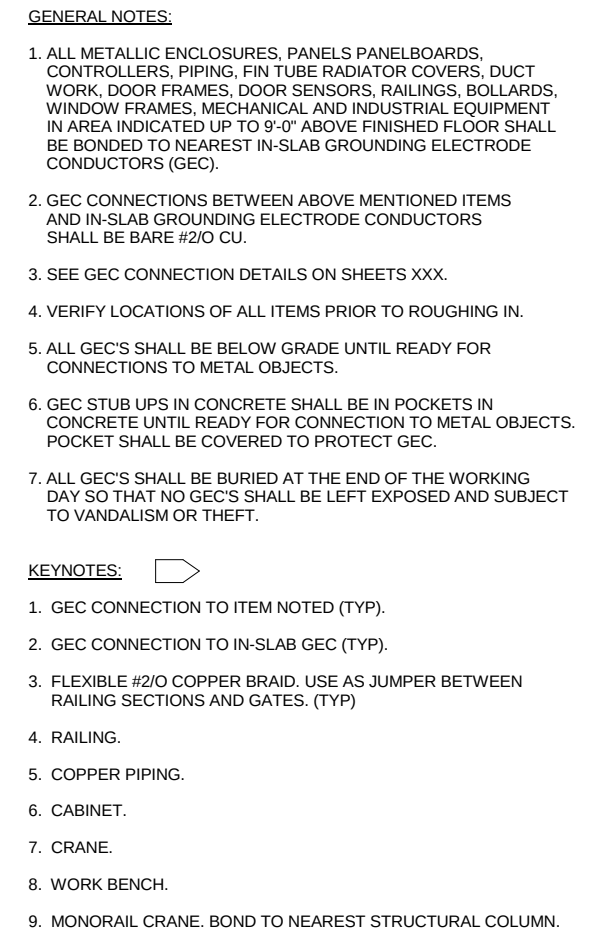

AECOM *MP CONSULTANTS*
CONSULTING ENGINEERING
MINNEAPOLIS • MINNESOTA




METROPOLITAN COUNCIL

SOUTHWEST

OPERATIONS & MAINTENANCE FACILITY - V2B
ELECTRICAL
SAFETY GROUNDING SYSTEM - MEZZANINE
LEVEL - AREA J


DISCIPLINE:	SHEET NAME:	
ELECTRICAL	OMF-ELE-PLN	E415J

9/22/2015 10:12:44 AM C:\Users\jv-Beggs\Documents\OMF_ELEC_V-Beggs\B.rvt

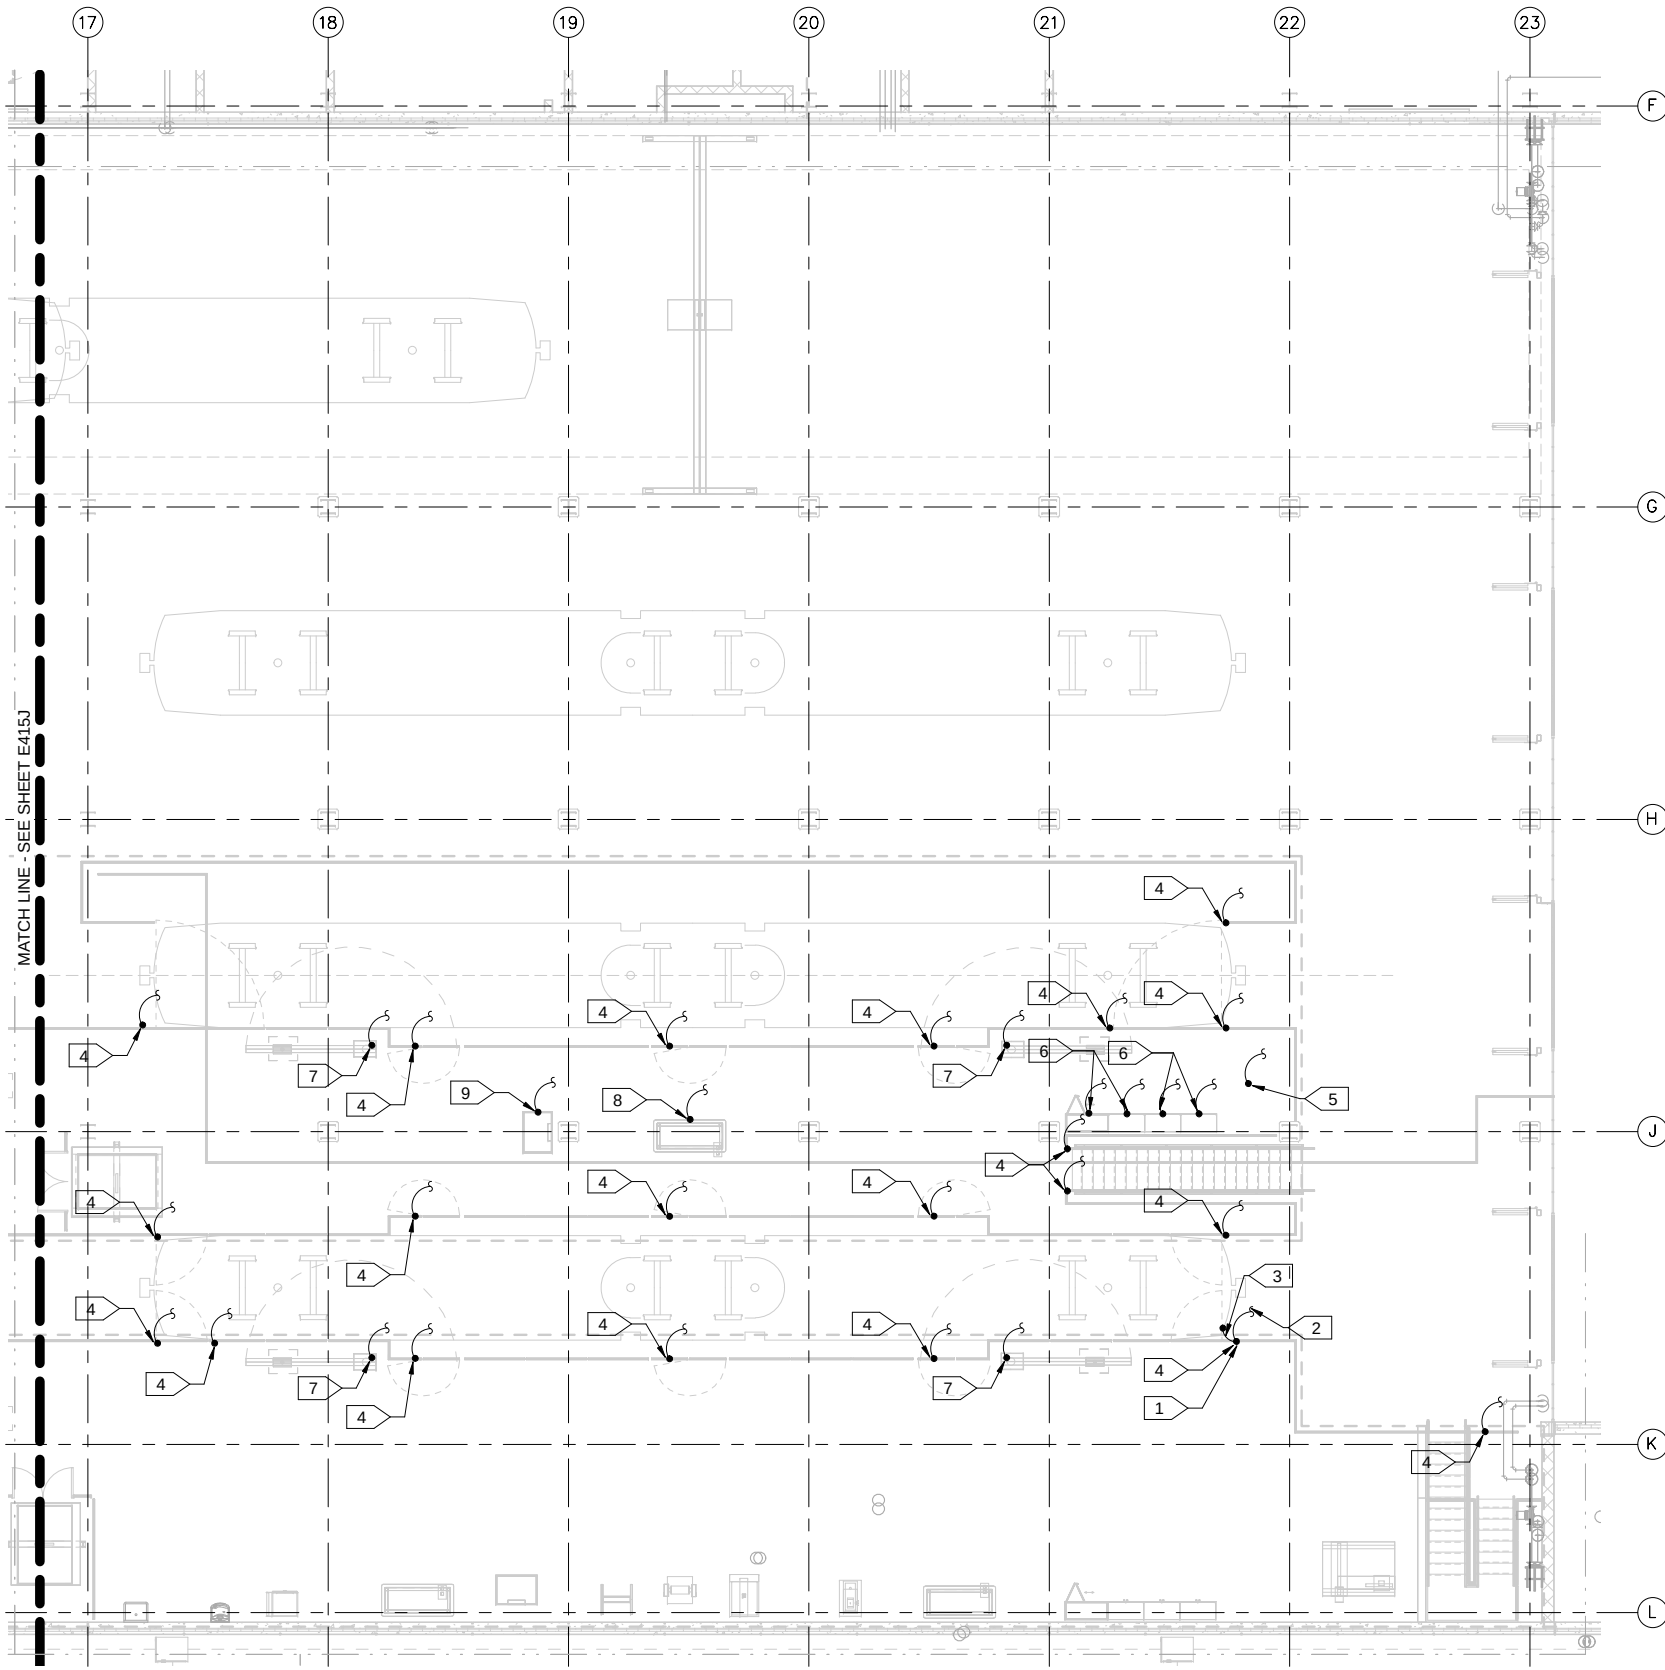

- GENERAL NOTES:**
1. ALL METALLIC ENCLOSURES, PANELS PANELBOARDS, CONTROLLERS, PIPING, FIN TUBE RADIATOR COVERS, DUCT WORK, DOOR FRAMES, DOOR SENSORS, RAILINGS, BOLLARDS, WINDOW FRAMES, MECHANICAL AND INDUSTRIAL EQUIPMENT IN AREA INDICATED UP TO 9'-0" ABOVE FINISHED FLOOR SHALL BE BONDED TO NEAREST IN-SLAB GROUNDING ELECTRODE CONDUCTORS (GEC).
 2. GEC CONNECTIONS BETWEEN ABOVE MENTIONED ITEMS AND IN-SLAB GROUNDING ELECTRODE CONDUCTORS SHALL BE BARE #2/O CU.
 3. SEE GEC CONNECTION DETAILS ON SHEETS XXX.
 4. VERIFY LOCATIONS OF ALL ITEMS PRIOR TO ROUGHING IN.
 5. ALL GEC'S SHALL BE BELOW GRADE UNTIL READY FOR CONNECTIONS TO METAL OBJECTS.
 6. GEC STUB UPS IN CONCRETE SHALL BE IN POCKETS IN CONCRETE UNTIL READY FOR CONNECTION TO METAL OBJECTS. POCKET SHALL BE COVERED TO PROTECT GEC.
 7. ALL GEC'S SHALL BE BURIED AT THE END OF THE WORKING DAY SO THAT NO GEC'S SHALL BE LEFT EXPOSED AND SUBJECT TO VANDALISM OR THEFT.

- KEYNOTES:**
1. GEC CONNECTION TO ITEM NOTED (TYP).
 2. GEC CONNECTION TO IN-SLAB GEC (TYP).
 3. FLEXIBLE #2/O COPPER BRAID. USE AS JUMPER BETWEEN RAILING SECTIONS AND GATES. (TYP)
 4. RAILING.
 5. COPPER PIPING.
 6. CABINET.
 7. CRANE.
 8. WORK BENCH.
 9. PARTS WASHER.

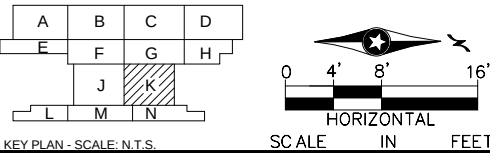

1 SAFETY GROUNDING SYSTEM - AREA K
E415K SCALE: 1/8" = 1'-0"

NO	DATE	BY	CHECK	DESIGN	REVISION / SUBMITTAL

AECOM
CONSULTING ENGINEERING
MINNEAPOLIS, MINNESOTA

MP Consultants
CONSULTING ENGINEERING
MINNEAPOLIS, MINNESOTA

60% SUBMISSION - 9/28/15

METROPOLITAN
COUNCIL

SOUTHWEST


OPERATIONS & MAINTENANCE FACILITY - V2B
ELECTRICAL
SAFETY GROUNDING SYSTEM - MEZZANINE
LEVEL - AREA K

DISCIPLINE:
ELECTRICAL

SHEET NAME:
OMF-ELE-PLN


E415K

SHEET
233
OF
263

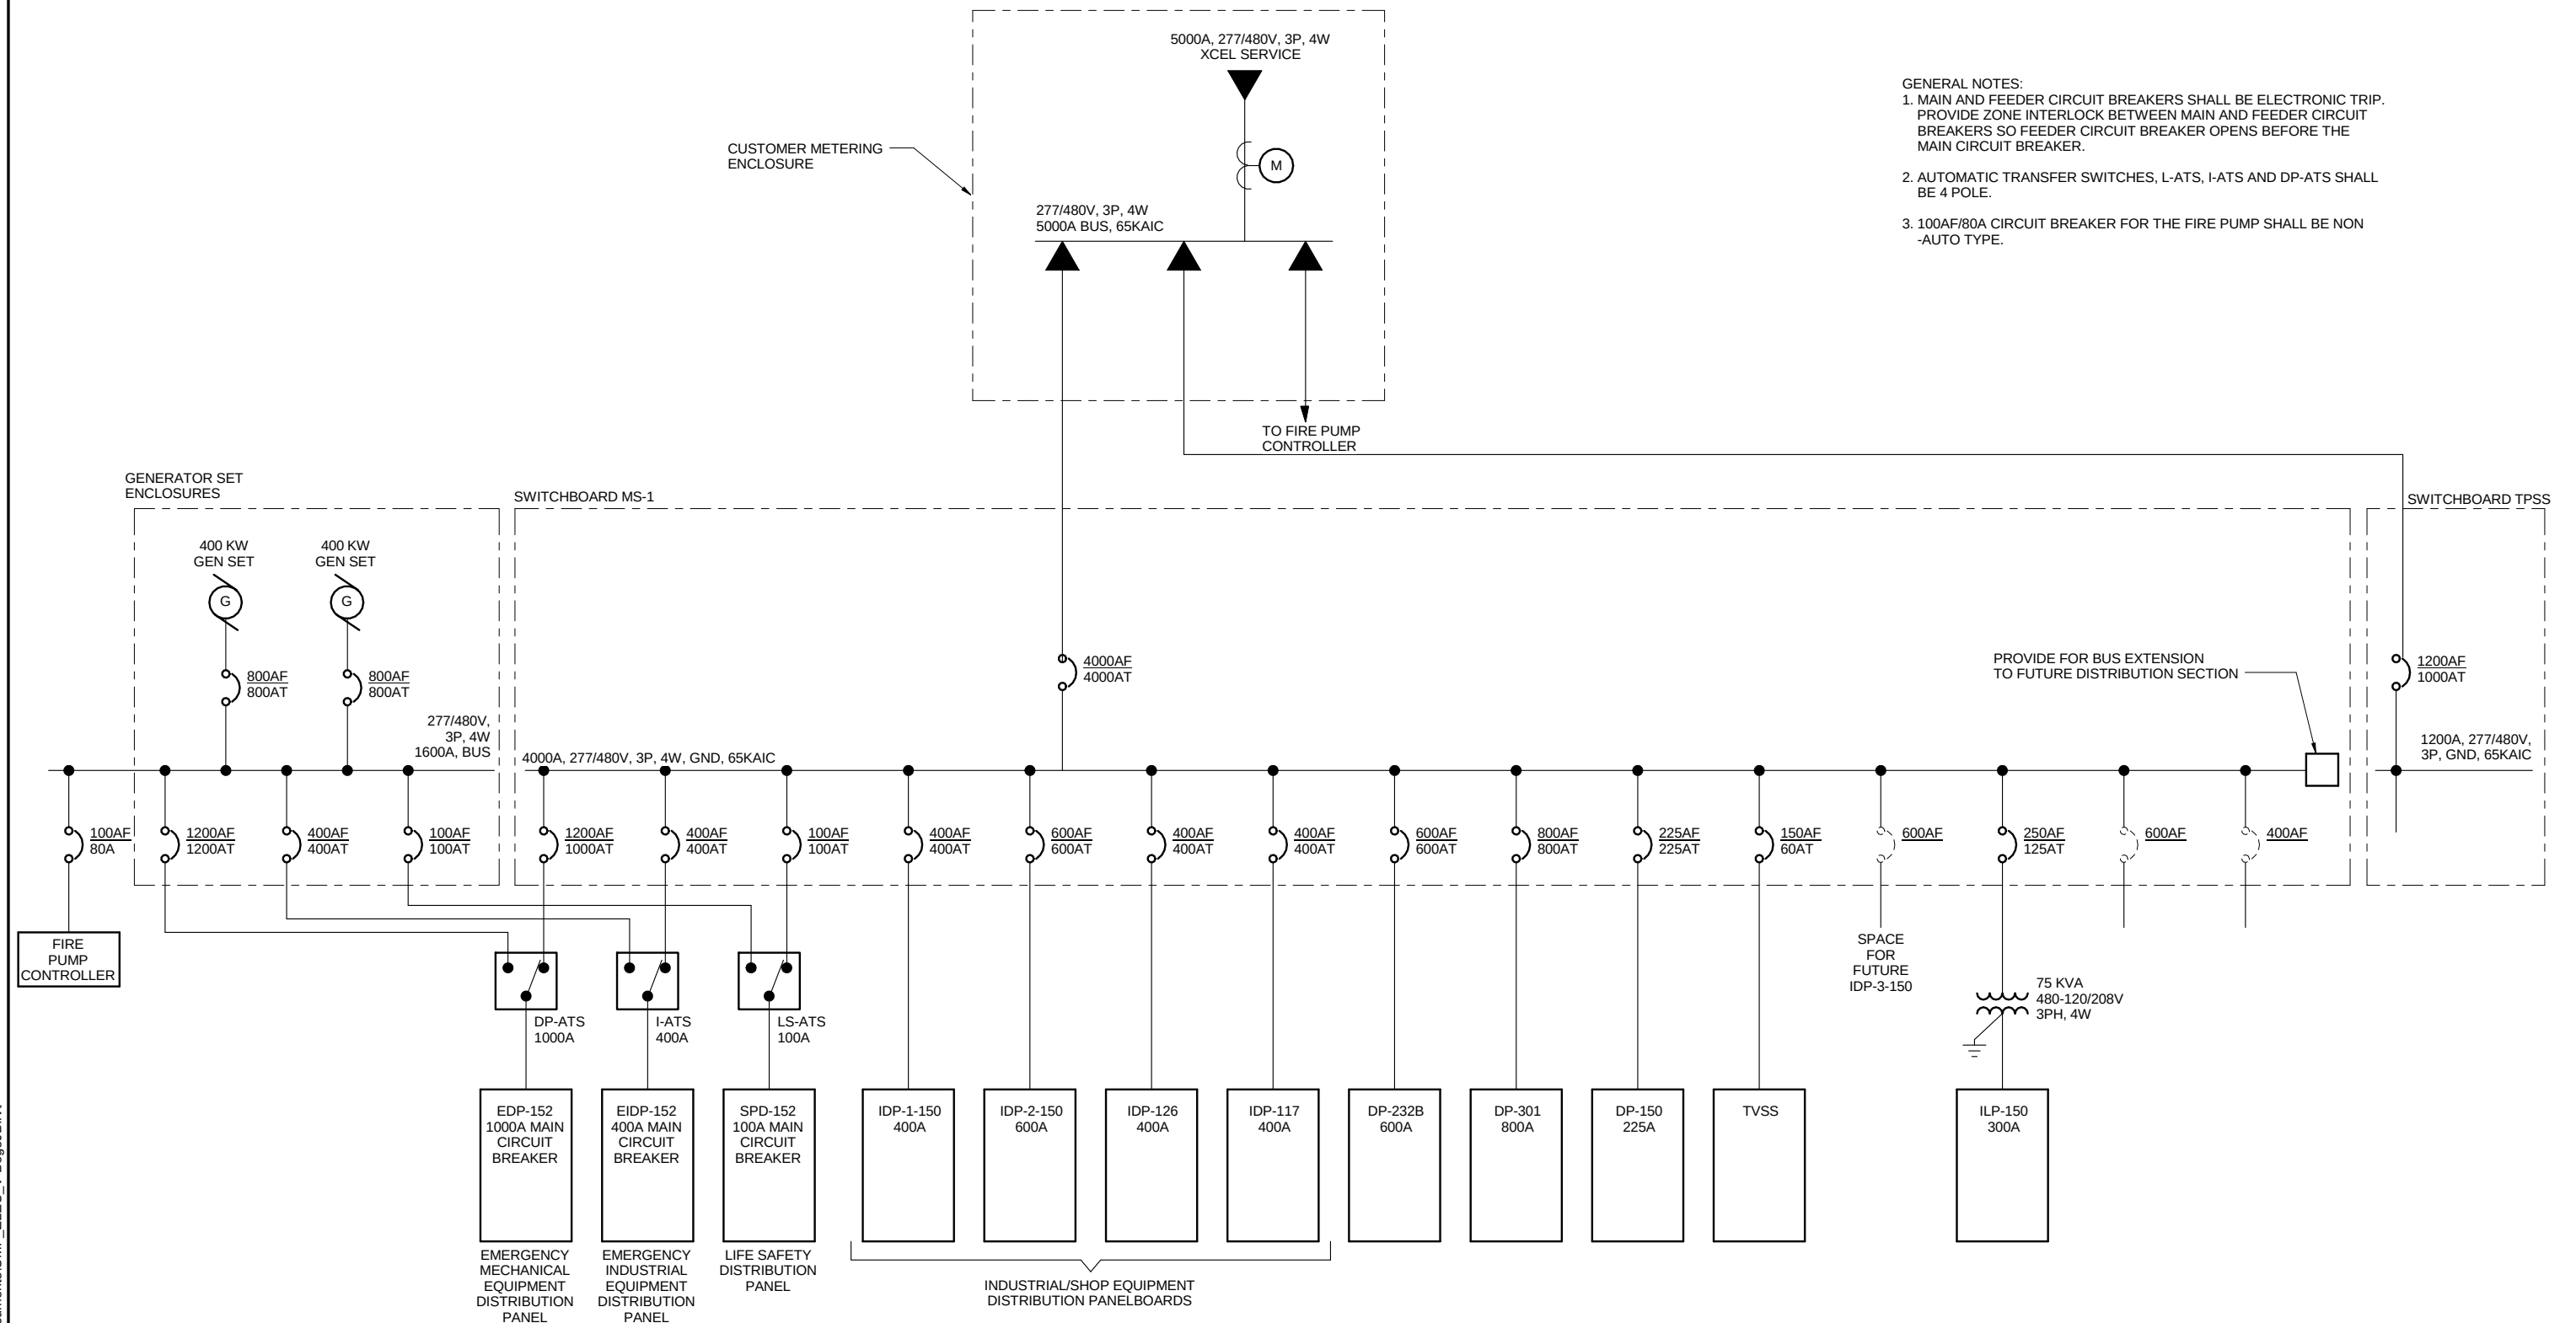

1 E-501 ONE LINE DIAGRAM
E501 SCALE: 1" = 1'-0"

9/22/2015 10:12:46 AM C:\Users\jv-Bega\B\Documents\OMF_ELEC_V-Bega\JB.rvt

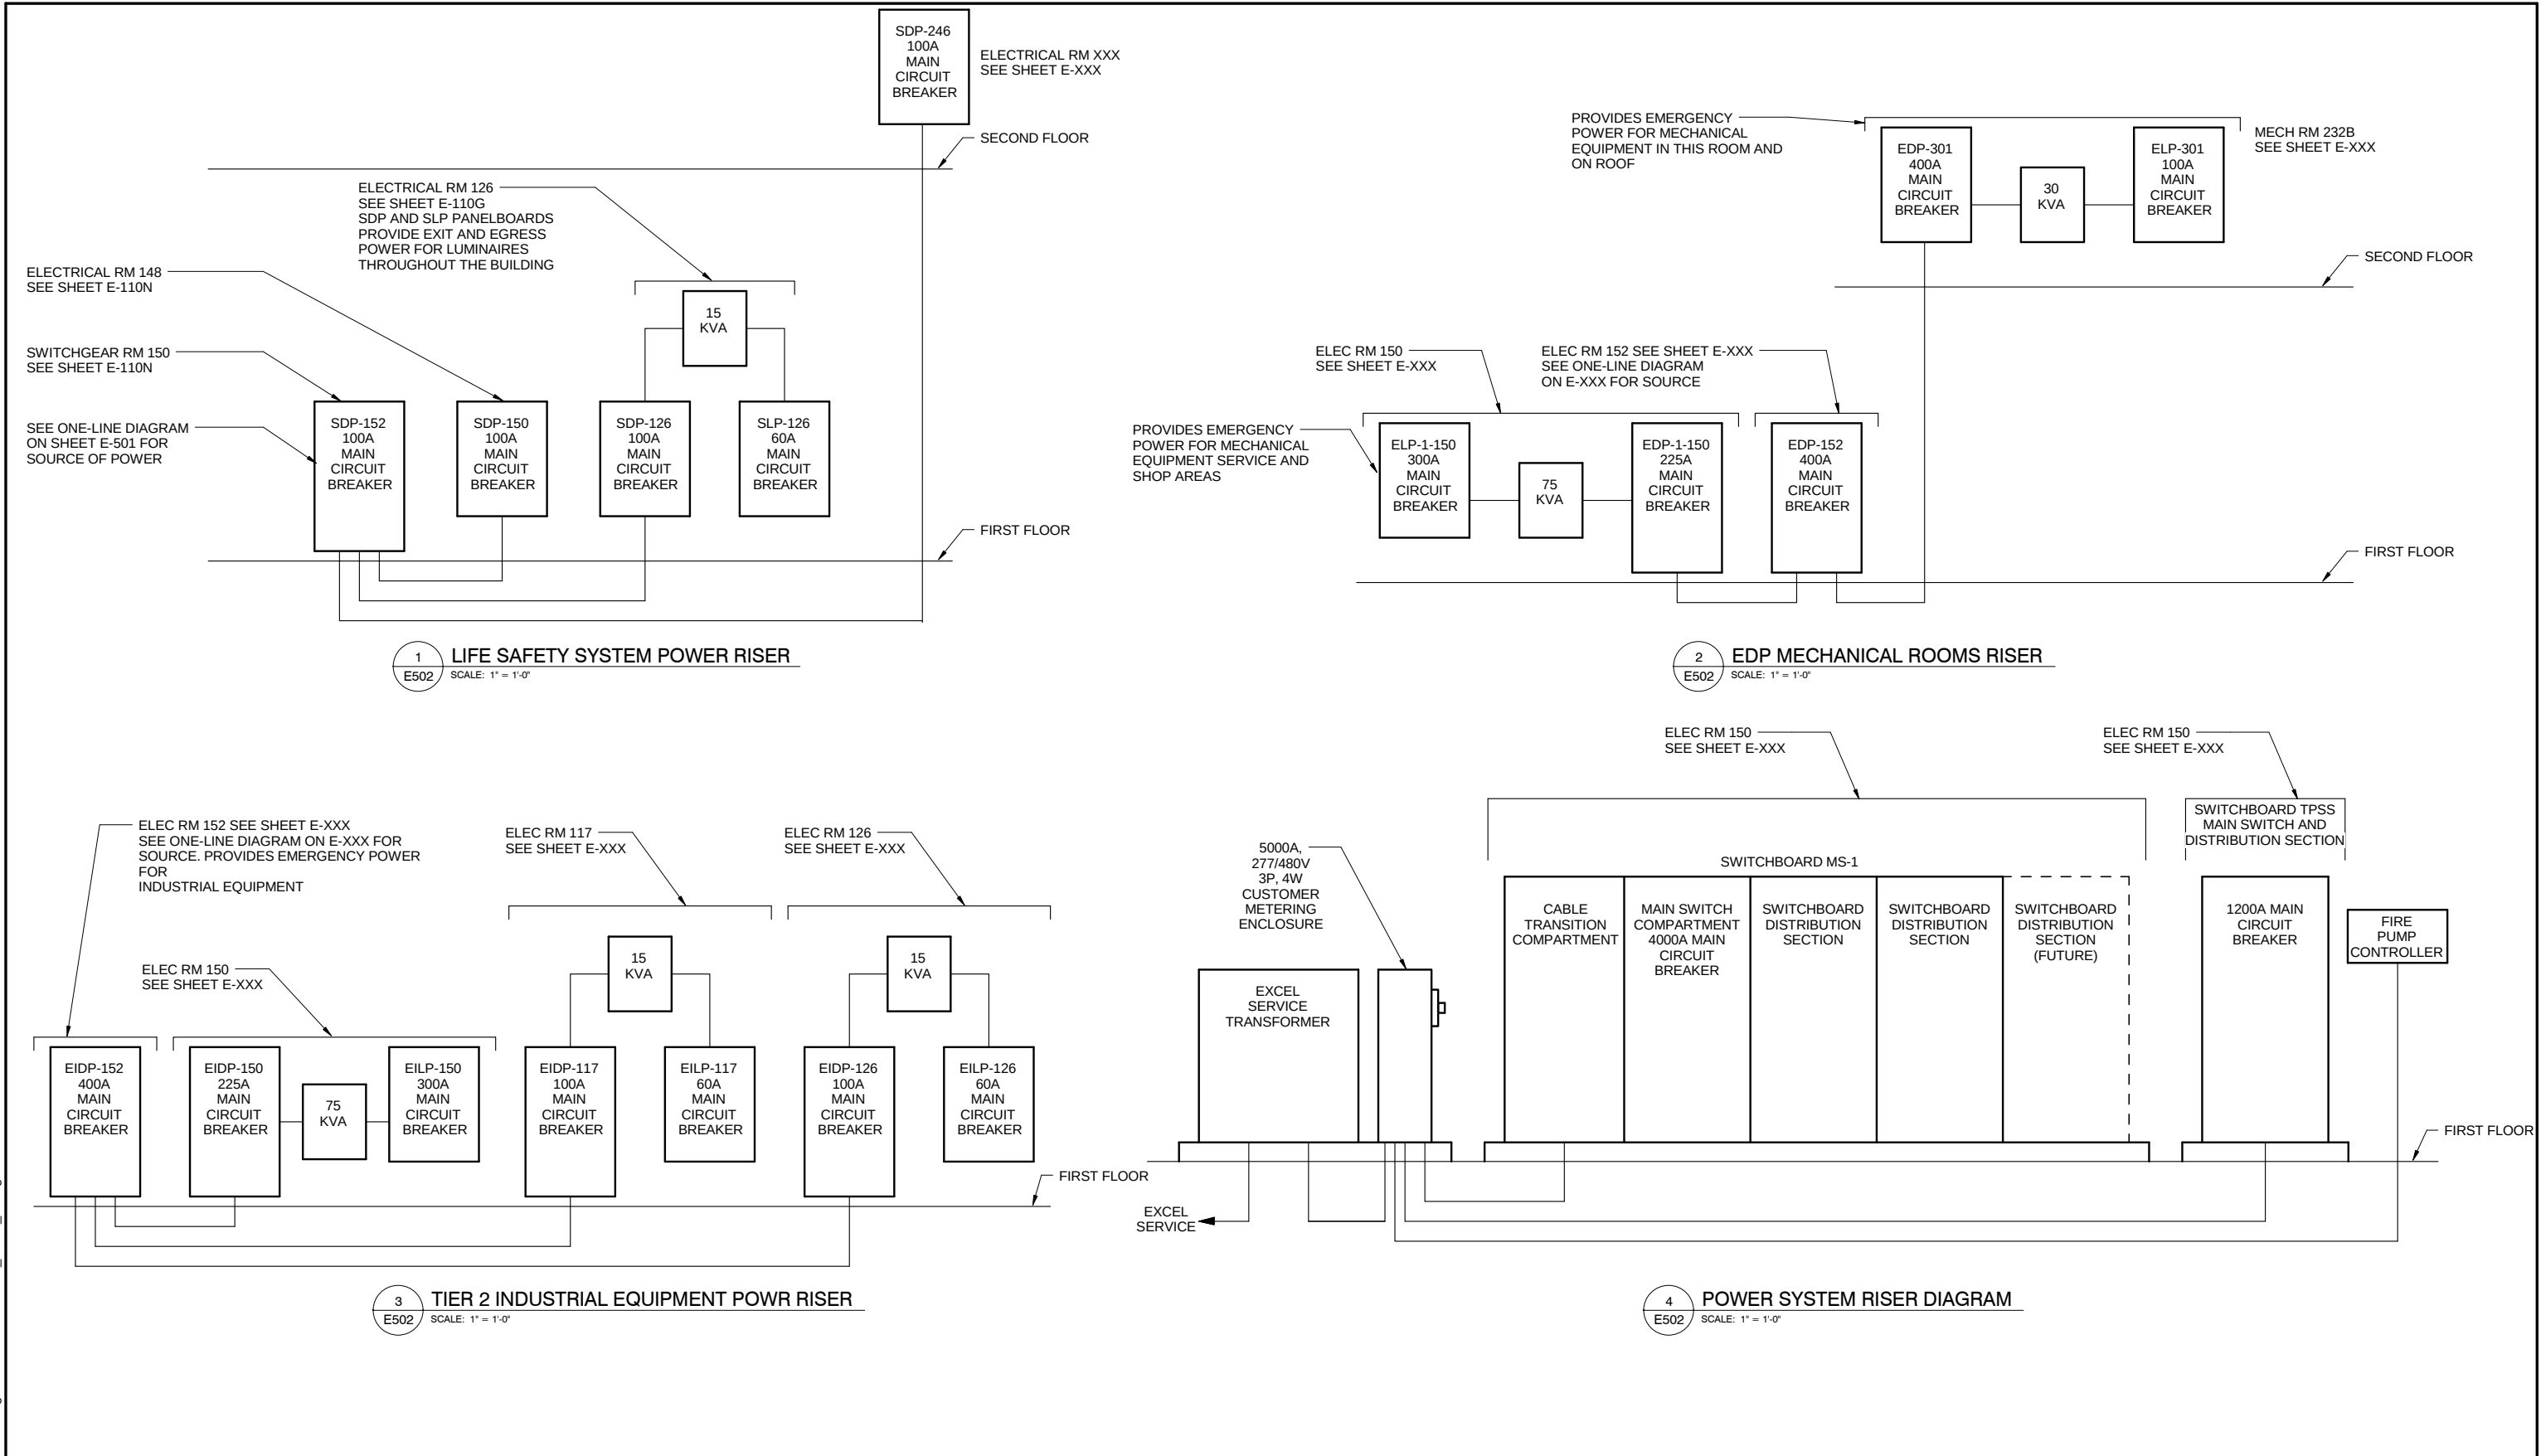

NO	DATE	BY	CHECK	DESIGN	REVISION / SUBMITTAL

AECOM

MP Consultants
CONSULTING ENGINEERING
MINNEAPOLIS, MINNESOTA

METROPOLITAN COUNCIL

SOUTHWEST

60% SUBMISSION - 9/28/15

OPERATIONS & MAINTENANCE FACILITY - V2B

ELECTRICAL

POWER ONE-LINE DIAGRAMS

DISCIPLINE:
ELECTRICAL

SHEET NAME:
OMF-ELE-RSD

E502


SHEET

235


OF

263

9/22/2015 10:12:49 AM C:\Users\V-Bege\B\Documents\OMF_ELEC_V-Bege\B.rvt

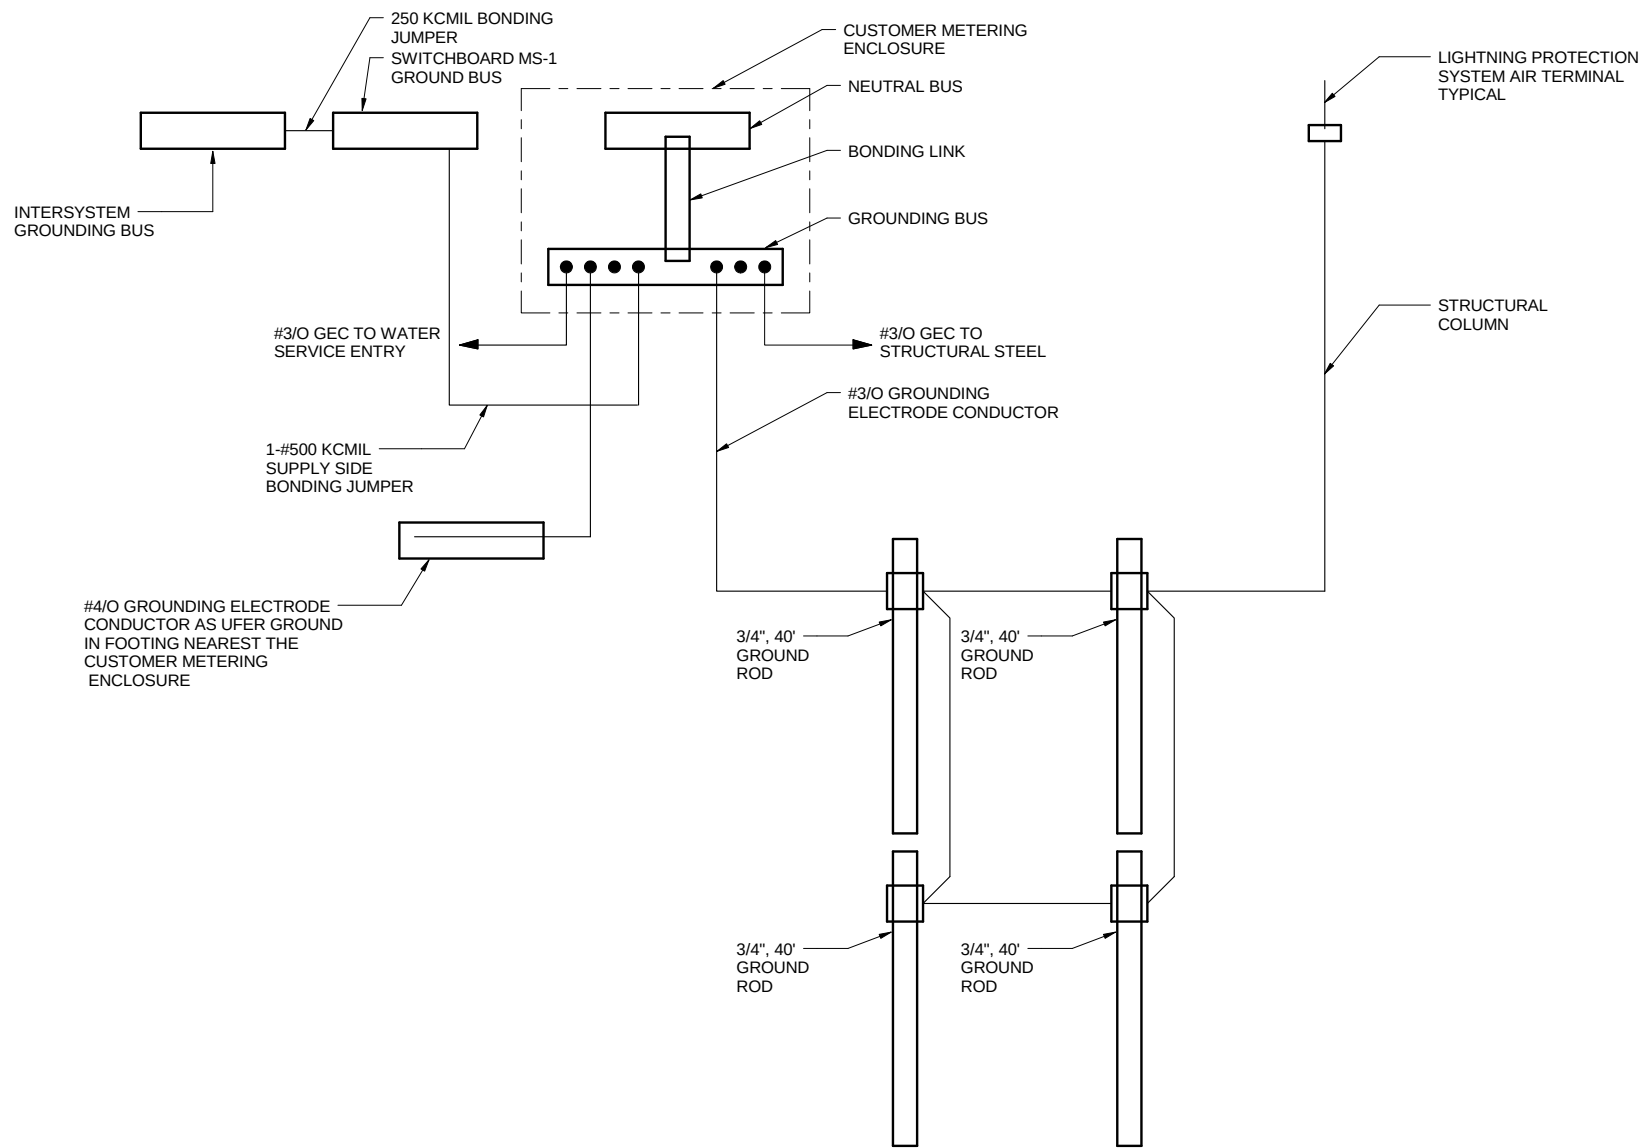

1
E504
GROUNDING ELECTRODE SYSTEM ONE-LINE
SCALE: 1" = 1'-0"

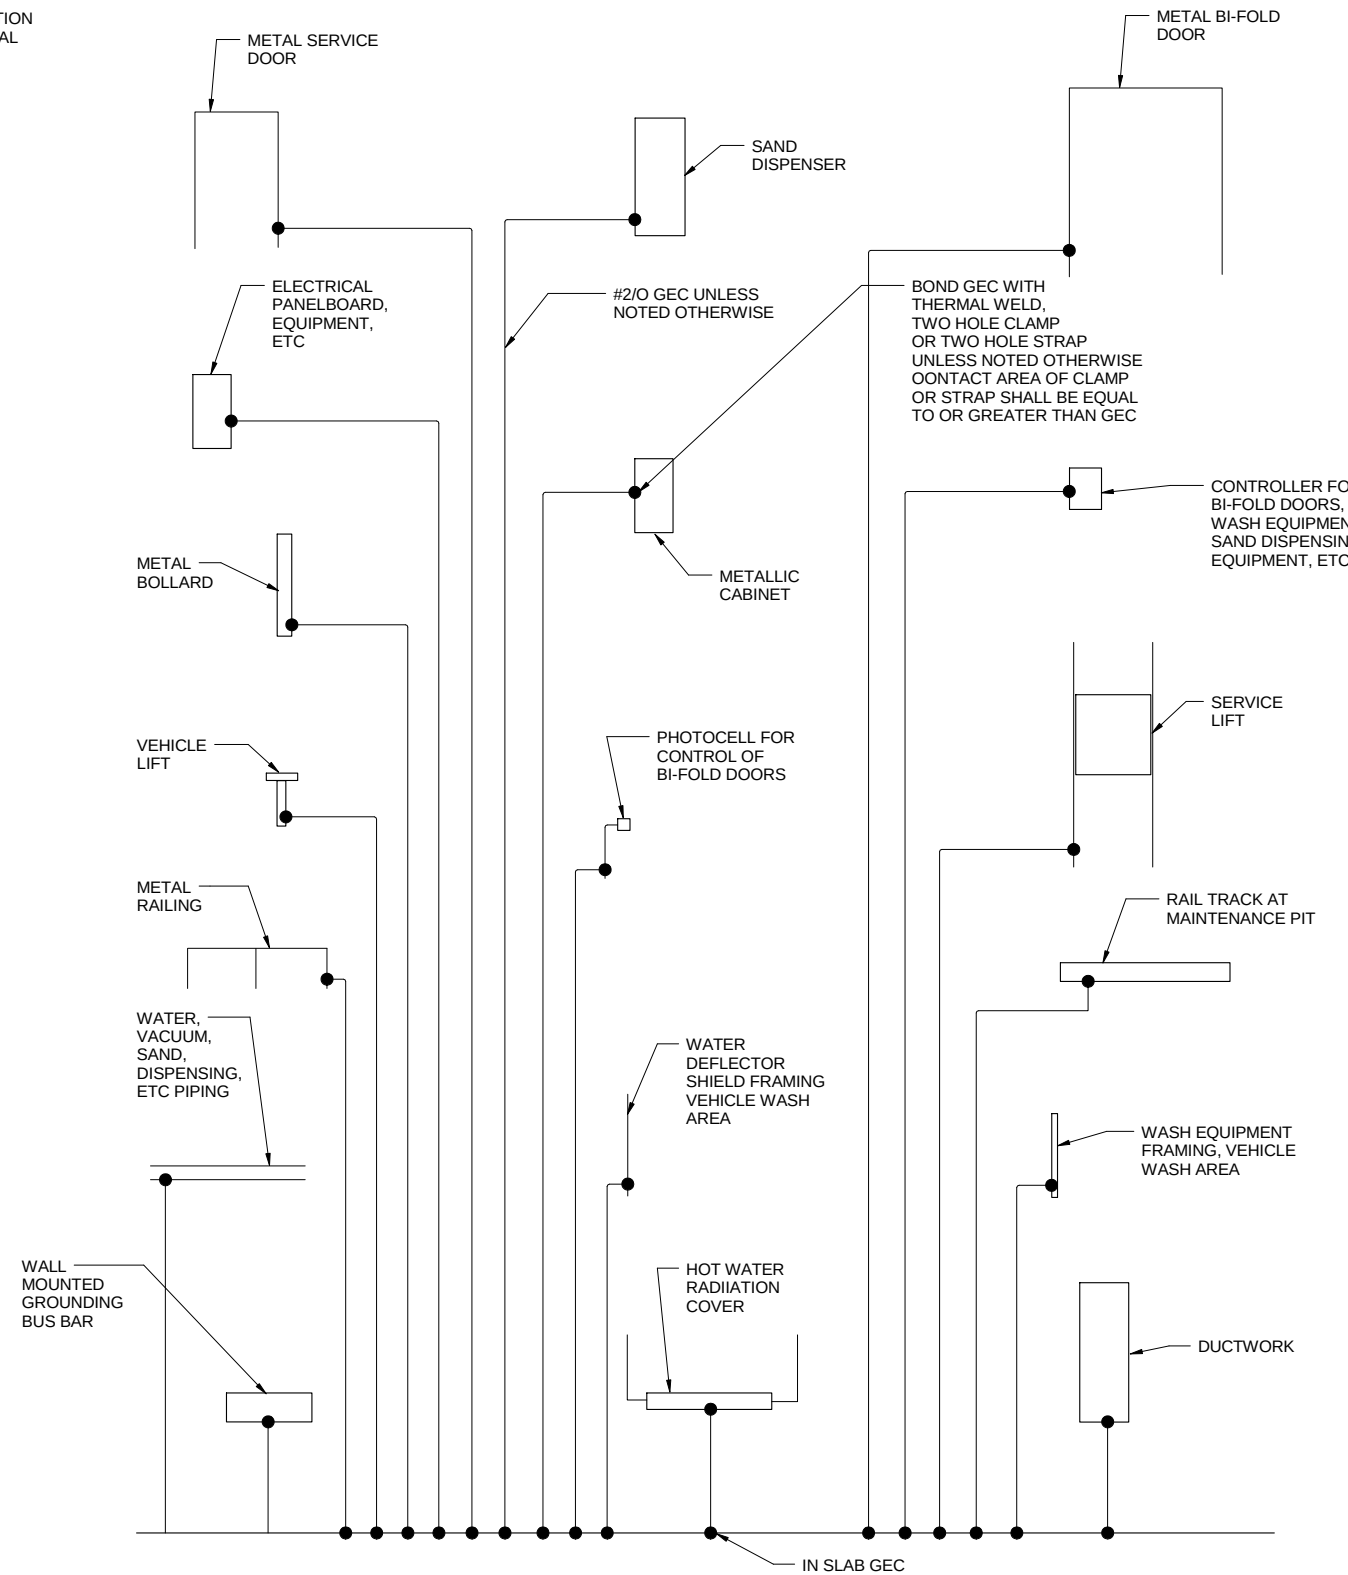

3
E504
SAFETY GROUNDING SYSTEM ONE-LINE DIAGRAM
SCALE: 1" = 1'-0"

NO	DATE	BY	CHECK	DESIGN	REVISION / SUBMITTAL

AECOM

MP Consultants
CONSULTING ENGINEERING
MINNEAPOLIS • MINNESOTA

60% SUBMISSION - 9/28/15

**METROPOLITAN**
COUNCIL


**SOUTHWEST**

OPERATIONS & MAINTENANCE FACILITY - V2B
ELECTRICAL
POWER ONE-LINE DIAGRAMS



DISCIPLINE: **ELECTRICAL**

SHEET NAME: **OMF-ELE-RSD**


E504

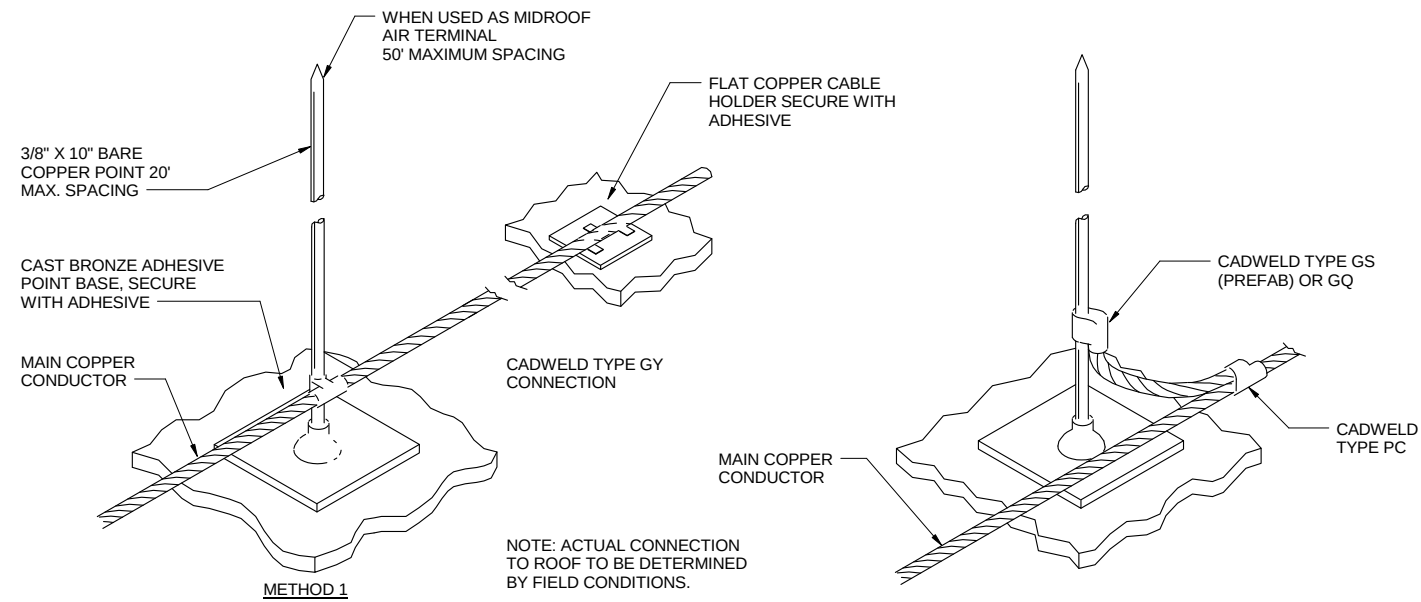

1
E505
AIR TERMINAL DETAILS
SCALE: 12" = 1'-0"

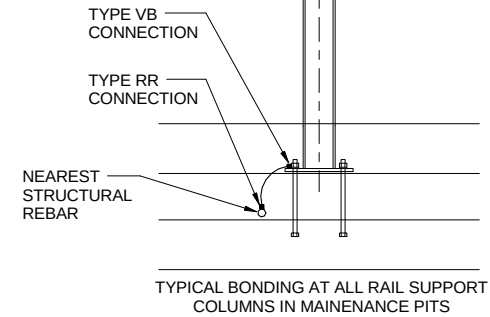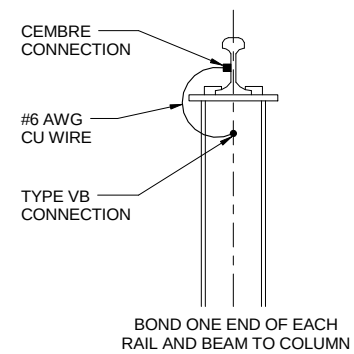

3
E505
AIR TERMINAL DETAILS
SCALE: 12" = 1'-0"

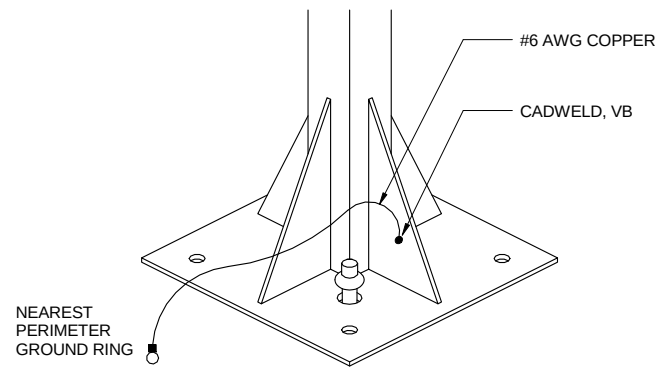

4
E505
E-505.4 GROUNDING OF WASHBAY PEDESTALS
SCALE: 12" = 1'-0"

NO	DATE	BY	CHECK	DESIGN	REVISION / SUBMITTAL

AECOM
CONSULTING ENGINEERING
MINNEAPOLIS, MINNESOTA

MP Consultants
CONSULTING ENGINEERING
MINNEAPOLIS, MINNESOTA


60% SUBMISSION - 9/28/15

METROPOLITAN COUNCIL


SOUTHWEST

OPERATIONS & MAINTENANCE FACILITY - V2B ELECTRICAL ELECTRICAL EQUIPMENT DETAILS			SHEET 238 OF 263
DISCIPLINE: ELECTRICAL	SHEET NAME: OMF-ELE-DTL	E505	


9/22/2015 10:12:52 AM C:\Users\V-Bege\B\Documents\OMF_ELEC_V-Bege\B.rvt

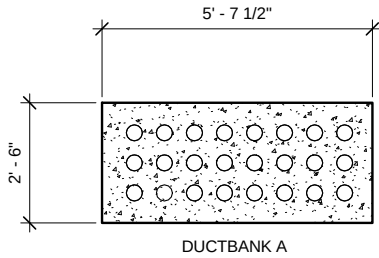


DUCTBANK A

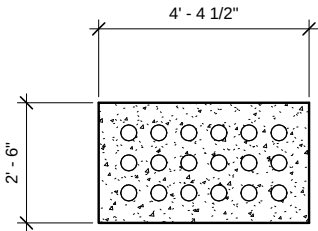


DUCTBANK B

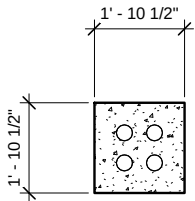

DUCTBANK C

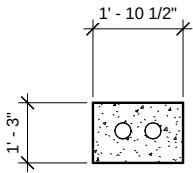

DUCTBANK D

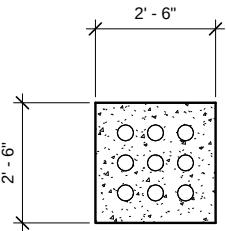

DUCTBANK E

1 E-506 DUCTBANK DETAILS
E506 SCALE: 1/2" = 1'-0"

NO	DATE	BY	CHECK	DESIGN	REVISION / SUBMITTAL





60% SUBMISSION - 9/28/15



OPERATIONS & MAINTENANCE FACILITY - V2B
ELECTRICAL
DUCTBANK DETAILS

DISCIPLINE:
ELECTRICAL

SHEET NAME:
OMF-ELE-DTL


E506

LUMINAIRE MOUNTING HEIGHT SCHEDULE					
LOCATION	CEILING TYPE	CEILING HEIGHT	MOUNTING HEIGHT	TYPE OF MOUNTING	NOTES
PIT	NONE	NA	NA	MOUNT ON SIDE WALL AT 4' ABOVE BOTTOM OF PIT AND ANGLE LUMINAIRE UP.	
COMMUNICATION ROOM, BACK-OFF-HOUSE, FM SHOP	LAY-IN/HARD/NONE	8'	8'	SURFACE	
RESTROOMS, OFFICES, TOOL CRIB, GEAR ROOM, STORAGE ROOM, CUSTODIAL CLOSET	LAY-IN/HARD/NONE	9'	9'	SURFACE	
COMPRESSOR AND LUBE ROOM	NONE	9'-8"	9'-8"	SURFACE	
RESTROOMS, PARTS OFFICE, CUSTODIAL ROOM	LAY-IN/HARD/NONE	10'	10'	SURFACE	
UNDER MEZZANINE AND PIT	NONE	13'	13'	SURFACE	PIT 5' BELOW FIRST FLOOR LEVEL
MEZZANINE	NONE	15'	15'	SURFACE	
TRUCK WASH	HARD	18'	18'	SURFACE	
SHOPS, ELEVATOR MACHINE ROOM, LOBBY, MEZZANINE, ELECTRICAL ROOMS, MECHANICAL ROOMS	NONE	18'	12'	PENDENT OR CHAIN	
STORAGE ROOMS	NONE	18'	12'	PENDENT OR CHAIN	COORDINATE MOUNTING HEIGHTS WITH SHELVING
SALLY PORT	NONE	19'	12'	PENDENT OR CHAIN	
LRV STORAGE (BARN)	NONE	20'	18'	CHAIN MOUNT FLUSH WITH BOTTOM OF STRUCTURAL STEEL	
TRUCK WASH AND WASH SUPPORT	HARD	22'-3"	22'-3"	SURFACE	
LIFTS AREA, COMPONENT WORK AREA, UNSCHEDULED MAINTENANCE,	NONE	28'	15'-8"	CHAIN MOUNT FLUSH WITH BOTTOM OF STRUCTURAL STEEL	
EXTERIOR WALL MOUNTED LUMINAIRES	NA	NA	MOUNT LUMINAIRES 2' ABOVE HEIGHT OF DOOR	WALL	




OPERATIONS & MAINTENANCE FACILITY - V2B
ELECTRICAL
INDUSTRIAL EQUIPMENT SCHEDULE


DISCIPLINE:	ELECTRICAL	SHEET NAME:	OMF-ELE-SCH	E805
-------------	-------------------	-------------	--------------------	-------------

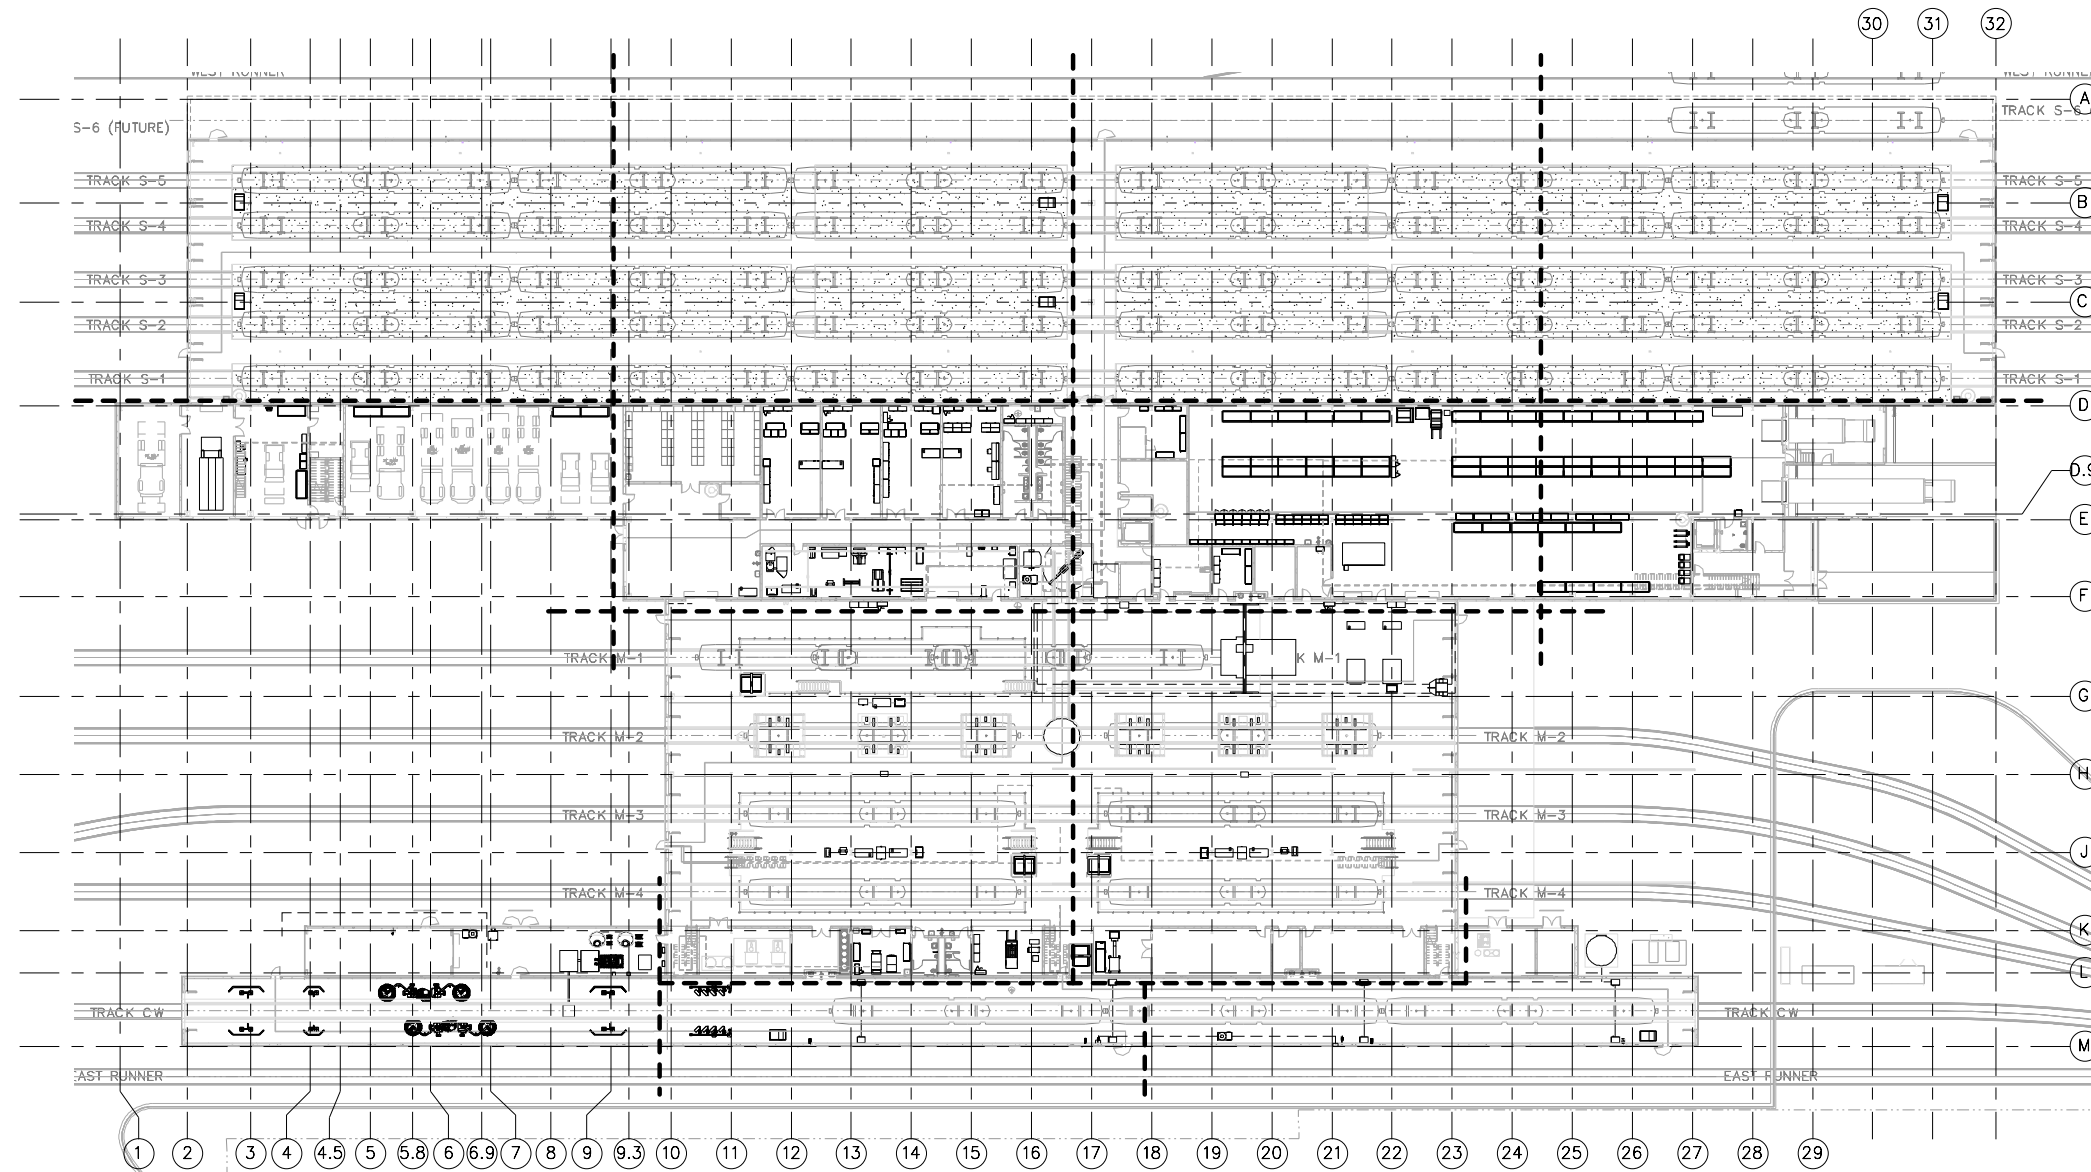

① LEVEL ONE OVERALL PLAN
1/32" = 1'-0"

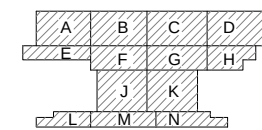

KEY PLAN - SCALE: N.T.S.

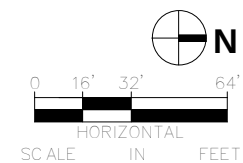[illegible]

AECOM **PARSONS**
BRINCKERHOFF

60% SUBMISSION - 09/28/15

OPERATIONS & MAINTENANCE FACILITY -V2B INDUSTRIAL	S
--	---

LEVEL ONE OVERALL FLOOR PLAN

DISCIPLINE:

INDUSTRIAL

SHEET NAME:

AME:
OMF-IND-PLN

I110


SHEET

243


OF

263


9/22/2015 8:51:24 AM R:\PROJECTS\19140A - SWLRT FDD\Drawings\OMF - SWLRT FDD\Drawings\IND-STR-VT (INDUSTRIAL).rvt

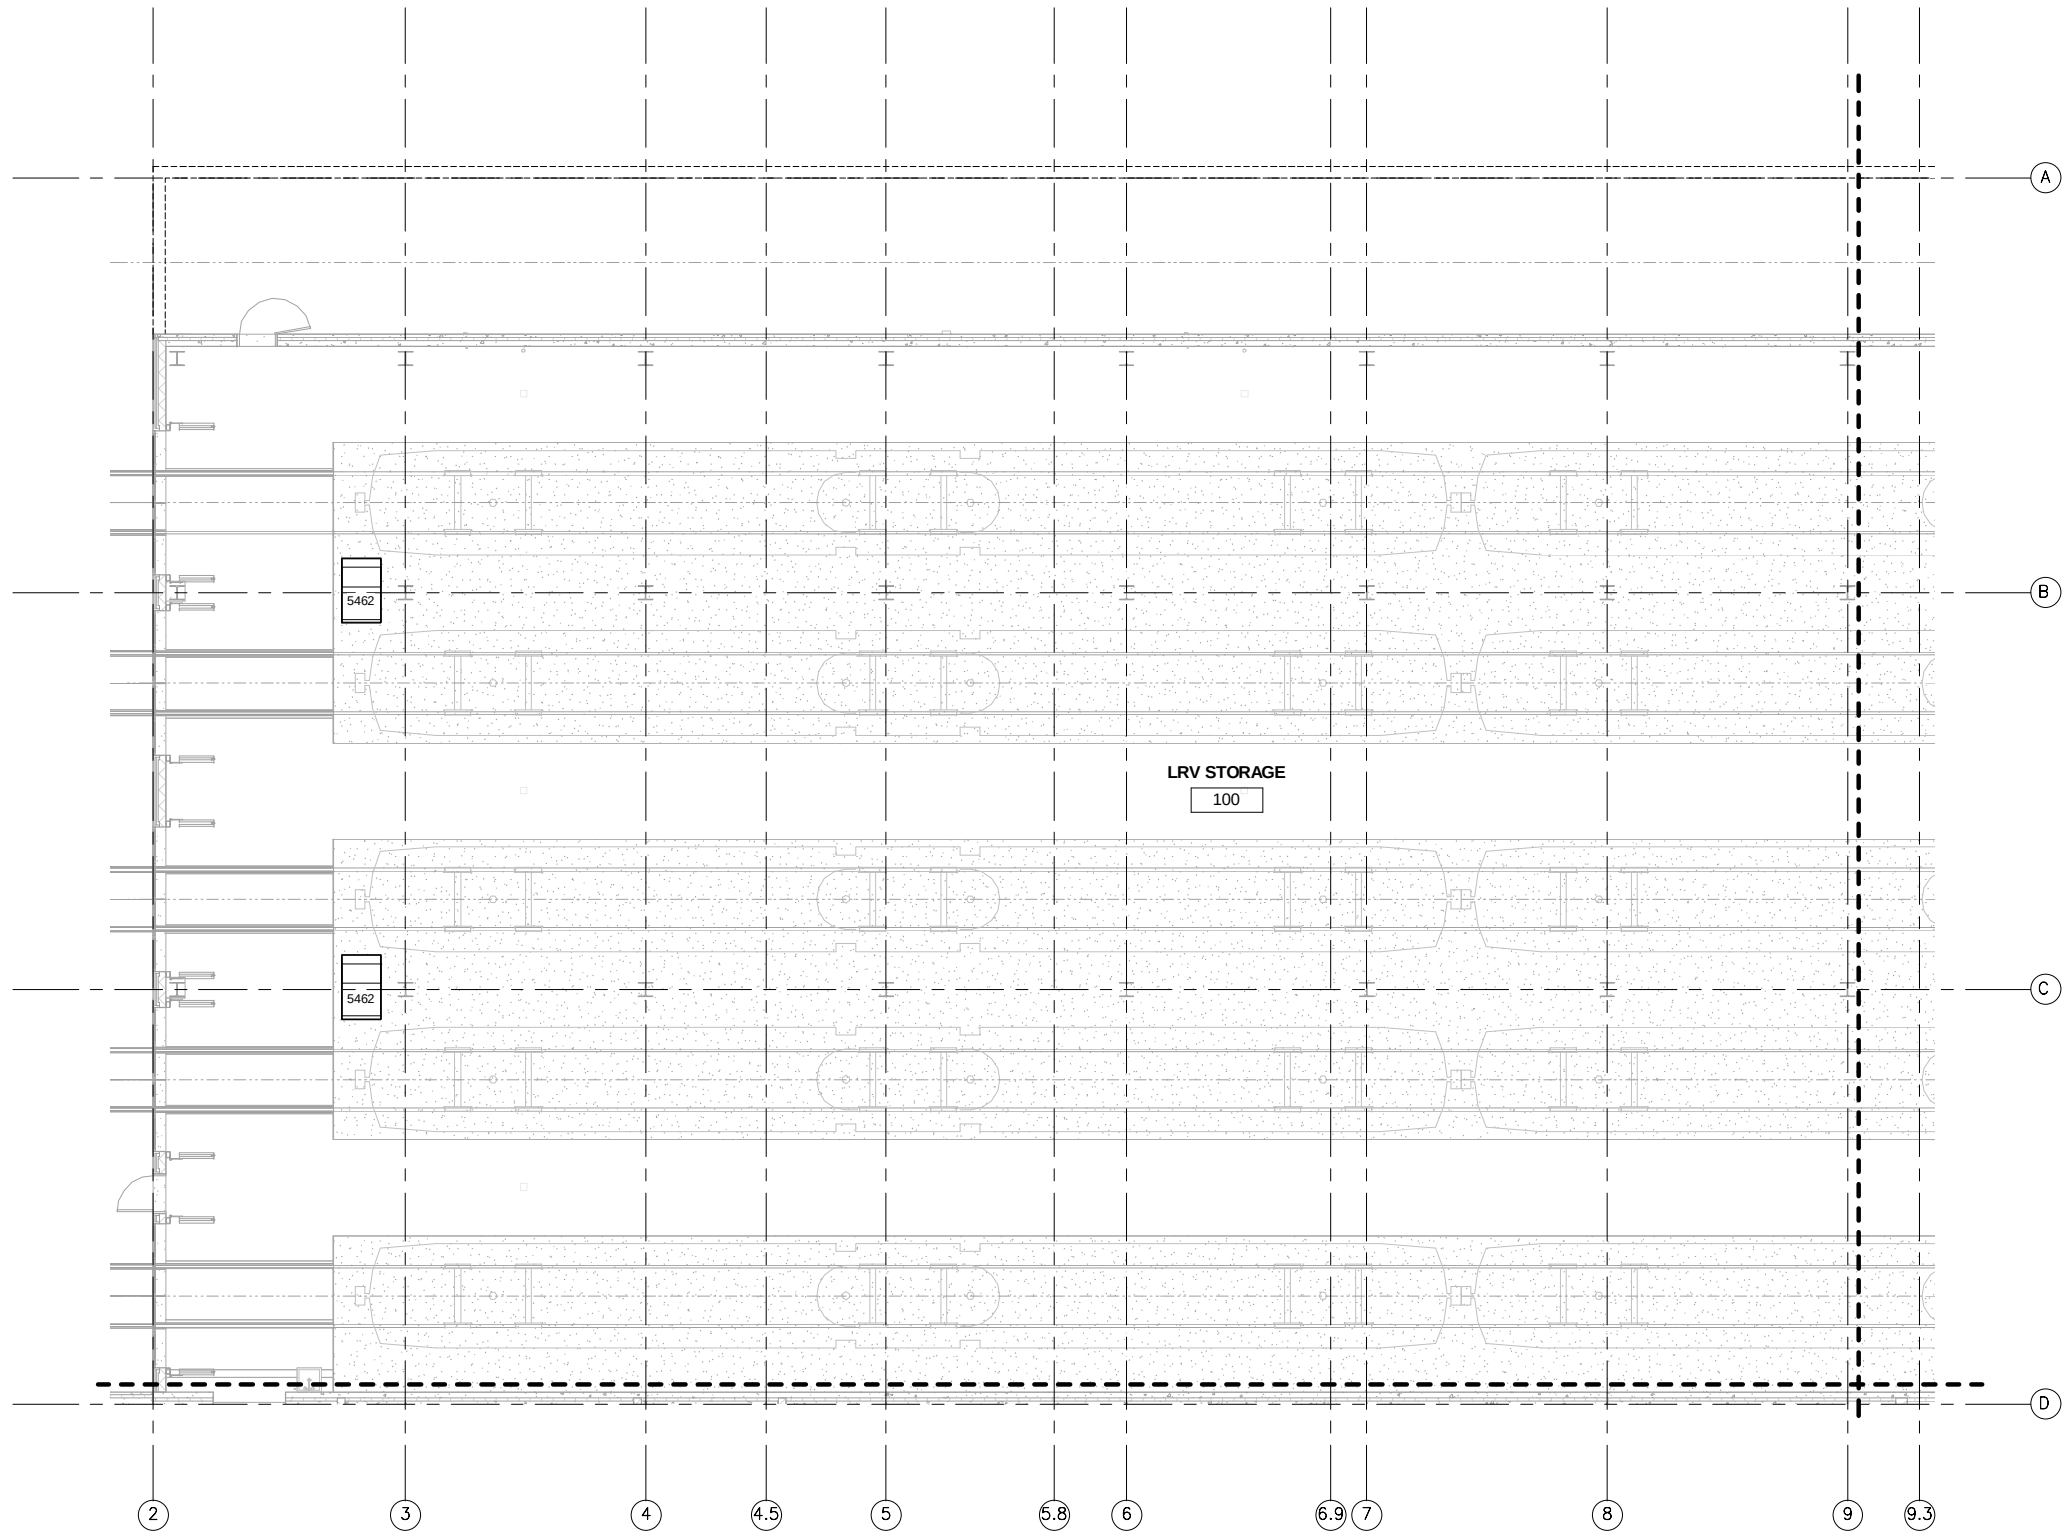

① LEVEL ONE - AREA A
1/8" = 1'-0"


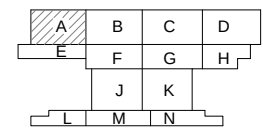


KEY PLAN - SCALE: N.T.S.

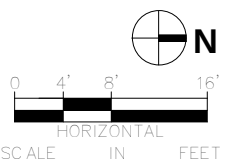

NO	DATE	BY	CHECK	DESIGN	REVISION / SUBMITTAL

 	 	OPERATIONS & MAINTENANCE FACILITY -V2B			SHEET 244 OF 263
		INDUSTRIAL			
LEVEL ONE ENLARGED PLANS AREA A		DISCIPLINE: INDUSTRIAL	SHEET NAME: OMF-IND-PLN	I110A	
60% SUBMISSION - 09/28/15					

  [illegible]

60% SUBMISSION - 09/28/15




LEVEL ONE ENLARGED PLANS AREA B


I110B	
-------	--

SHEET
245
OF
263


9/22/2015 8:51:29 AM R:\PROJECTS\19140A - SWLRT FDD\Drawings\OMF - SWLRT FDD\Drawings\OMF_IND.ST.RVT (INDUSTRIAL).rvt

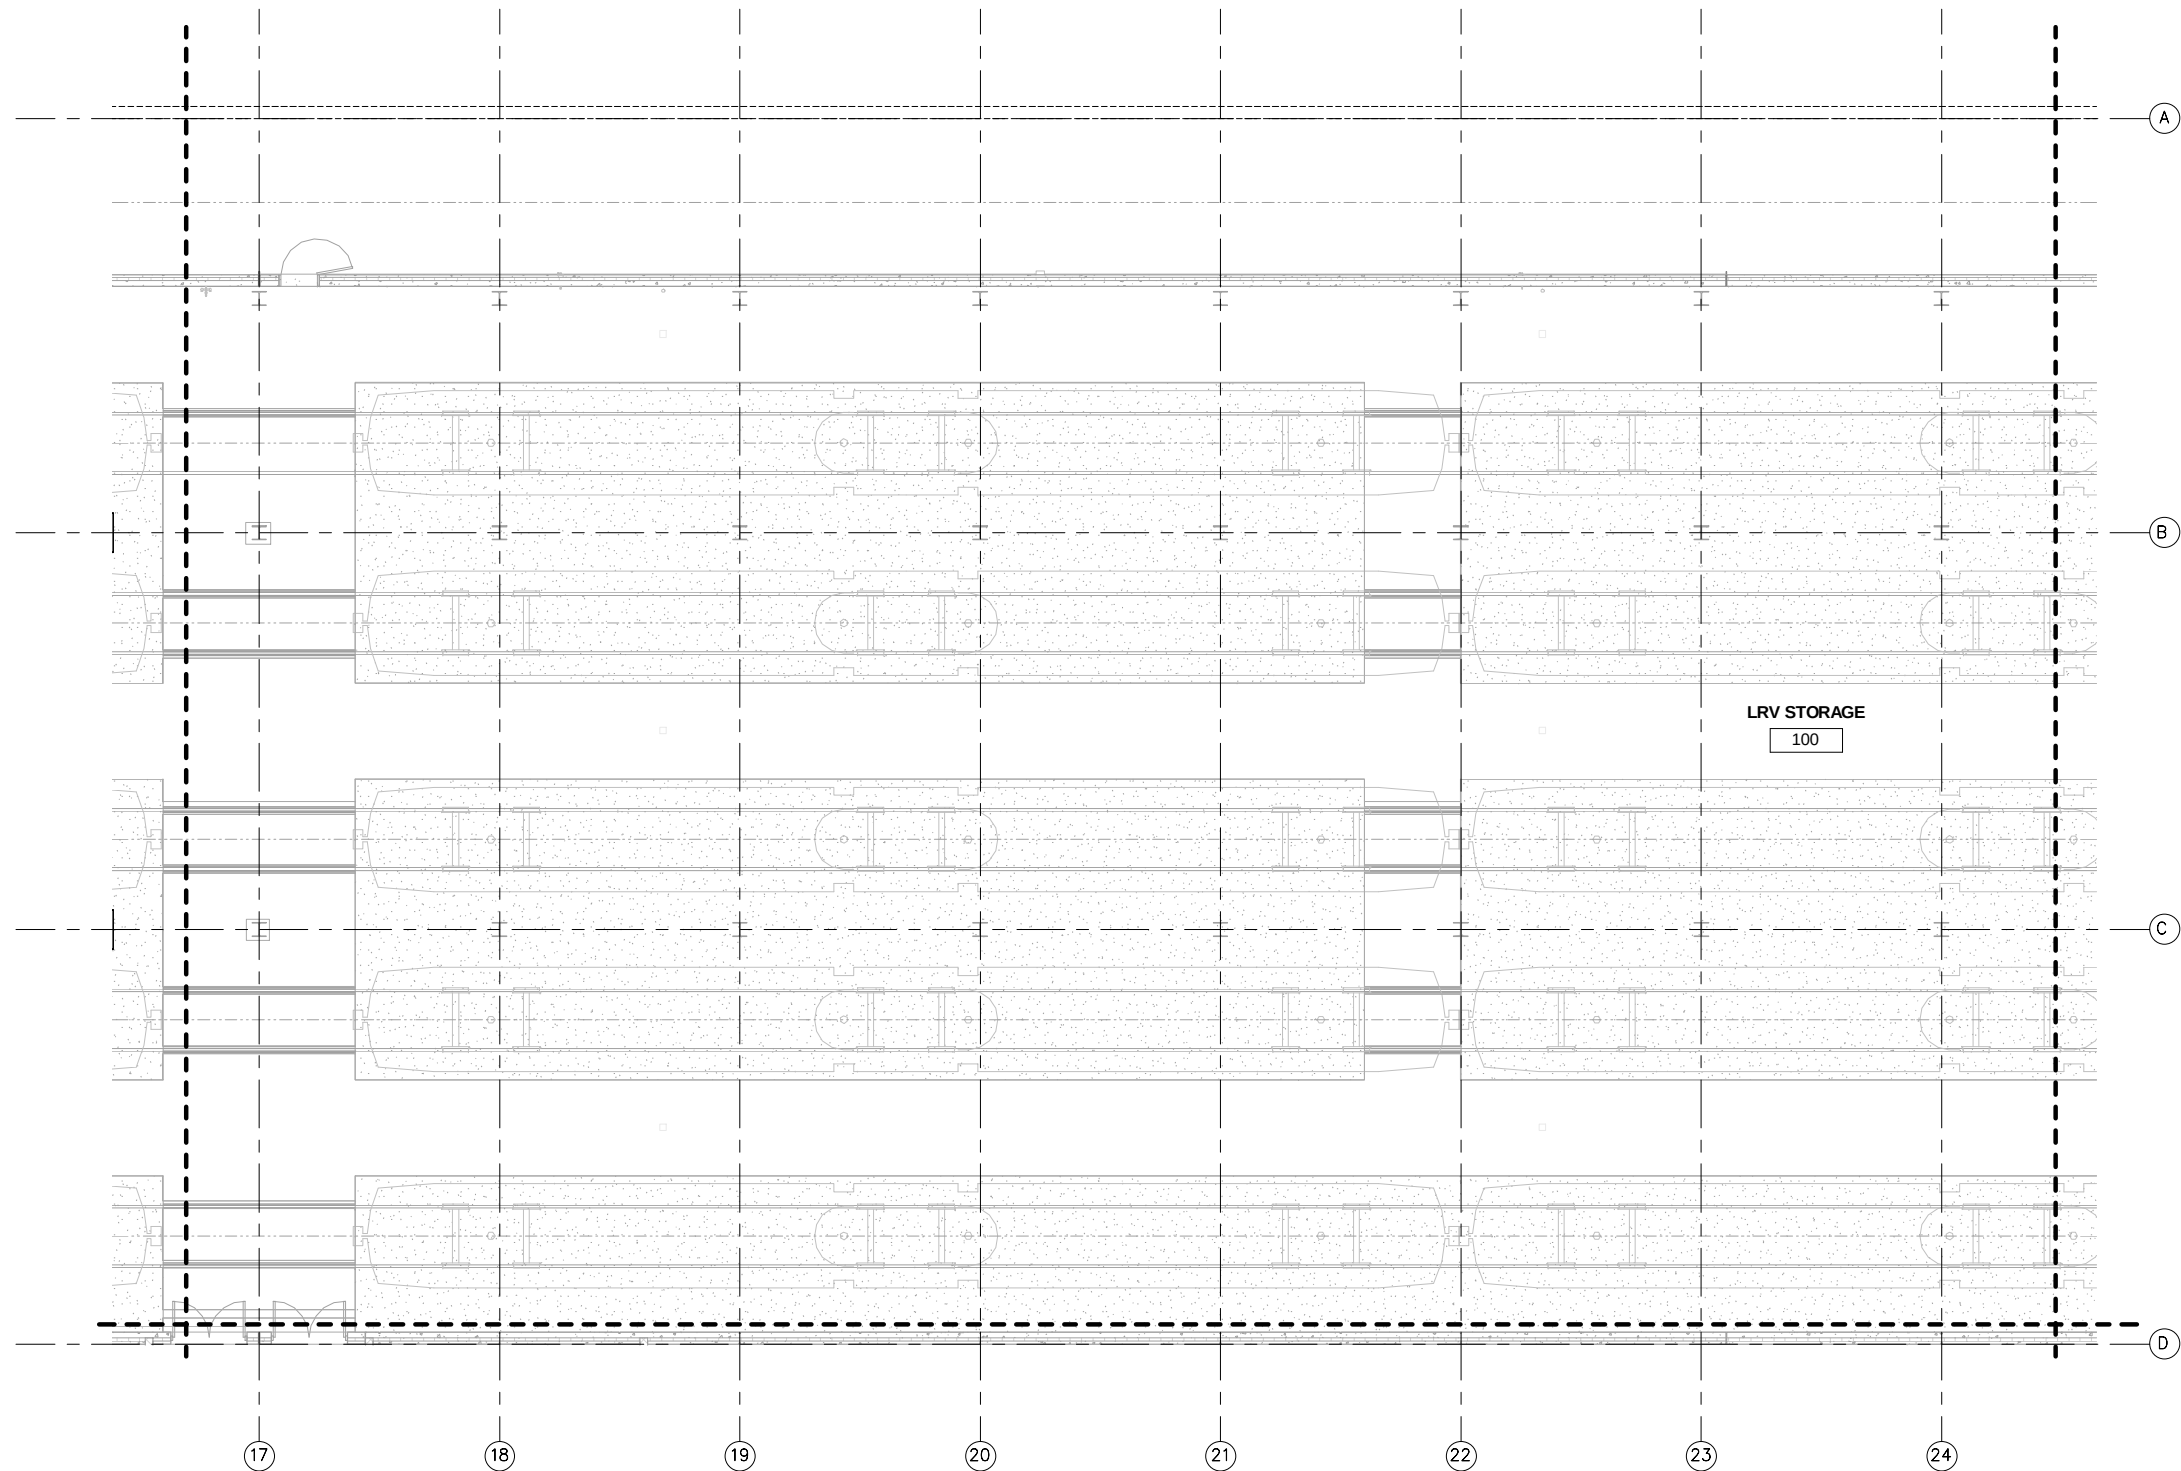

① LEVEL ONE - AREA C
1/8" = 1'-0"

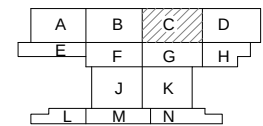

KEY PLAN - SCALE: N.T.S.

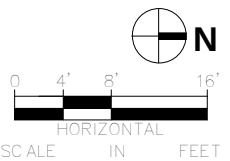

NO	DATE	BY	CHECK	DESIGN	REVISION / SUBMITTAL

AECOM **PARSONS BRINCKERHOFF**

60% SUBMISSION - 09/28/15




OPERATIONS & MAINTENANCE FACILITY -V2B
INDUSTRIAL
LEVEL ONE ENLARGED PLANS AREA C

DISCIPLINE: **INDUSTRIAL** SHEET NAME: **OMF-IND-PLN** **I110C**

SHEET
246
OF
263

9/22/2015 8:51:32 AM R:\PROJECTS\19140A - SWLRT FDD\Drawings\OMF - INDUSTRIAL\IND-PLN-1.rvt

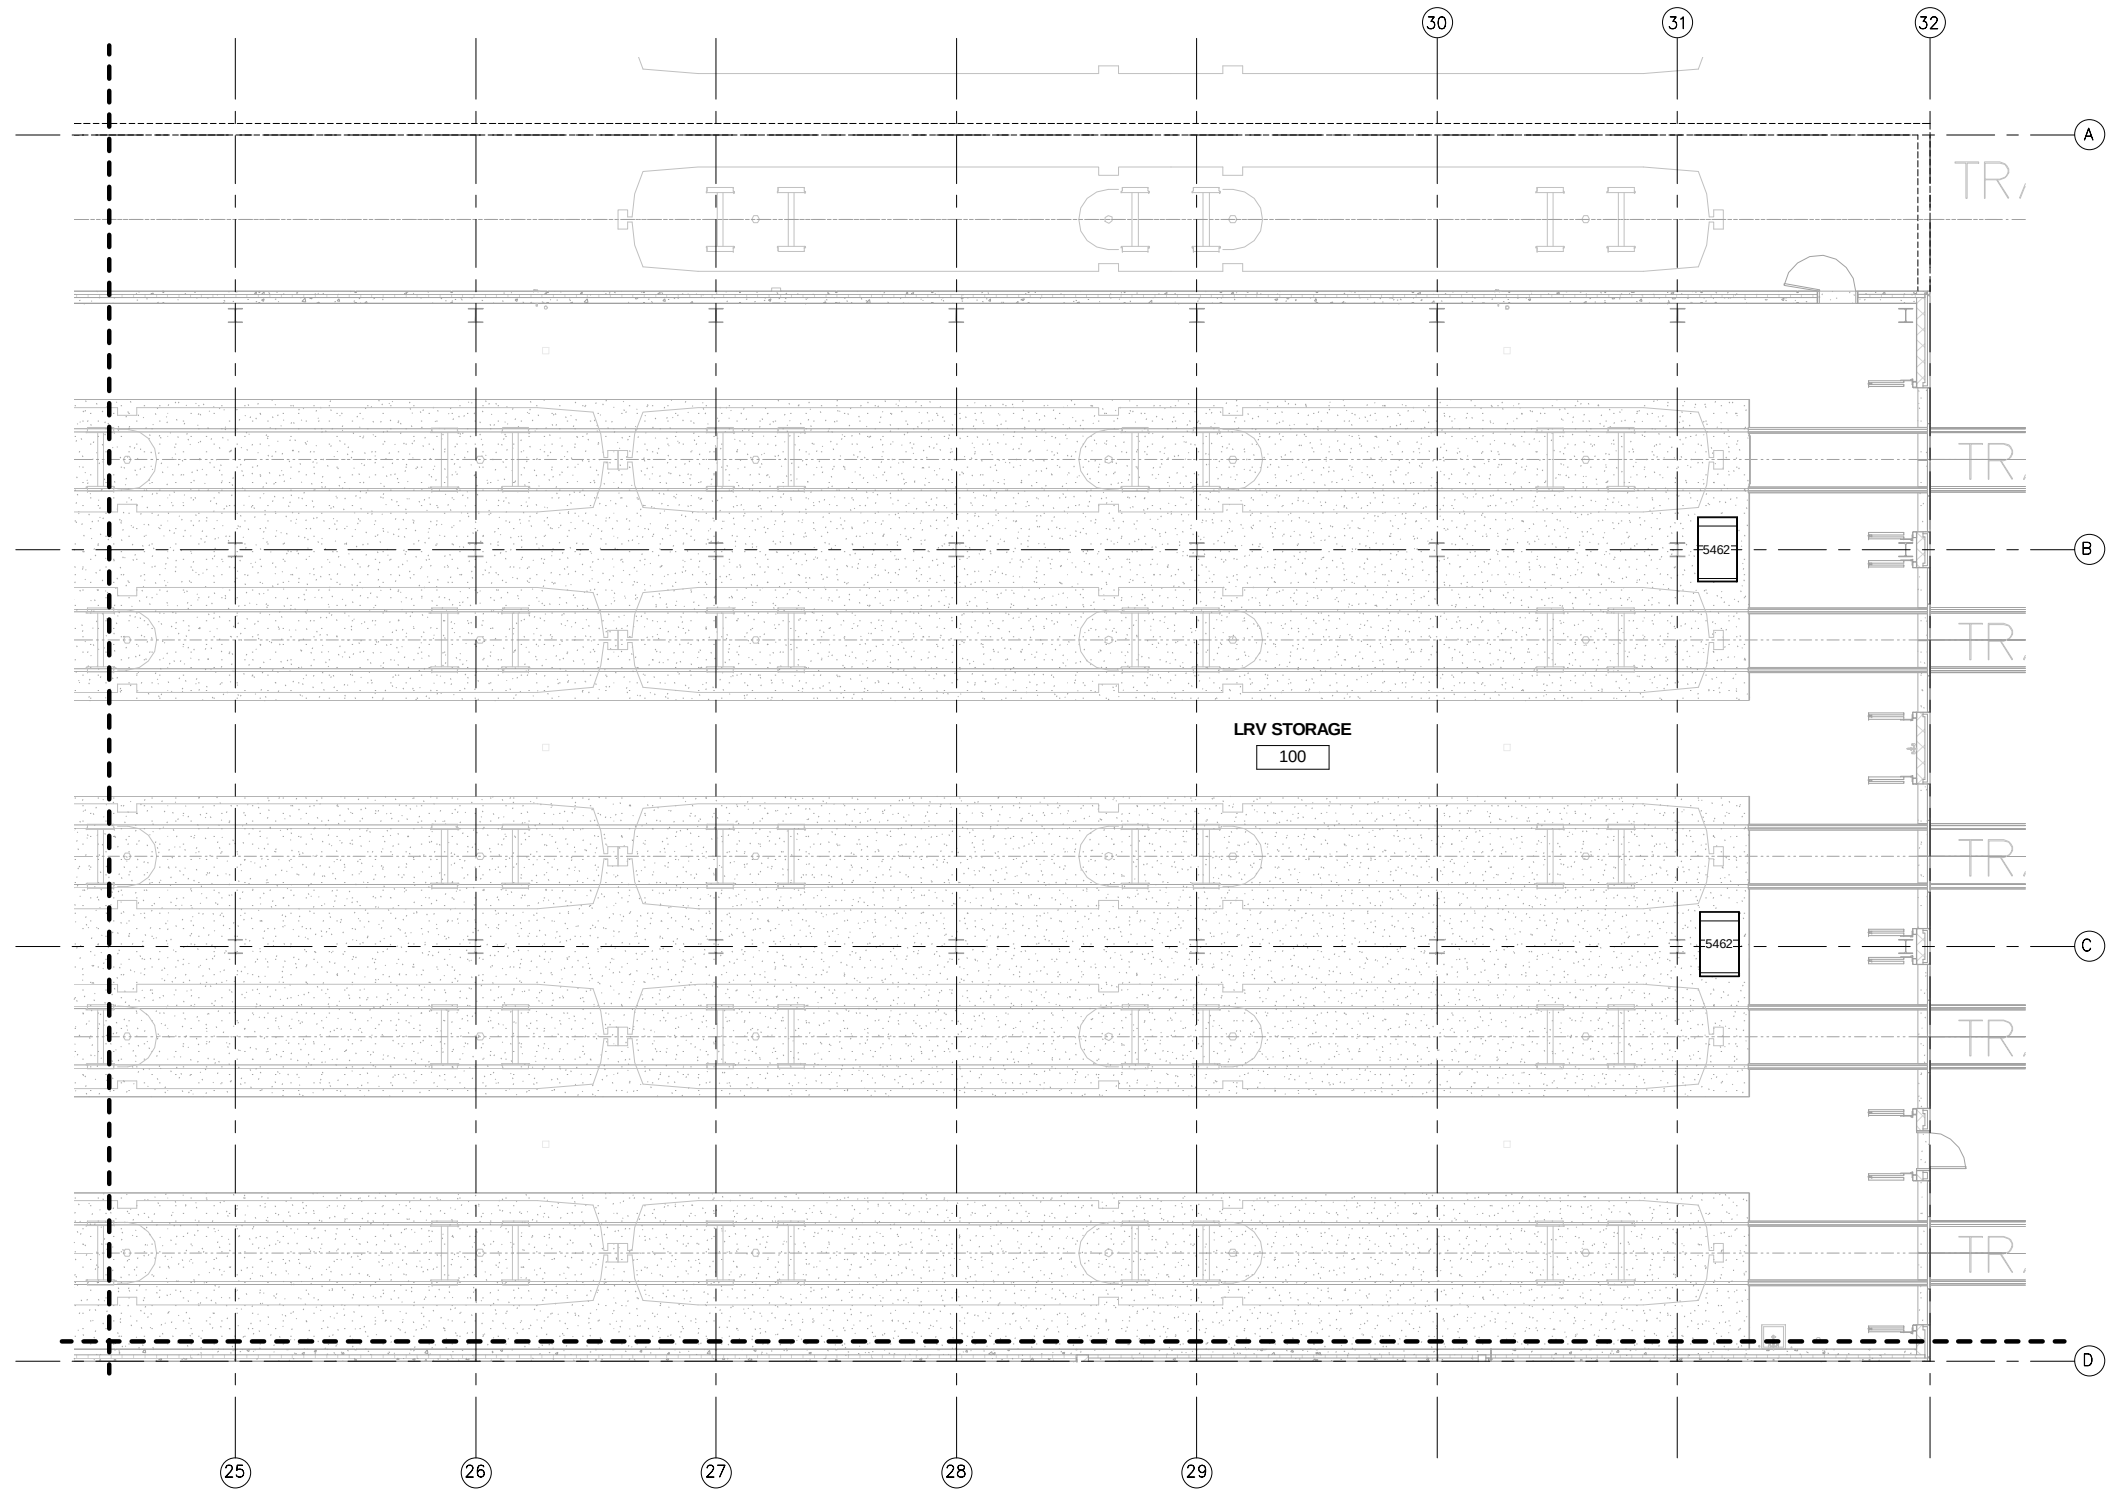

① LEVEL ONE - AREA D
1/8" = 1'-0"

A	B	C	D
E	F	G	H
	J	K	
L	M	N	

KEY PLAN - SCALE: N.T.S.

N

0 4' 8' 16'

HORIZONTAL SCALE IN FEET

NO	DATE	BY	CHECK	DESIGN	REVISION / SUBMITTAL


60% SUBMISSION - 09/28/15

OPERATIONS & MAINTENANCE FACILITY -V2B
INDUSTRIAL
LEVEL ONE ENLARGED PLANS AREA D


DISCIPLINE: INDUSTRIAL
SHEET NAME: OMF-IND-PLN
I110D

SHEET 247
OF 263

9/22/2015 8:51:34 AM R:\PROJECTS\19140A - SWLRT FDD\Drawings\OMF_IND\ST.RVT (INDUSTRIAL).rvt

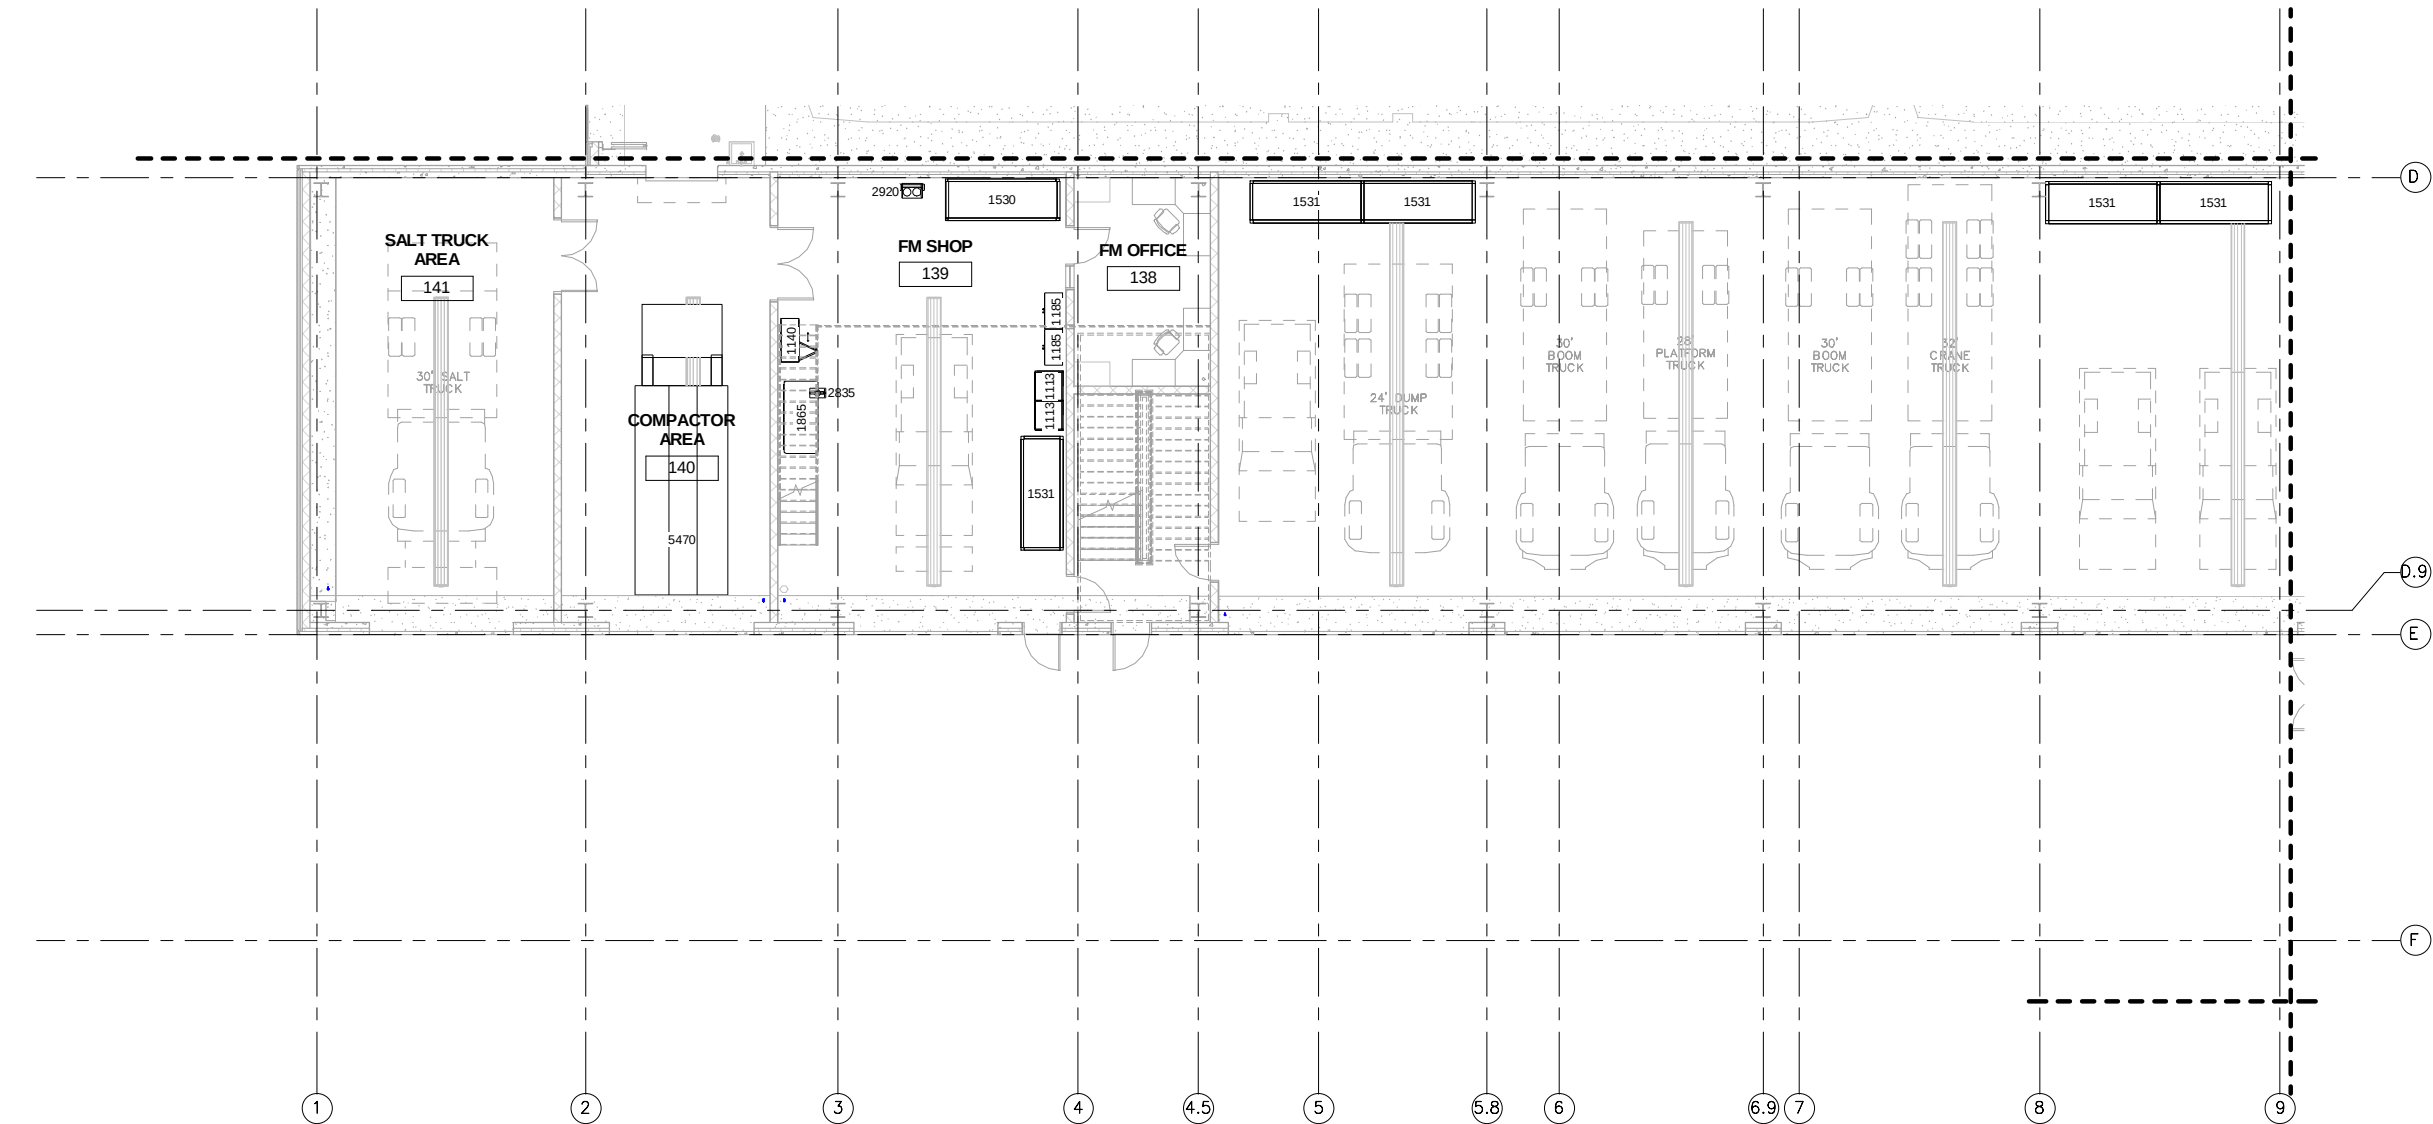

1 LEVEL ONE - AREA E
1/8" = 1'-0"

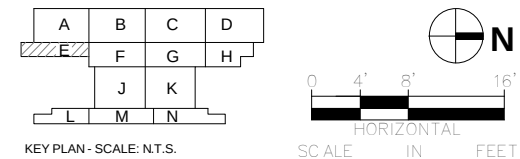

NO	DATE	BY	CHECK	DESIGN	REVISION / SUBMITTAL

 60% SUBMISSION - 09/28/15	 SOUTHWEST Green Line LRT Extension	OPERATIONS & MAINTENANCE FACILITY -V2B		SHEET 248 OF 263
		INDUSTRIAL		
		LEVEL ONE ENLARGED PLANS AREA E		
		DISCIPLINE: INDUSTRIAL	SHEET NAME: OMF-IND-PLN	I110E

A	B	C	D
E	F	G	H
	J	K	
L	M	N	


[illegible]

LEVEL ONE ENLARGED PLANS AREA G


I110G	
-------	--

HEET
250
OF
263


9/22/2015 8:51:40 AM R:\PROJECTS\19140A - SWLRT FDD\Drawings\OMF - IND\ST.RVT (INDUSTRIAL).rvt

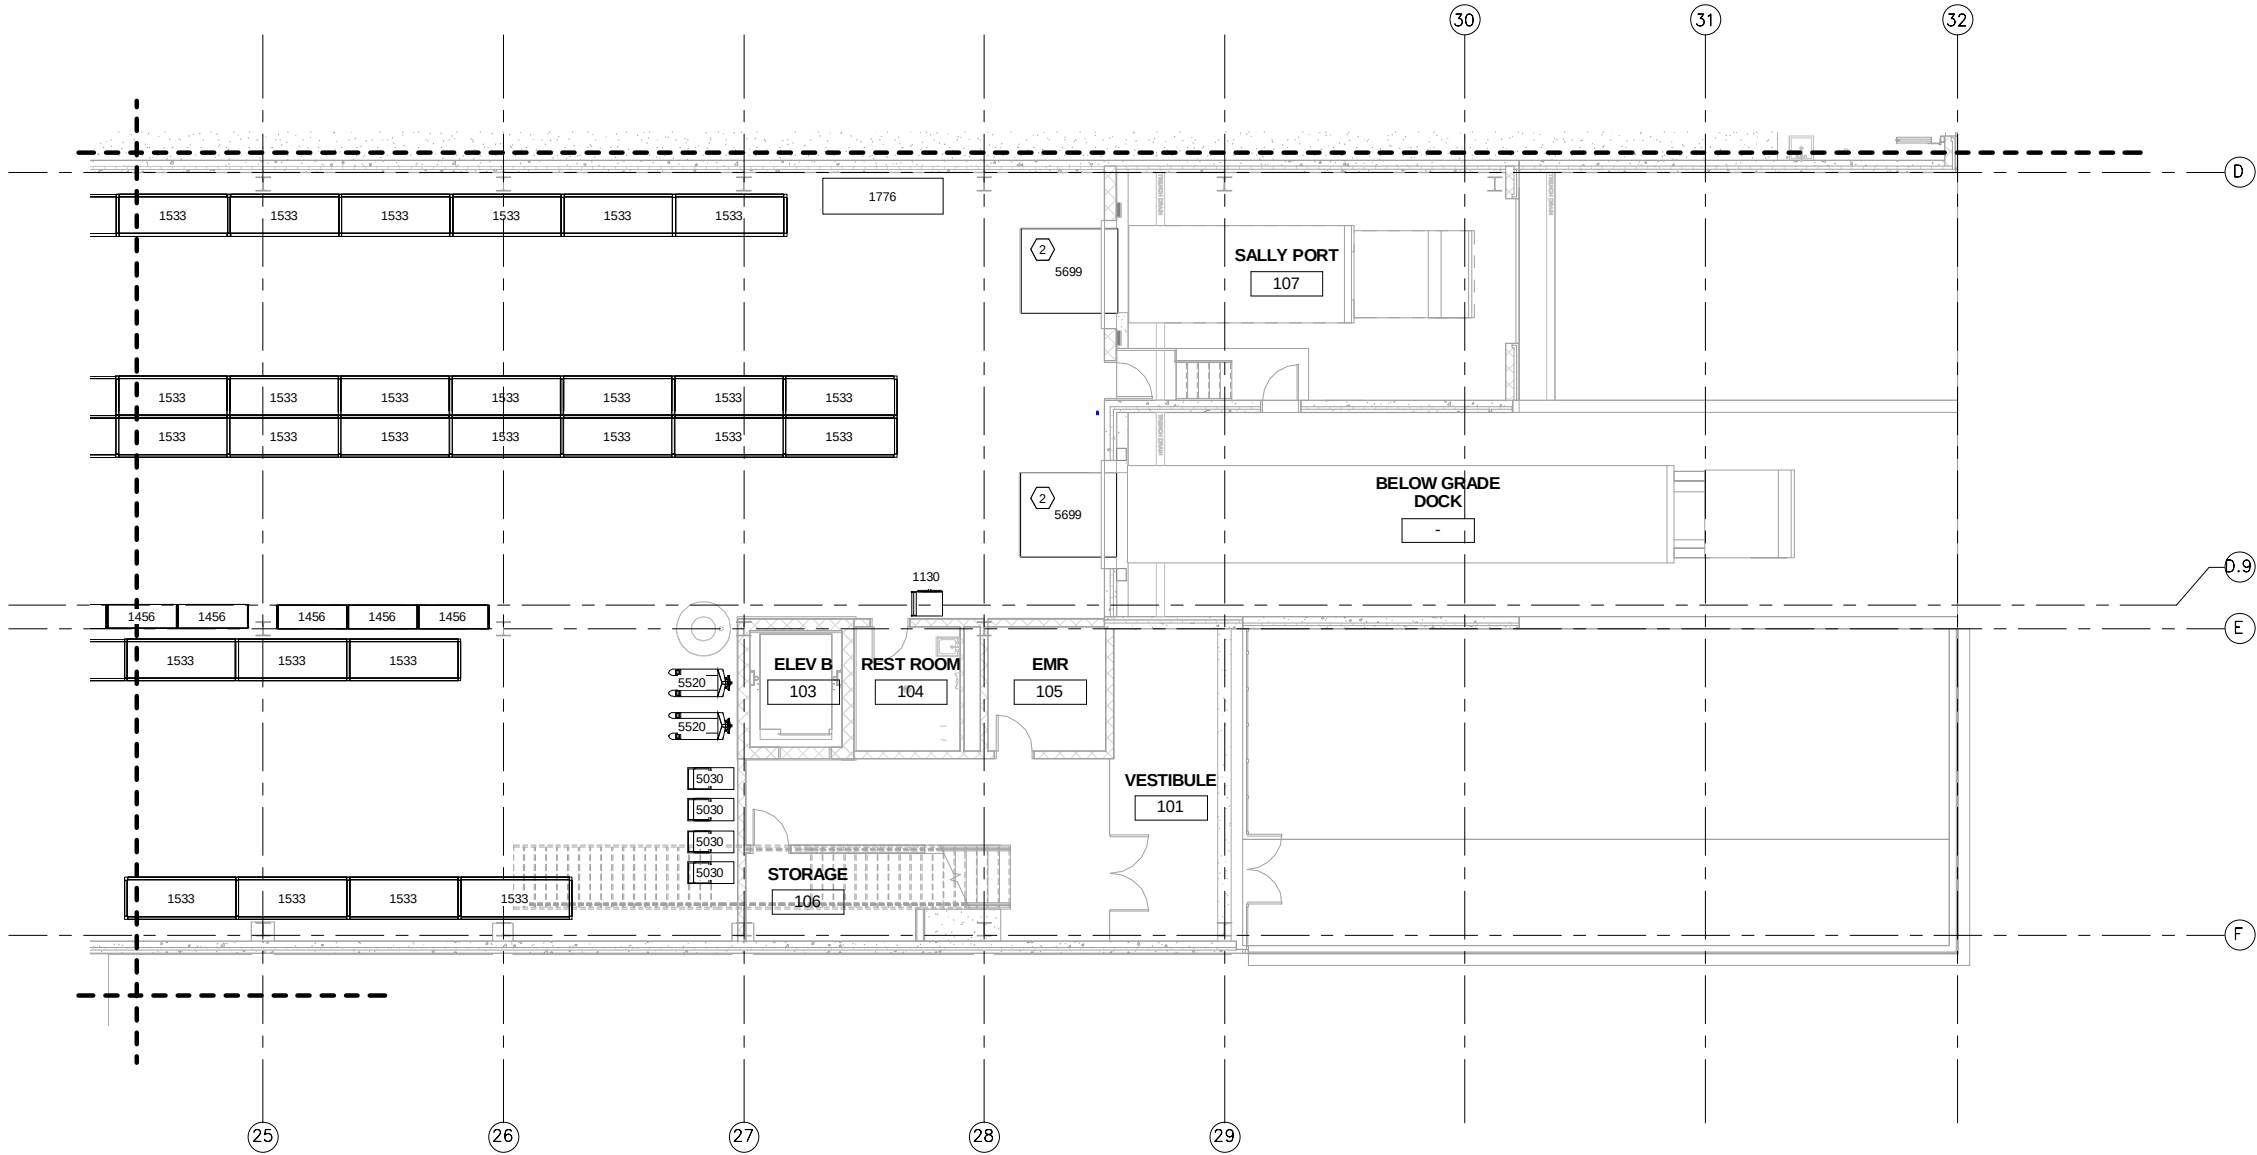

① LEVEL ONE - AREA H
1/8" = 1'-0"

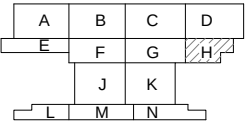

KEY PLAN - SCALE: N.T.S.

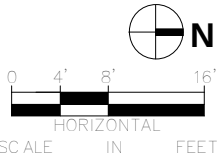

NO	DATE	BY	CHECK	DESIGN	REVISION / SUBMITTAL



60% SUBMISSION - 09/28/15






OPERATIONS & MAINTENANCE FACILITY -V2B
INDUSTRIAL
LEVEL ONE ENLARGED PLANS AREA H

DISCIPLINE: INDUSTRIAL
SHEET NAME: OMF-IND-PLN
I110H


SHEET
251
OF
263

NOT USED

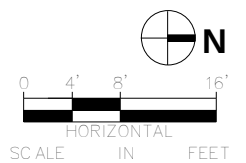
[illegible]

  


9/22/2015 8:51:46 AM R:\PROJECTS\19140A - SW LRT FDD\Drawings\OMF - IND\ST.RVT (INDUSTRIAL).rvt

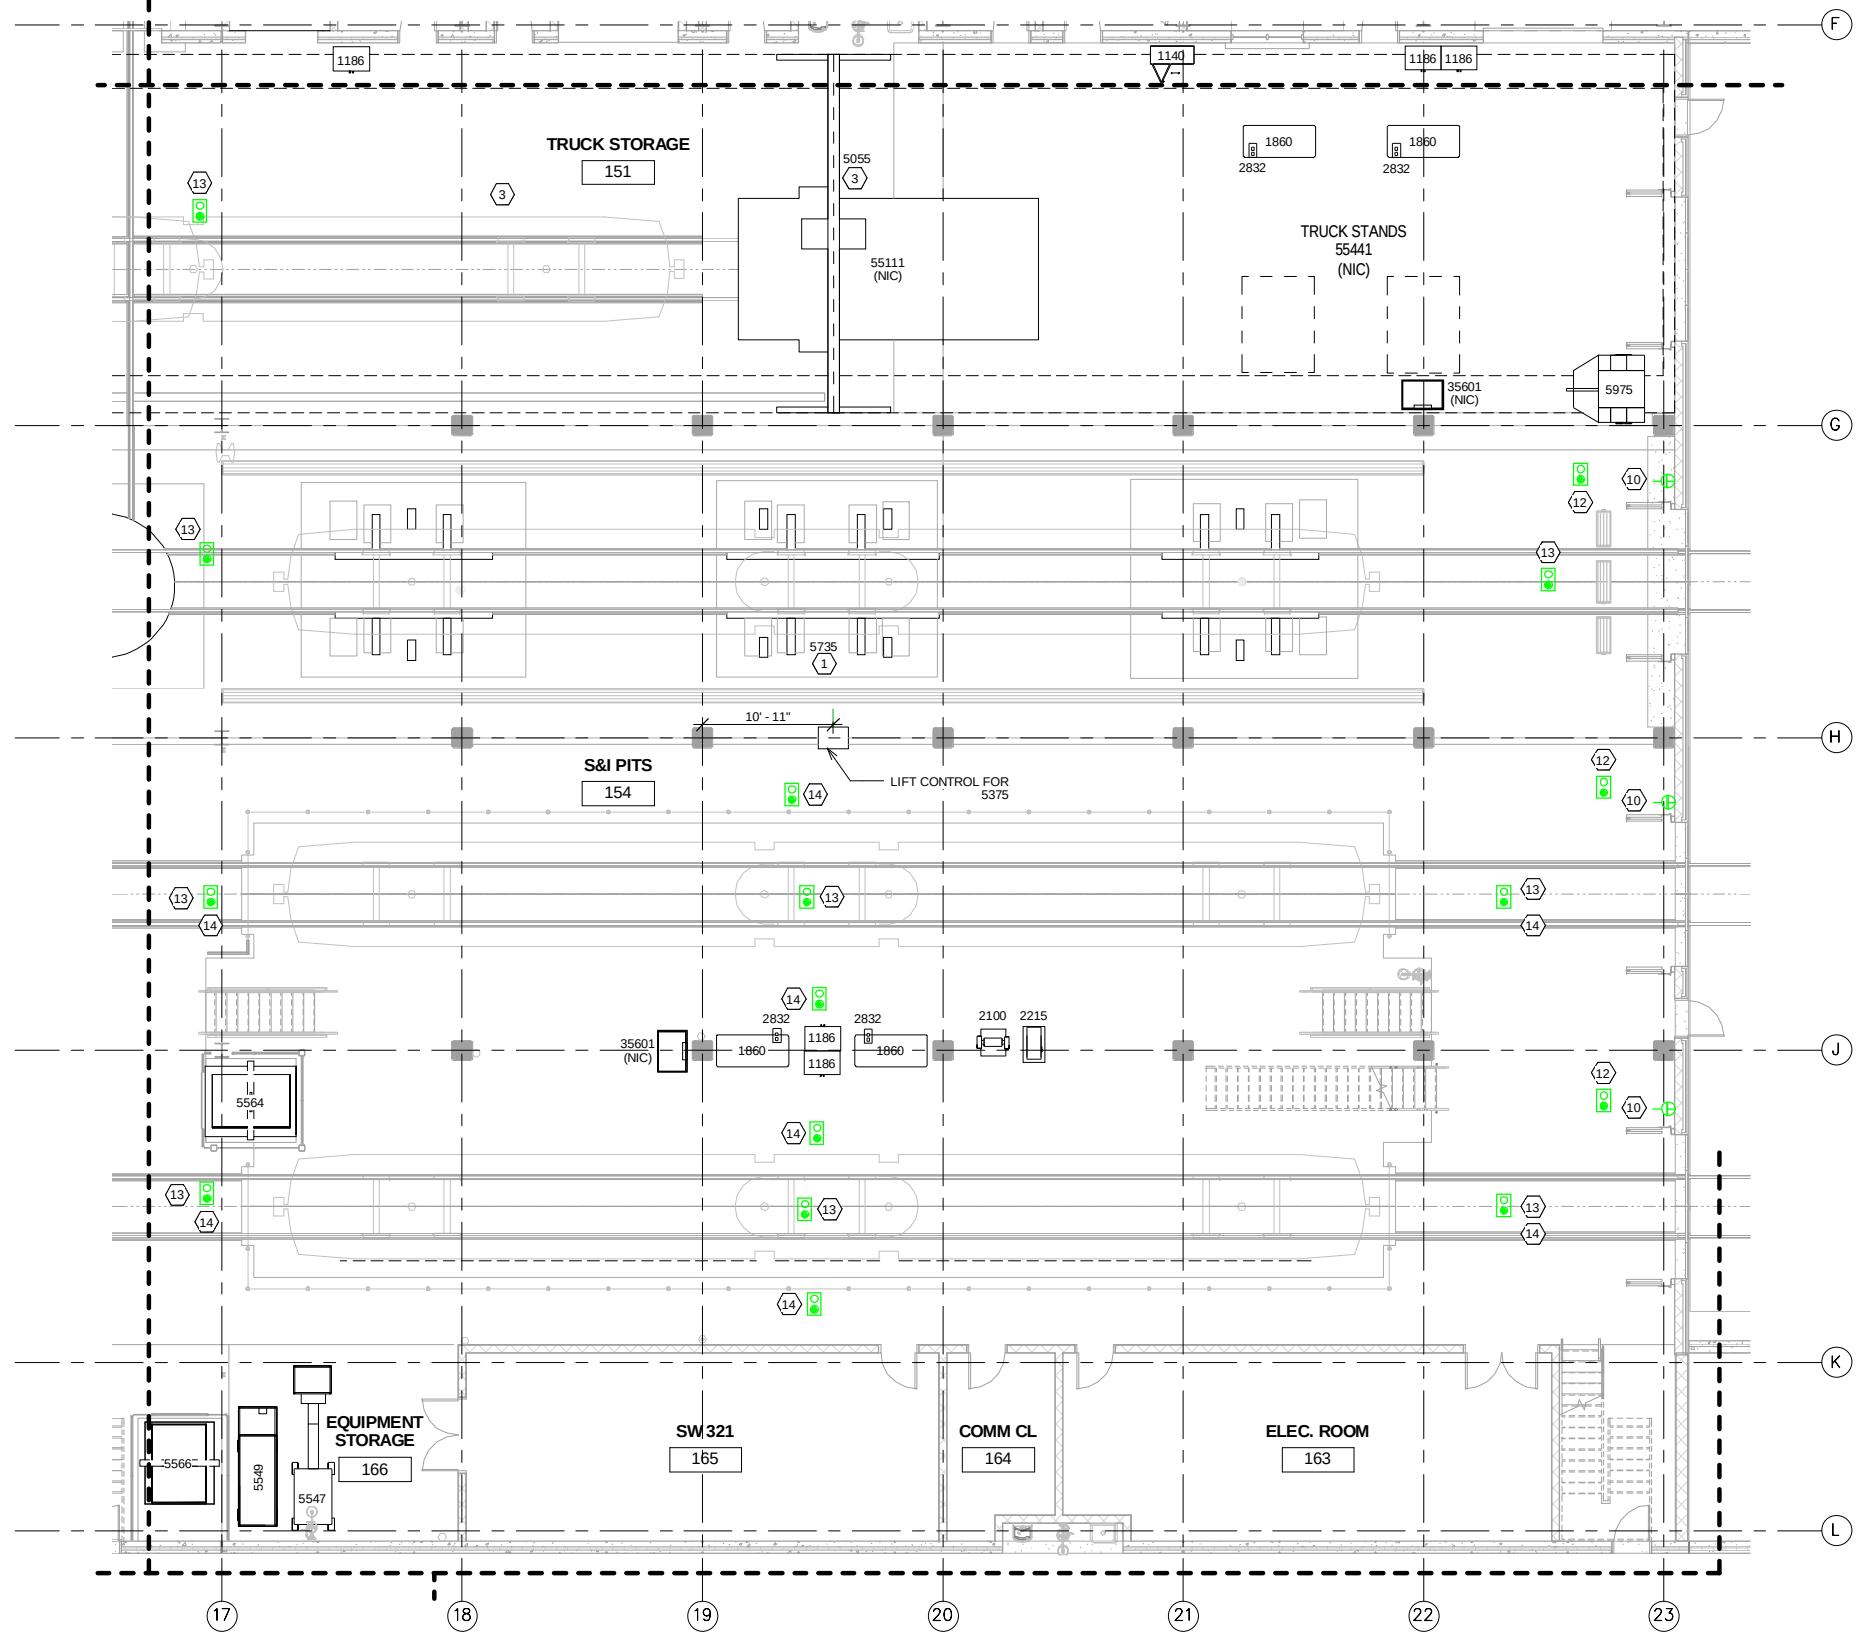

① LEVEL ONE - AREA K
1/8" = 1'-0"

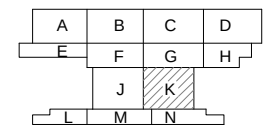

KEY PLAN - SCALE: N.T.S.

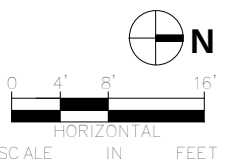

NO	DATE	BY	CHECK	DESIGN	REVISION / SUBMITTAL

AECOM **PARSONS**
BRINCKERHOFF

60% SUBMISSION - 09/28/15



OPERATIONS & MAINTENANCE FACILITY -V2B
INDUSTRIAL
LEVEL ONE ENLARGED PLANS AREA K

DISCIPLINE:


INDUSTRIAL

SHEET NAME:


OMF-IND-PLN

I110K


SHEET
254
OF
263

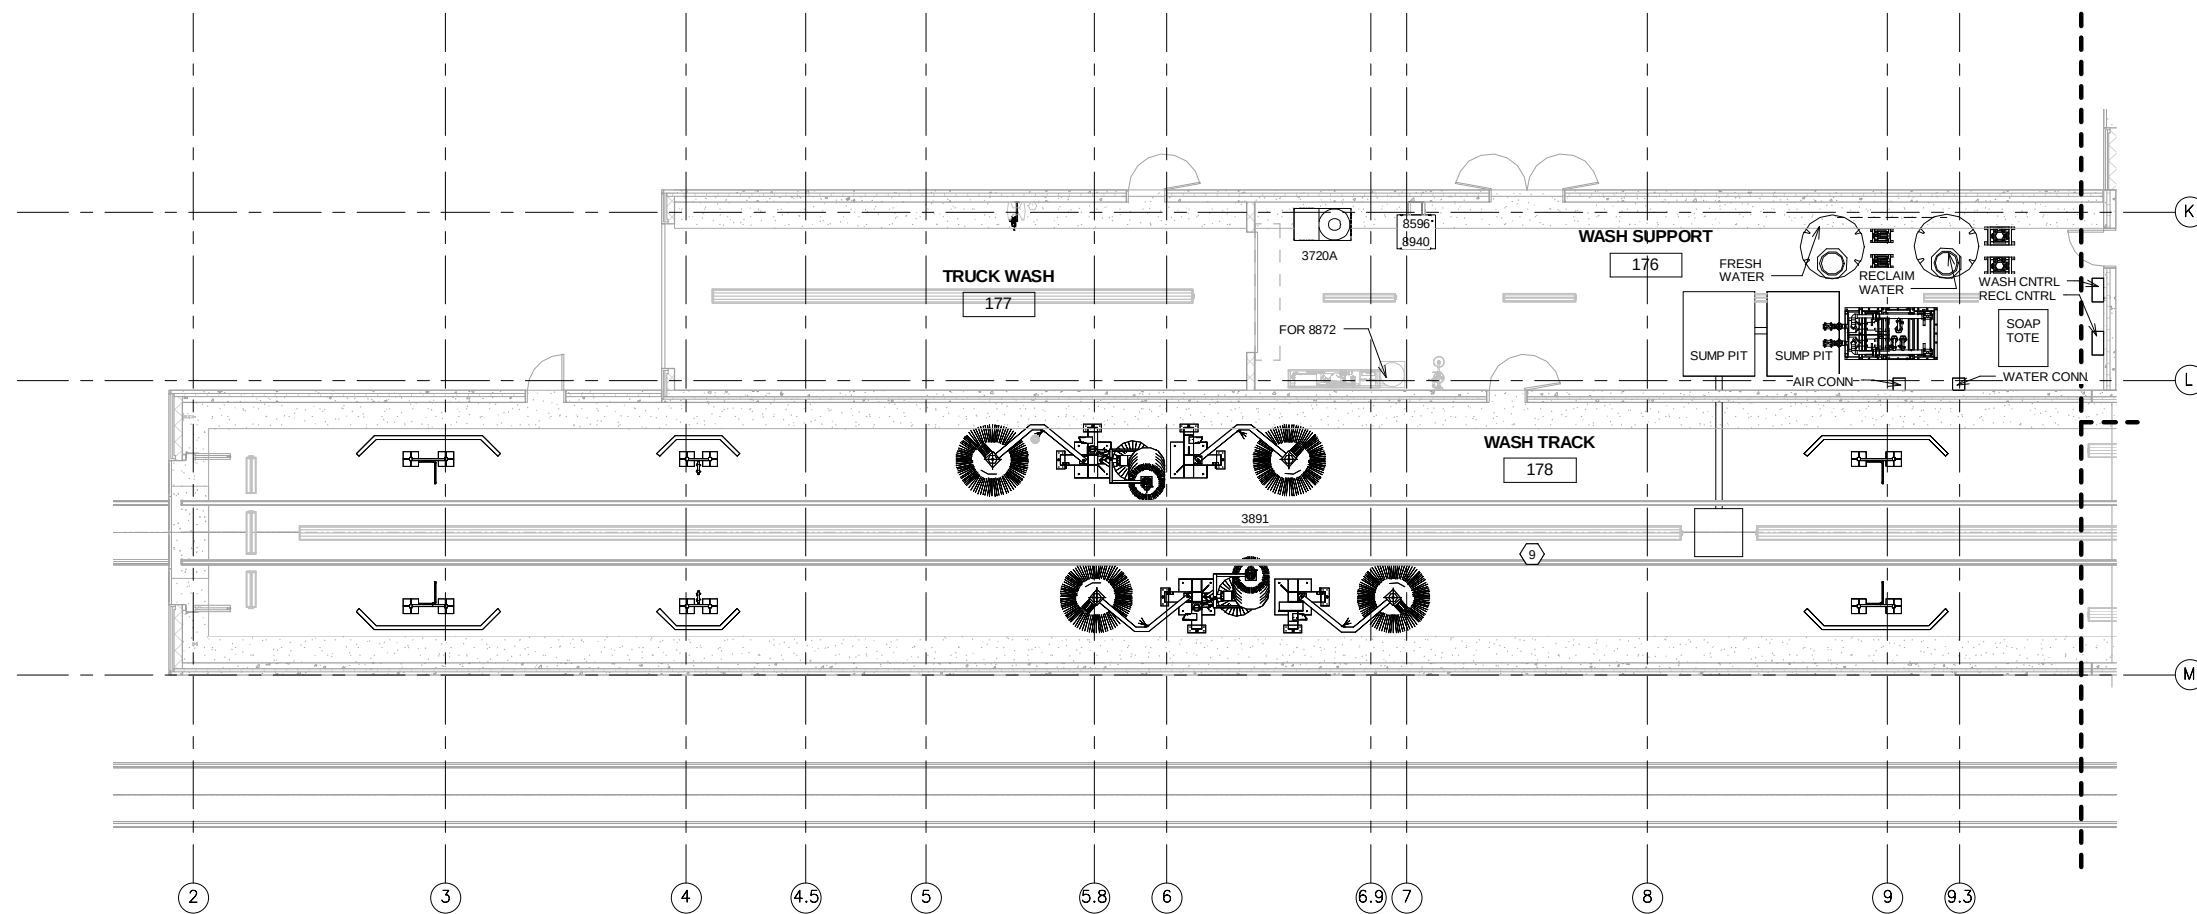

① LEVEL ONE - AREA L
 $1/8" = 1'-0"$

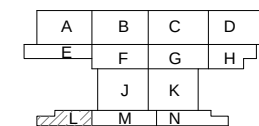

KEY PLAN - SCALE: N.T.S.

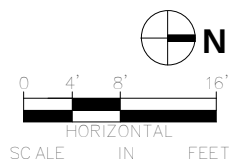[illegible]

AECOM **PARSONS**
BRINCKERHOFF

60% SUBMISSION - 09/28/15



OPERATIONS & MAINTENANCE FACILITY -V2B INDUSTRIAL	S
--	---

LEVEL ONE ENLARGED PLANS AREA L

DISCIPLINE:

INDUSTRIAL

	SHEET NAME:
--	--------------------

AME:
OMF-IND-PLN

I110L


SHEET

255


OF

263


9/22/2015 8:51:52 AM R:\PROJECTS\19140A - SWLRT FDD\Drawings\OMF_IND\ST.RVT (INDUSTRIAL).rvt

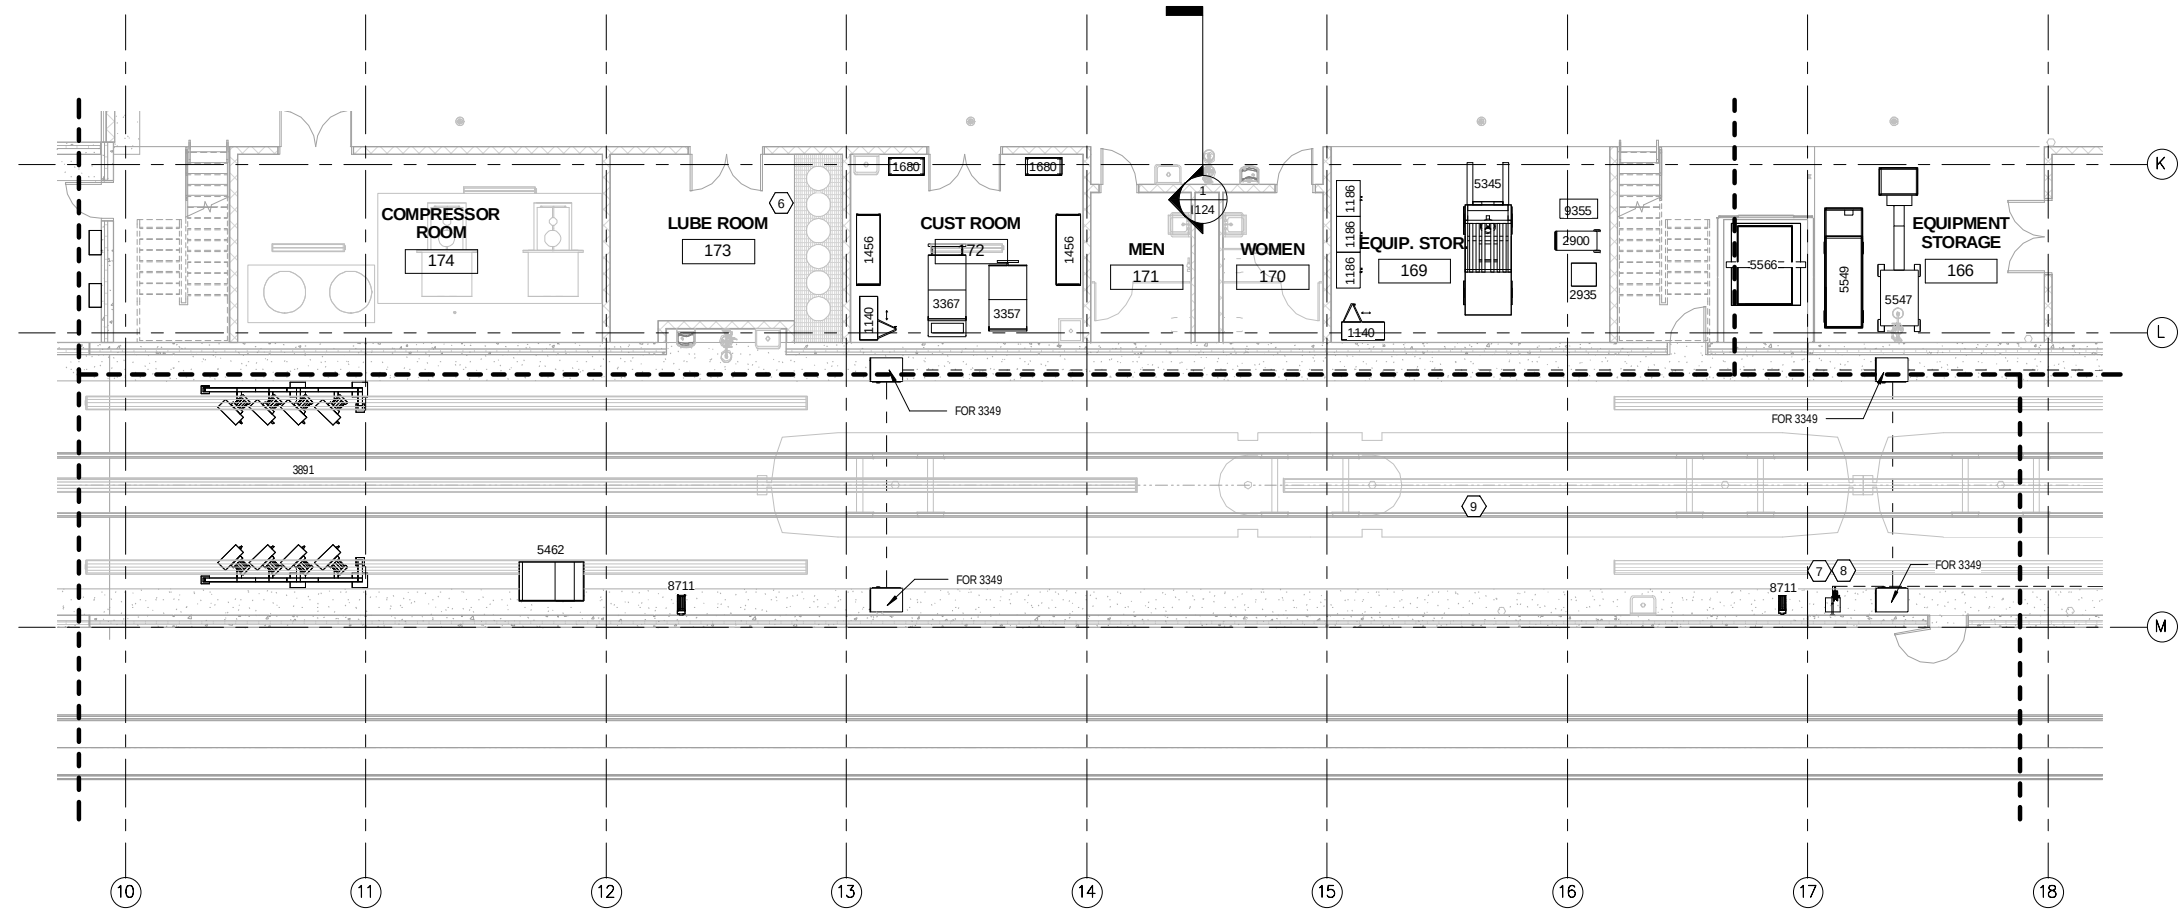

① LEVEL ONE - AREA M
1/8" = 1'-0"

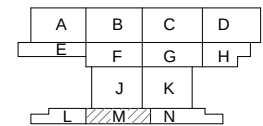


KEY PLAN - SCALE: N.T.S.

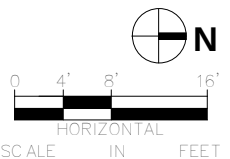


NO	DATE	BY	CHECK	DESIGN	REVISION / SUBMITTAL


 	  	OPERATIONS & MAINTENANCE FACILITY -V2B		SHEET 256
		INDUSTRIAL		
60% SUBMISSION - 09/28/15		LEVEL ONE ENLARGED PLANS AREA M		INDUSTRIAL
		OMF-IND-PLN		

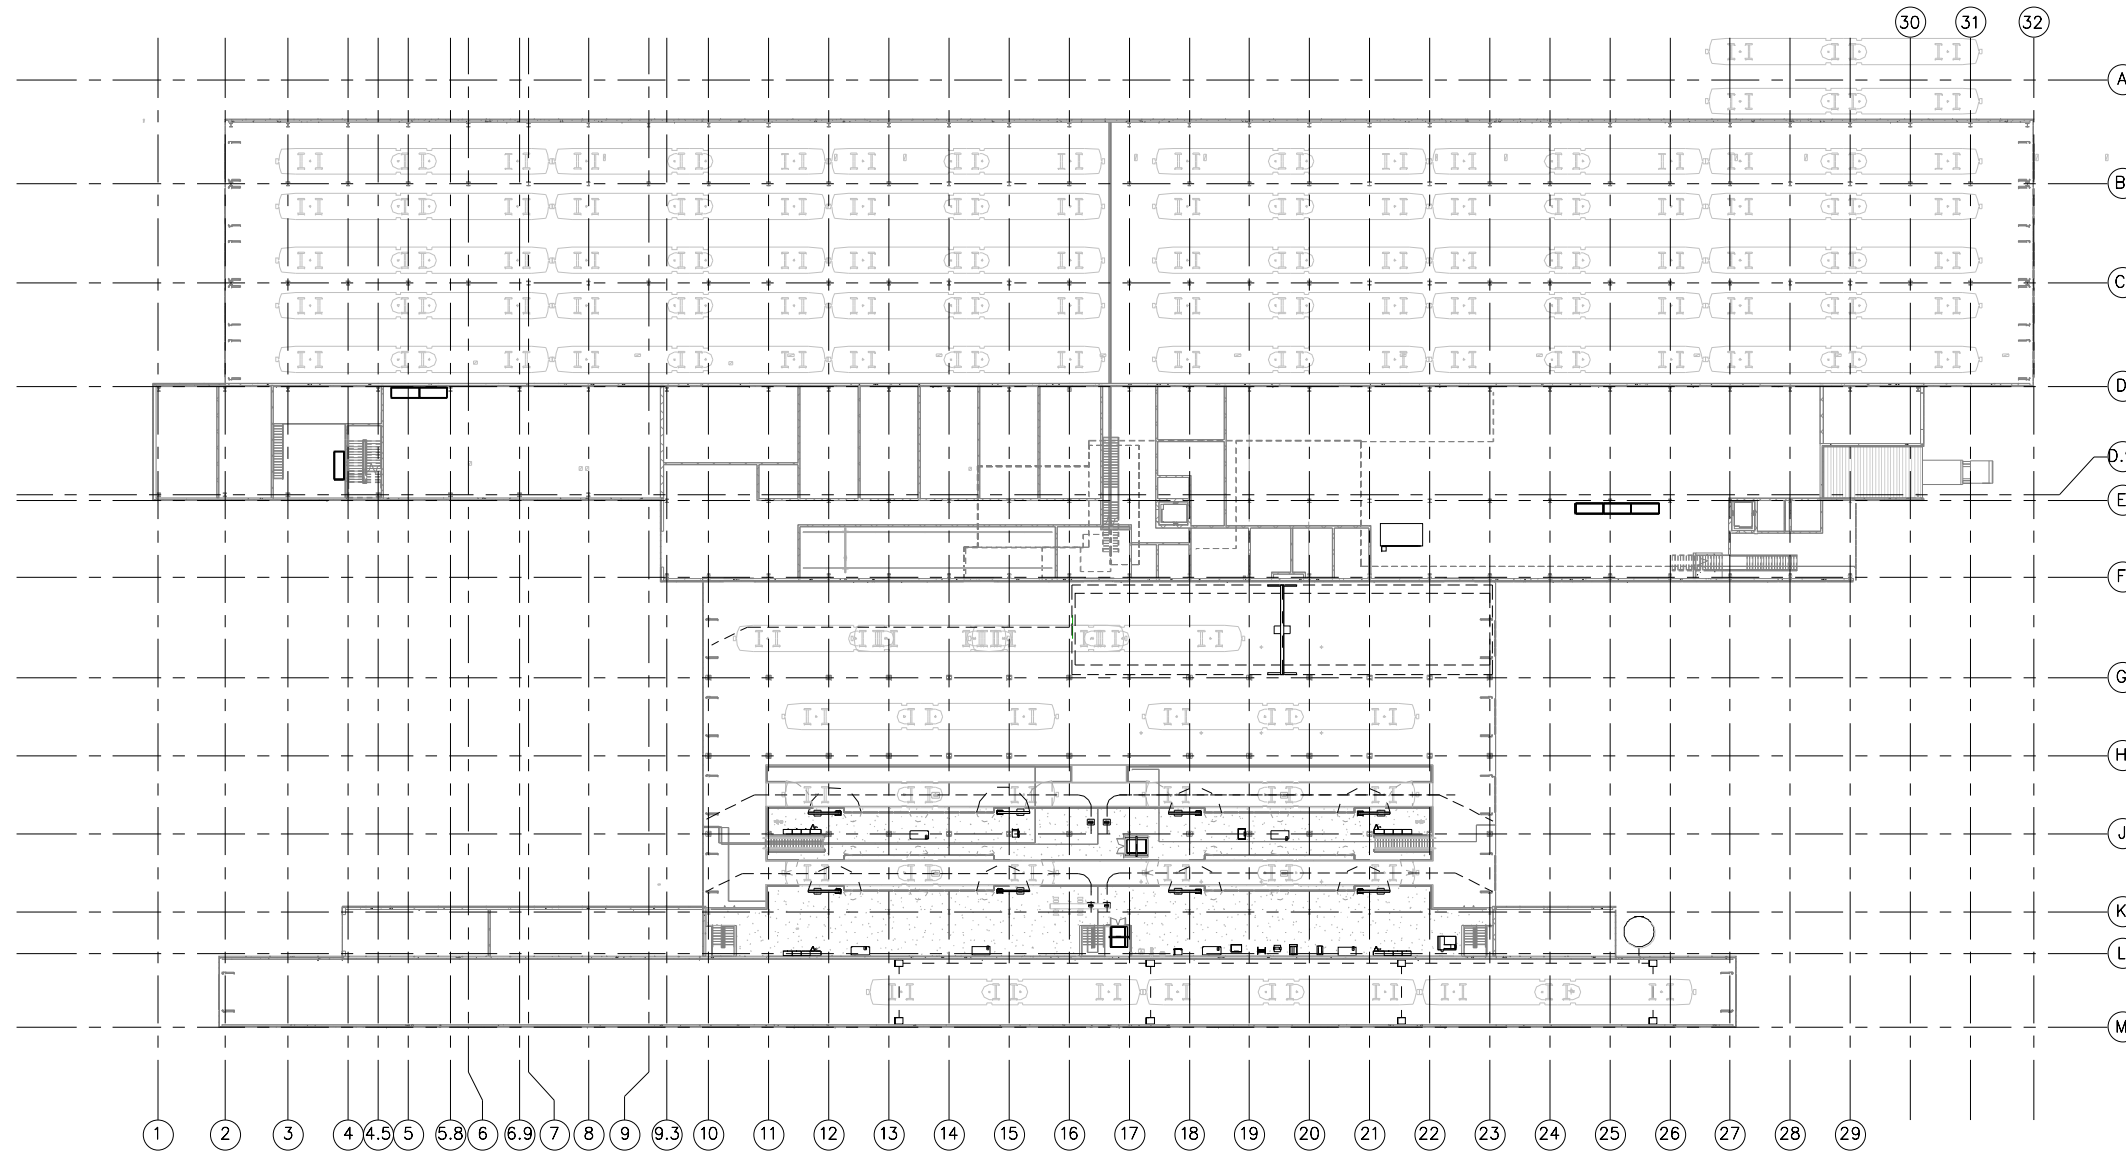

① MEZZANINE LEVEL - OVERALL PLAN
1/32" = 1'-0"

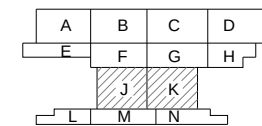

KEY PLAN - SCALE: N.T.S.

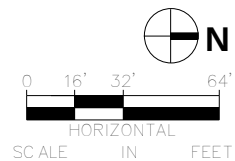[illegible]

AECOM **PARSONS**
BRINCKERHOFF

60% SUBMISSION - 09/28/15




OPERATIONS & MAINTENANCE FACILITY -V2B INDUSTRIAL	S
--	---

MEZZANINE LEVEL OVERALL FLOOR PLAN


DISCIPLINE:	INDUSTRIAL
-------------	-------------------

SHEET NAME:	OMF-IND-PLN
-------------	-------------


1115

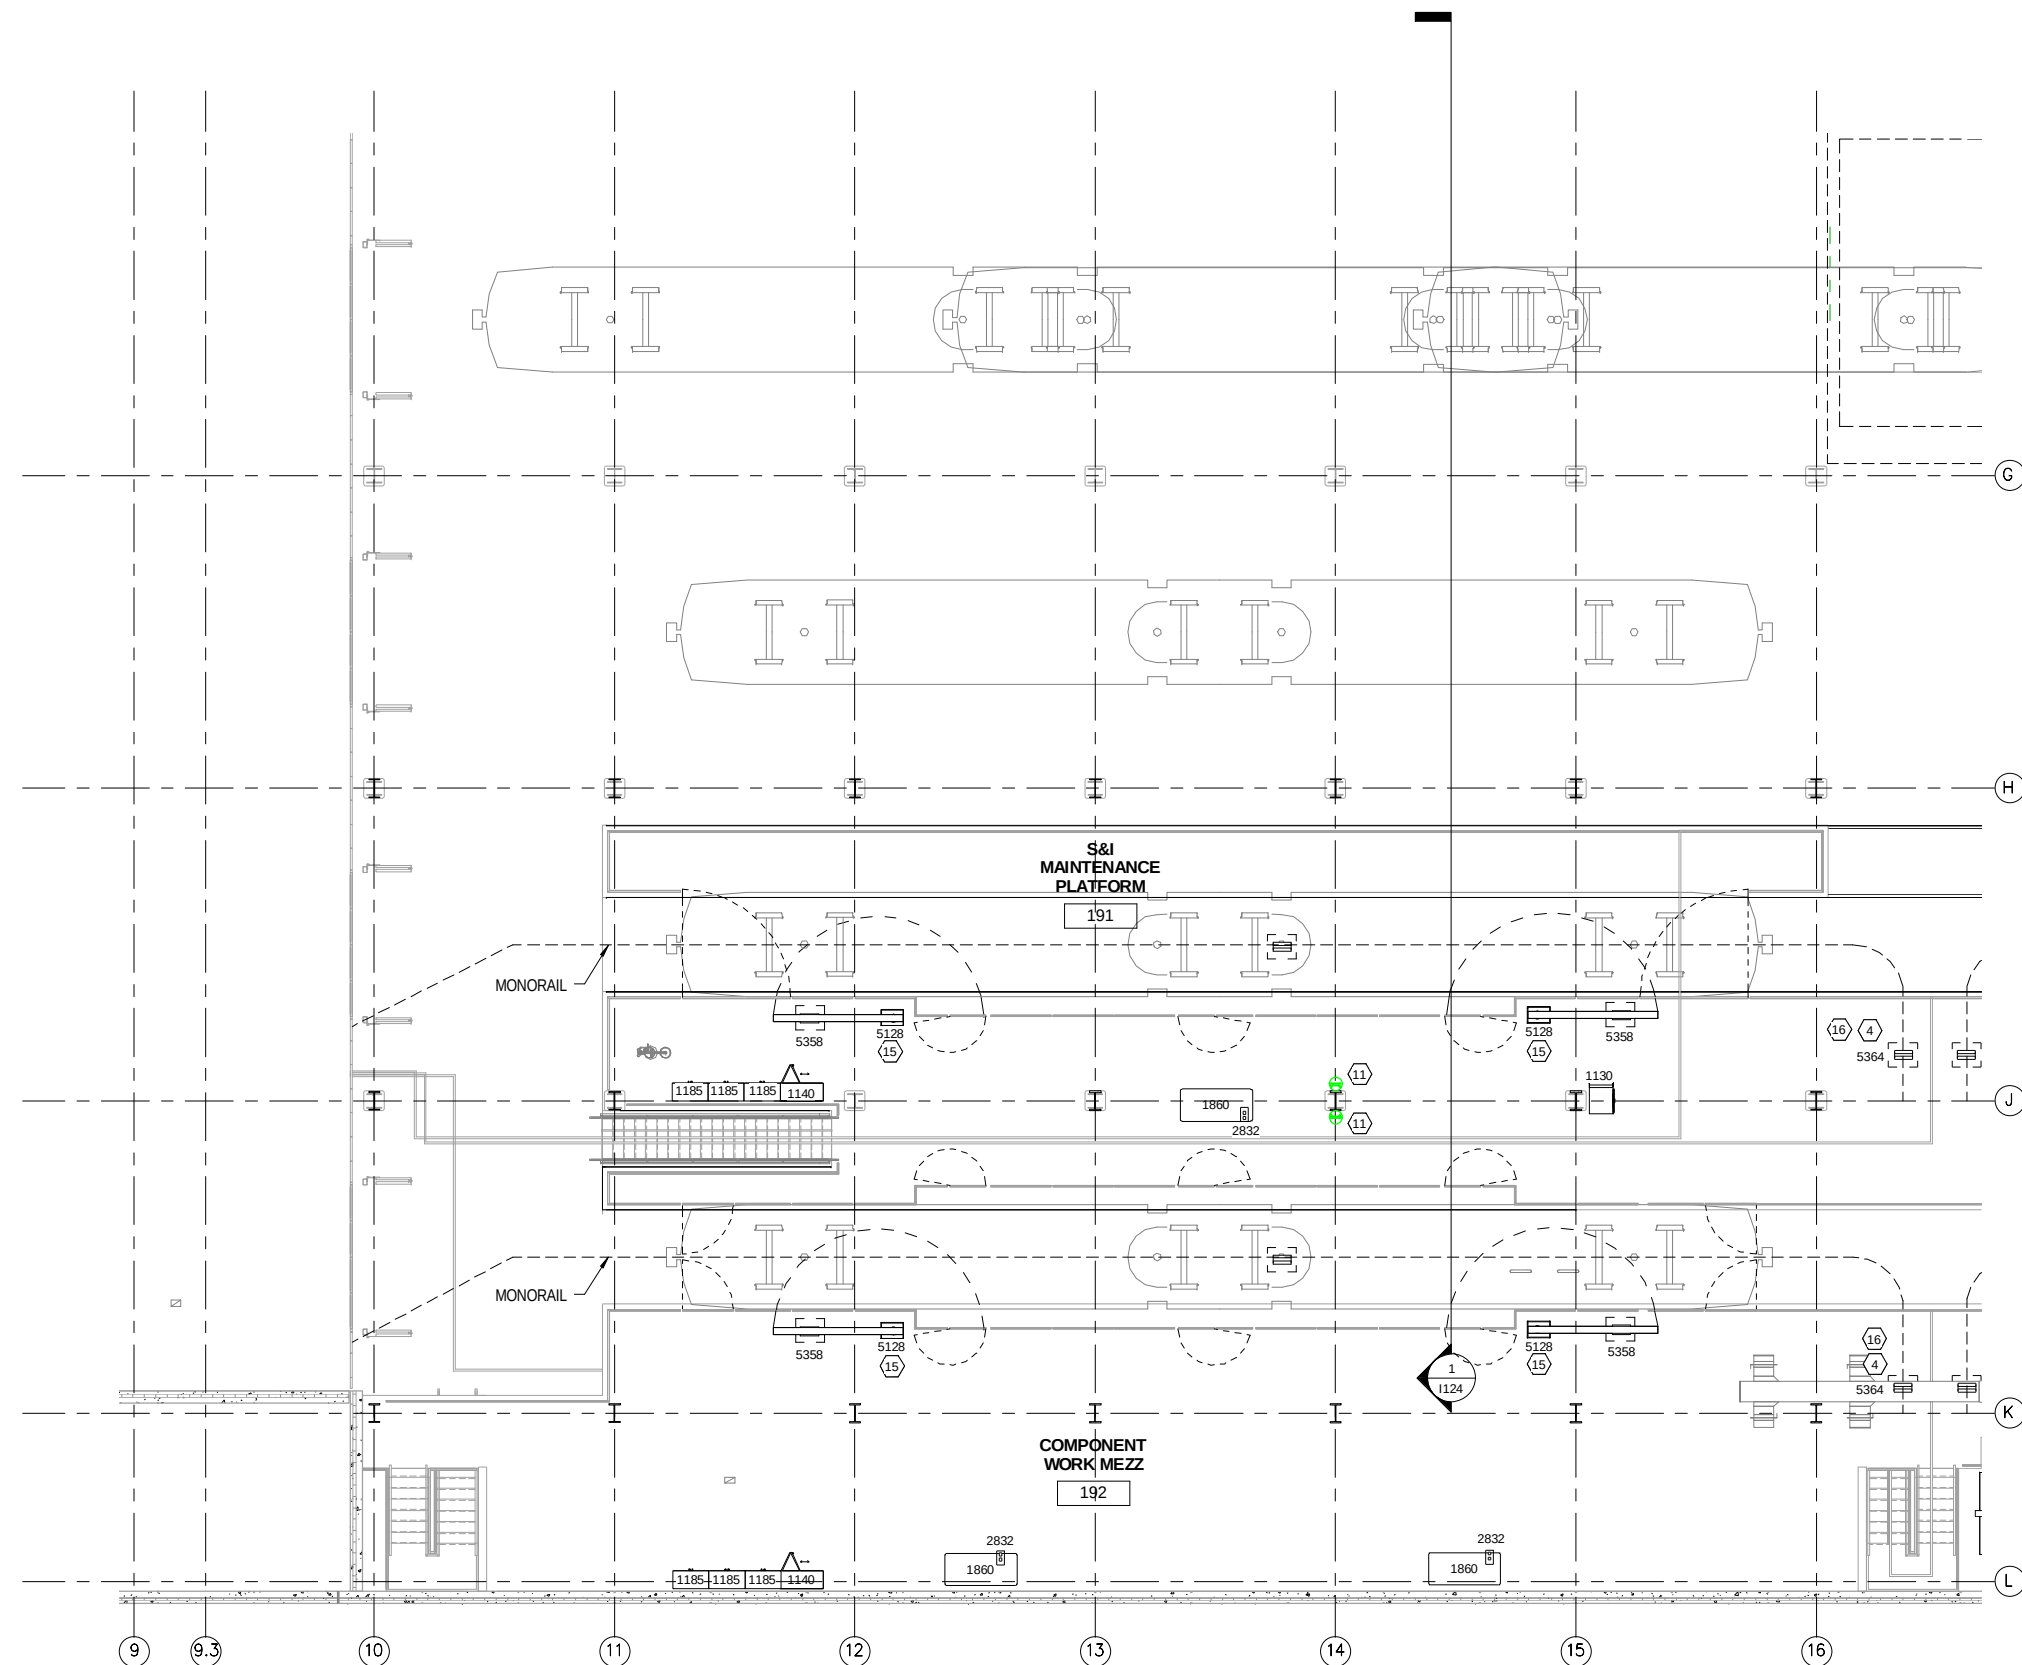

① MEZZANINE LEVEL - AREA J
1/8" = 1'-0"

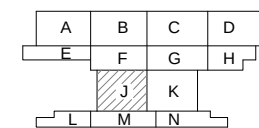

KEY PLAN - SCALE: N.T.S.

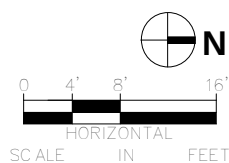[illegible]

AECOM **PARSONS**
BRINCKERHOFF

60% SUBMISSION - 09/28/15




OPERATIONS & MAINTENANCE FACILITY -V2B	S
INDUSTRIAL	

MEZZANINE LEVEL ENLARGED PLANS J


DISCIPLINE: **INDUSTRIAL**

SHEET NAME:	OMF-IND-PLN
-------------	-------------


1120

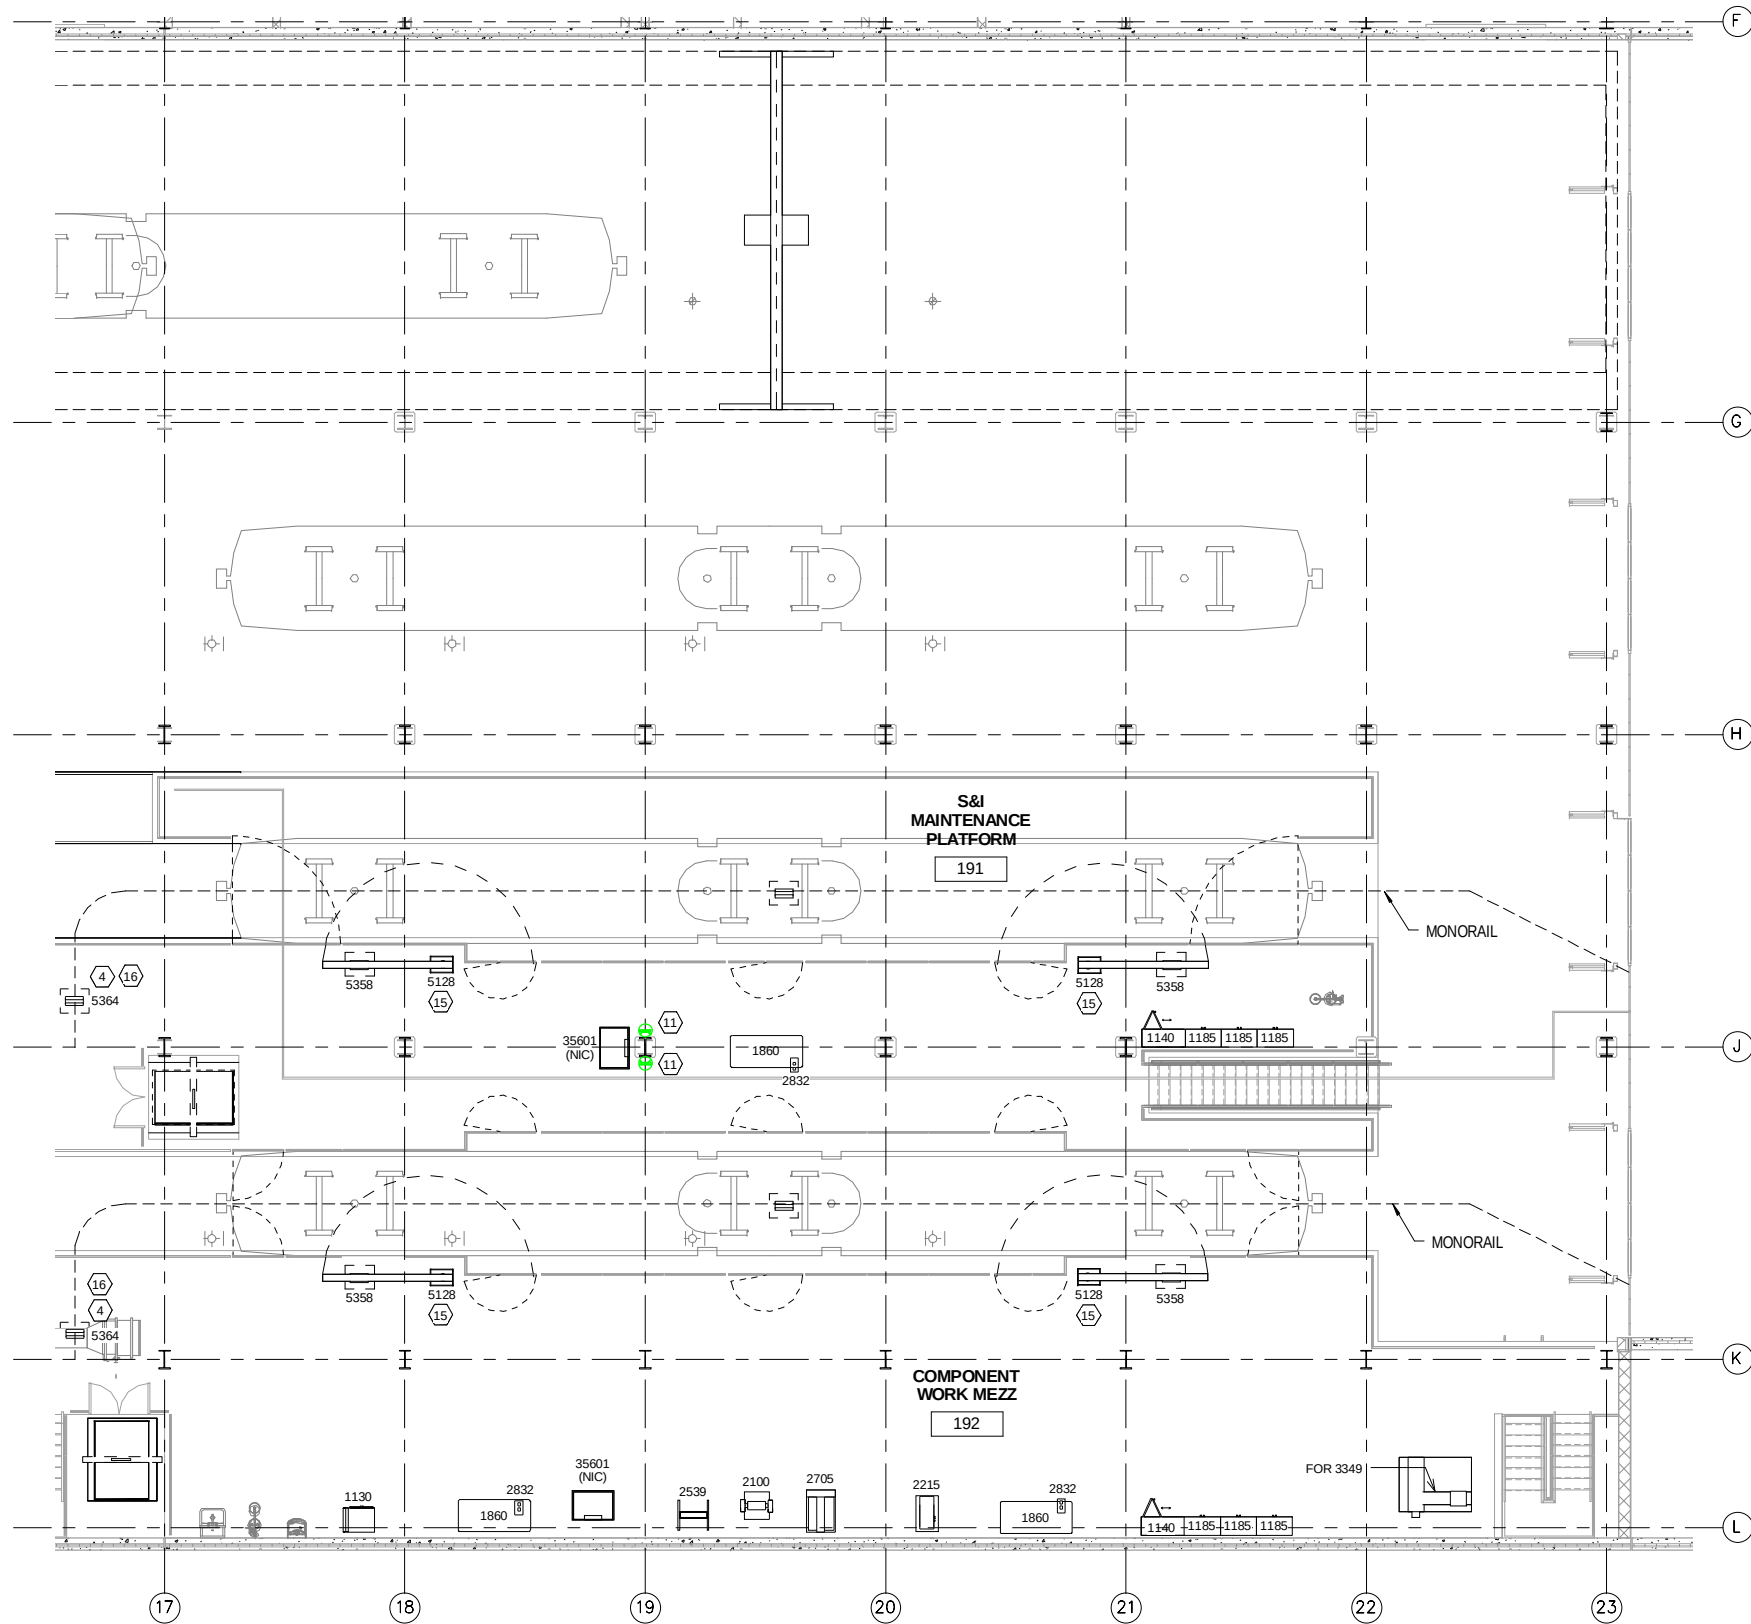

① MEZZANINE LEVEL - AREA K
1/8" = 1'-0"

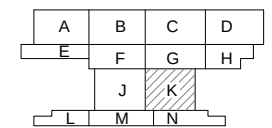

KEY PLAN - SCALE: N.T.S.

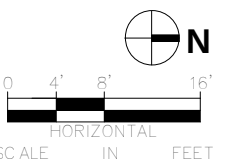[illegible]

AECOM **PARSONS**
BRINCKERHOFF

60% SUBMISSION - 09/28/15



OPERATIONS & MAINTENANCE FACILITY -V2B INDUSTRIAL	SP
--	----


MEZZANNINE LEVEL ENLARGED PLANS K

DISCIPLINE: **INDUSTRIAL**


SHEET NAME:	OMF-IND-PLN
-------------	-------------

121

9/22/2015 8:52:05 AM R:\PROJECTS\19140A - SWLRT FDD\Drawings\OMF_IND.ST.RVT (INDUSTRIAL).rvt

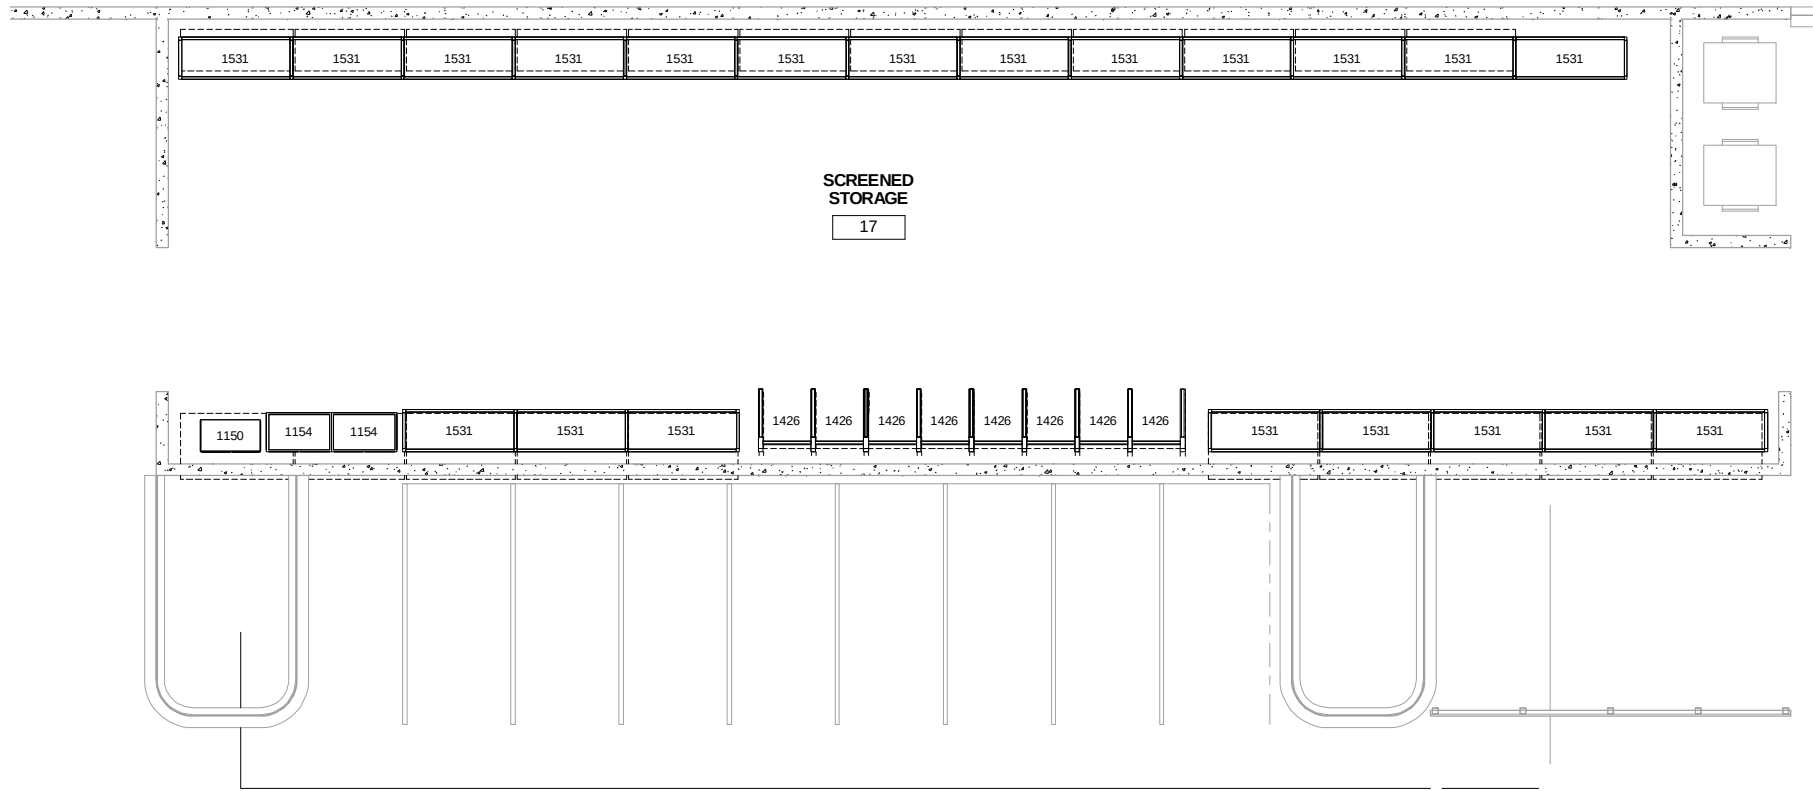

① LEVEL ONE-SCREENED STORAGE
1/8" = 1'-0"

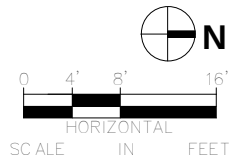

NO	DATE	BY	CHECK	DESIGN	REVISION / SUBMITTAL





60% SUBMISSION - 09/28/15




OPERATIONS & MAINTENANCE FACILITY -V2B
INDUSTRIAL
SCREENED STORAGE

DISCIPLINE:
INDUSTRIAL


SHEET NAME:
OMF-IND-PLN

I122


9/22/2015 8:52:06 AM R:\PROJECTS\19140A - SWLRT FDD\Drawings\OMF_IND-ST.RVT (INDUSTRIAL).rvt

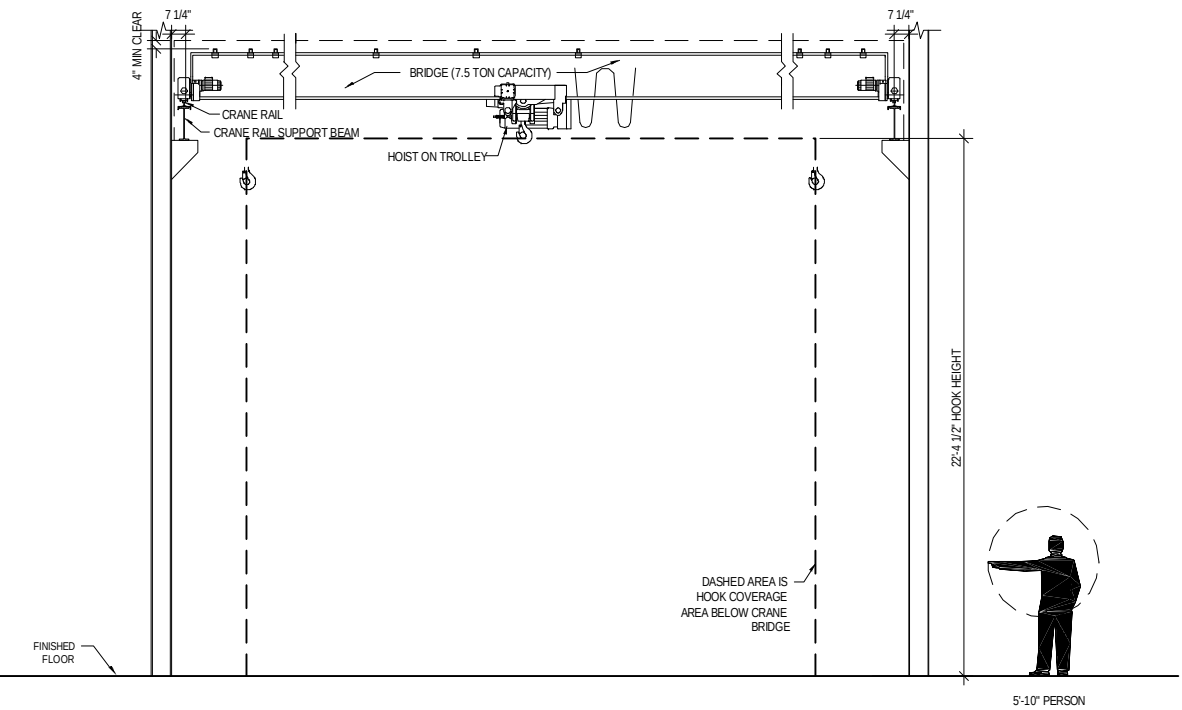

① 7.5 Ton Capacity Top Running Bridge Crane
1/4" = 1'-0"

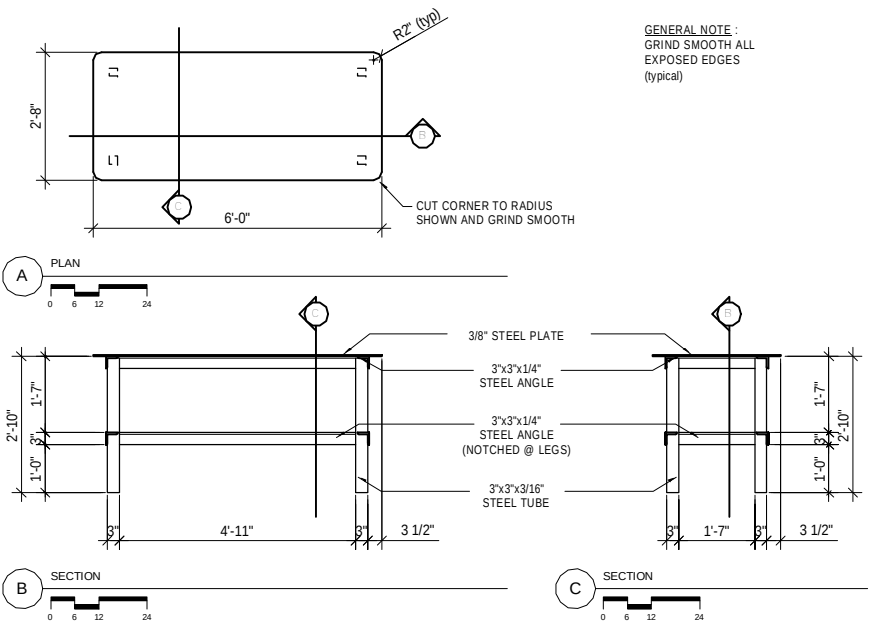

③ Workbench
1/2" = 1'-0"

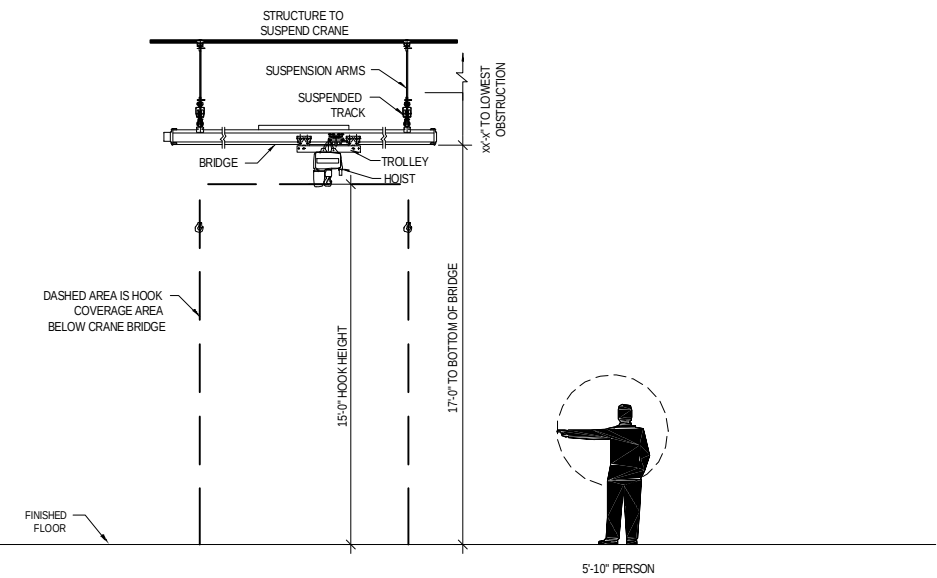

② .5 Ton Capacity Suspended Bridge Crane
1/4" = 1'-0"

NO	DATE	BY	CHECK	DESIGN	REVISION / SUBMITTAL

AECOM

**PARSONS
BRINCKERHOFF**

METROPOLITAN

SOUTHWEST

Green Line LRT Extension

60% SUBMISSION - 09/28/15

OPERATIONS & MAINTENANCE FACILITY -V2B

INDUSTRIAL

EQUIPMENT DETAILS

DISCIPLINE:

INDUSTRIAL

SHEET NAME:

OMF-IND-PLN

I123


SHEET

262

OF

263

9/22/2015 8:52:12 AM R:\PROJECTS\19140A - SWLRT FDD\Drawings\OMF - SWLRT FDD\Drawings\IND-IND-PLN-INDUST.RVT (INDUSTRIAL).rvt

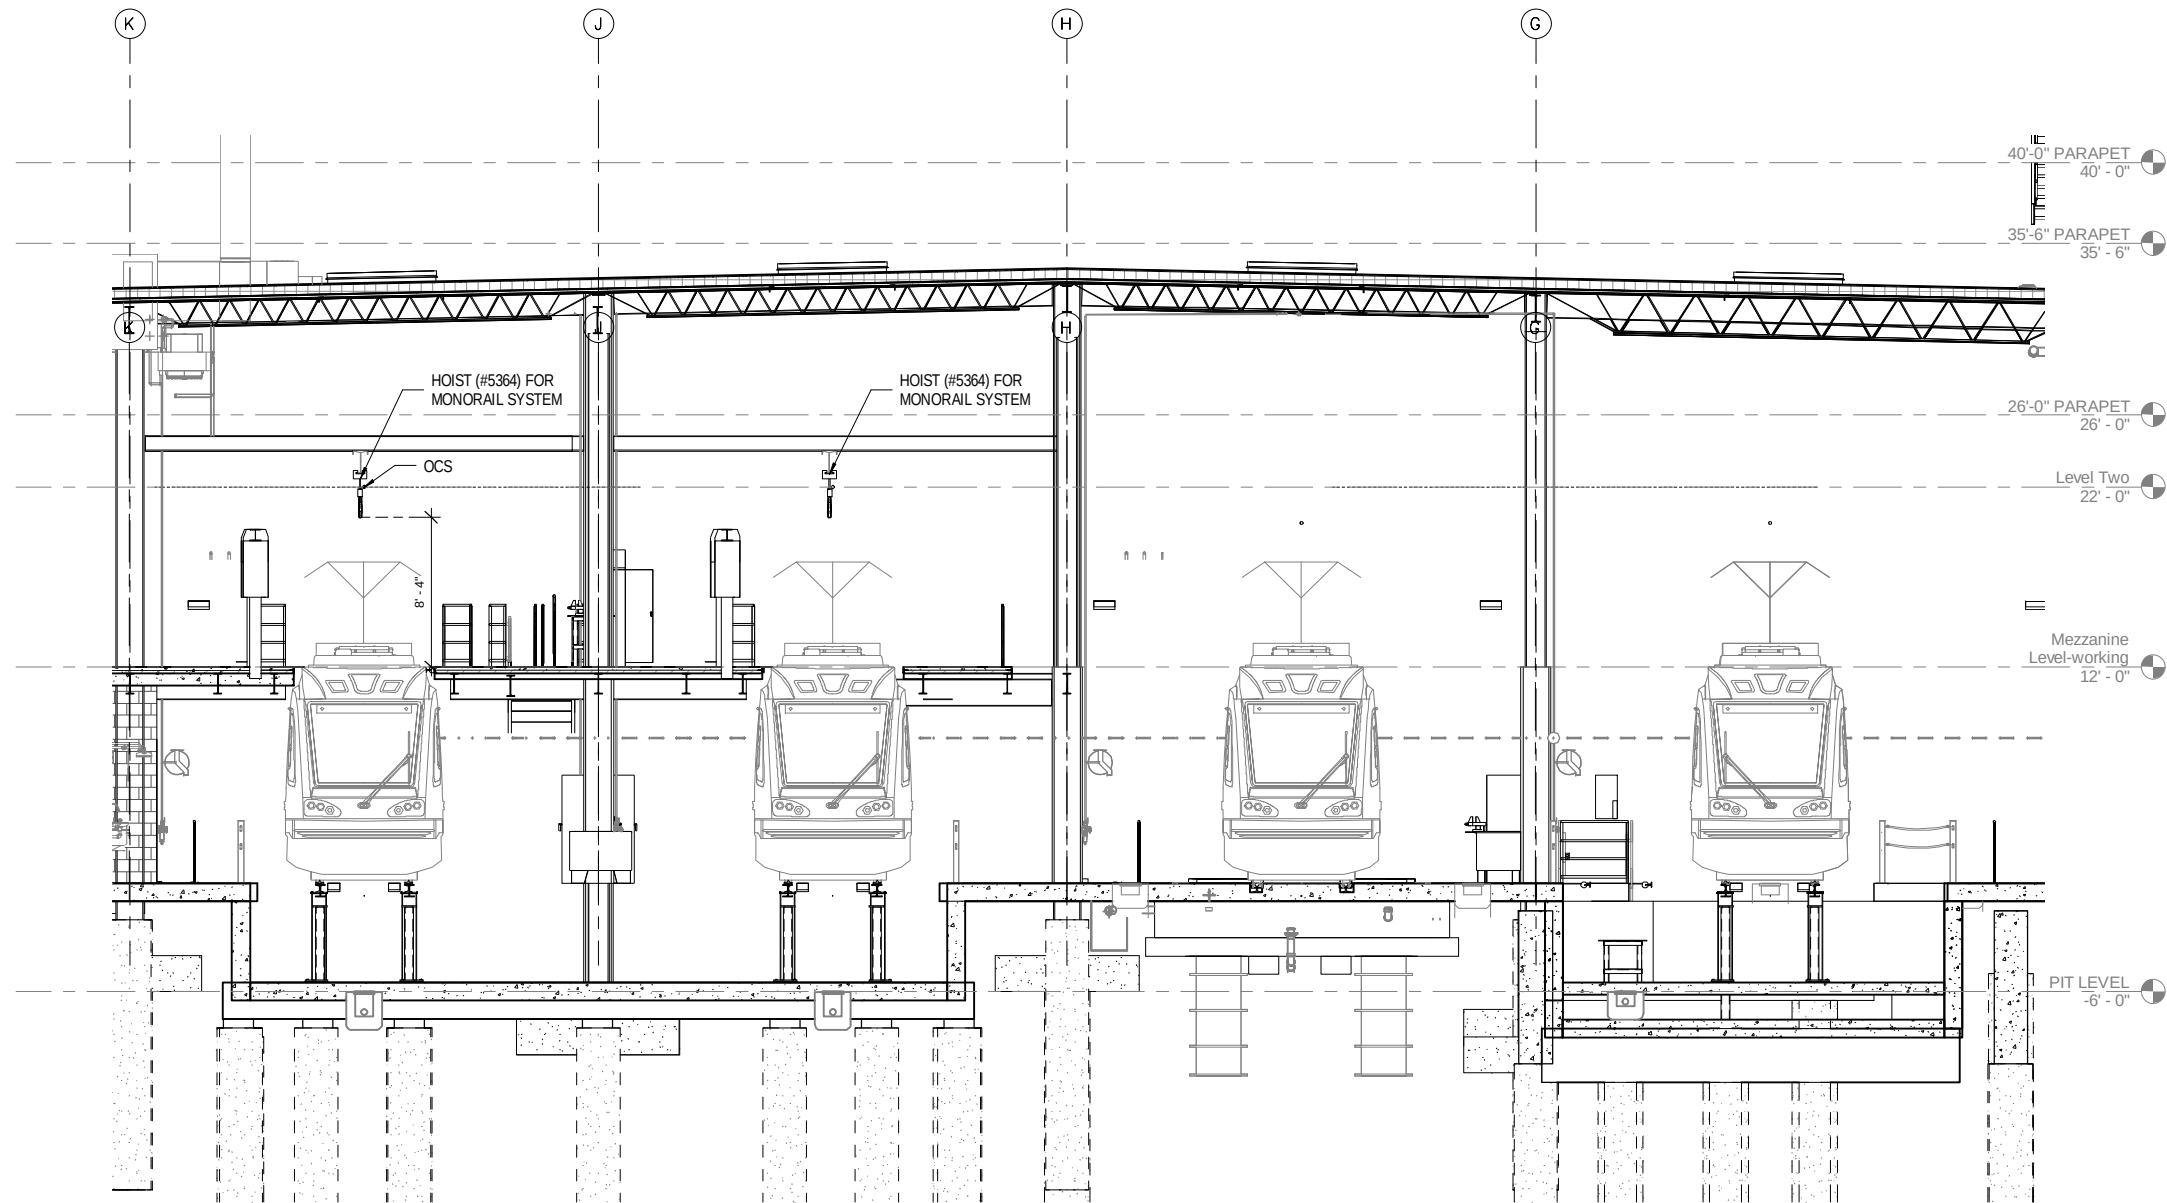

1 SECTION MONORAIL ON TRACKS
3/16" = 1'-0"

NO	DATE	BY	CHECK	DESIGN	REVISION / SUBMITTAL

AECOM **PARSONS
BRINCKERHOFF**

60% SUBMISSION - 09/28/15



OPERATIONS & MAINTENANCE FACILITY -V2B
INDUSTRIAL
EQUIPMENT DETAILS

DISCIPLINE:
INDUSTRIAL

SHEET NAME:
OMF-IND-PLN

I124

SHEET
263
OF
263